


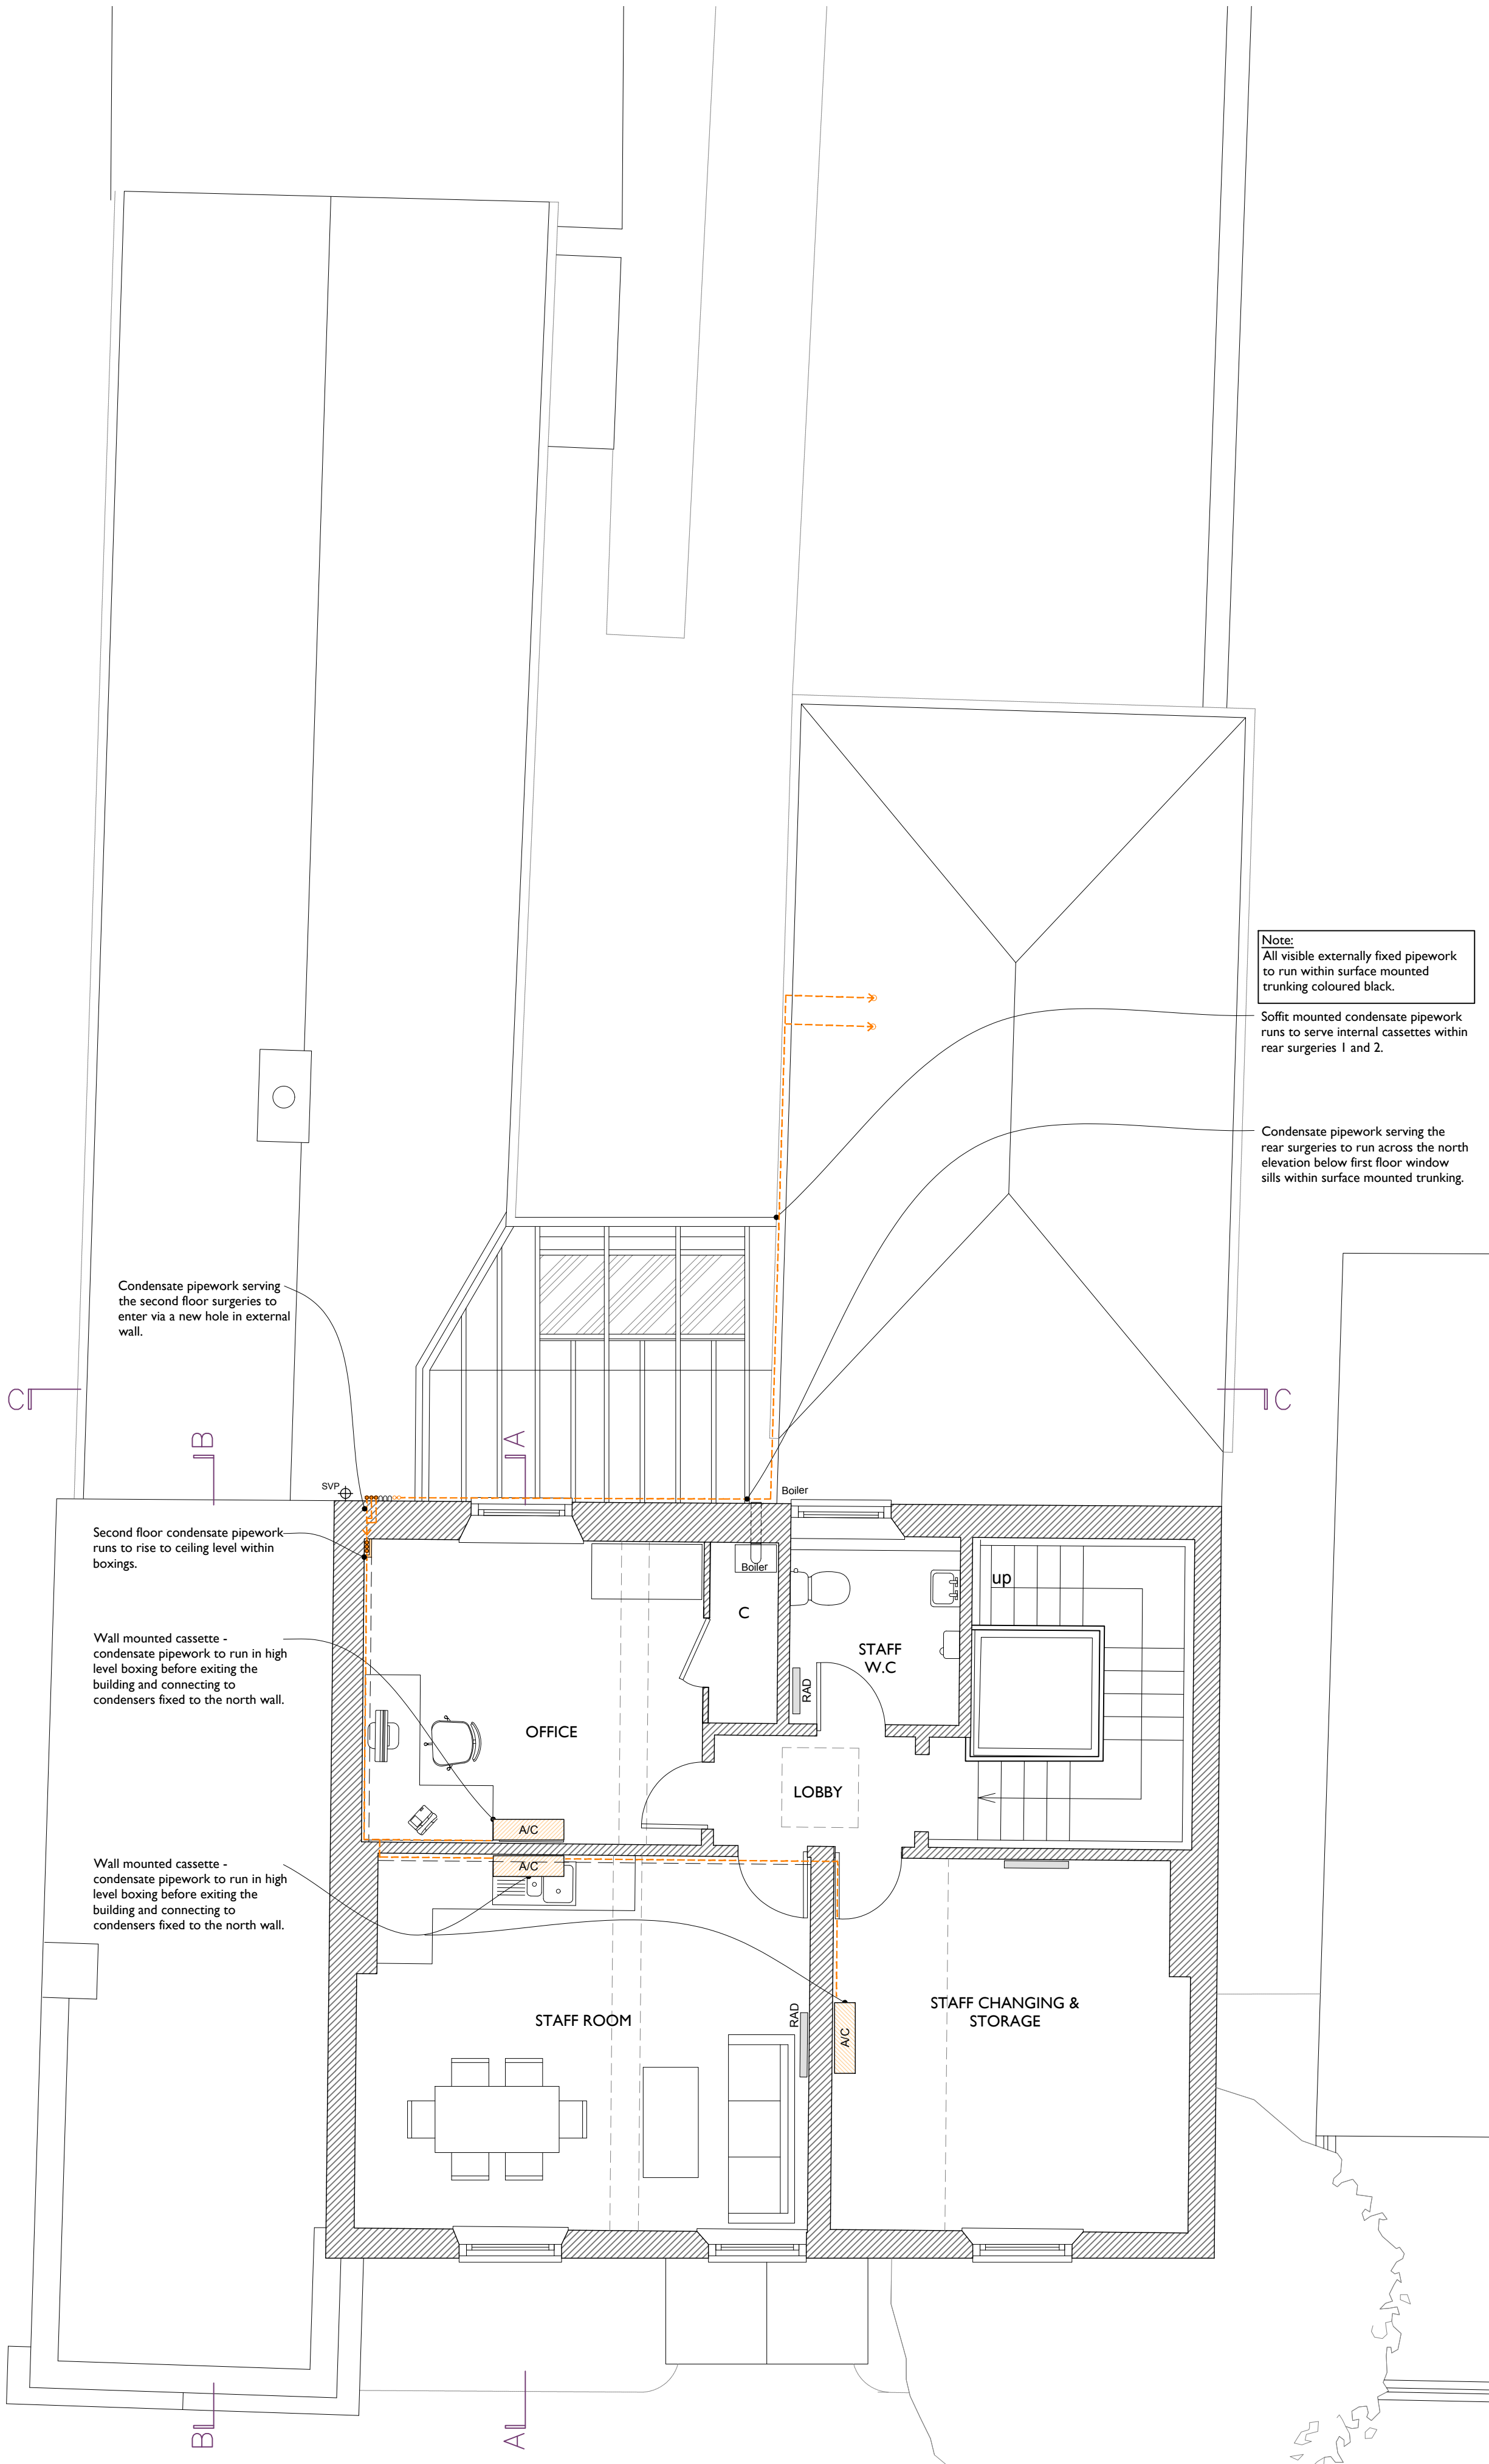

Check all dimensions on site prior to commencement of work.
Do not scale from this drawing except for planning purposes.

This drawing is the © copyright of

VALLIS & HALL
CONSERVATION ARCHITECTS

This drawing has been produced for **Abbas Visanji** for the project **Magnolia House - Airconditioning** and is submitted as part of the **Planning and Listed Building Consent Application** and is not intended for use by any other person or for any other purpose.

Notes -

LEGEND

-  = A/C Cassette
-  = Indicative Condensate Pipe Run
-  = External Condenser Unit

A/C CASSETTE & CONDENSER SCHEDULE:

Ground Floor:

- A/C Unit 1 - Daikin 5MXM90A9 to serve:
- Front Surgery
 - Middle Surgery
 - Waiting Room

- A/C Unit 2 - Daikin 5MXM90A9 to serve:
- Reception
 - Rear Surgery 1
 - Rear Surgery 2

- A/C Unit 3 - Daikin RXP25N9 to serve:
- Accessible Surgery

First Floor:

- A/C Unit 4 - Daikin 4MXM80N to serve:
- Surgery 1
 - Surgery 2
 - Waiting Area

Second Floor:

- A/C Unit 5 - Daikin 4MXM80A9 to serve:
- Office
 - Staff Room
 - Changing Room



Middle Barn
Oak Lane
Chichester
PO20 7FD

T : 01243 767151
E : mail@vallisandhall.com
W: www.vallisandhall.com

RIBA 
Chartered Practice

Revisions

Rev	Description	Date	Drawn
A	A/C Units 4 & 5 relocated in response to planning comments.	01/11/2024	AH
B	A/C pipework routes revised.	19/11/2024	AH

Project:

Magnolia House, Havant,
A/C Installation

Drawing Title:

**As Proposed
Ground Floor Plan**

Scale:
1:50 at A1

Issue Date:
29/08/2024

Drawing No.
692/PL 102

Revision.
B

Drawn By:
AH