


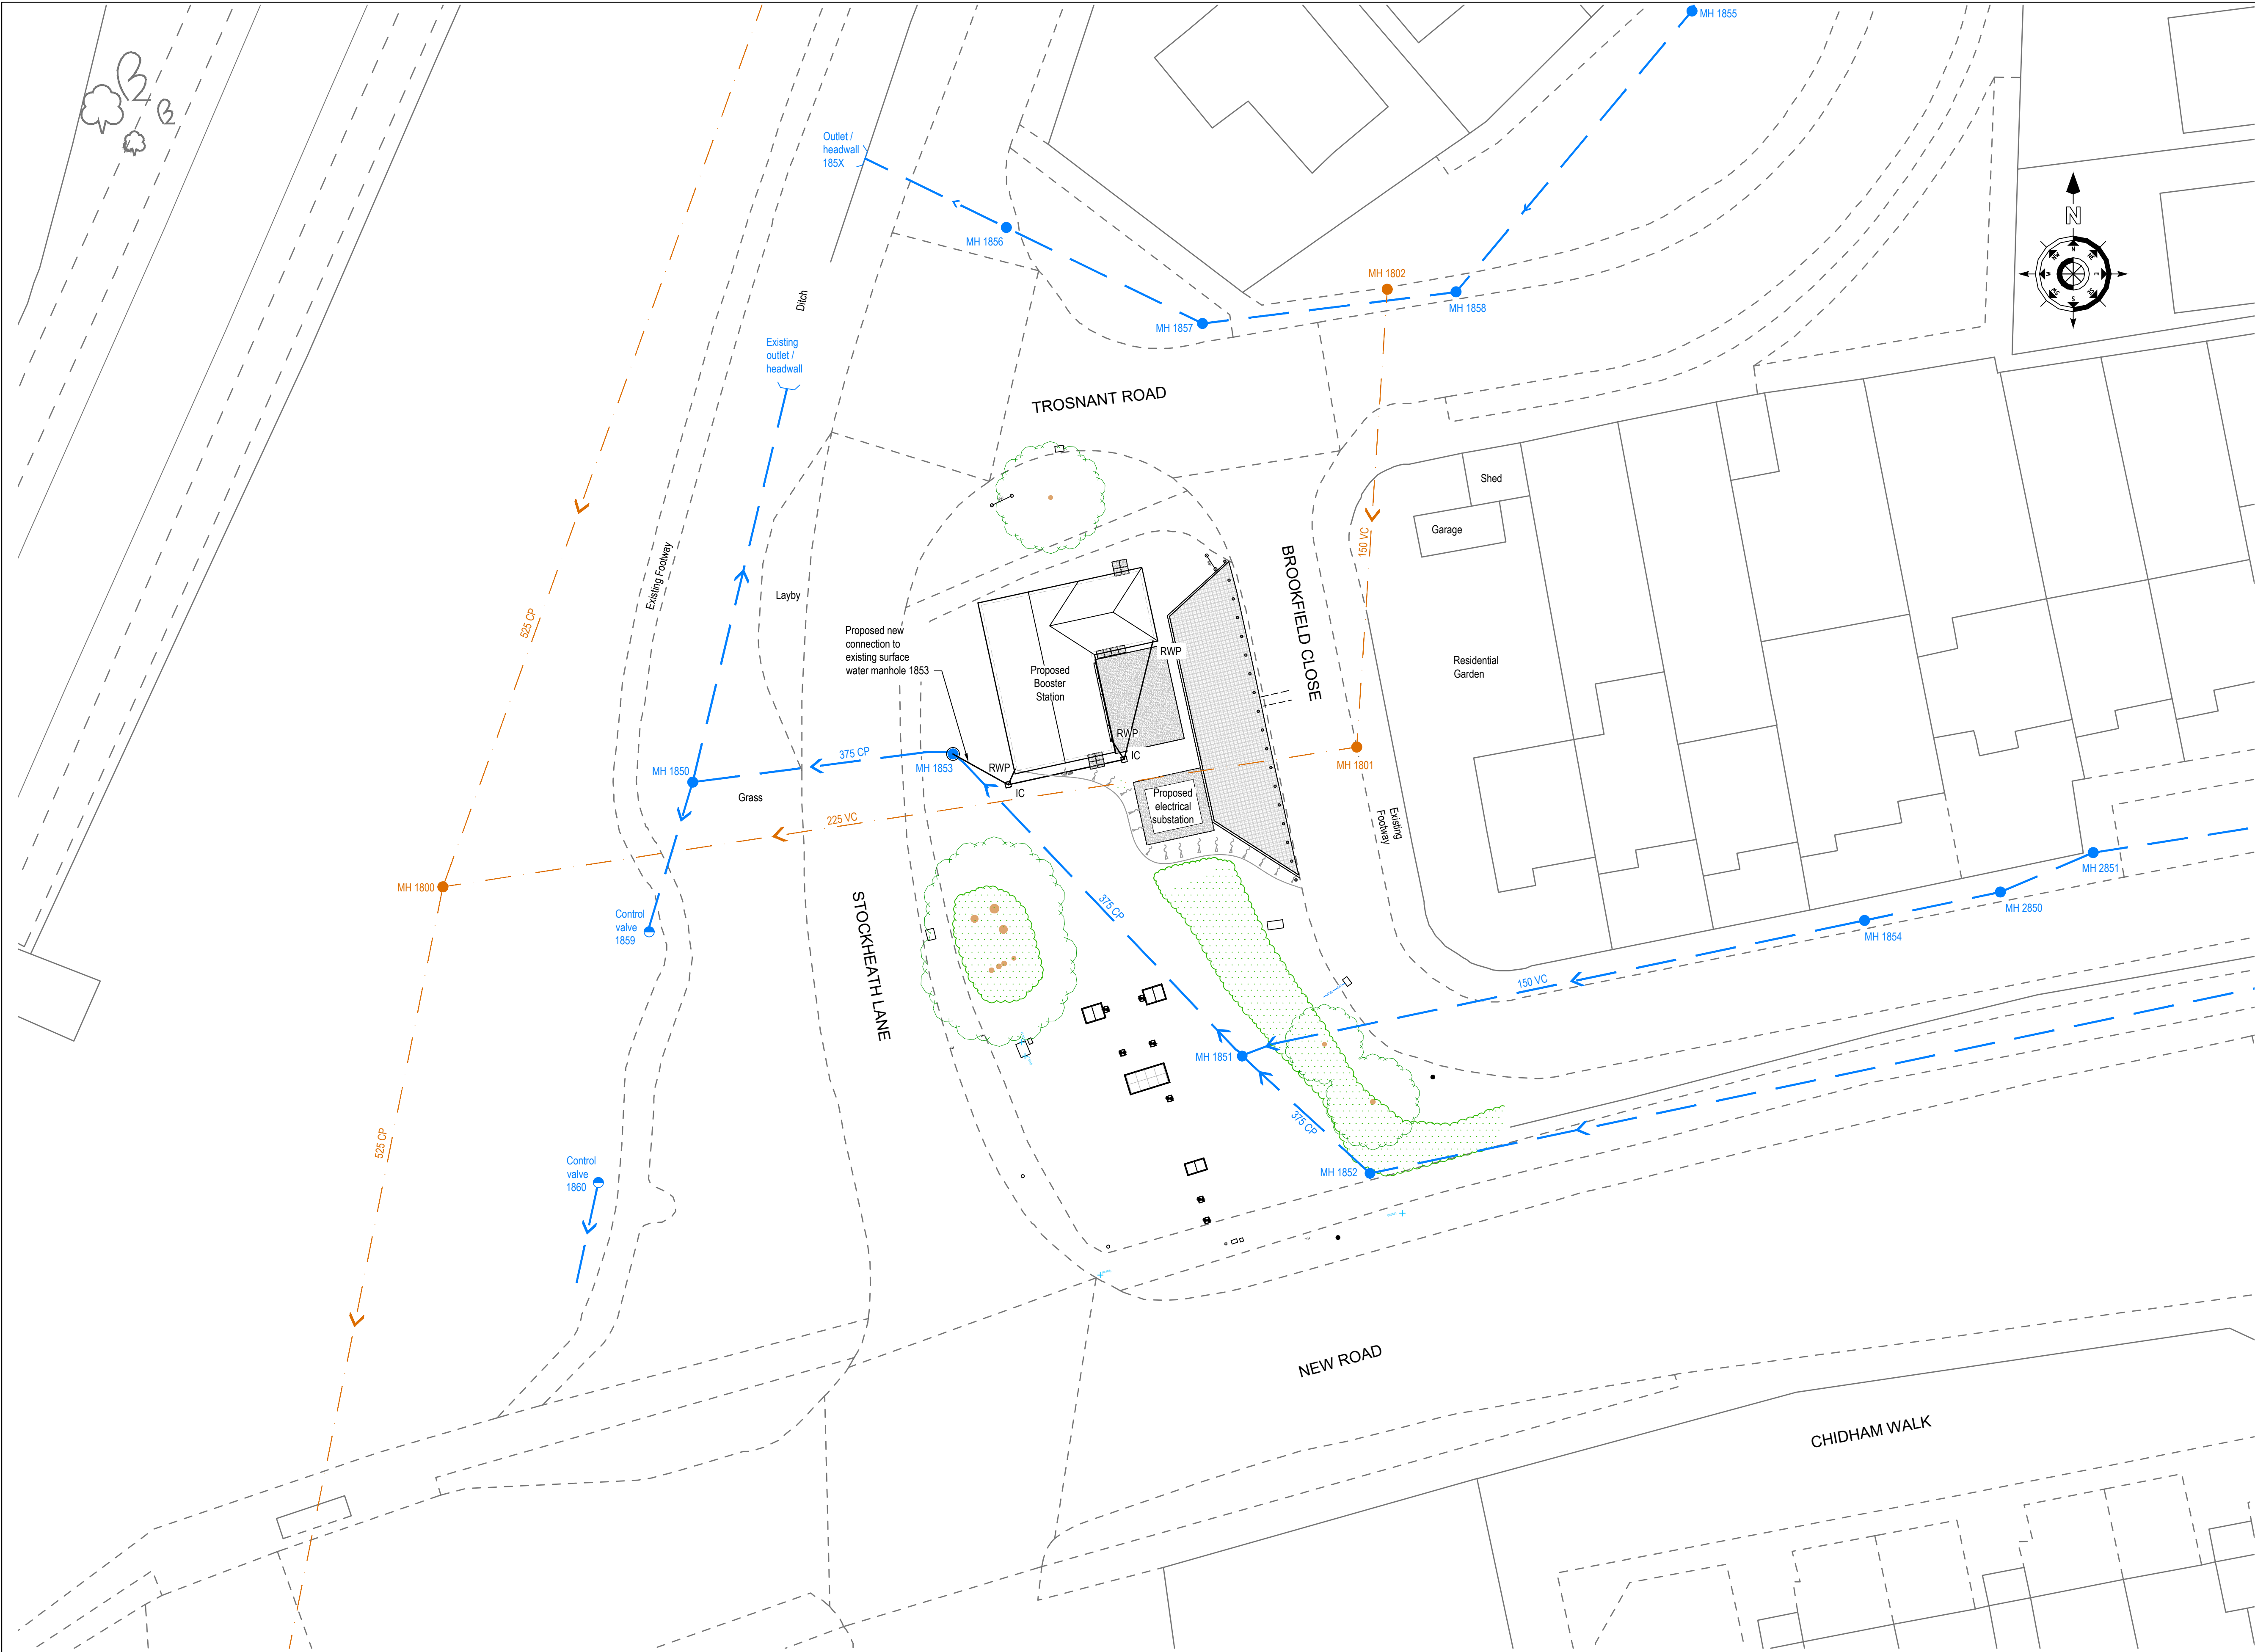


Notes:

- ALL DIMENSIONS IN MILLIMETRES & ALL LEVELS IN METRES UNLESS SHOWN OTHERWISE.
- SEE DRG. S847.11-IDS-PW-RT-DR-C-0013 FOR PROPOSED ROOF DRAINAGE DETAILS.

LEGEND

- EXISTING SOUTHERN WATER SURFACE WATER SEWER
- EXISTING SOUTHERN WATER SURFACE WATER MANHOLE
- EXISTING SOUTHERN WATER CONTROL VALVE
- EXISTING SOUTHERN WATER FOUL WATER SEWER
- EXISTING SOUTHERN WATER FOUL WATER MANHOLE
- PROPOSED ROOF DRAINAGE SYSTEM TO BE CONNECTED TO EXISTING SURFACE WATER NETWORK

 - DRAWING REFERENCES
- S847.11-IDS-PW-RT-DR-C-0010 SITE LOCATION PLAN
 - S847.11-IDS-PW-RT-DR-C-0011 EXISTING SITE PLAN
 - S847.11-IDS-PW-RT-DR-C-0012 PROPOSED SITE PLAN
 - S847.11-IDS-PW-RT-DR-C-0013 PROPOSED EQUIPMENT PLANS
 - S847.11-IDS-PW-RT-DR-C-0014 PROPOSED ELEVATIONS
 - S847.11-IDS-PW-RT-DR-C-0015 PROPOSED BUILDING ELEVATIONS
 - S847.11-IDS-PW-RT-DR-C-0016 PROPOSED LGV / SITE ACCESS / EGRESS
 - S847.11-IDS-PW-RT-DR-C-0017 PROPOSED HGV / SITE ACCESS / EGRESS
 - S847.11-IDS-PW-RT-DR-C-0018 PROPOSED EQUIPMENT BUILDING SECTIONS



CURRENT REVISION CHANGES

- GENERAL UPDATE

P01	S3	MJS	KV	JO	KK	FOR REVIEW			27/11/24
Rev	Status Code	Des By	Des By	Des By	Des By	Description			Date

TRANT Engineering Ltd.
Head Office: Rushington House,
Rushington, Southampton
SO40 9LT.
Telephone: (023) 8066 5544
E-Mail: Engineering@trant.co.uk
www.trant.co.uk

Contractors Drawing Number:
S847.11-IDS-PW-RT-DR-C-0019

Telephone: Havant (023) 9249 9888
Fax: Havant (023) 9245 3832
Website: www.portsmouthwater.co.uk
Registered Office: PO Box 8 West Street
Havant Hampshire PO9 1LG
REGISTERED IN ENGLAND No. 2536455

PIN: S847.11 Scale: 1:200 Sheet Size: A1

Project Title:
RACTON BOOSTER TRANSFER PUMPING STATION

Drawing Title:
PROPOSED SURFACE WATER SEWER CONNECTION

Portsmouth Water Drawing Number: Rev: P01