




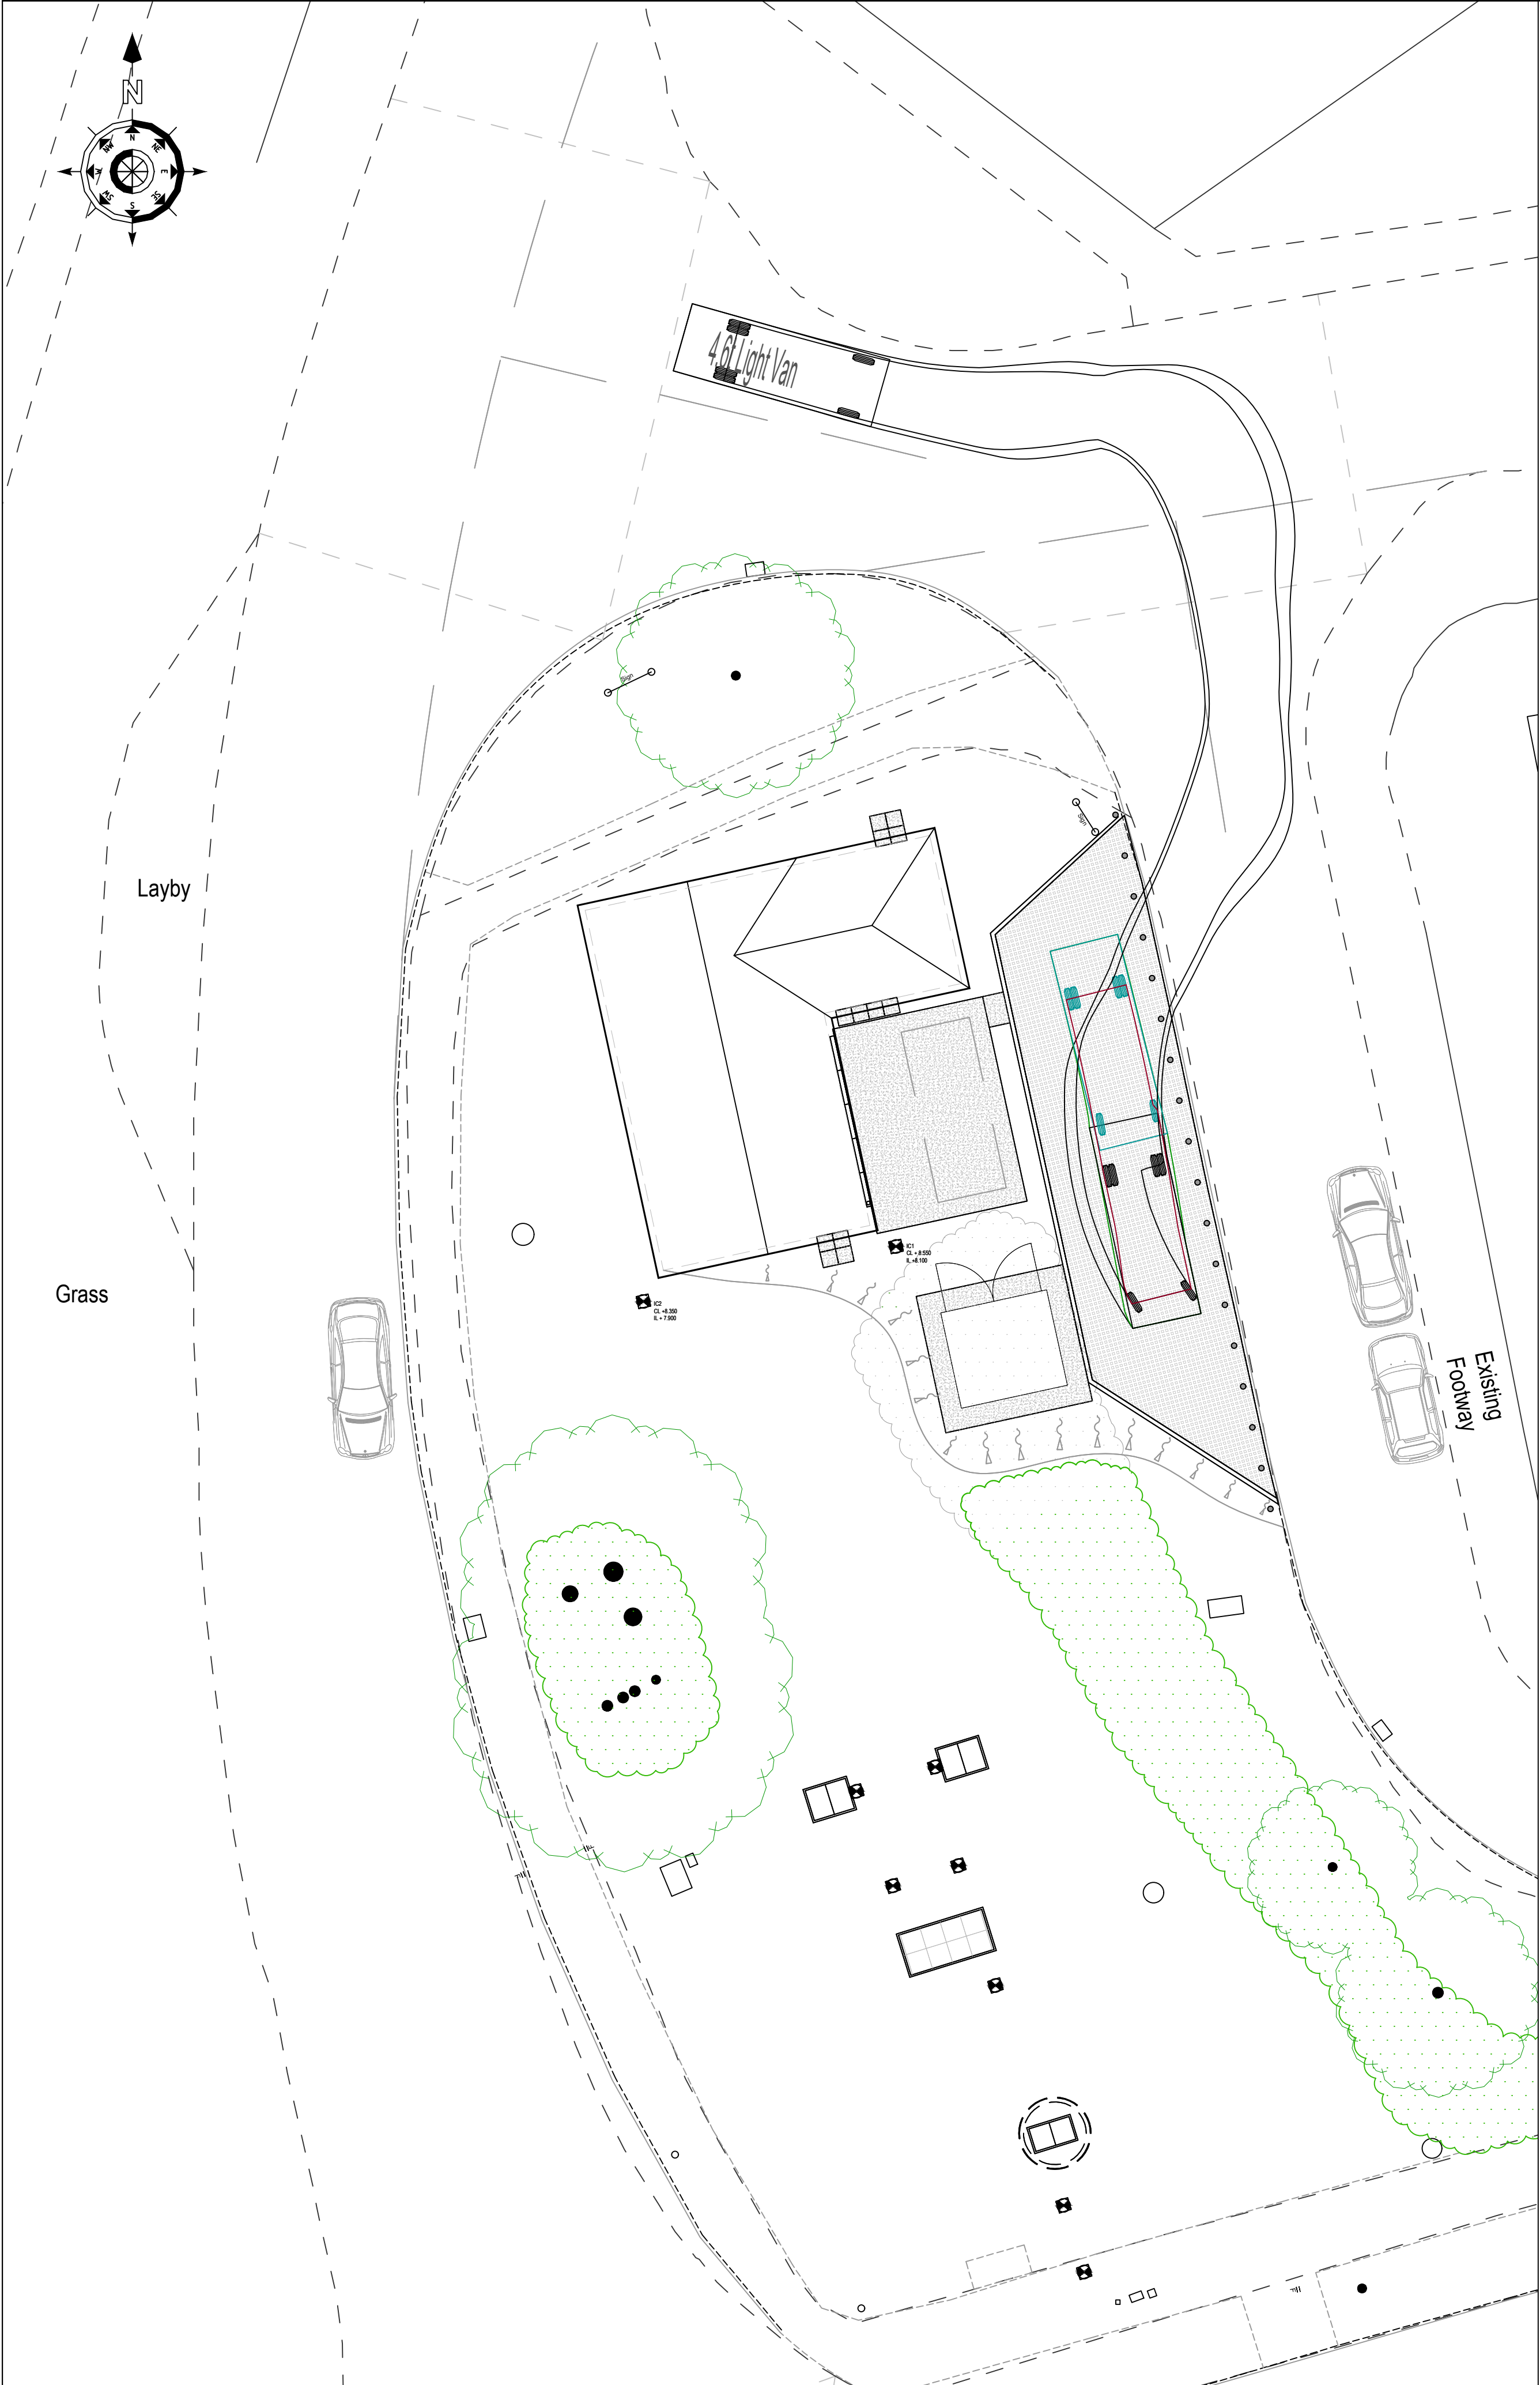

LIGHT GOODS VEHICLE ENTRY TO SITE

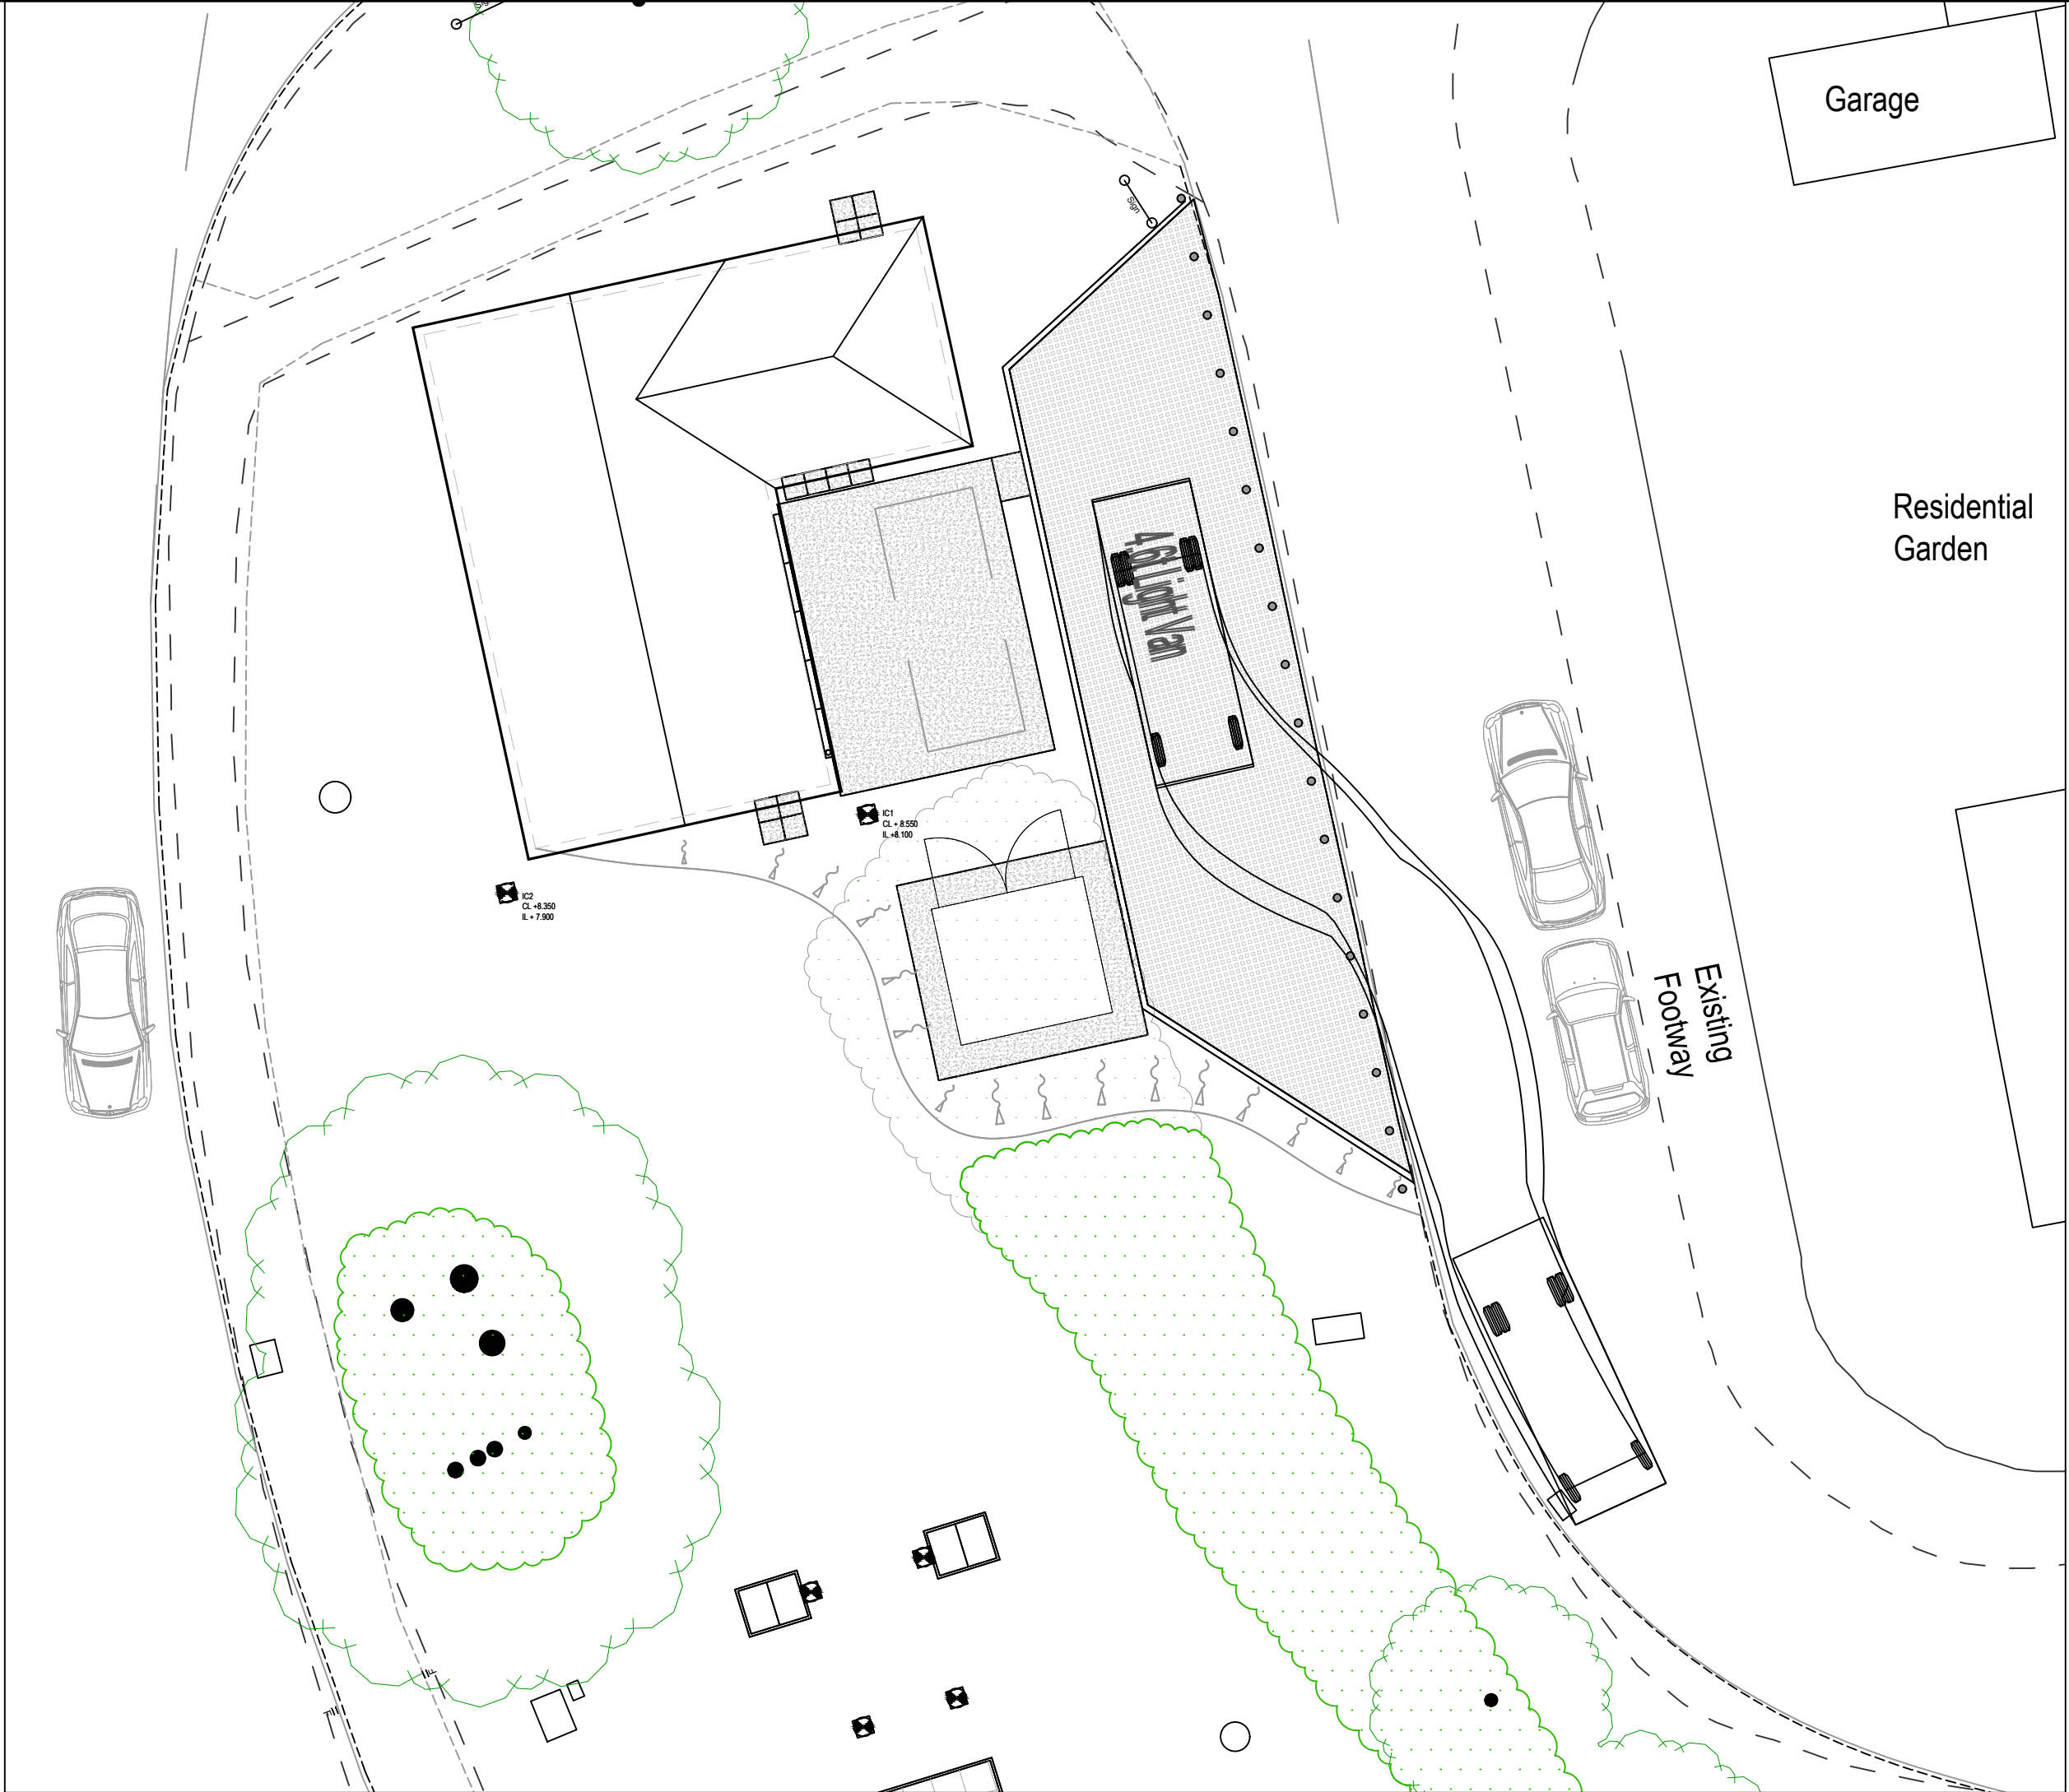


LIGHT GOODS VEHICLE EXIT FROM SITE

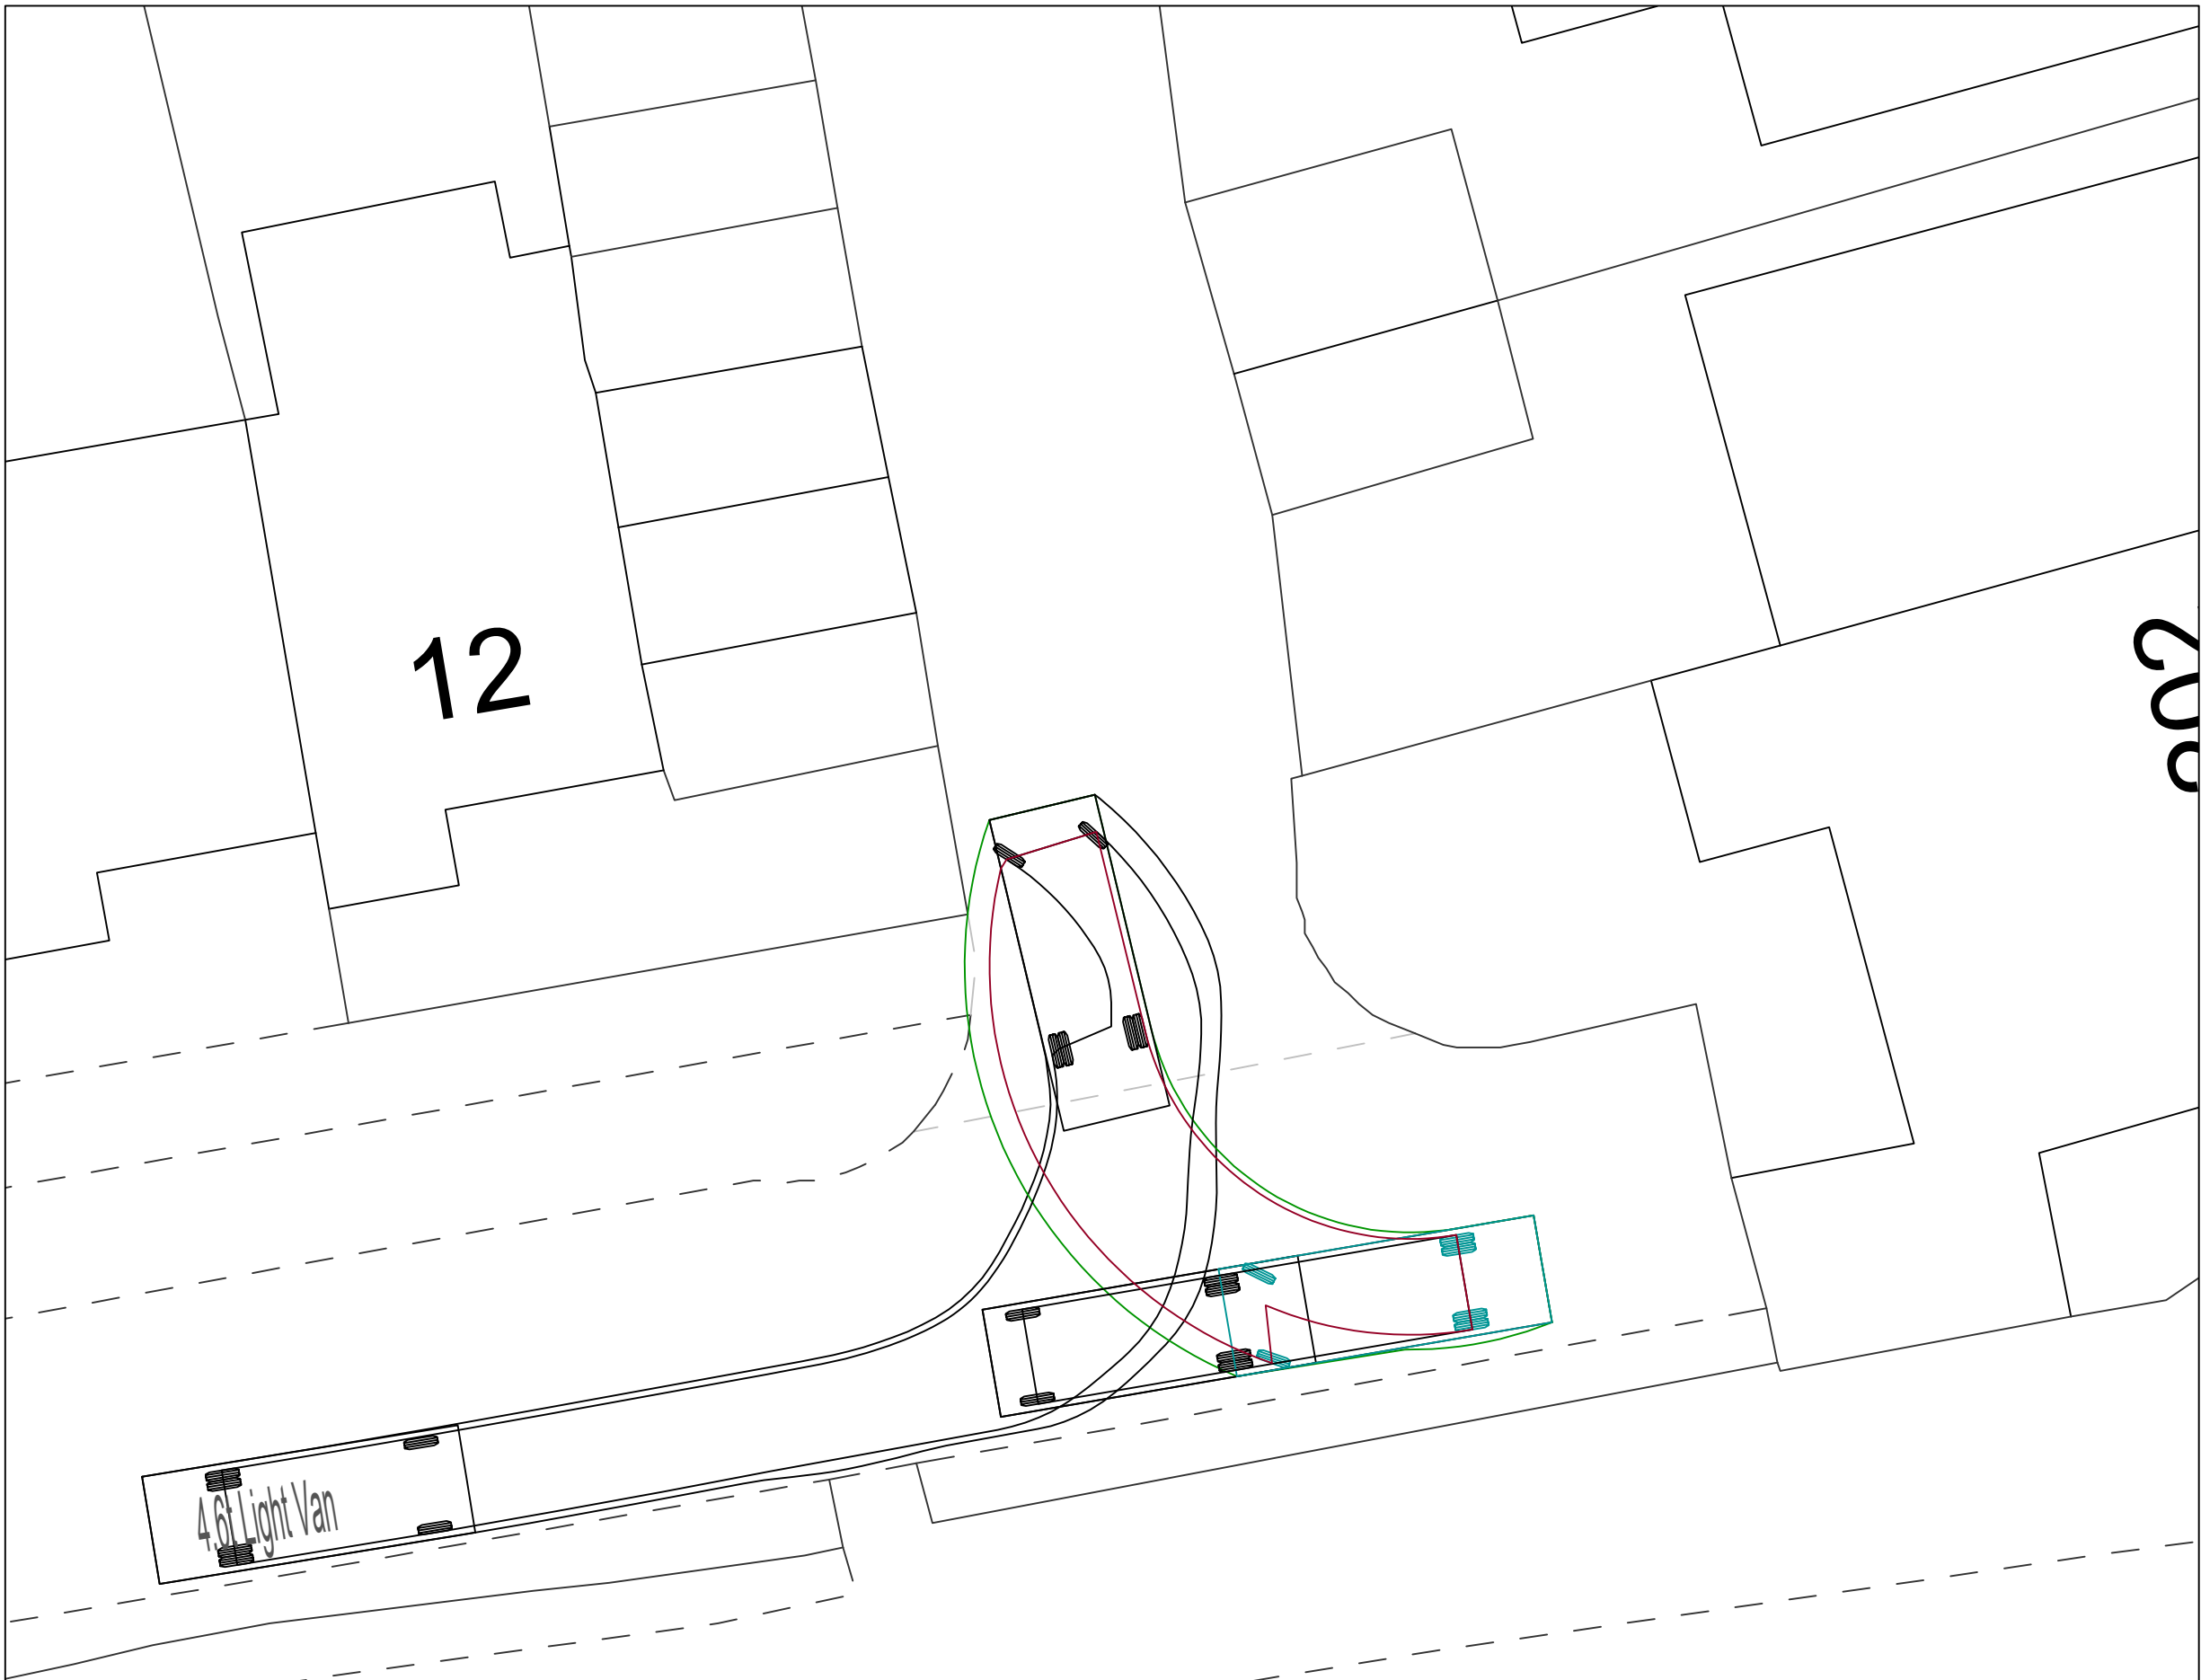

LIGHT GOODS VEHICLE TURNING AT TURNING HEAD OF BROOKFIELD CLOSE

Notes:
1. ALL DIMENSIONS IN MILLIMETRES & ALL LEVELS IN METRES UNLESS SHOWN OTHERWISE.

LEGEND

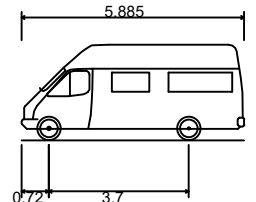

4.6t Light Van
Overall Length 5.885m
Overall Width 2.000m
Overall Body Height 2.526m
Min Body Ground Clearance 0.299m
Track Width 1.765m
Lock to lock time 4.00s
Kerb to Kerb Turning Radius 6.000m

DRAWING REFERENCES

- S847.11-IDS-PW-RT-DR-C-0010 SITE LOCATION PLAN
- S847.11-IDS-PW-RT-DR-C-0011 EXISTING SITE PLAN
- S847.11-IDS-PW-RT-DR-C-0012 PROPOSED SITE PLAN
- S847.11-IDS-PW-RT-DR-C-0013 PROPOSED EQUIPMENT PLANS
- S847.11-IDS-PW-RT-DR-C-0014 PROPOSED ELEVATIONS
- S847.11-IDS-PW-RT-DR-C-0015 PROPOSED BUILDING ELEVATIONS
- S847.11-IDS-PW-RT-DR-C-0017 PROPOSED HGV / SITE ACCESS / EGRESS
- S847.11-IDS-PW-RT-DR-C-0018 PROPOSED EQUIPMENT BUILDING SECTIONS



CURRENT REVISION CHANGES

- 1. DRAWING REFERENCES UPDATED

P02	S3	MJS	KV	JO	RR	FOR REVIEW	25.03.24
P01	S3	MJS	KV	RR	RR	FOR REVIEW	18.12.23
Rev	Status	Drn	Des	Ckd	Apv	Description	Date

TRANT Engineering Ltd.
Head Office: Rushington House,
Rushington, Southampton
SO40 9LT.
Telephone: (023) 8066 5544
E-Mail: Engineering@trant.co.uk
www.trant.co.uk



Contractors Drawing Number:
S847.11-IDS-PW-RT-DR-C-0016

Telephone: Havant (023) 9249 9888
Fax: Havant (023) 9245 3832
Website: www.portsmouthwater.co.uk
Registered Office: PO Box 8 West Street
Havant Hampshire PO9 1LG
REGISTERED IN ENGLAND No. 2536455



PIN: S847.11 Scale: 1:125 Sheet Size: A1

Project Title:
RACTON BOOSTER TRANSFER
PUMPING STATION

Drawing Title:
PROPOSED LIGHT GOODS
VEHICLE SITE ACCESS / EGRESS

Portsmouth Water Drawing Number: P02