
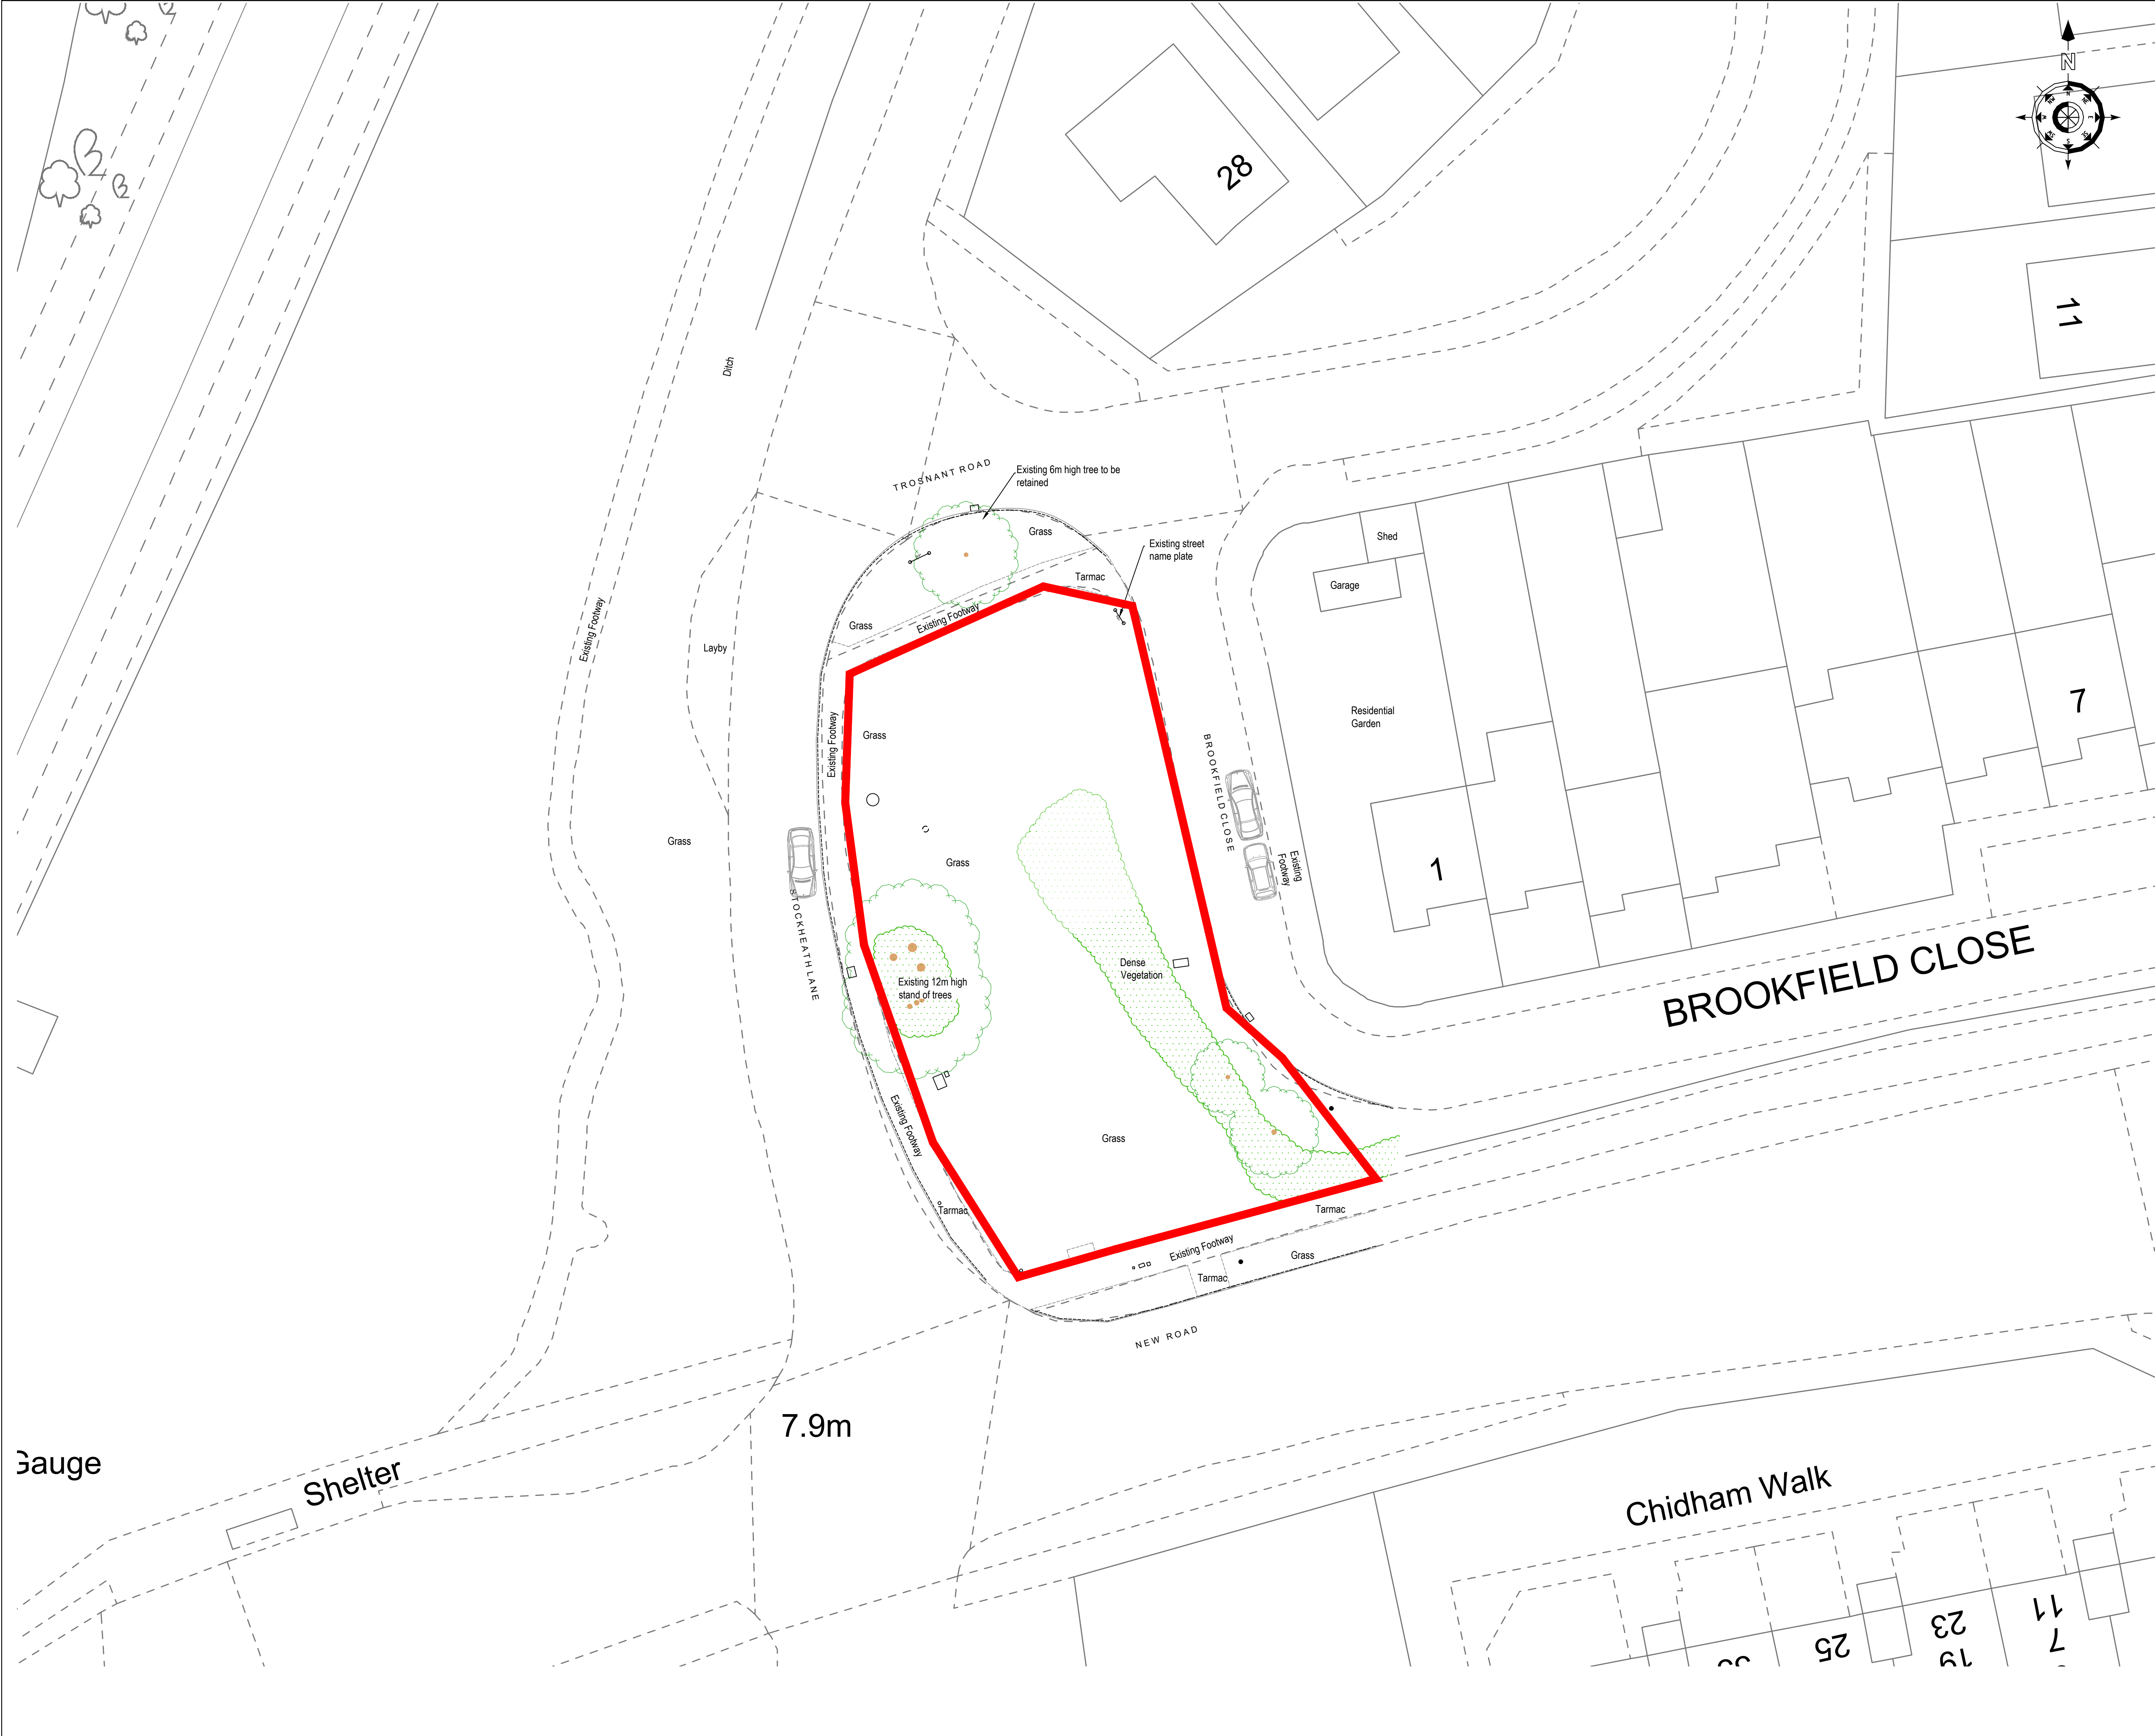


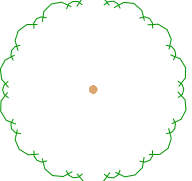


Notes:

- ALL DIMENSIONS IN MILLIMETRES & ALL LEVELS IN METRES UNLESS SHOWN OTHERWISE.
- REPRODUCED BY PERMISSION OF THE ORDNANCE SURVEY ON BEHALF OF HMSO © CROWN COPYRIGHT & DATABASE RIGHT 2019. ALL RIGHT RESERVED
ORDNANCE SURVEY LICENSE NUMBER 100053143

LEGEND

 EXISTING TREES

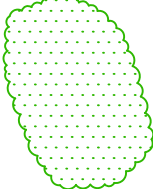 EXISTING VEGETATION

DRAWING REFERENCES

S847.11-IDS-PW-RT-DR-C-0010 SITE LOCATION PLAN
S847.11-IDS-PW-RT-DR-C-0012 PROPOSED SITE PLAN
S847.11-IDS-PW-RT-DR-C-0013 PROPOSED EQUIPMENT PLANS
S847.11-IDS-PW-RT-DR-C-0014 PROPOSED ELEVATIONS
S847.11-IDS-PW-RT-DR-C-0015 PROPOSED BUILDING ELEVATIONS
S847.11-IDS-PW-RT-DR-C-0016 PROPOSED LGV / SITE ACCESS / EGRESS
S847.11-IDS-PW-RT-DR-C-0017 PROPOSED HGV / SITE ACCESS / EGRESS
S847.11-IDS-PW-RT-DR-C-0018 PROPOSED EQUIPMENT BUILDING SECTIONS

5m 0m 5m 10m
Scale 1:200

CURRENT REVISION CHANGES

1.	RED DRAWING BOUNDARY
2.	LEGEND UPDATED

P04	S3	JB	KV	JO	RR	FOR REVIEW	28.11.24
P03	S3	MJS	KV	JO	RR	FOR REVIEW	25.03.24
P02	S3	MJS	KV	RR	POC	FOR REVIEW	19.01.24
P01	S3	MJS	KV	RR	RR	FOR REVIEW	18.12.23
Rev	Status Code	Dm By	Des By	App By	Chk By	Description	Date

TRANT Engineering Ltd.
Head Office: Rushington House,
Rushington, Southampton
SO40 9LT.
Telephone: (023) 8066 5544
E-Mail: Engineering@trant.co.uk
www.trant.co.uk



Contractors Drawing Number:
S847.11-IDS-PW-RT-DR-C-0011

Telephone: Havant (023) 9249 9888
Fax: Havant (023) 9245 3832
Website: www.portsmouthwater.co.uk
Registered Office: PO Box 8 West Street
Havant Hampshire PO9 1LG
REGISTERED IN ENGLAND No. 2536455



PIN:	S847.11	Scale:	1:200	Sheet Size:	A1
------	---------	--------	-------	-------------	----

Project Title:

RACTON BOOSTER TRANSFER PUMPING STATION

Drawing Title:

EXISTING SITE PLAN

Portsmouth Water Drawing Number:	Rev:
	P04