


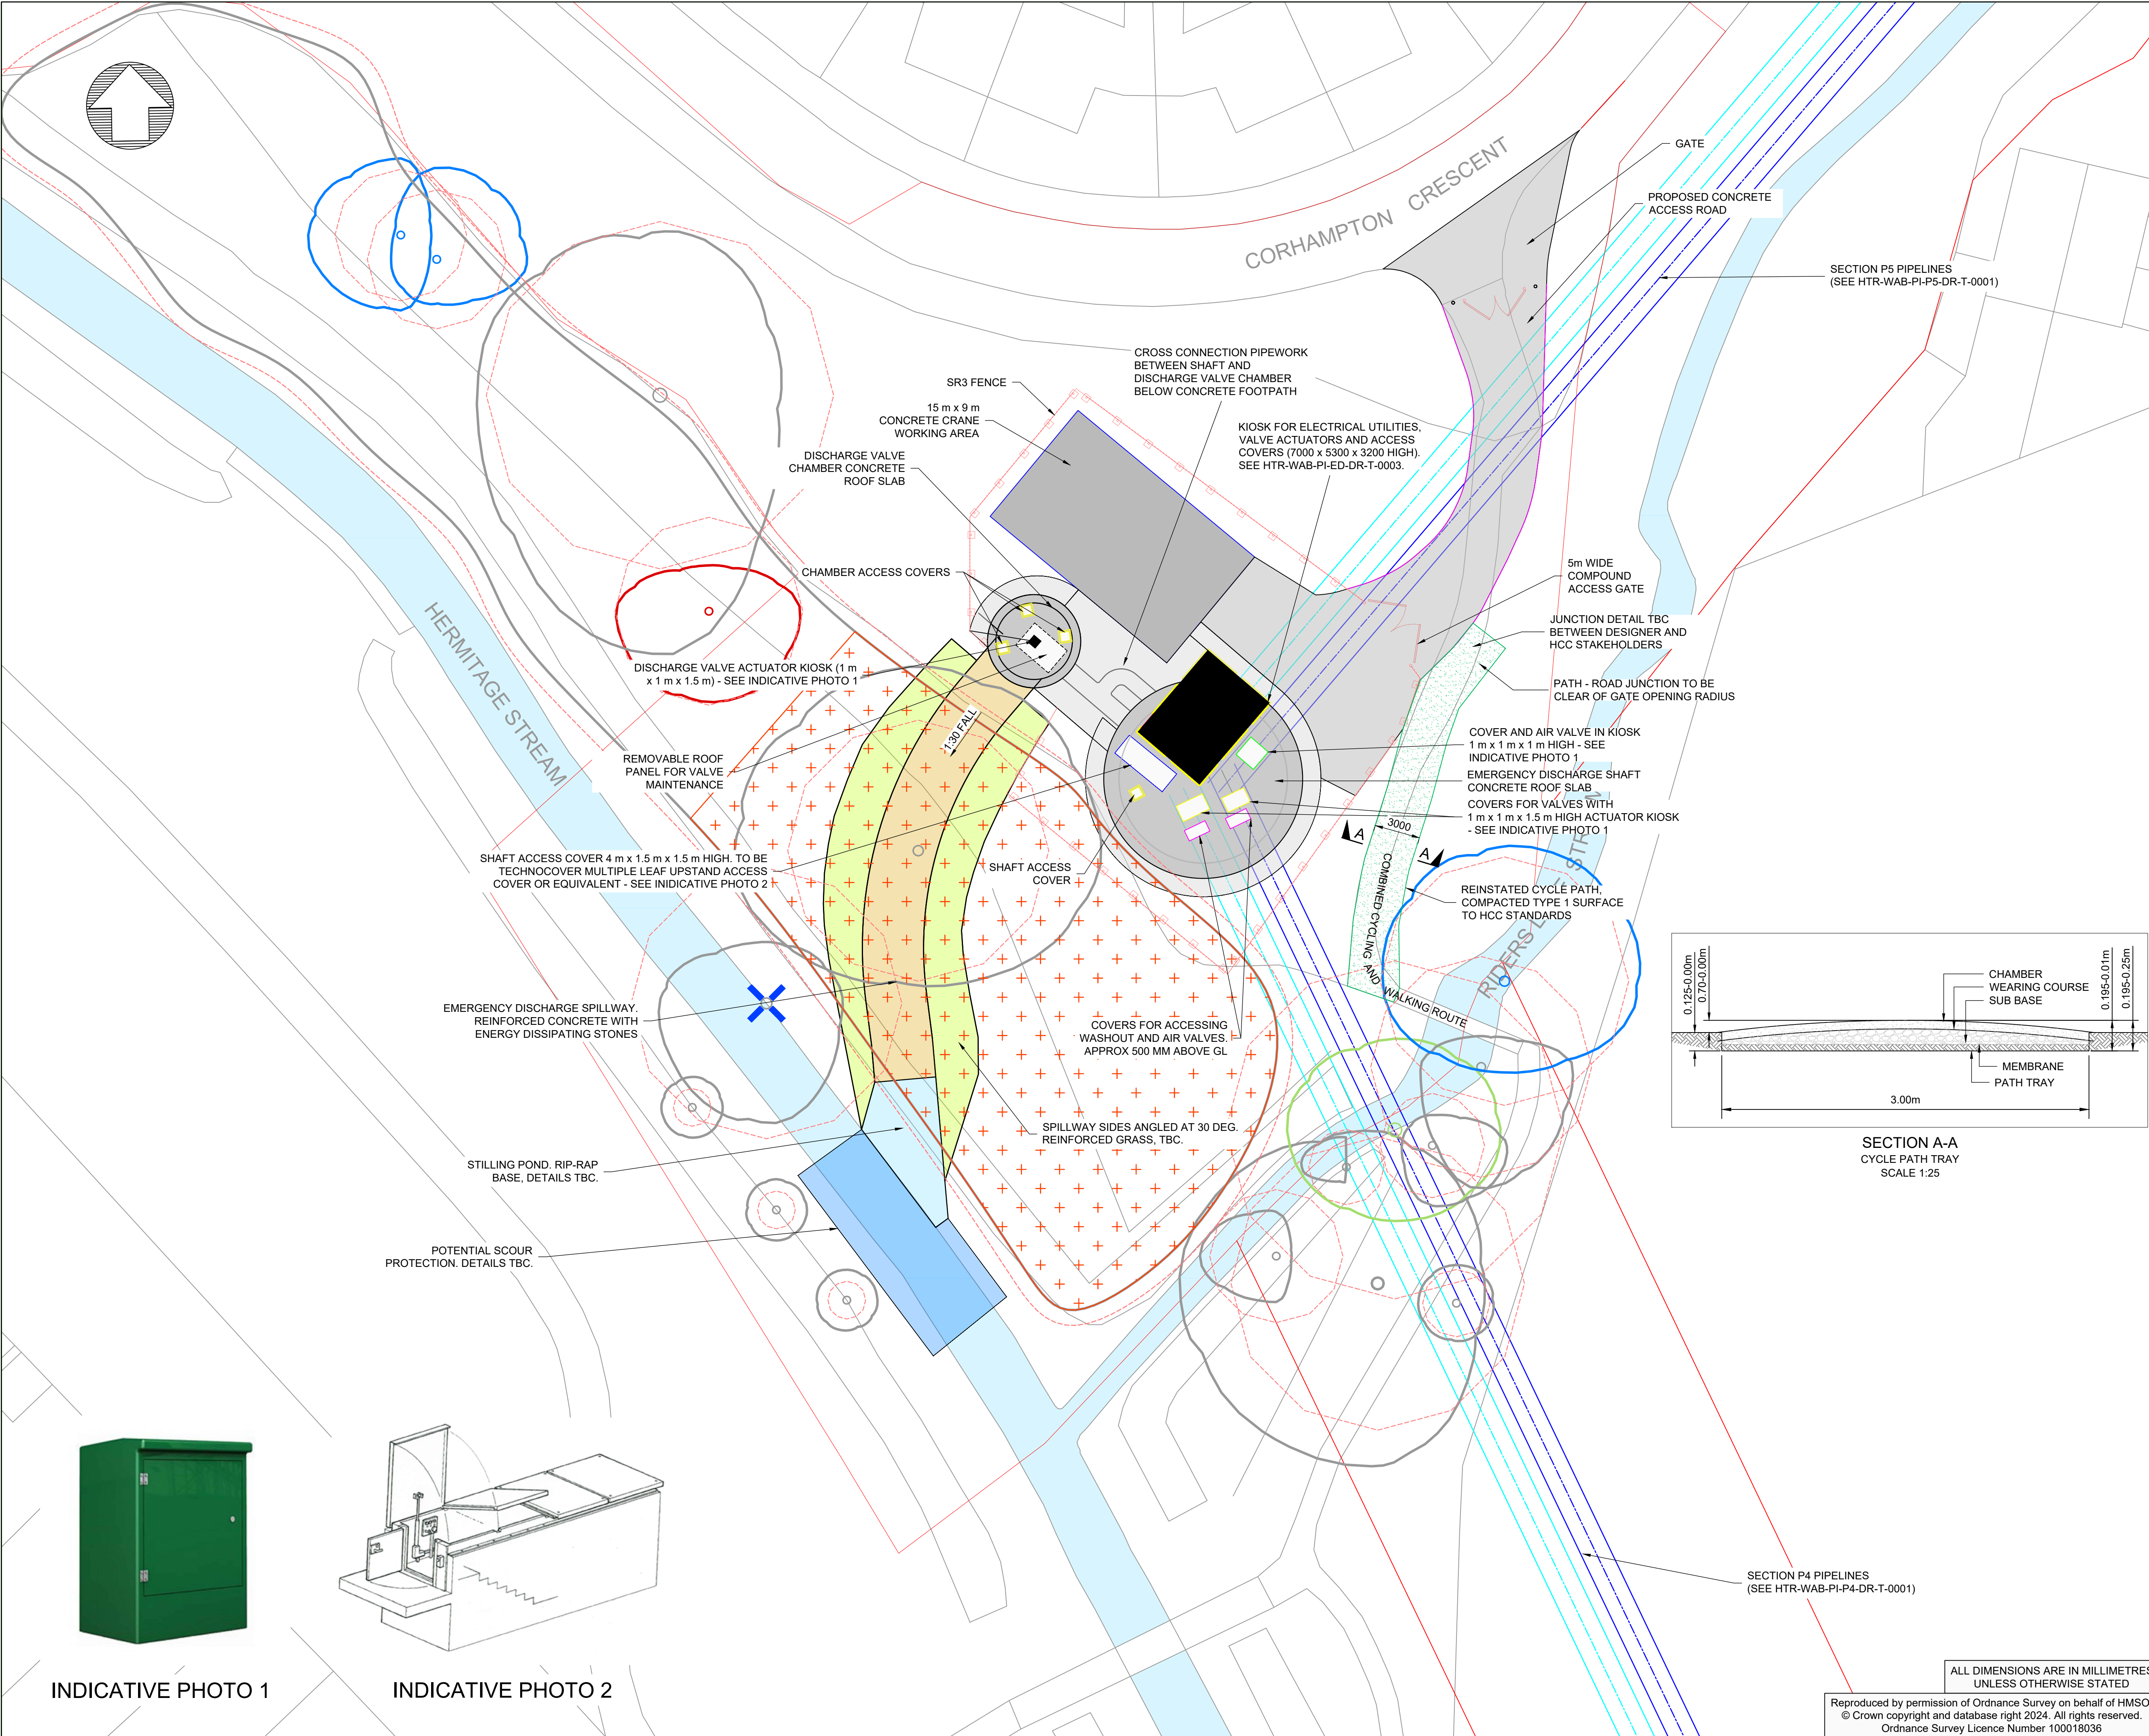

INDICATIVE PHOTO 1


INDICATIVE PHOTO 2

Notes:


KEY PLAN

- Notes:
1. FOR EMERGENCY DISCHARGE SHAFT AND CHAMBER GA SEE DRAWING: HTR-WAB-PI-ED-DR-T-0004
 2. ALL KIOSKS TO BE COLOUR: RAL- 6003 (OLIVE GREEN)
 3. FOR KIOSK ELEVATIONS SEE DRAWING: HTR-WAB-PI-ED-DR-T-0003
 4. REINSTATEMENT TO BE TO LTN1/20 AND HCC TG10 STANDARDS. FOR REINSTATEMENT DETAILS SEE DRAWINGS: HTR-ATK-PL-XX-DR-L-0005.

- LEGEND
- FILL PIPELINE
 - RETURN PIPELINE
 - SITE PERIMETER FENCE
 - REDLINE BOUNDARY
 - PUBLIC RIGHT OF WAY
 - PUBLIC CYCLE AND PATH
 - CATEGORY A TREE
 - CATEGORY B TREE
 - CATEGORY U TREE
 - CATEGORY C TREE
 - ROOT PROTECTION AREA
 - TREE TO BE COPICED
 - TREE REMOVAL TO FACILITATE WORKS
 - TREE GROUP/HEDGE REMOVAL TO FACILITATE WORKS
 - NEW COMBINED WALKING AND CYCLING ROUTE

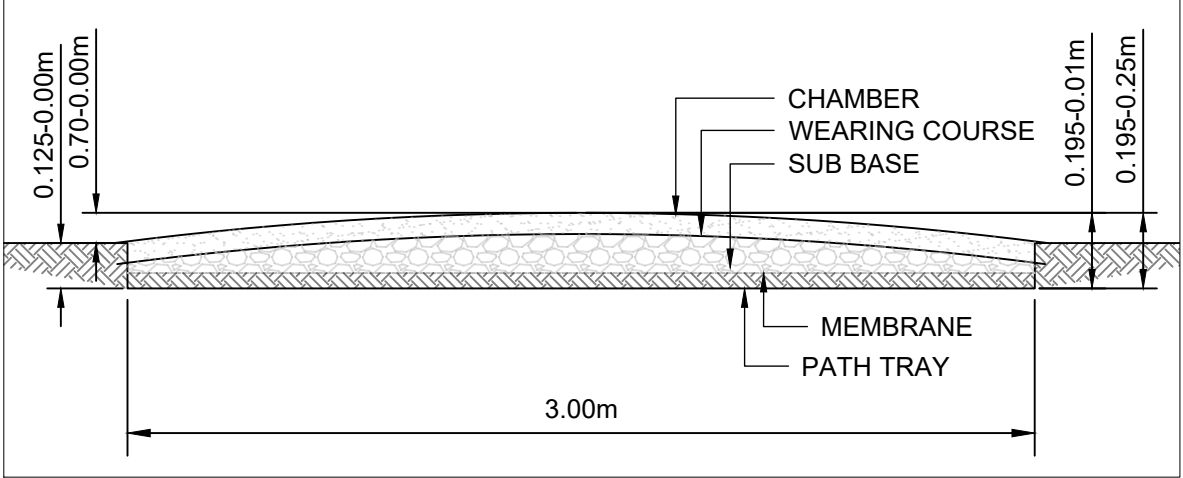

SECTION A-A
CYCLE PATH TRAY
SCALE 1:25

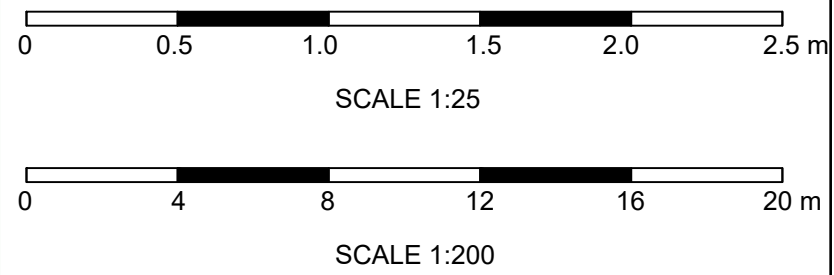

P05 A4	BP	BP	BC	INCORPORATING COMMENTS	13/01/24
P04 A4	CK	BP	BC	REVISED PLANNING VERSION	22/10/24
P03 A4	JT	BP	BC	PLANNING VERSION	03/05/24
Rev	Dm By	Ckd By	App By	Description	Date

WARD & BURKE

Drawing Suitability: **APPROVED FOR DETAILED DESIGN** Status: **A4**

Contractors Drawing Number: **HTR-WAB-PI-ED-DR-T-0002**

Telephone: Havant (023) 9249 9888
Fax: Havant (023) 9245 3632
Website: www.portsmouthwater.co.uk
Registered Office: PO Box 8 West Street
Havant Hampshire PO9 1LG
REGISTERED IN ENGLAND No. 2536455

Date: 13/01/2025 Scale: 1:200 Sheet: 01 of 01 Sheet Size: A1

Project Title: **HAVANT THICKET RESERVOIR**

Drawing Title: **BEDHAMPTON TO HTR PIPELINE
EMERGENCY DISCHARGE
PERMANENT SITE PLAN**

Portsmouth Water Drawing Number: P05 Rev: P05

ALL DIMENSIONS ARE IN MILLIMETRES
UNLESS OTHERWISE STATED

Reproduced by permission of Ordnance Survey on behalf of HMSO.
© Crown copyright and database right 2024. All rights reserved.
Ordnance Survey Licence Number 100018036