



WORKS MUST COMPLY IN FULL WITH THE REQUIREMENTS SET OUT IN THE HAMPSHIRE COUNTY COUNCIL PROPERTY SERVICES STANDARD SPECIFICATIONS PART A AND PART B.
PART A: GENERAL REQUIREMENTS, CONDITIONS AND PROCEDURES
PART B: STANDARD SPECIFICATION FOR MATERIALS, WORKMANSHIP AND INSTALLATION OF ELECTRICAL SERVICES.

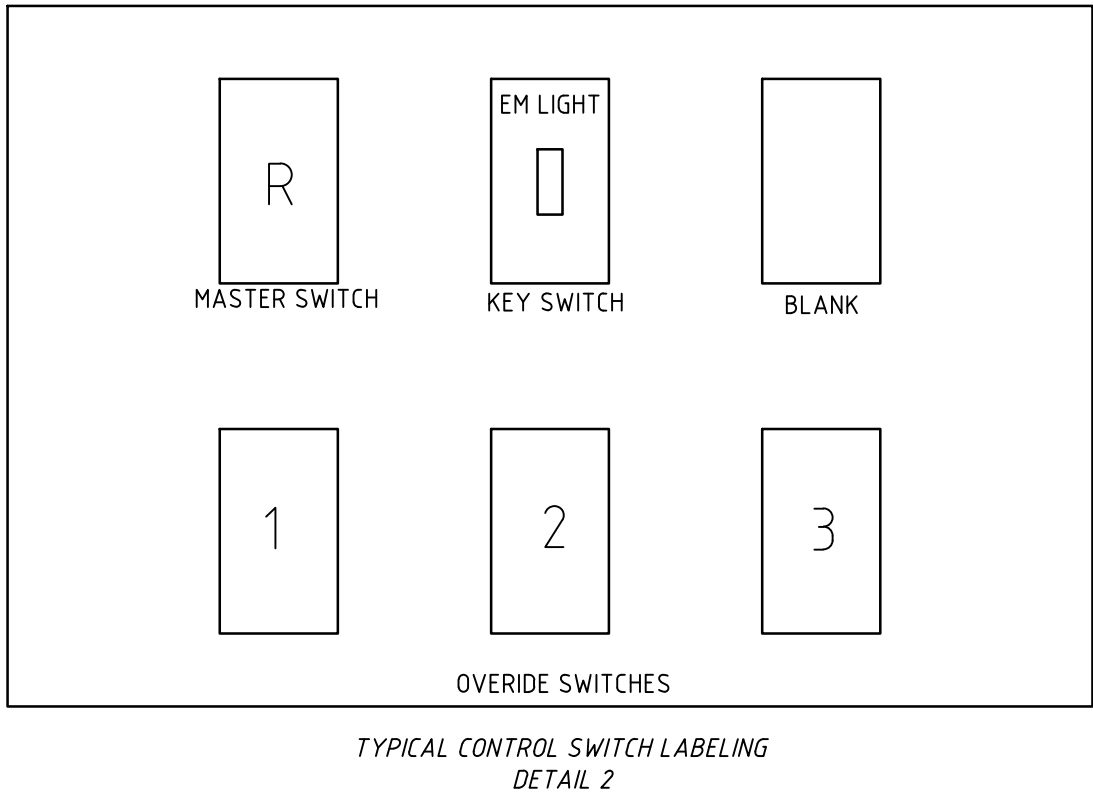

- NOTES:
- ALL LIGHTING WIRING TO BE NEW
 - EXISTING MCB'S WHICH SUPPLIED EXISTING CIRCUITS THAT HAVE BEEN REMOVED SHALL BE REUSED
 - CIRCUITS FED FROM EXISTING DB LOCATED IN FIRST FLOOR CUPBOARD

- A. This drawing is © copyright Hampshire County Council 2023. No unauthorised reproduction of any kind is permitted.
- B. No dimensions to be scaled from this drawing. Verify all dimensions prior to construction. Immediately report any discrepancies on the document to the Architect/Contract Administrator. This document shall be read in conjunction with associated models, specifications and related consultant's documents.
- C. Drawing to be read with all relevant Architectural, Structural, M&E, Drainage/Public Health, Landscape, Civils and Interiors drawings and specifications.
- D. This map is reproduced from Ordnance Survey material with the permission of Ordnance Survey Material on behalf of the controller of Her Majesty's Stationery Office © Crown Copyright. Unauthorised reproduction infringes Crown Copyright & may lead to prosecution or civil proceedings (10001980) 2023.
- E. Read this drawing in conjunction with all other tender and contract documentation issued for this project.
- F. The installation shall be carried out in strict accordance with the project tender drawings, electrical works brief, HCC standard specifications and the current edition of the wiring regulations (BS7671).
- G. Final positions of all equipment shall be agreed on site with the CA prior to installation.
- H. The contractor shall coordinate the works with all other trades prior to commencement.
- I. Where any of the existing installation detailed to be reused is found to be of a dubious standard, then instructions should be sought from the CA.
- J. Liaise & coordinate with all specialist contractors employed for the works.
- K. Isolate, remove and dispose any existing services to allow works to take place. All items of equipment to be removed and not reused shall be offered to the client's representative and if not required, confirmation for their disposal shall be obtained from the CA.

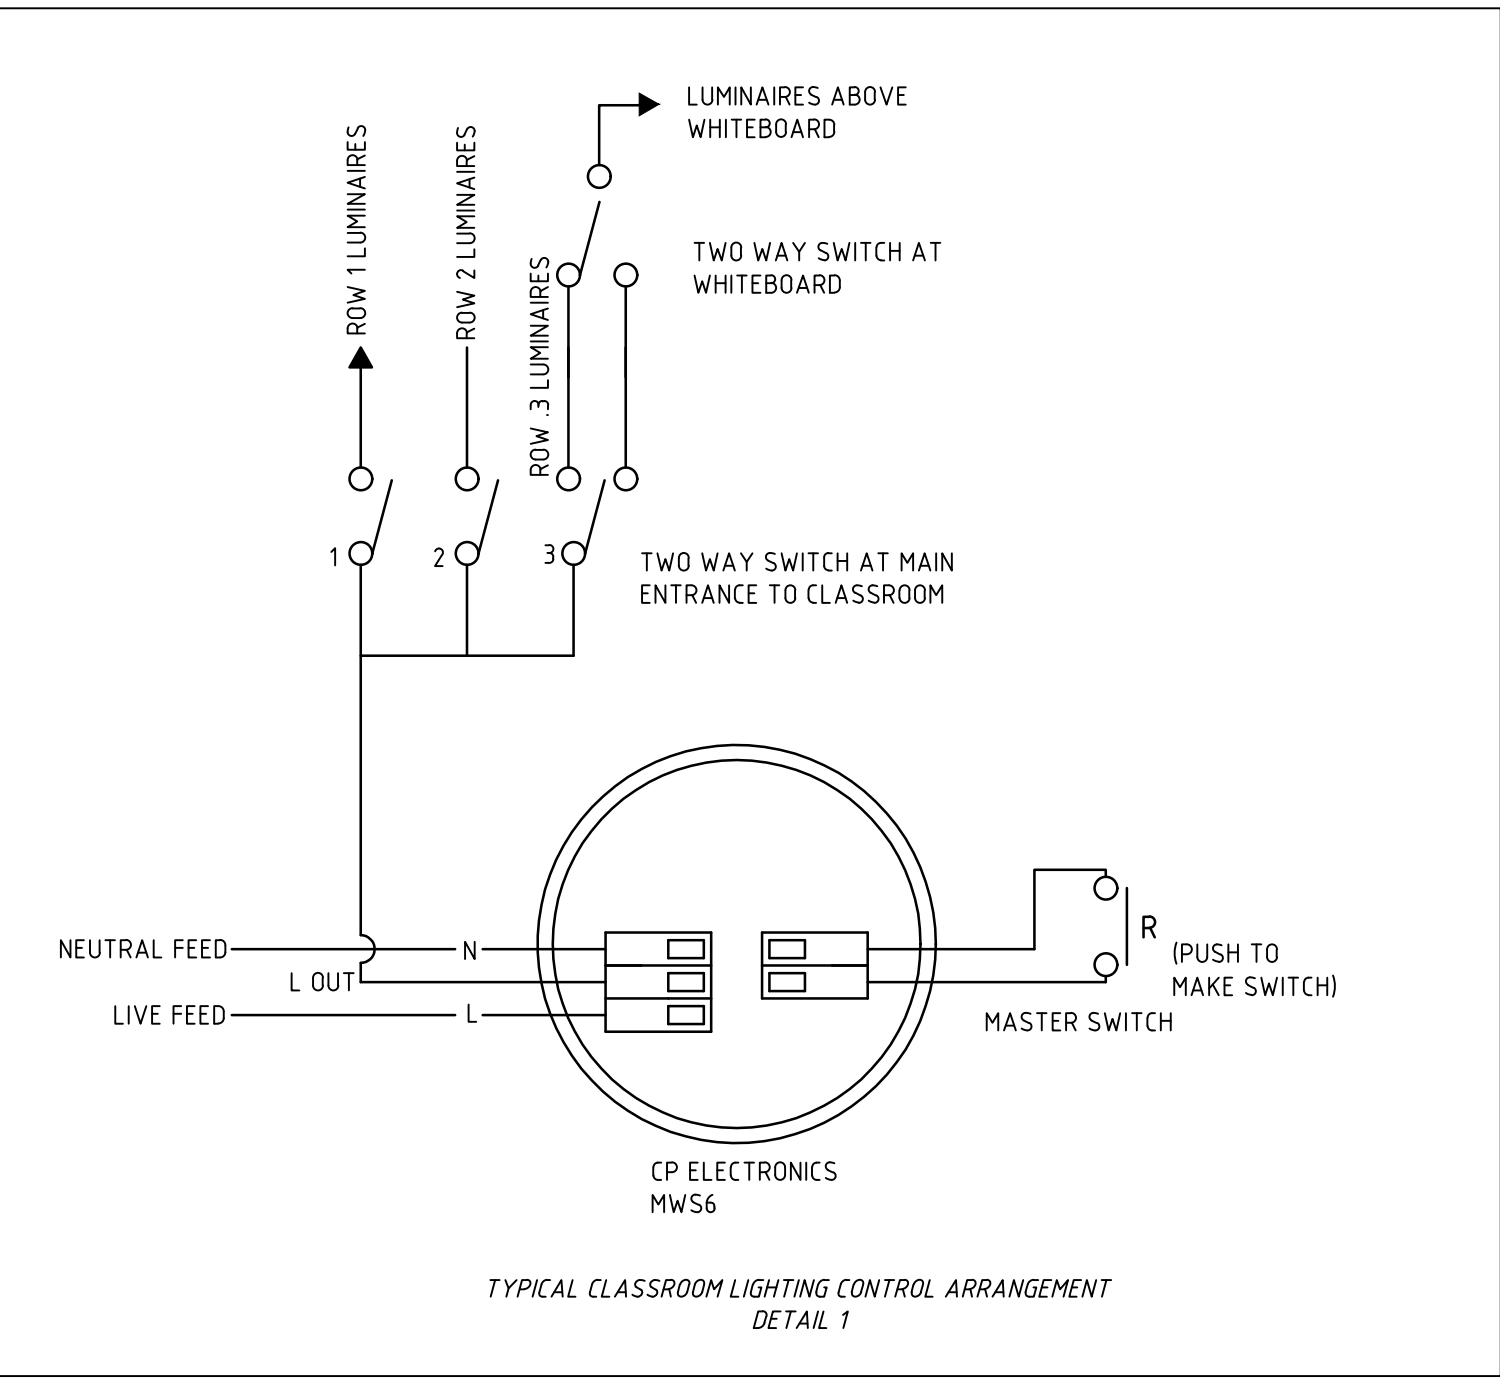

LEGEND

- A 600 x 600 RECESSED LED PANEL AS QVIS REF: LYNX 5LG 406 X 640W 4800LUMEN
- A/E AS ABOVE BUT 3 HOUR EMERGENCY VERSION
- B 600 x 600 RECESSED LED PANEL AS QVIS REF: LYNX
- B/E AS ABOVE BUT 3 HOUR EMERGENCY VERSION
- EXIT MAINTAINED EMERGENCY EXIT SIGN AS QVIS BLADE SUSPENDED 3W 150 LUMEN
- C SURFACE MOUNTED 17W EMERGENCY BULKHEAD AS QVIS MITRE C/W PHOTOCELL REF: MIT-WS-TC/EM
- P A RECESSED MICROWAVE ABSENCE DETECTOR WITH LUX LEVEL SENSING, AS CP ELECTRONICS MW56 20 MIN SET-TIME
- P AS ABOVE FOR PRESENCE
- SD SMOKE DETECTOR C/W SOUNDER BASE
- SD SMOKE DETECTOR
- ⊙ BREAK GLASS

Rev	Description	Date	By	Chkd

HCC Property Services,
Three Minsters House,
76 High Street, Winchester SO23 8UL
tel: (01962) 847801



Hart Plain Junior School
Hart Plain Ave
Waterlooville PO8 8SA

Electrical Engineering Services
Lighting & Fire Alarm Layout
Ground Floor

SCALE 1 : 50@ A1 DRAWN EM CHKD DH APRV DH

DRAWING No. project code - originator - volume - level - type - role - number revision
C10314-HCC-PS-00-DR-E-8200 T0

October, 2023

Tender Issue