


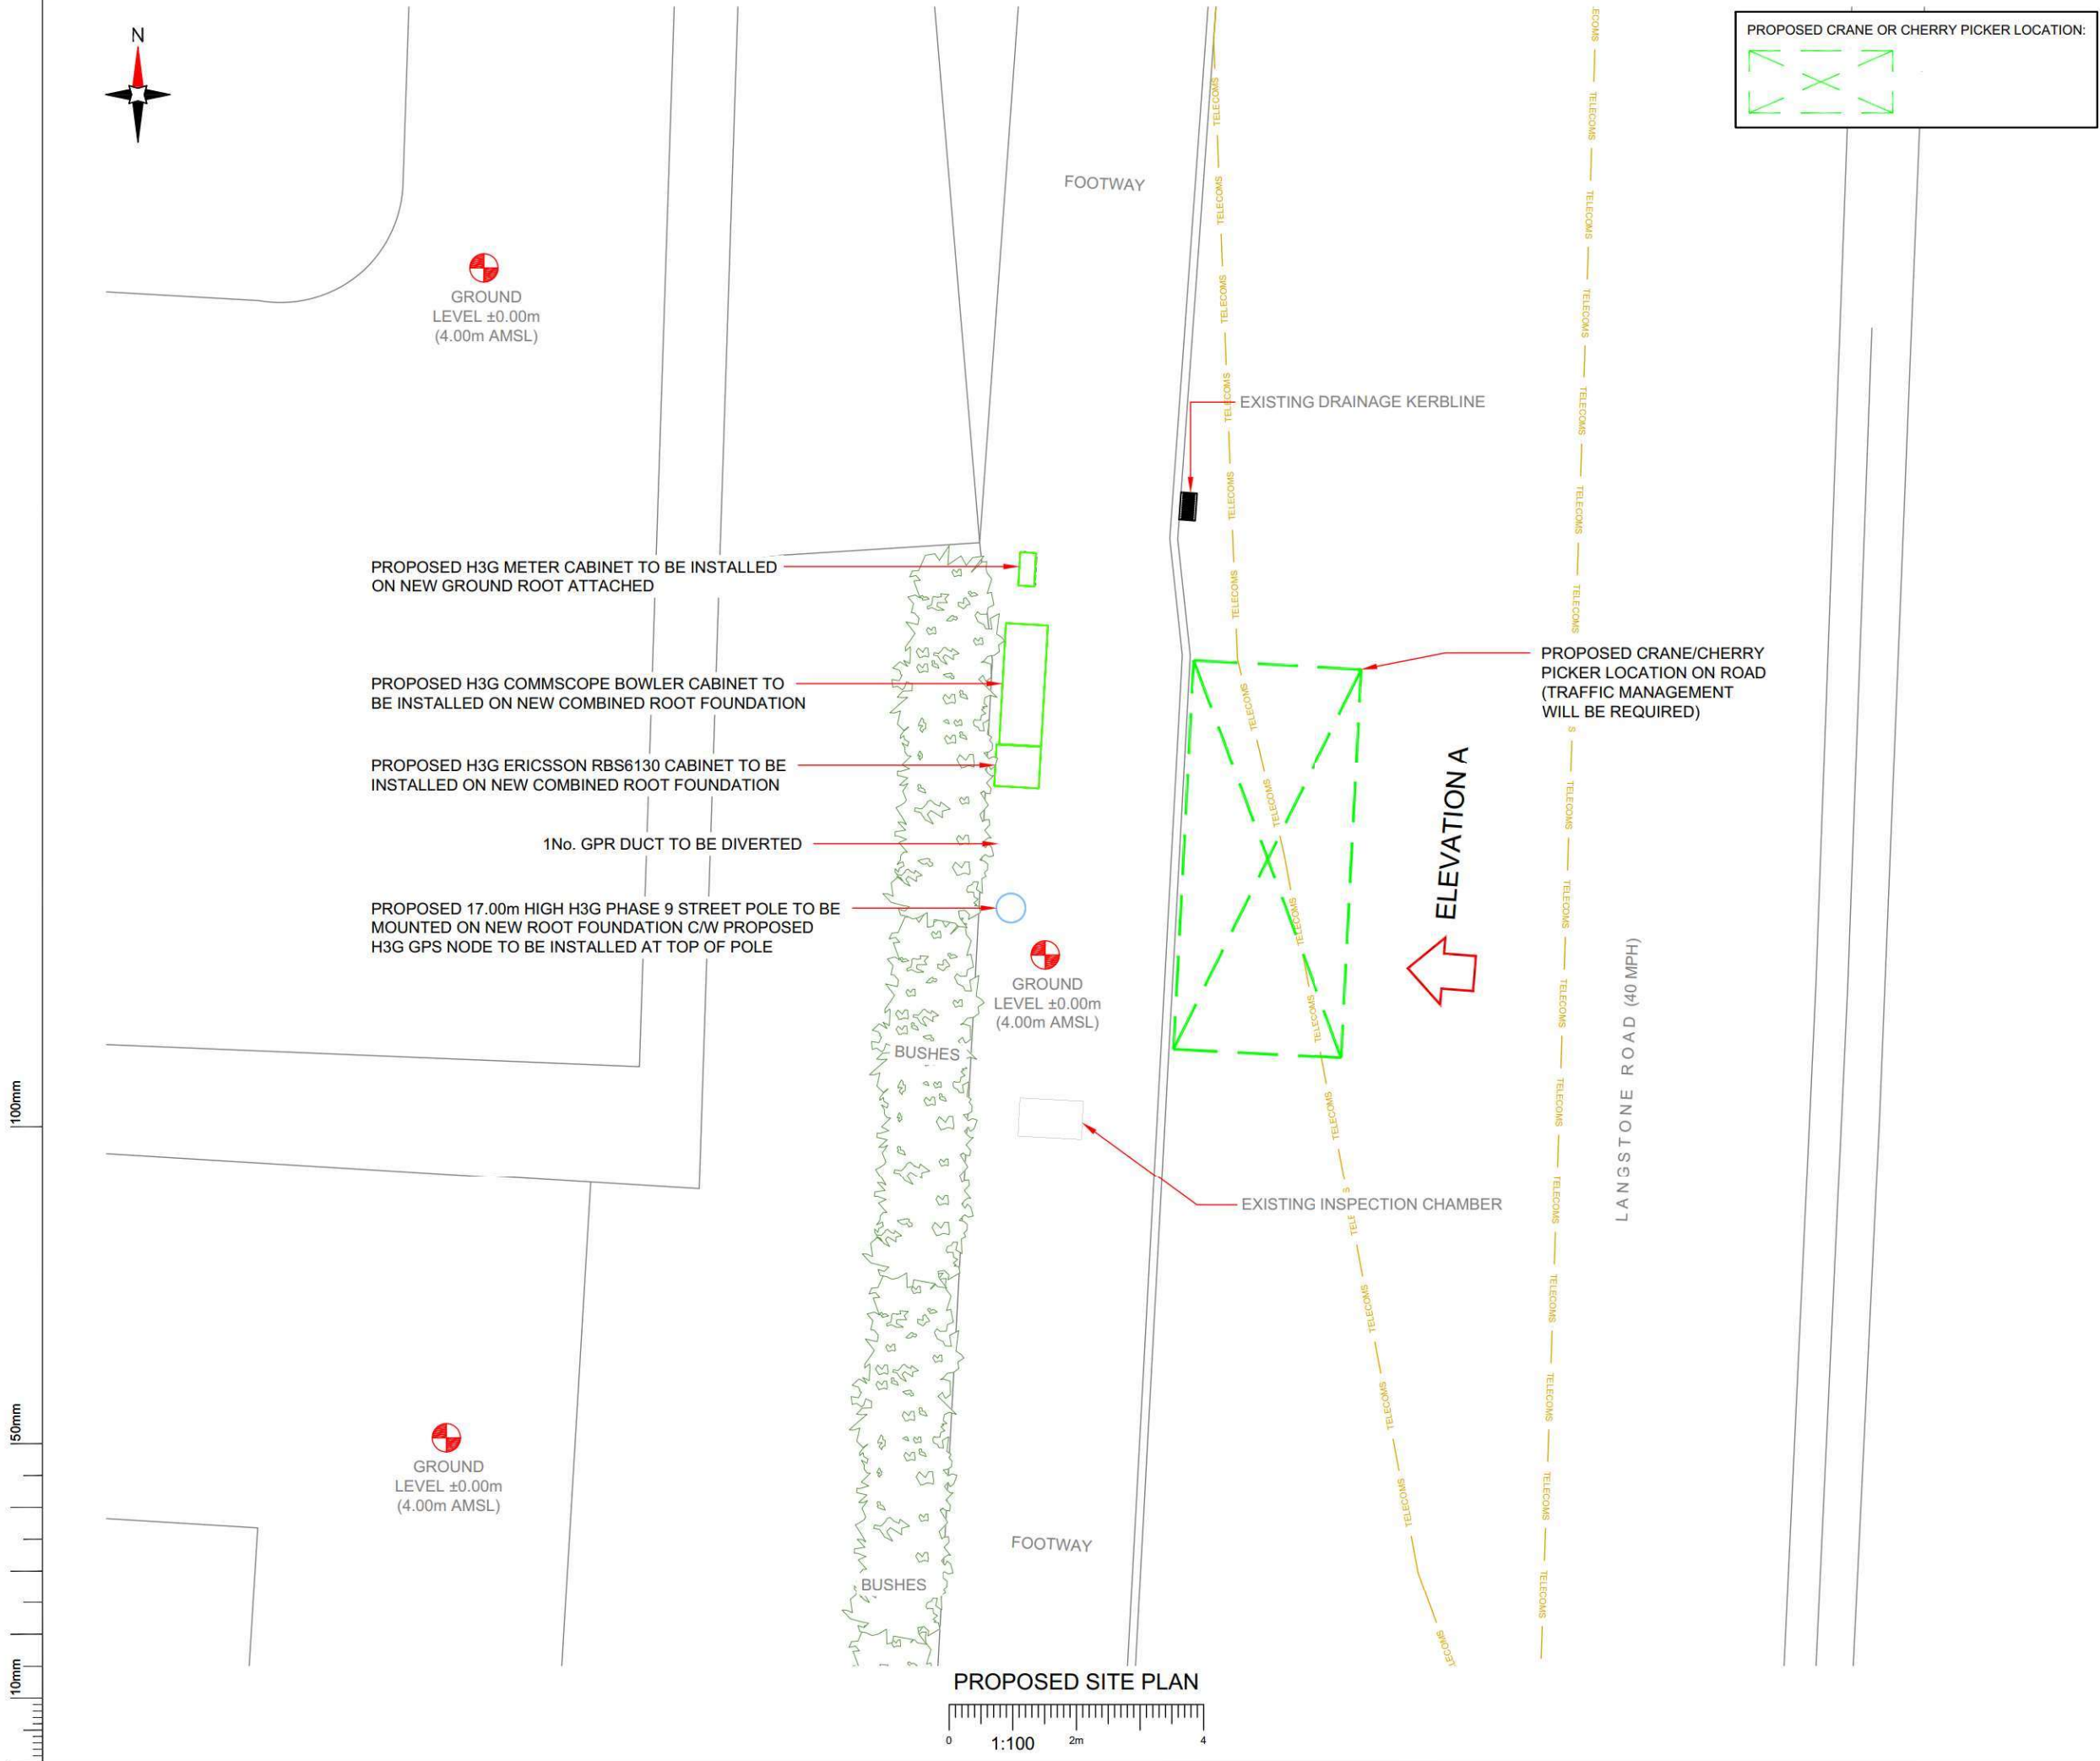

NOTES:

1. ALL DIMENSIONS IN MM UNLESS OTHERWISE NOTED.

SERVICES:

LV ELECTRIC

LV ELECTRIC

SURFACE WATER

SURFACE WATER

SEWAGE WATER

SEWAGE WATER

TELECOMS

TELECOMS

GPR

GPR

URF

URF

Master:	MBNL / EE / H3G:	Project:	Purpose of Issue:	Issue:
M004	H3G	DENSIFICATION SW	Planning	D
Date:	23/03/2023	Revision / Upgrade Description:		
Drawn:	A.Lemos	New Phase 9 Pole Location		
Checked:	G.Thomas			
Approved:	G.Thomas			
Master:	MBNL / EE / H3G:	Project:	Purpose of Issue:	Issue:
M003	H3G	DENSIFICATION SW	Planning	C
Date:	24/01/2023	Revision / Upgrade Description:		
Drawn:	W.Weston	Phase 9 Pole Proposed. Height Reduced.		
Checked:	G.Thomas			
Approved:	G.Thomas			
Master:	MBNL / EE / H3G:	Project:	Purpose of Issue:	Issue:
M002	H3G	DENSIFICATION SW	Planning	B
Date:	06/10/2022	Revision / Upgrade Description:		
Drawn:	S.Booth	QR code and directions updated		
Checked:	G.Thomas			
Approved:	G.Thomas			
Master:	MBNL / EE / H3G:	Project:	Purpose of Issue:	Issue:
M001	H3G	DENSIFICATION SW	Planning	A
Date:	15/09/2022	Revision / Upgrade Description:		
Drawn:	S.Booth	First Issue - Site nomination dated: TBC		
Checked:	G.Thomas			
Approved:	G.Thomas			

Hutchison 3G UK Limited
Green Park, 450 Longwater Avenue
Reading, RG30 3UR
Tel: 01628 765 000
Fax: 01628 765 001

H3G Base Station Information line:
0845 6043000
Available 8am-8pm Monday to Friday

Design Consultant & Principal Contractor:

Unit E, Madison Place, Northampton Road,
Manchester, M40 5AG
Tel: 0161 785 4500 Fax: 0161 785 4501
Web: www.clarke-telecom.com

Site Name:

LANGSTONE ROAD

Site ID:

HVT25307

Address:

LANGSTONE ROAD,
HAVANT,
HAMPSHIRE,
PO9 1RE

Title:

210 PROPOSED SITE PLAN

Project:

H3G DENSIFICATION STREETWORKS

Purpose of Issue:

PLANNING

EE Cell ID:	MBNL Cell ID:	3UK Cell ID:
87575	HVT064	PO1050

Master Drawing No:

HVT25307_HVT064_PO1050_M003_H3G_DNSW_GA_C

Issue:

D