





0 500 1000 1500 2000 2500m
1:50000

SITE LOCATION (Scale 1:50000)

Ordnance Survey map extract
based upon Landranger map series
with the permission of the controller of
Her Majesty's Stationery Office
Licence No. 100022432
Crown copyright.



SITE PHOTOGRAPH

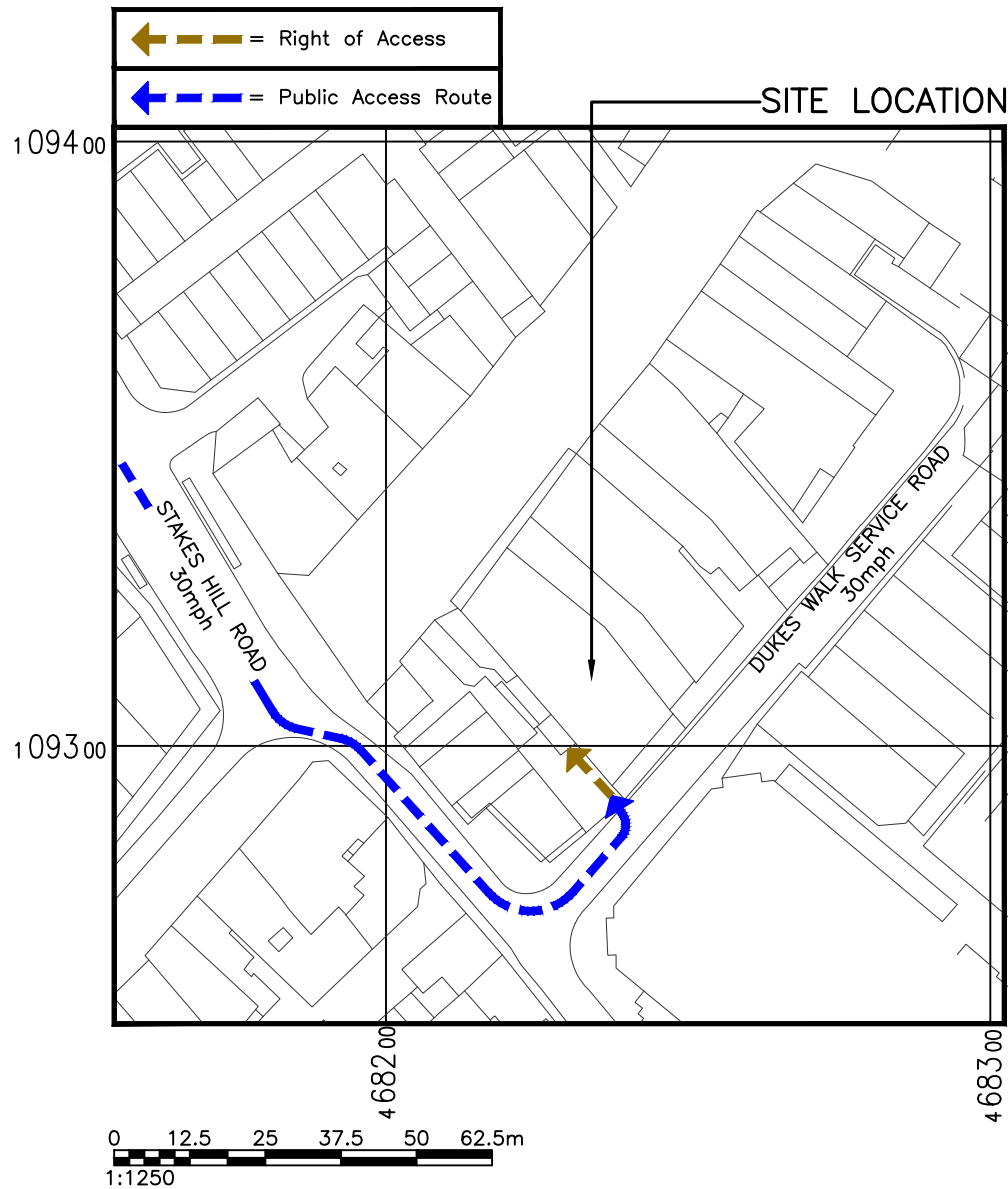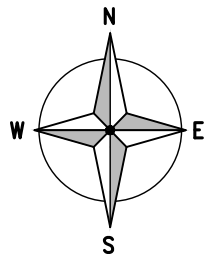

0 12.5 25 37.5 50 62.5m
1:1250

DETAILED SITE LOCATION (Scale 1:1250)

Based upon Ordnance Survey map extract
with the permission of the Controller of
Her Majesty's Stationery Office.
Crown copyright.
Licence No. 100022432

ALL DIMENSIONS ARE IN mm UNLESS NOTED OTHERWISE

N.G.R. E: 468240 N: 109310

DIRECTIONS TO SITE:

FROM THE A3 (M) J3 FOLLOW THE B2150
TOWARDS WATERLOOVILLE. CONTINUE STRAIGHT
ON, AT FIRST ROUNDABOUT THEN TURN LEFT
ONTO WARFIELD AVENUE. AT THE END TURN
RIGHT ONTO STAKES HILL ROAD THEN RIGHT
WHEN YOU REACH THE PEDESTRIAN ZONE
INTO DUKES WALK SERVICE ROAD, SITE IS
LOCATED ON THE LEFT HAND SIDE

NOTES:

A	Issued for Approval	BP	RP	17.03.2023
REV	MODIFICATION	BY	CH	DATE



COMMScope
COMMScope DESIGN & INTEGRATION UK LTD
100 NEW BRIDGE STREET
LONDON
EC4V 6JA
Email:-chris.serjeant@commscope.com



vodafone
CORNERSTONE - METROPOLIS 5G



Cell Name		Opt.
PEACOCK STORES		A
Cell ID No		
CORNERSTONE	VMO2	VF
E315081	034241	86536_9
12766924		

Site Address / Contact Details

288 LONDON ROAD
WATERLOOVILLE
HAMPSHIRE
PO7 7DS

Drawing Title: SITE LOCATION MAPS				
Purpose of issue: PLANNING				Dwg Rev:
Drawing Number: 100				A
Surveyed By: COMMScope		Original Sheet Size: A3		Pack Issue:
Drawn: BP	Date: 17.03.2023	Checked: RP	Date: 17.03.2023	A


These drawings comply with TEF and VF Non-Standard ICNIRP Guidelines under configuration VM7F.
Designed in accordance with Cornerstone Document : SDN0013 & SDN0009 "ICNIRP Compliance Summary v5"

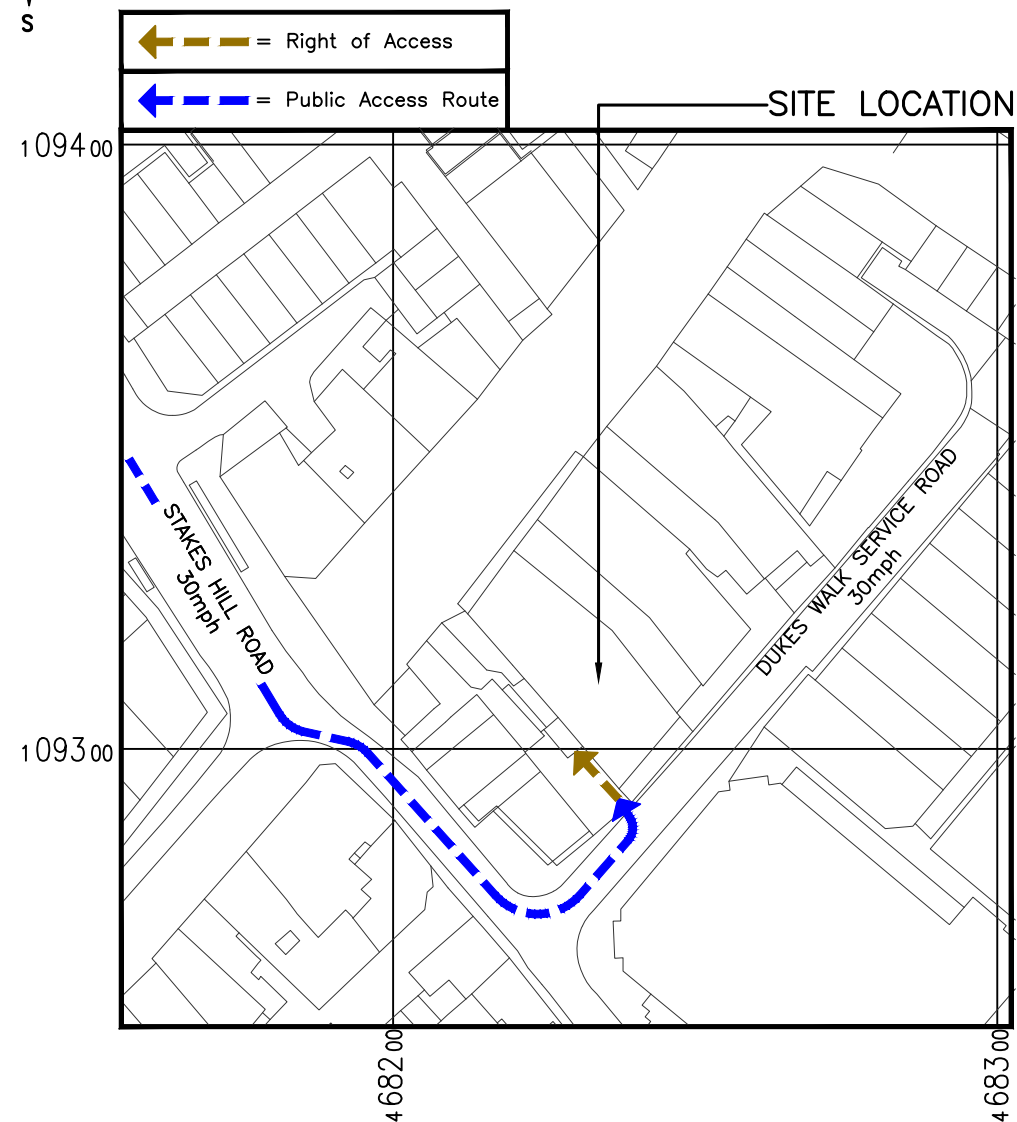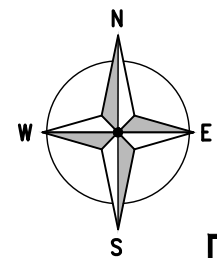

DETAILED SITE LOCATION


(Scale 1:1250)

Based upon Ordnance Survey map extract
with the permission of the Controller of
Her Majesty's Stationery Office.
Crown copyright.
Licence No. 100022432

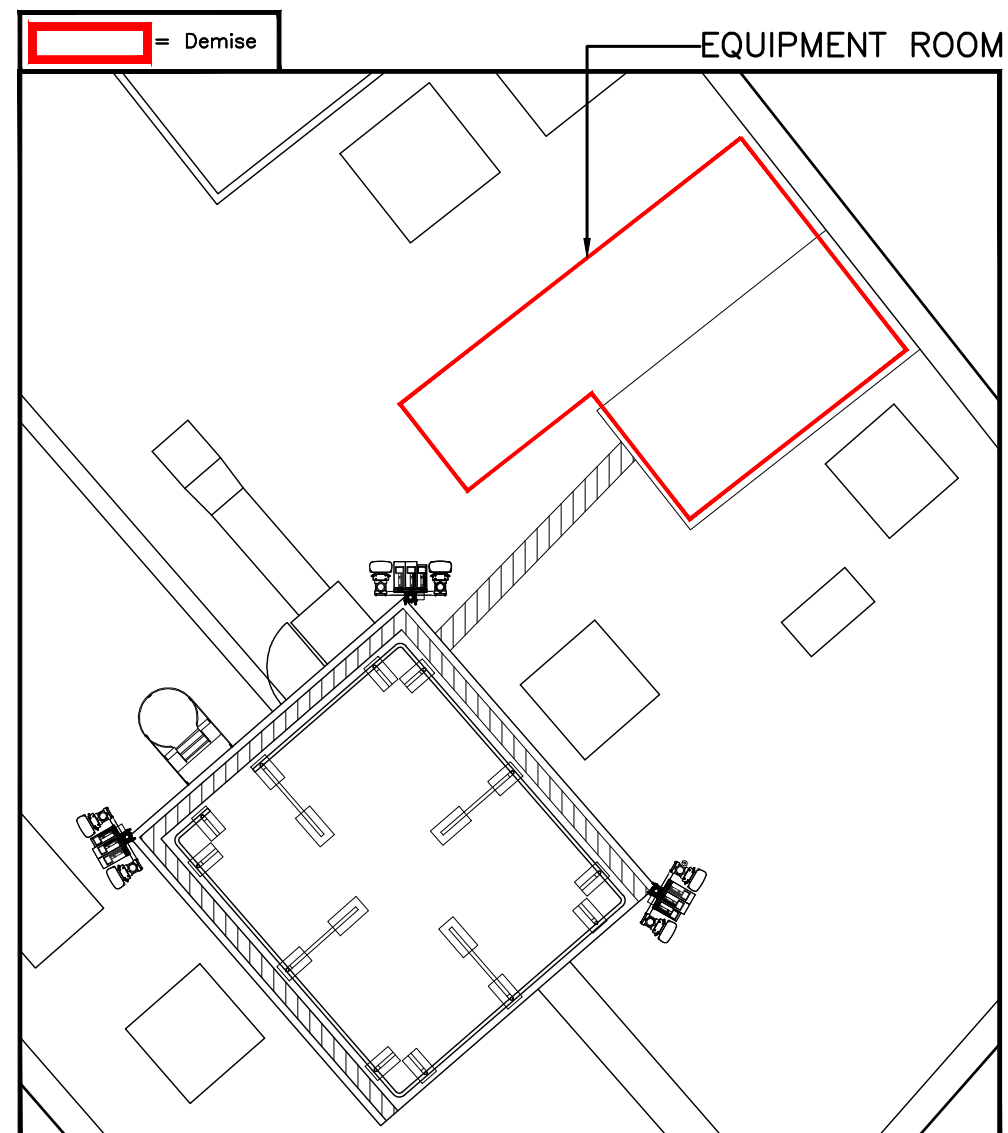

DEMISE PLAN

 (1:100)



ALL DIMENSIONS ARE IN mm UNLESS NOTED OTHERWISE

N.G.R. E: 468240 N: 109310

NOTES:

REV	MODIFICATION	BY	CH	DATE
A	Issued for Approval	BP	RP	17.03.2023

ERICSSON
COMMScope
COMMScope DESIGN & INTEGRATION UK LTD
100 NEW BRIDGE STREET
LONDON
EC4V 6JA
Email:—chris.serjeant@commscope.com



CORNERSTONE - METROPOLIS 5G


Cell Name		Opt.
PEACOCK STORES		A
Cell ID No		
CORNERSTONE	VMO2	VF
E315081		
12766924	034241	86536_9

Site Address / Contact Details

288 LONDON ROAD
WATERLOOVILLE
HAMPSHIRE
PO7 7DS

Drawing Title:		LEASE DRAWING	
Purpose of issue:		PLANNING	Dwg Rev:
Drawing Number:		101	A
Surveyed By:		Original Sheet Size:	Pack Issue:
COMMScope		A3	
Drawn:	Date:	Checked:	Date:
BP	17.03.2023	RP	17.03.2023

These drawings comply with TEF and VF Non-Standard ICNIRP Guidelines under configuration VM7F.
Designed in accordance with Cornerstone Document : SDN0013 & SDN0009 "ICNIRP Compliance Summary v5"

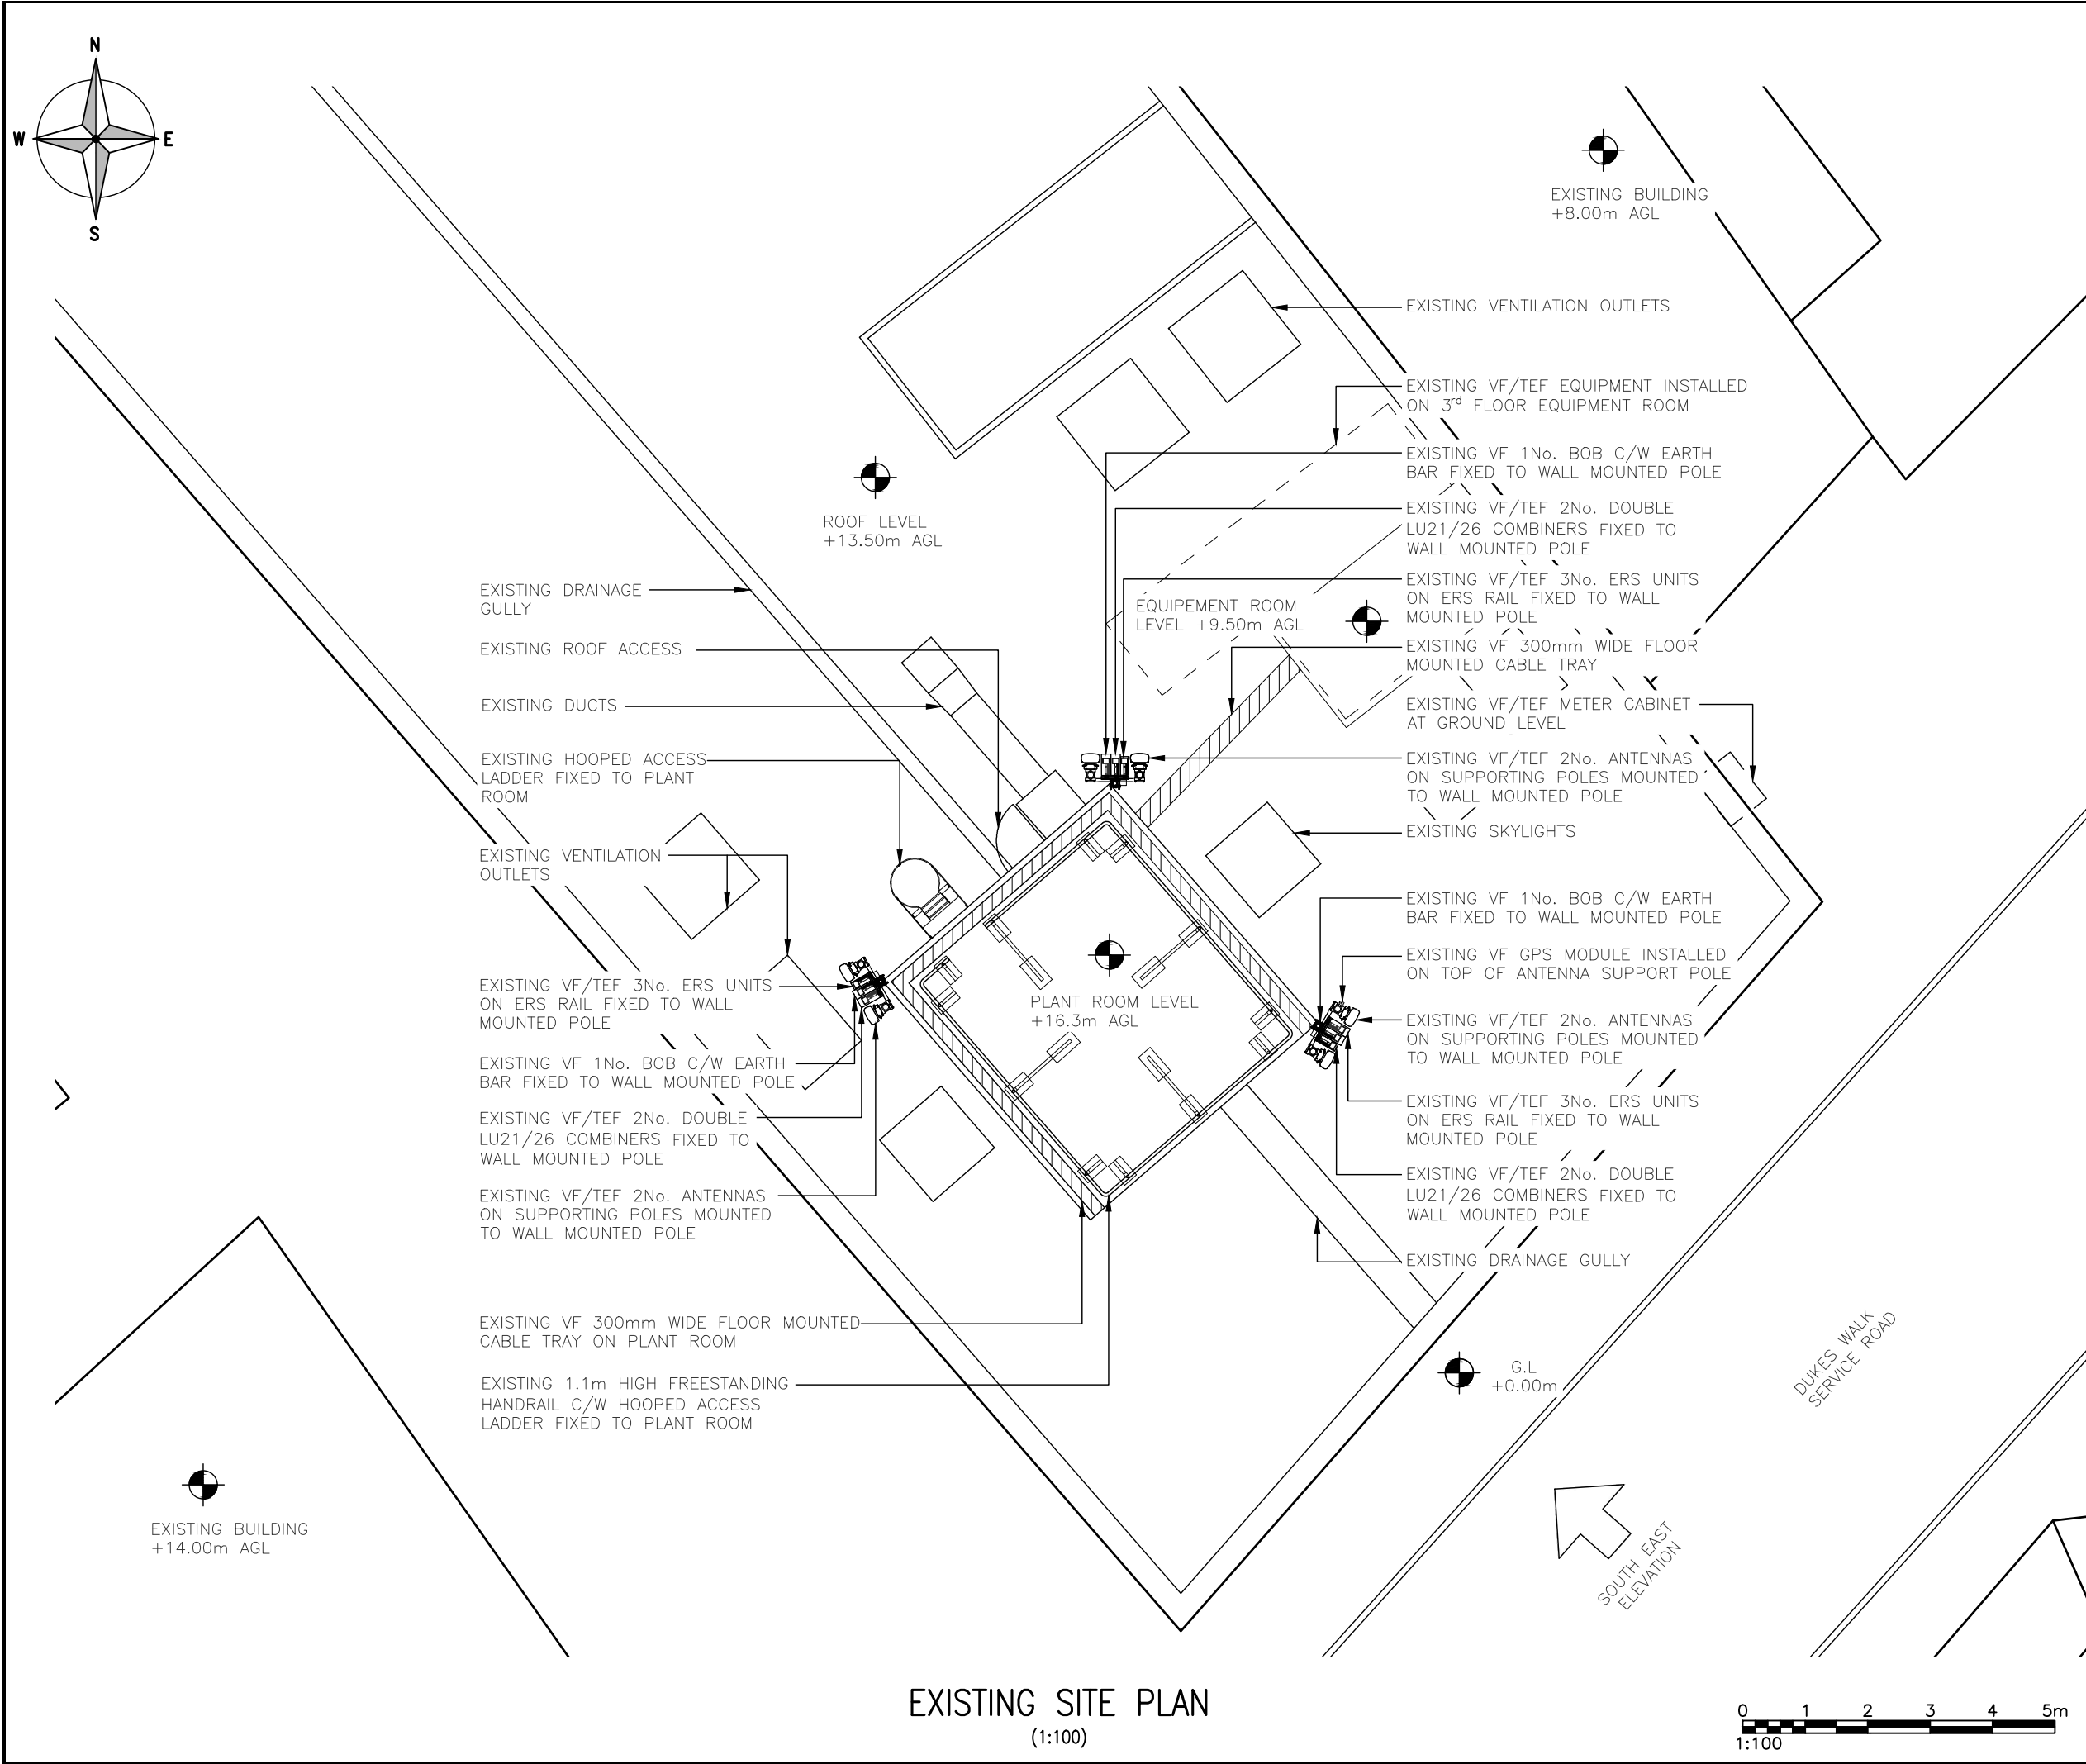

ALL DIMENSIONS ARE IN mm UNLESS NOTED OTHERWISE

N.G.R

E: 468240

N: 109310

NOTES:

A	Issued for Approval	RS	RP	17.03.2023
REV	MODIFICATION	BY	CH	DATE

ERICSSON

COMMSCOPE[®]

COMMSCOPE DESIGN & INTEGRATION UK LTD
100 NEW BRIDGE STREET
LONDON
EC4V 6JA
Email:—chris.serjeant@commscope.com

vodafone

CORNERSTONE - METROPOLIS 5G

Cell Name			Opt.
PEACOCK STORES			A
Cell ID No			
CORNERSTONE	VMO2	VF	
E315081			
12766924	034241	86536_9	

Site Address / Contact Details

288 LONDON ROAD
WATERLOOVILLE
HAMPSHIRE
PO7 7DS


Drawing Title:
EXISTING SITE PLAN


Purpose of issue:		Dwg Rev:
PLANNING		

Drawing Number:		
200		A

Surveyed By: COMMSCOPE		Original Sheet Size: A3		Pack Issue:
Drawn: BP	Date: 17.03.2023	Checked: RP	Date: 17.03.2023	A

 EXISTING SITE PLAN
(1:100)



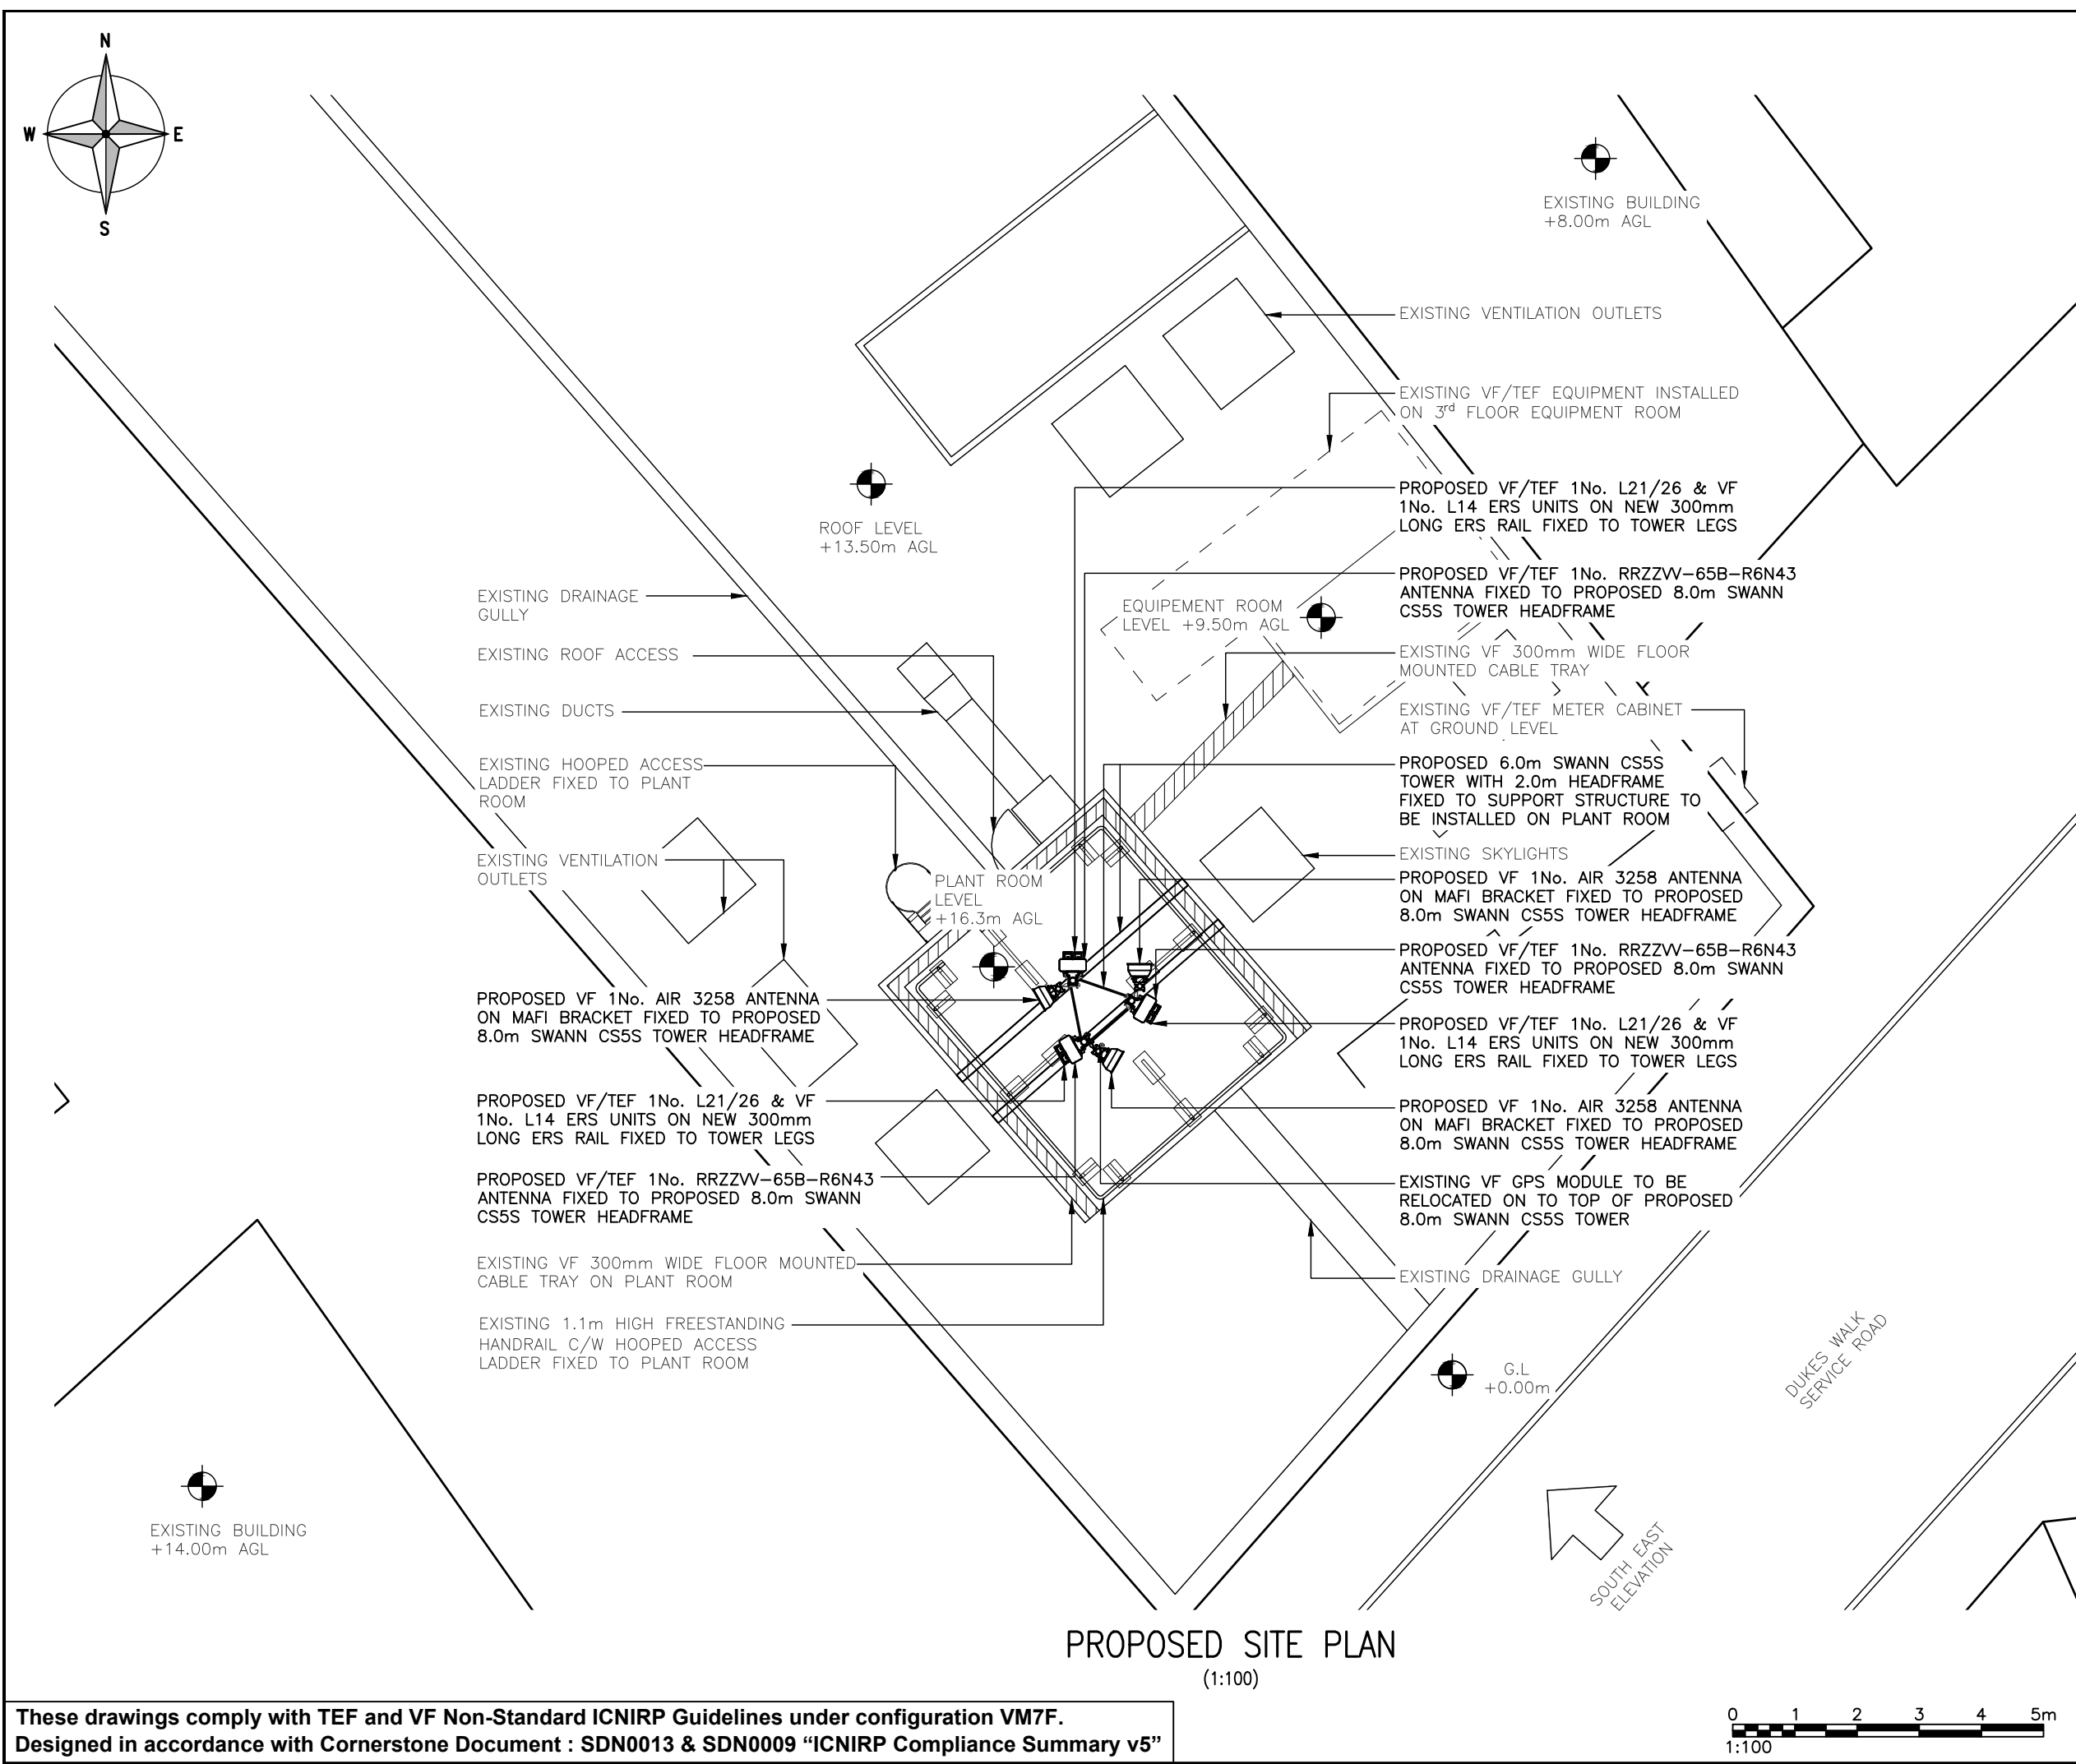

ALL DIMENSIONS ARE IN mm UNLESS NOTED OTHERWISE

N.G.R

E: 468240

N: 109310

NOTES:

- REPLACE 2100 / 2600 SB ERS WITH DUAL BAND RADIOS, ADD L14 (4-WAY), 3X NEW 12 PORT RRZZV-65B-R6N43 ANTENNAS, 3X NEW 3258 ANTENNAS. ON NEW PROPOSED 8.0m (WITH 2.0m HEADFRAME) TOWER.
- EXISTING ANTENNAS, 21/26 COMBINERS, BOB's & SUPPORT POLES TO BE REMOVED
- OUTDOOR EQUIPMENT CABINETS MOUNTED ON GRILLAGE WITHIN NEWLY ENCLOSED ROOM – NEW COMMSCOPE MONITOR II COOLING SYSTEM TO BE INSTALLED
- TO MITIGATE ICNIRP ISSUES, EXISTING ANTENNA POLES TO BE REPLACED BY 8.0m (WITH 2.0m HEADFRAME) TOWER MOUNTED ON STEELWORK FRAME ABOVE THE PLANT ROOM ROOF. STEEL SUPPORT FRAME TO BE FIXED TO WALLS OF PLANT ROOM USING THROUGH-BOLTS

A	Issued for Approval	BP	RP	17.03.2023
REV	MODIFICATION	BY	CH	DATE

ERICSSON

COMMSCOPE[®]


COMMSCOPE DESIGN & INTEGRATION UK LTD
100 NEW BRIDGE STREET
LONDON
EC4V 6JA
Email:—chris.serjeant@commscope.com

vodafone


CORNERSTONE - METROPOLIS 5G

Cell Name		Opt.
PEACOCK STORES		A
Cell ID No		
CORNERSTONE	VMO2	VF
E315081		
12766924	034241	86536_9
Site Address / Contact Details		
288 LONDON ROAD WATERLOOVILLE HAMPSHIRE PO7 7DS		
Drawing Title: PROPOSED SITE PLAN		
Purpose of issue: PLANNING		Dwg Rev:
Drawing Number: 201		A
Surveyed By: COMMSCOPE	Original Sheet Size: A3	Pack Issue:
Drawn: BP	Date: 17.03.2023	Checked: RP
	Date: 17.03.2023	A

These drawings comply with TEF and VF Non-Standard ICNIRP Guidelines under configuration VM7F.
Designed in accordance with Cornerstone Document : SDN0013 & SDN0009 "ICNIRP Compliance Summary v5"

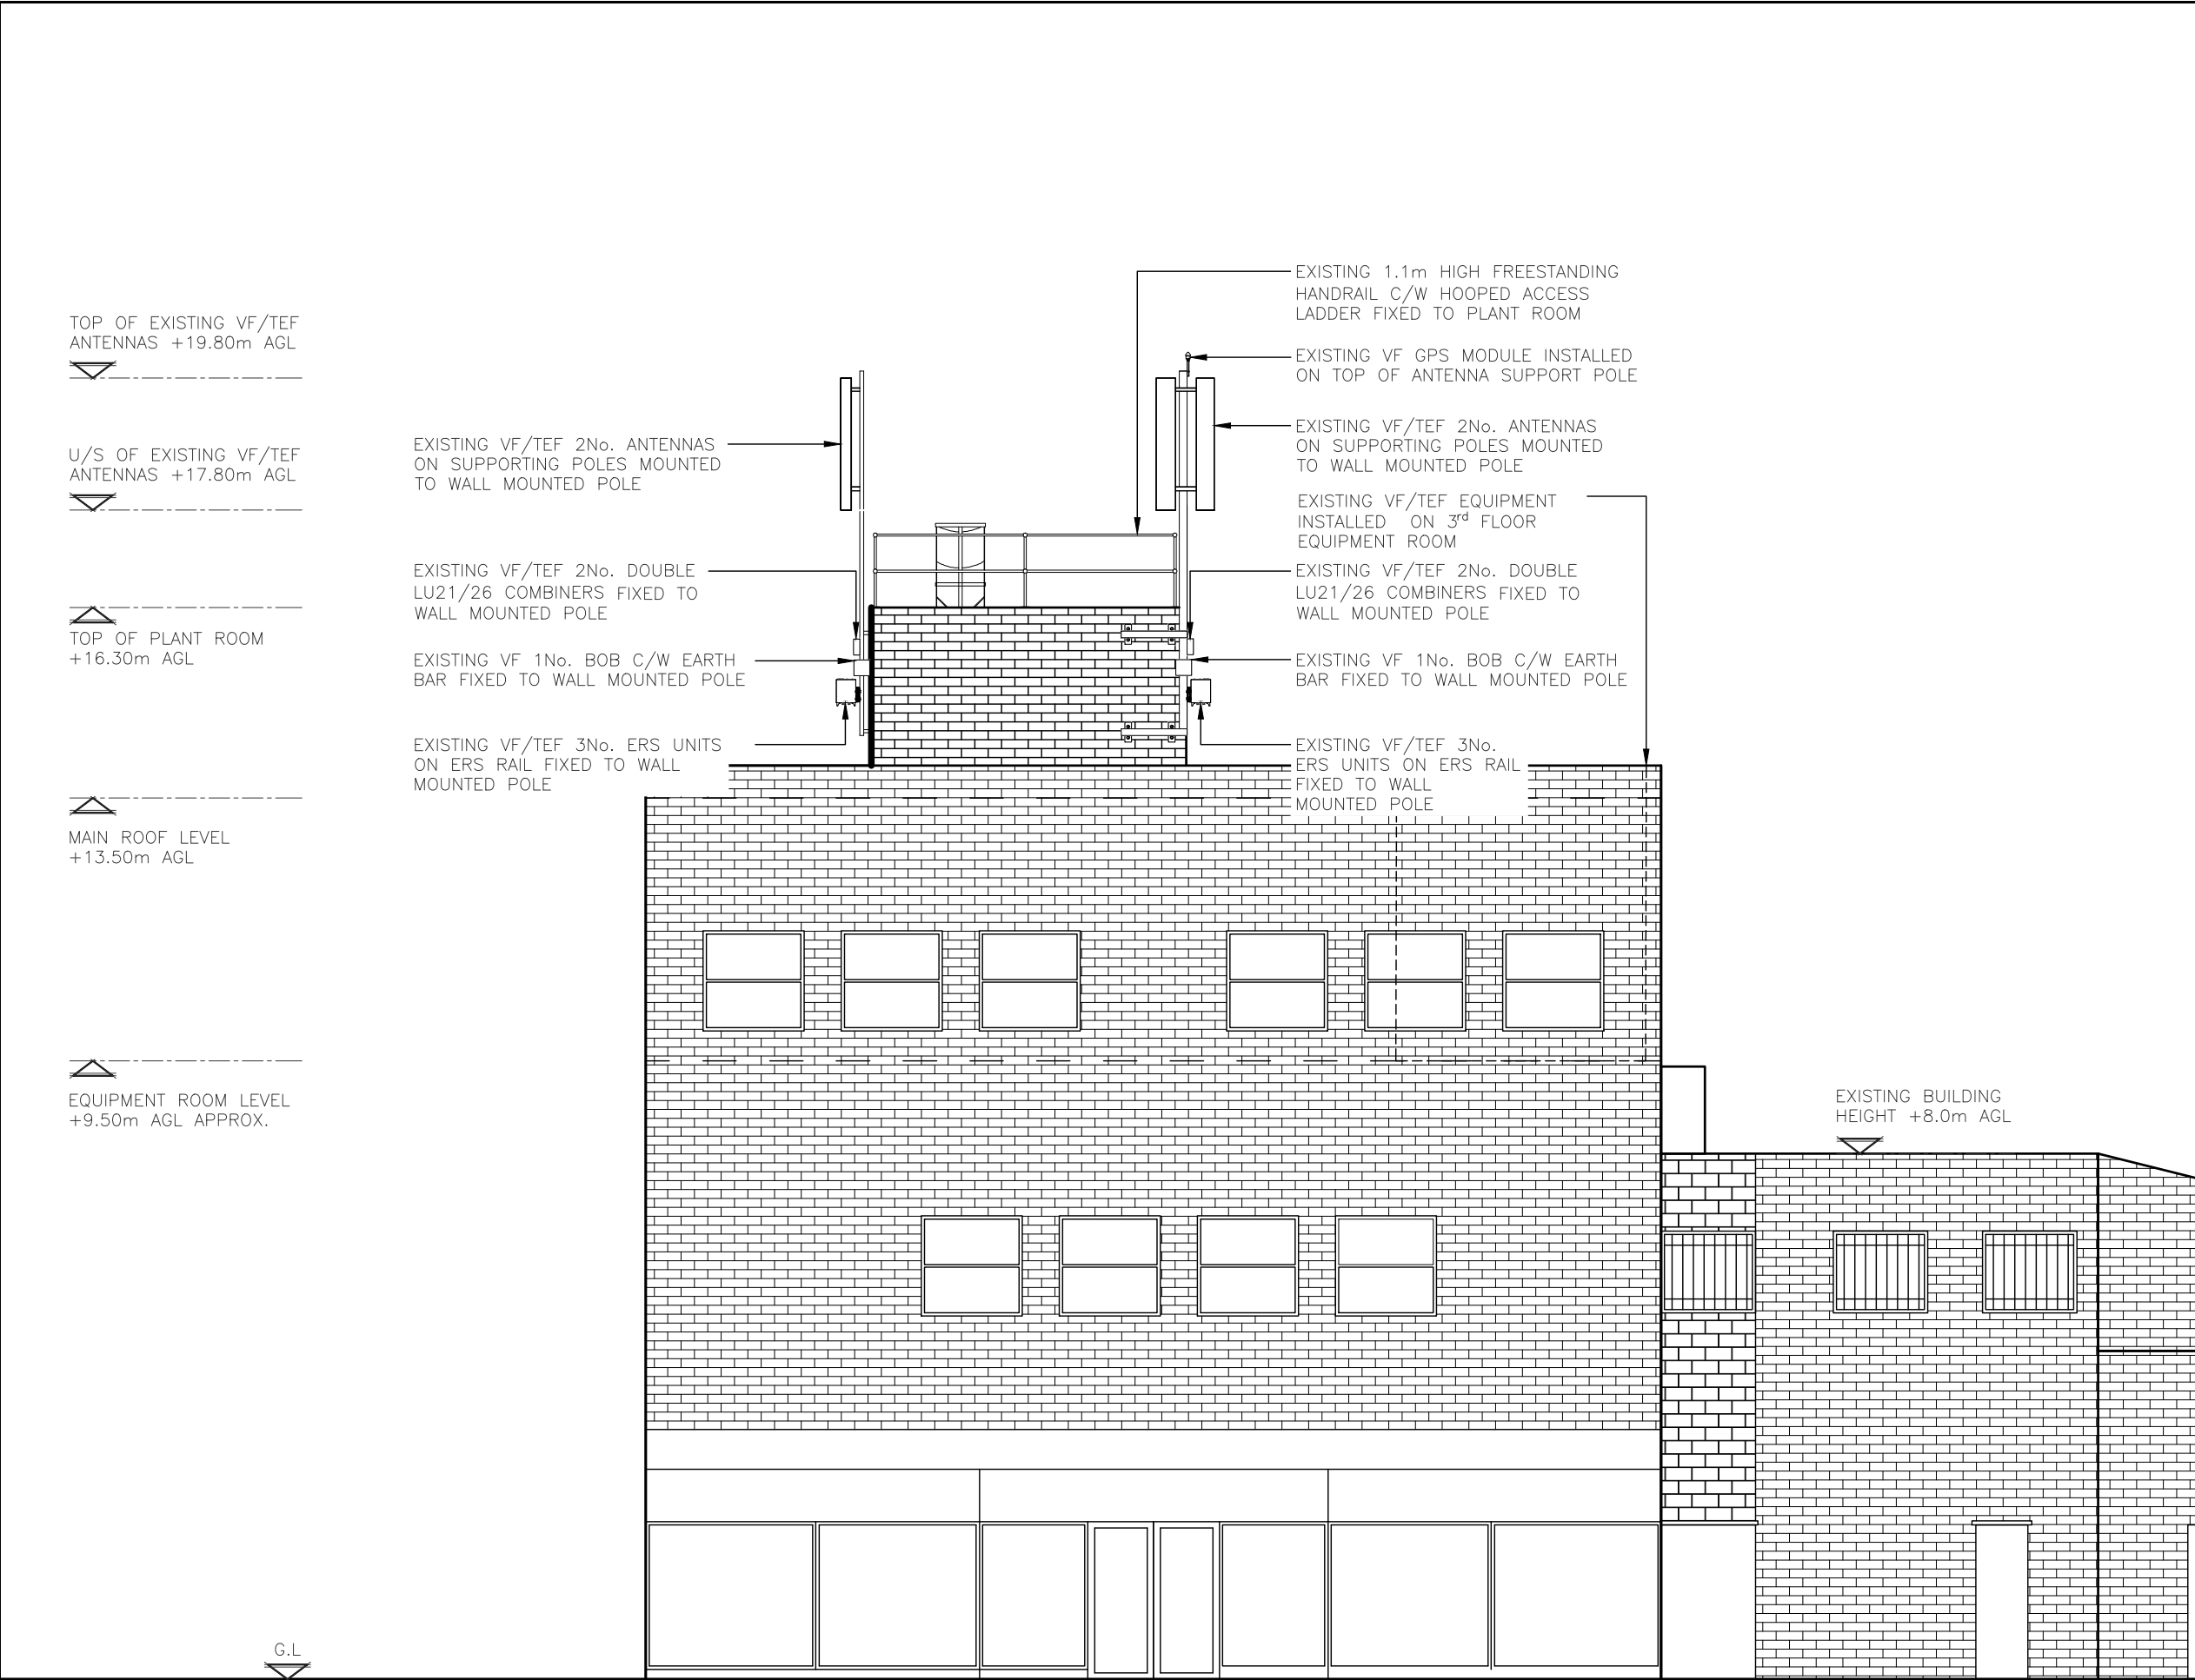

EXISTING SOUTH EAST ELEVATION
(1:100)

 

ALL DIMENSIONS ARE IN mm UNLESS NOTED OTHERWISE

N.G.R

E: 468240

N: 109310

NOTES:

A	Issued for Approval	BP	RP	17.03.2023
REV	MODIFICATION	BY	CH	DATE

ERICSSON

COMMScope[®]

COMMScope DESIGN & INTEGRATION UK LTD
100 NEW BRIDGE STREET
LONDON
EC4V 6JA
Email:—chris.serjeant@commscope.com

CORNERSTONE - METROPOLIS 5G

Cell Name		Opt.
PEACOCK STORES		A
Cell ID No		
CORNERSTONE	VMO2	VF
E315081		
12766924	034241	86536_9
Site Address / Contact Details		
288 LONDON ROAD WATERLOOVILLE HAMPSHIRE PO7 7DS		

Drawing Title:
EXISTING SITE ELEVATION

Purpose of issue:		Dwg Rev:		
PLANNING				
Drawing Number:				
300		A		
Surveyed By:		Original Sheet Size:		
COMMScope		A3		
Pack Issue:				
Drawn:	Date:	Checked:	Date:	
BP	17.03.2023	RP	17.03.2023	A

