

EXTENT OF WORKS LIES WITHIN A SOURCE PROTECTION ZONE. ALL WORKS TO BE UNDERTAKEN IN ACCORDANCE WITH APPROVED CEMP AND FRAP REQUIREMENTS, AND TO COMPLY WITH APPROVED DESIGN


CONTRACTOR NOTES

- EXCAVATION UNDERTAKEN IN SOURCE PROTECTION ZONE 1 AREA THAT IS MONITORED FOR GROUND WATER QUALITY.
- CAREFUL CONSIDERATION REQUIRED WHEN EXCAVATING CHALK MATERIAL AND STORING WET CONDITIONS.
- WATER RUNOFF TO BE CAREFULLY CONTROLLED DURING THE WORKS, PARTICULARLY WITHIN EXCAVATIONS.

NOTES

- DO NOT SCALE.
- UNLESS OTHERWISE STATED ALL DIMENSIONS ARE IN MILLIMETRES AND ALL INVERTS IN METRES AOD.
- ALL CIVIL WORKS IS THE RESPONSIBILITY OF THE DEVELOPER OR CONTRACTOR INCLUDING FIXING OF STEELWORK SUCH AS ACCESS COVERS AND PENSTOCKS ETC. INSTALLATION OF CABLE DUCTS, BENCHING AND MAKING GOOD AROUND PIPES AFTER INSTALLATION.
- REINFORCING BARS ARE TO BE A MINIMUM OF 75MM BELOW THE SURFACE, ANY STRUCTURAL DETAILING / CIVIL WORKS SHOWN ON THIS DRAWING ARE ILLUSTRATIVE ONLY UNLESS OTHERWISE STATED AND SHOULD NOT BE USED FOR CONSTRUCTION.
- BENCHING IS TO BE FORMED AFTER PUMP INSTALLATION AND TO BE IN ACCORDANCE WITH THE APPLICABLE SEWERS FOR ADOPTION AND ADOPTING AUTHORITY SPECIFICATION.
- UNLESS OTHERWISE STATED, ALL DUCTS ARE TO BE Ø100MM AND BE COMPLETE WITH DRAW ROPES, SERVICE DUCTS TO BE TO THE UTILITY SUPPLIERS SPECIFICATION.
- DUCT ROUTES ARE SHOWN DIAGRAMMATICALLY ONLY, ALL DUCTS LAID IN THE MOST DIRECT ROUTE TO SUIT THE SERVICE BEING CARRIED AVOIDING ANY ACUTE CHANGES OF DIRECTION.
- LEVEL CONTROL POSITIONS ARE SHOWN DIAGRAMMATICALLY ONLY, THEY WILL BE POSITIONED AWAY FROM OBSTRUCTIONS AND BE READILY ADJUSTABLE AFTER INSTALLATION.

TO BE READ IN CONJUNCTION WITH MJA CONSULTING STRUCTURAL DESIGN

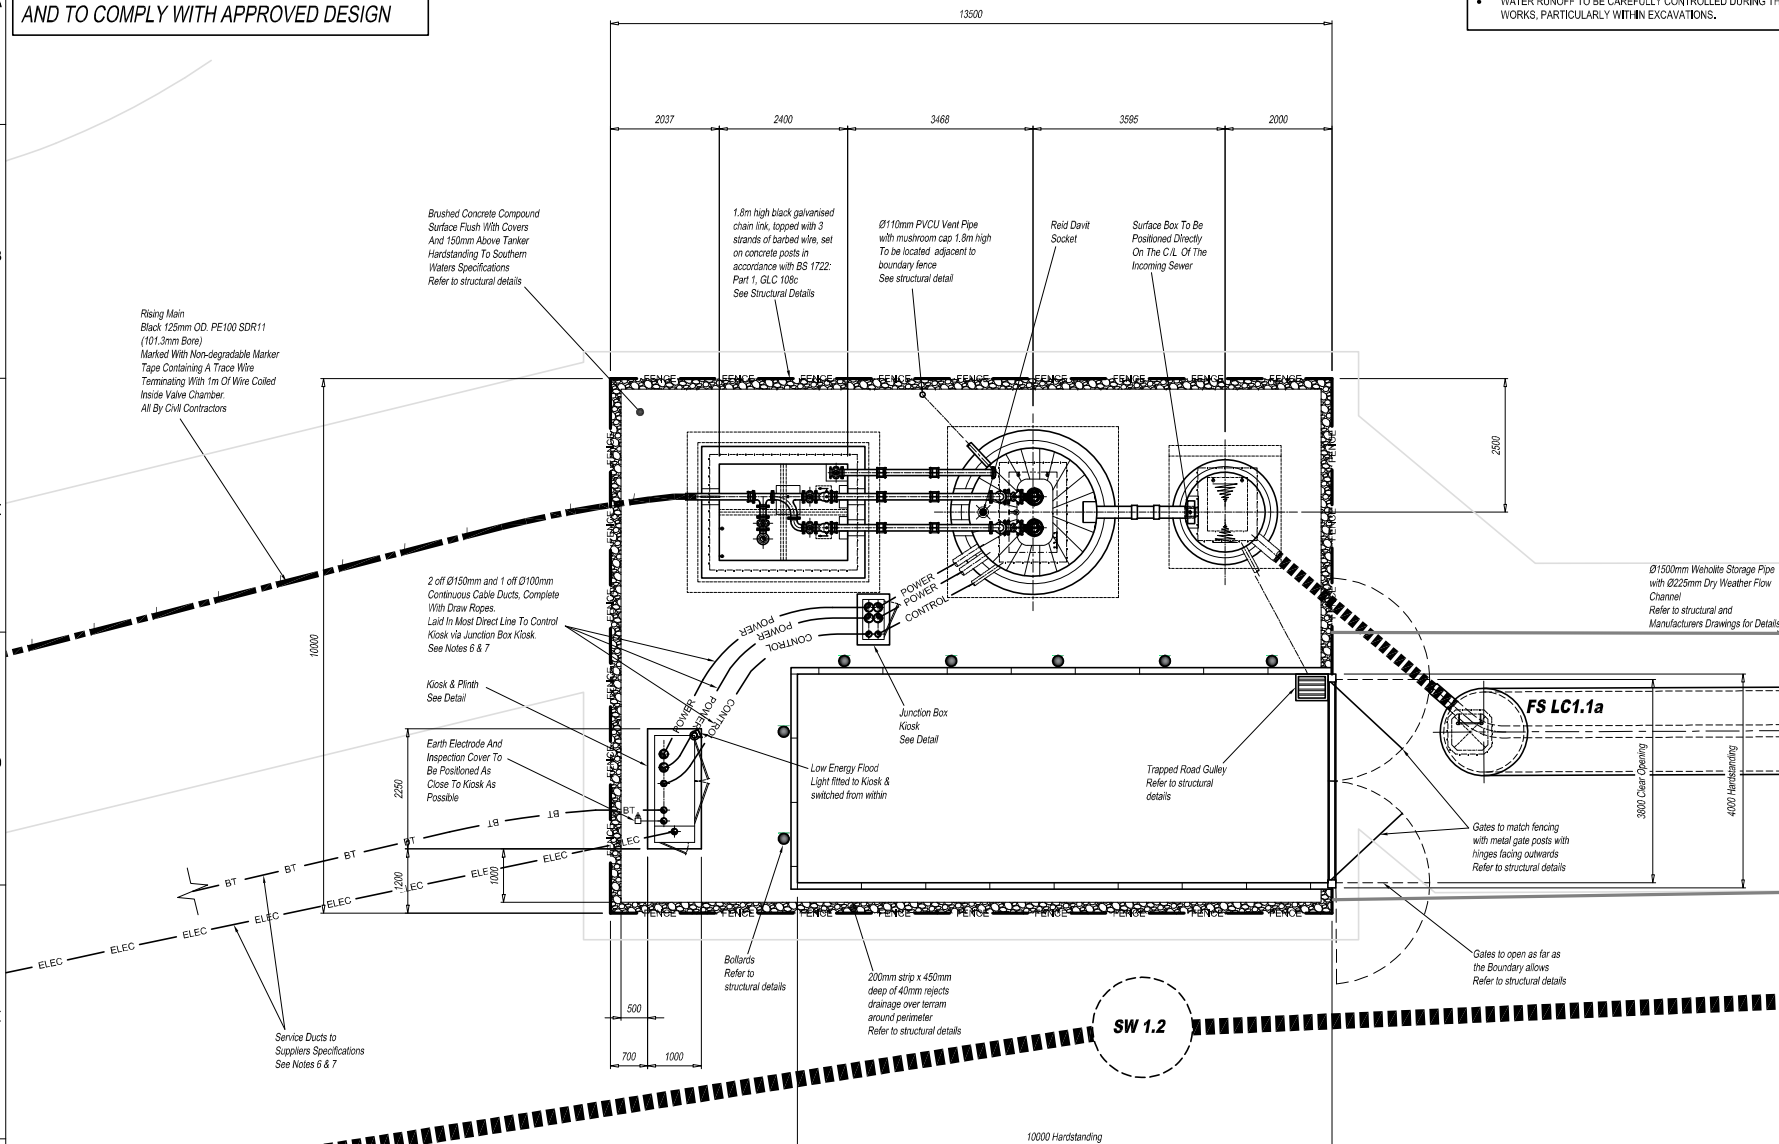

REV	DATE	DESCRIPTION	DR'n	CHK'd	APR
E	20/11/20	Marked for Construction Issue	N.K.	E.W.	P.W.
D	25/08/20	Penstock and Incoming Sewer diameter updated, Storage Tank DWF diameter updated, Site Plan updated to Clients latest Drawings.	N.K.	E.W.	P.W.
C	15/04/20	Flood Light added to Kiosk, Vent stack height amended to 1.8m, Gate Fence posts changed to Metal.	N.K.	E.W.	P.W.
B	17/10/19	Updated in line with latest structural details.	E.W.	-	P.W.
A	17/09/19	Junction Box Kiosk and Reject Strip added, Updated inline with Southern water requirements.	L.C.	-	P.W.

CONSTRUCTION ISSUE




Pump Design and Services Ltd

UNIT 7 STANMORE GATE, STANMORE ROAD, CAMBERLEY, SURREY, GU24 0EW
01443 700201
WWW.PDASLTD.CO.UK

PROJECT	WOODCROFT FARM HAMPSHIRE		
TITLE	FOUL WATER PUMP STATION SITE PLAN		
CLIENT	DERWENT DEVELOPMENTS LIMITED		
SCALE AT A1	1:50	SCALE AT A3	1:100
QUOTE NUMBER	Q10917	APR P.W.	DATE 29-11-2018
PROJECT REF.	PR10514	CHK P.W.	DATE 29-11-2018
DRAWING NUMBER	PR10514 - 004	DR E.W.	DATE 29-11-2018


EXTENT OF WORKS LIES WITHIN A SOURCE PROTECTION ZONE. ALL WORKS TO BE UNDERTAKEN IN ACCORDANCE WITH APPROVED CEMP AND FRAP REQUIREMENTS, AND TO COMPLY WITH APPROVED DESIGN

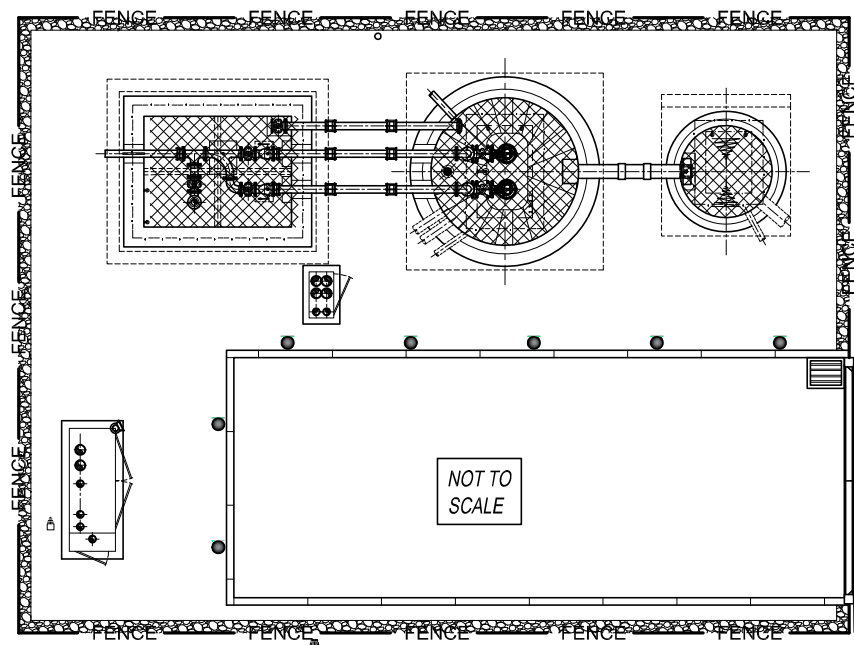


- CONTRACTOR NOTES
- EXCAVATION UNDERTAKEN IN SOURCE PROTECTION ZONE 1 AREA THAT IS MONITORED FOR GROUND WATER QUALITY.
 - CAREFUL CONSIDERATION REQUIRED WHEN EXCAVATING CHALK MATERIAL AND STORING WET CONDITIONS.
 - WATER RUNOFF TO BE CAREFULLY CONTROLLED DURING THE WORKS, PARTICULARLY WITHIN EXCAVATIONS.

- NOTES
- DO NOT SCALE.
 - UNLESS OTHERWISE STATED ALL DIMENSIONS ARE IN MILLIMETRES AND ALL INVERTS IN METRES AOD.
 - ALL CIVIL WORKS IS THE RESPONSIBILITY OF THE DEVELOPER OR CONTRACTOR INCLUDING FIXING OF STEELWORK SUCH AS ACCESS COVERS AND PENSTOCKS ETC. INSTALLATION OF CABLE DUCTS, BENCHING AND MAKING GOOD AROUND PIPES AFTER INSTALLATION.
 - REINFORCING BARS ARE TO BE A MINIMUM OF 75MM BELOW THE SURFACE. ANY STRUCTURAL DETAILING / CIVIL WORKS SHOWN SHOWN ON THIS DRAWING ARE ILLUSTRATIVE ONLY UNLESS OTHERWISE STATED AND SHOULD NOT BE USED FOR CONSTRUCTION.
 - BENCHING IS TO BE FORMED AFTER PUMP INSTALLATION AND TO BE IN ACCORDANCE WITH THE APPLICABLE SEWERS FOR ADOPTION AND ADOPTING AUTHORITY SPECIFICATION.
 - UNLESS OTHERWISE STATED, ALL DUCTS ARE TO BE Ø100MM AND BE COMPLETE WITH DRAW ROPES. SERVICE DUCTS TO BE TO THE UTILITY SUPPLIERS SPECIFICATION.
 - DUCT ROUTES ARE SHOWN DIAGRAMMATICALLY ONLY. ALL DUCTS LAID IN THE MOST DIRECT ROUTE TO SUIT THE SERVICE BEING CARRIED AVOIDING ANY ACUTE CHANGES OF DIRECTION.
 - LEVEL CONTROL POSITIONS ARE SHOWN DIAGRAMMATICALLY ONLY. THEY WILL BE POSITIONED AWAY FROM OBSTRUCTIONS AND BE READILY ADJUSTABLE AFTER INSTALLATION.

TO BE READ IN CONJUNCTION WITH MJA CONSULTING STRUCTURAL DESIGN

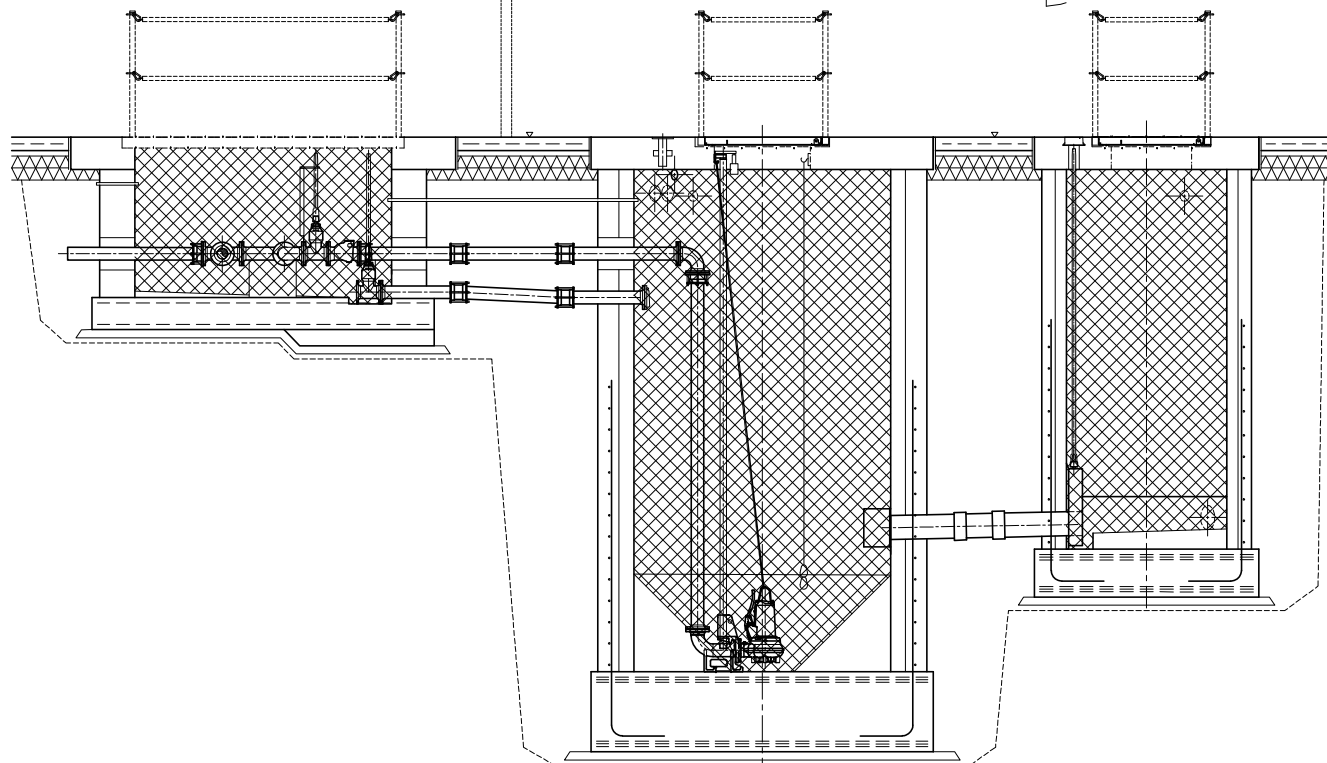

Cable Ducts in accordance with SFA7 F.3.4.4 and BS EN 1401-01 & BS 4690 sealed with rise sealant system Gas + waterproof sealant system

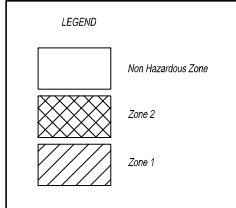

E	20/11/20	Marked for Construction Issue	NJK	E.W.	P.W.
D	25/08/20	Penstock and Incoming Sewer diameter updated.	NJK	E.W.	P.W.
C	15/04/20	Wet Well access cover hinge amended. Flood Light added to kiosk. Vent Stack height amended to 1.8m.	NJK	E.W.	P.W.
B	17/10/19	Updated in line with latest structural details.	E.W.	-	P.W.
A	17/09/19	Updated to reflect Site plan drawing.	L.C.	-	P.W.
REV	DATE	DESCRIPTION	DR'n	CHK'd	APR'l

CONSTRUCTION ISSUE

Pump Design and Services Ltd

UNIT 1 STANBORO GATE, STANBORO ROAD, CAMBERLEY, SURREY, GU15 2DW
01443 816100
WWW.PDASLTD.CO.UK

PROJECT: WOODCROFT FARM HAMPSHIRE

TITLE: FOUL WATER PUMP STATION HAZARDOUS ZONING

CLIENT: DERWENT DEVELOPMENTS LIMITED

SCALE AT A1: 1:25
SCALE AT A3: 1:50

QUOTE NUMBER: Q10917
PROJECT REF: PR10514
DRAWING NUMBER: PR10514 - 008

APR'D: P.W.
CHK'D: P.W.
DRN: E.W.

DATE: 29-11-2018
DATE: 29-11-2018
DATE: 29-11-2018