


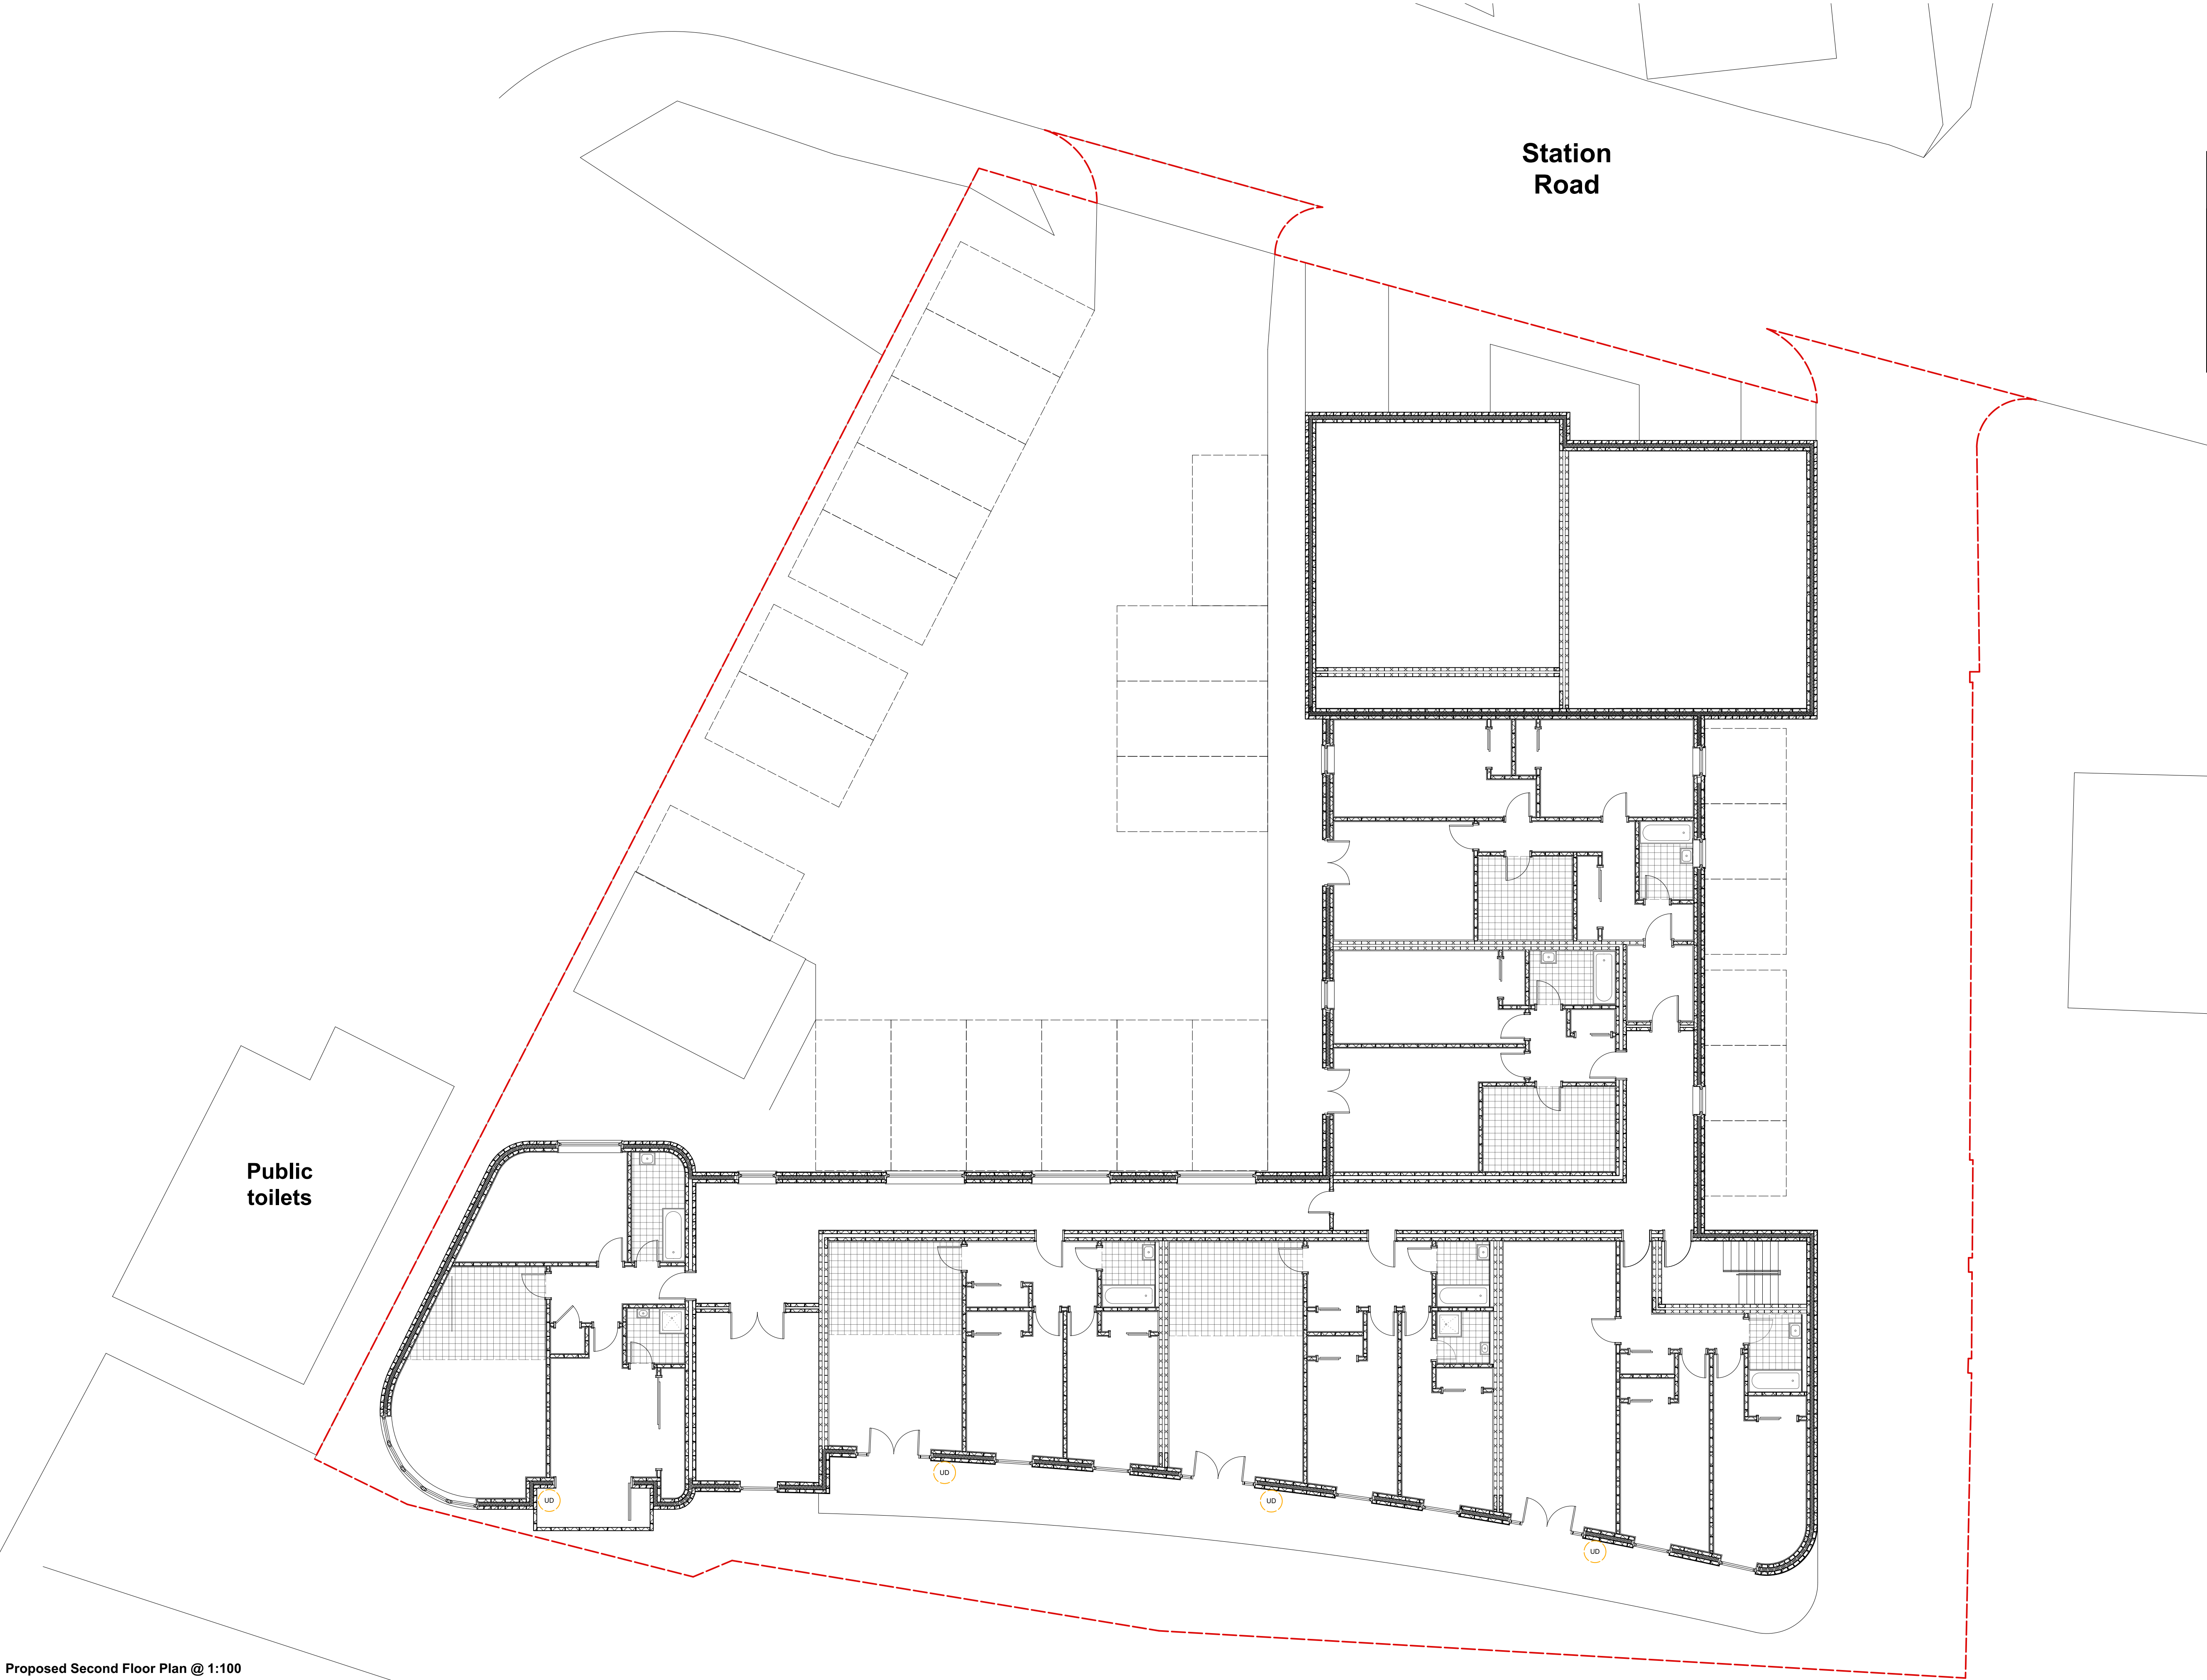

Proposed Second Floor Plan @ 1:100

KEY (External Lighting)

UD

Sensor Up Down Wall Light

- Warm white (3000K)
- Wattage: 12.5W LED
- Light output: 858 lm
- IP code: IP44

NOT FOR CONSTRUCTION

Amendments	by	Date

Job Title

123/SR/DL

Proposed Second Floor
(External lighting)

Scale: 1:100

Drg.No: HOPA-014-P

Drawn by: KC

Issued to: Client / LA

Status: Planning Condition

Date: 09.04.21

HOP

RIBA

ARB

Architects

HOP Architects Ltd

Business Support
01472 880122
Company no. 10571891