




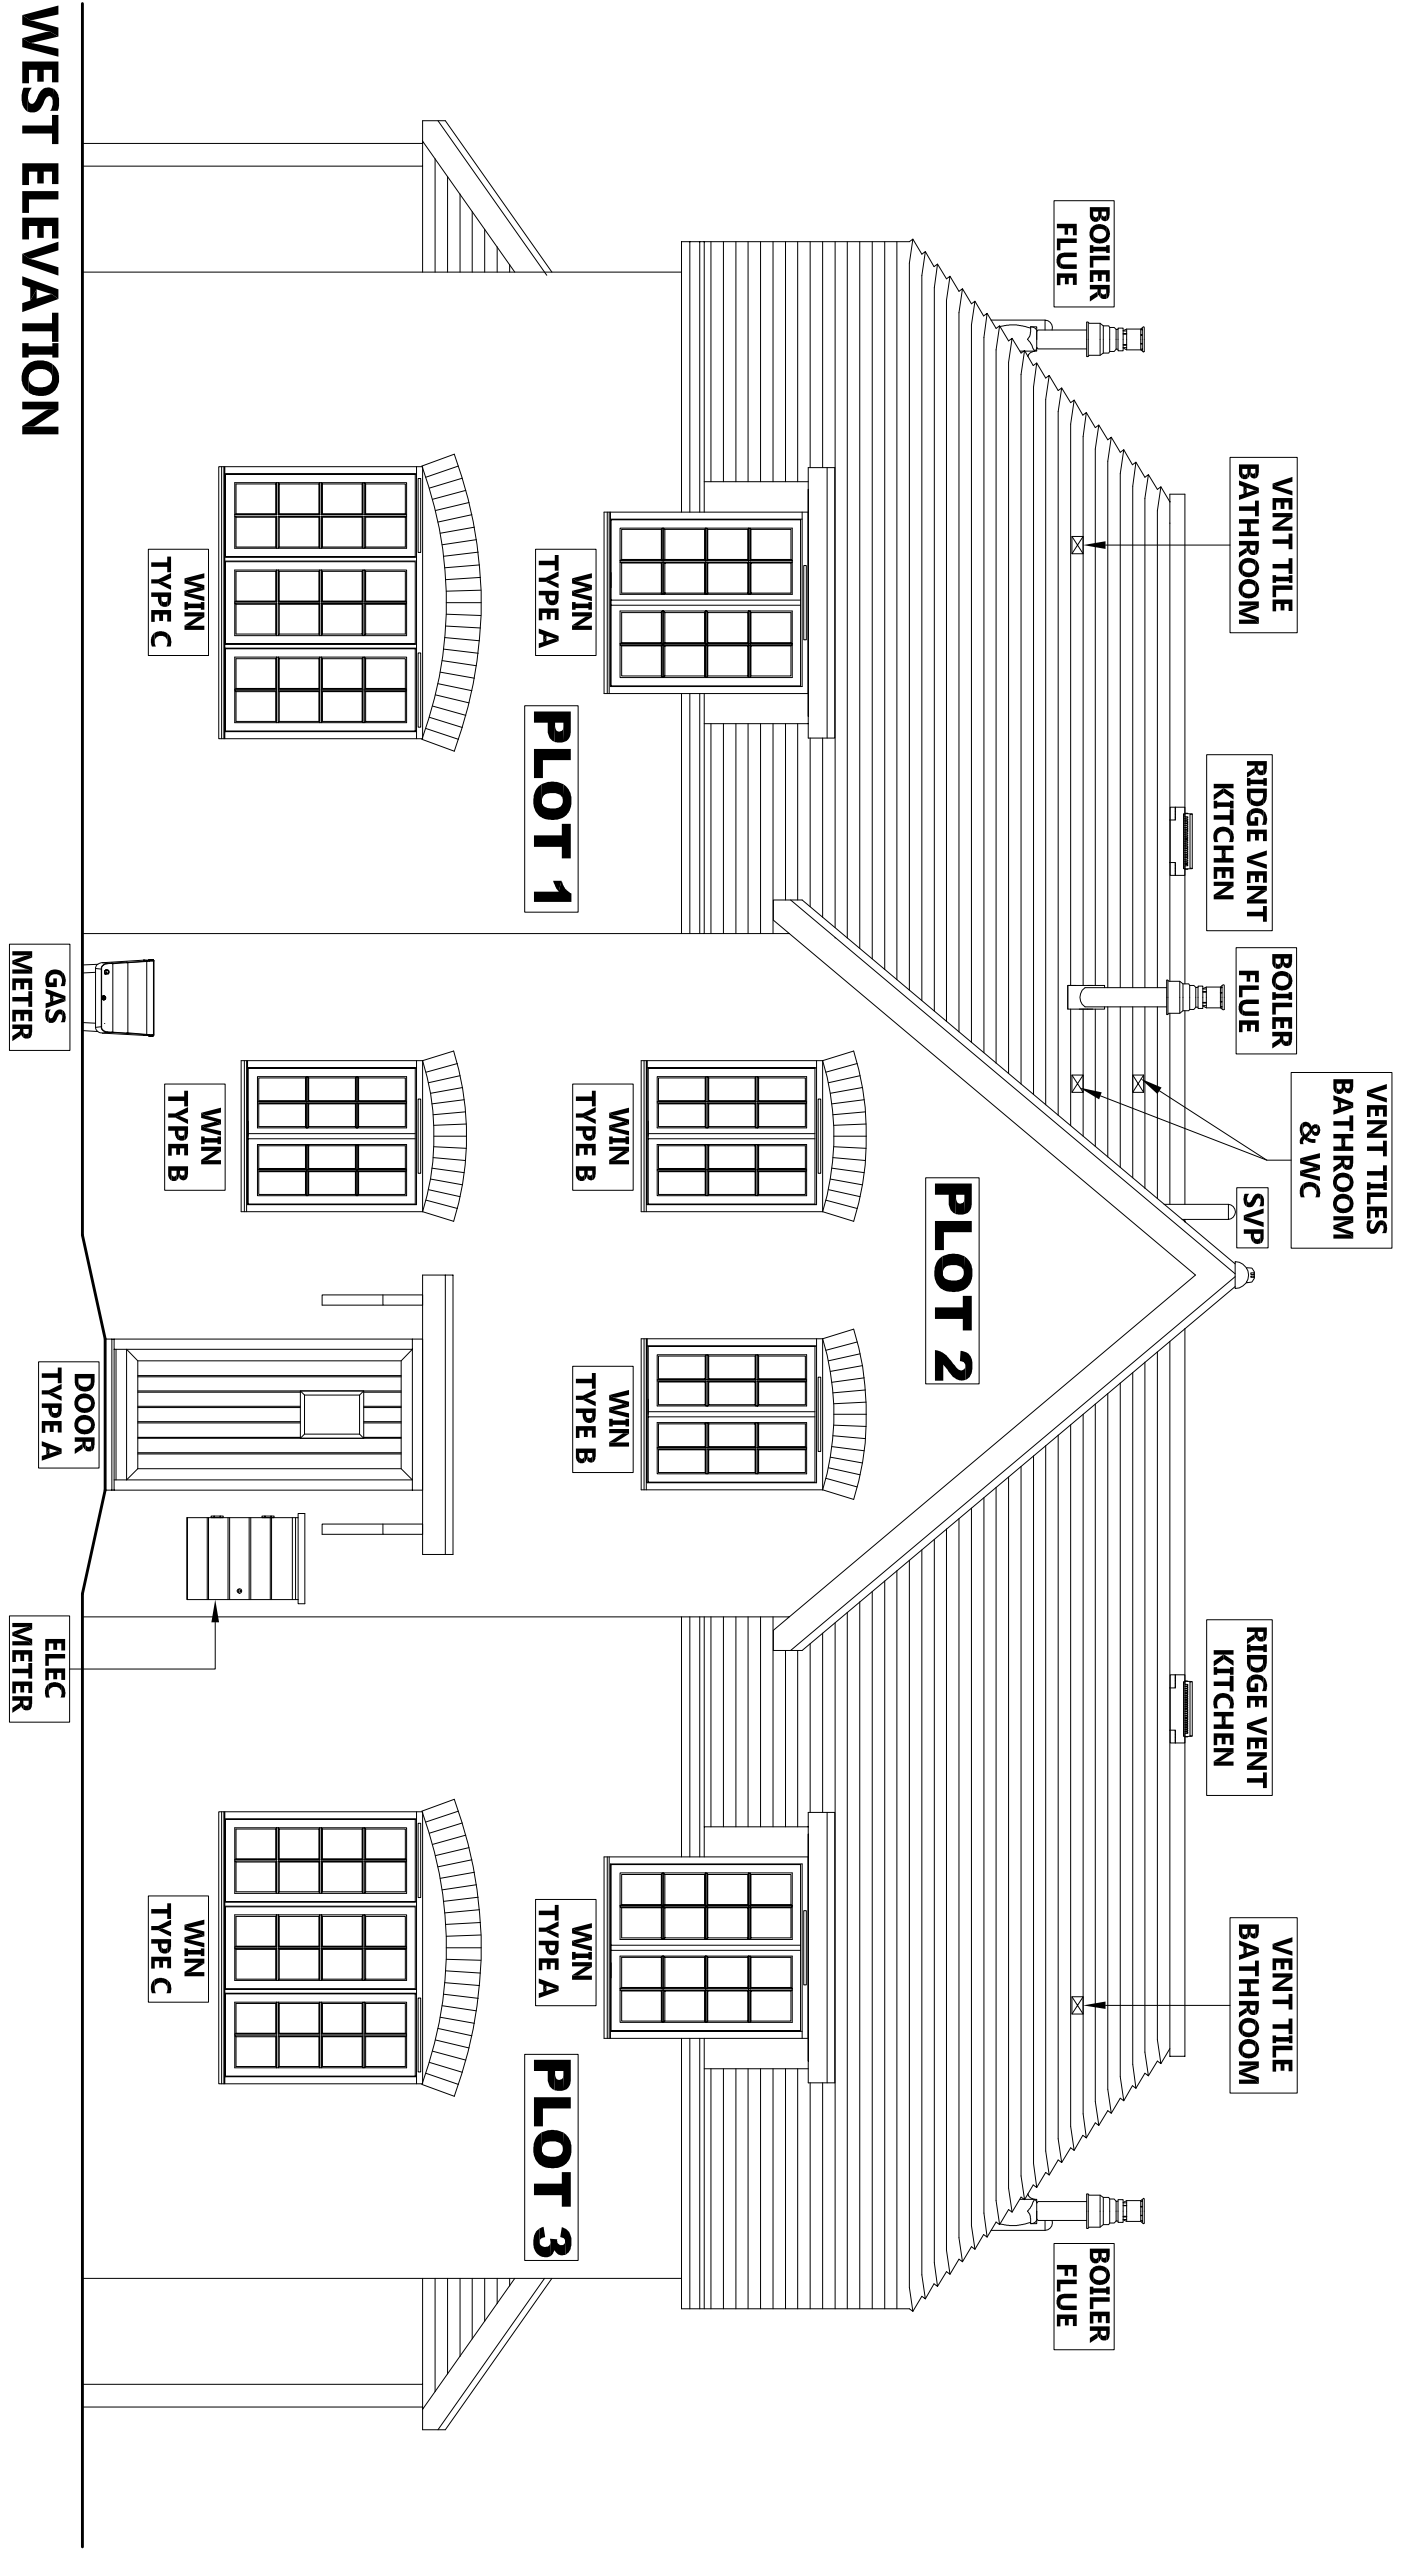


WEST ELEVATION
@ 1:50

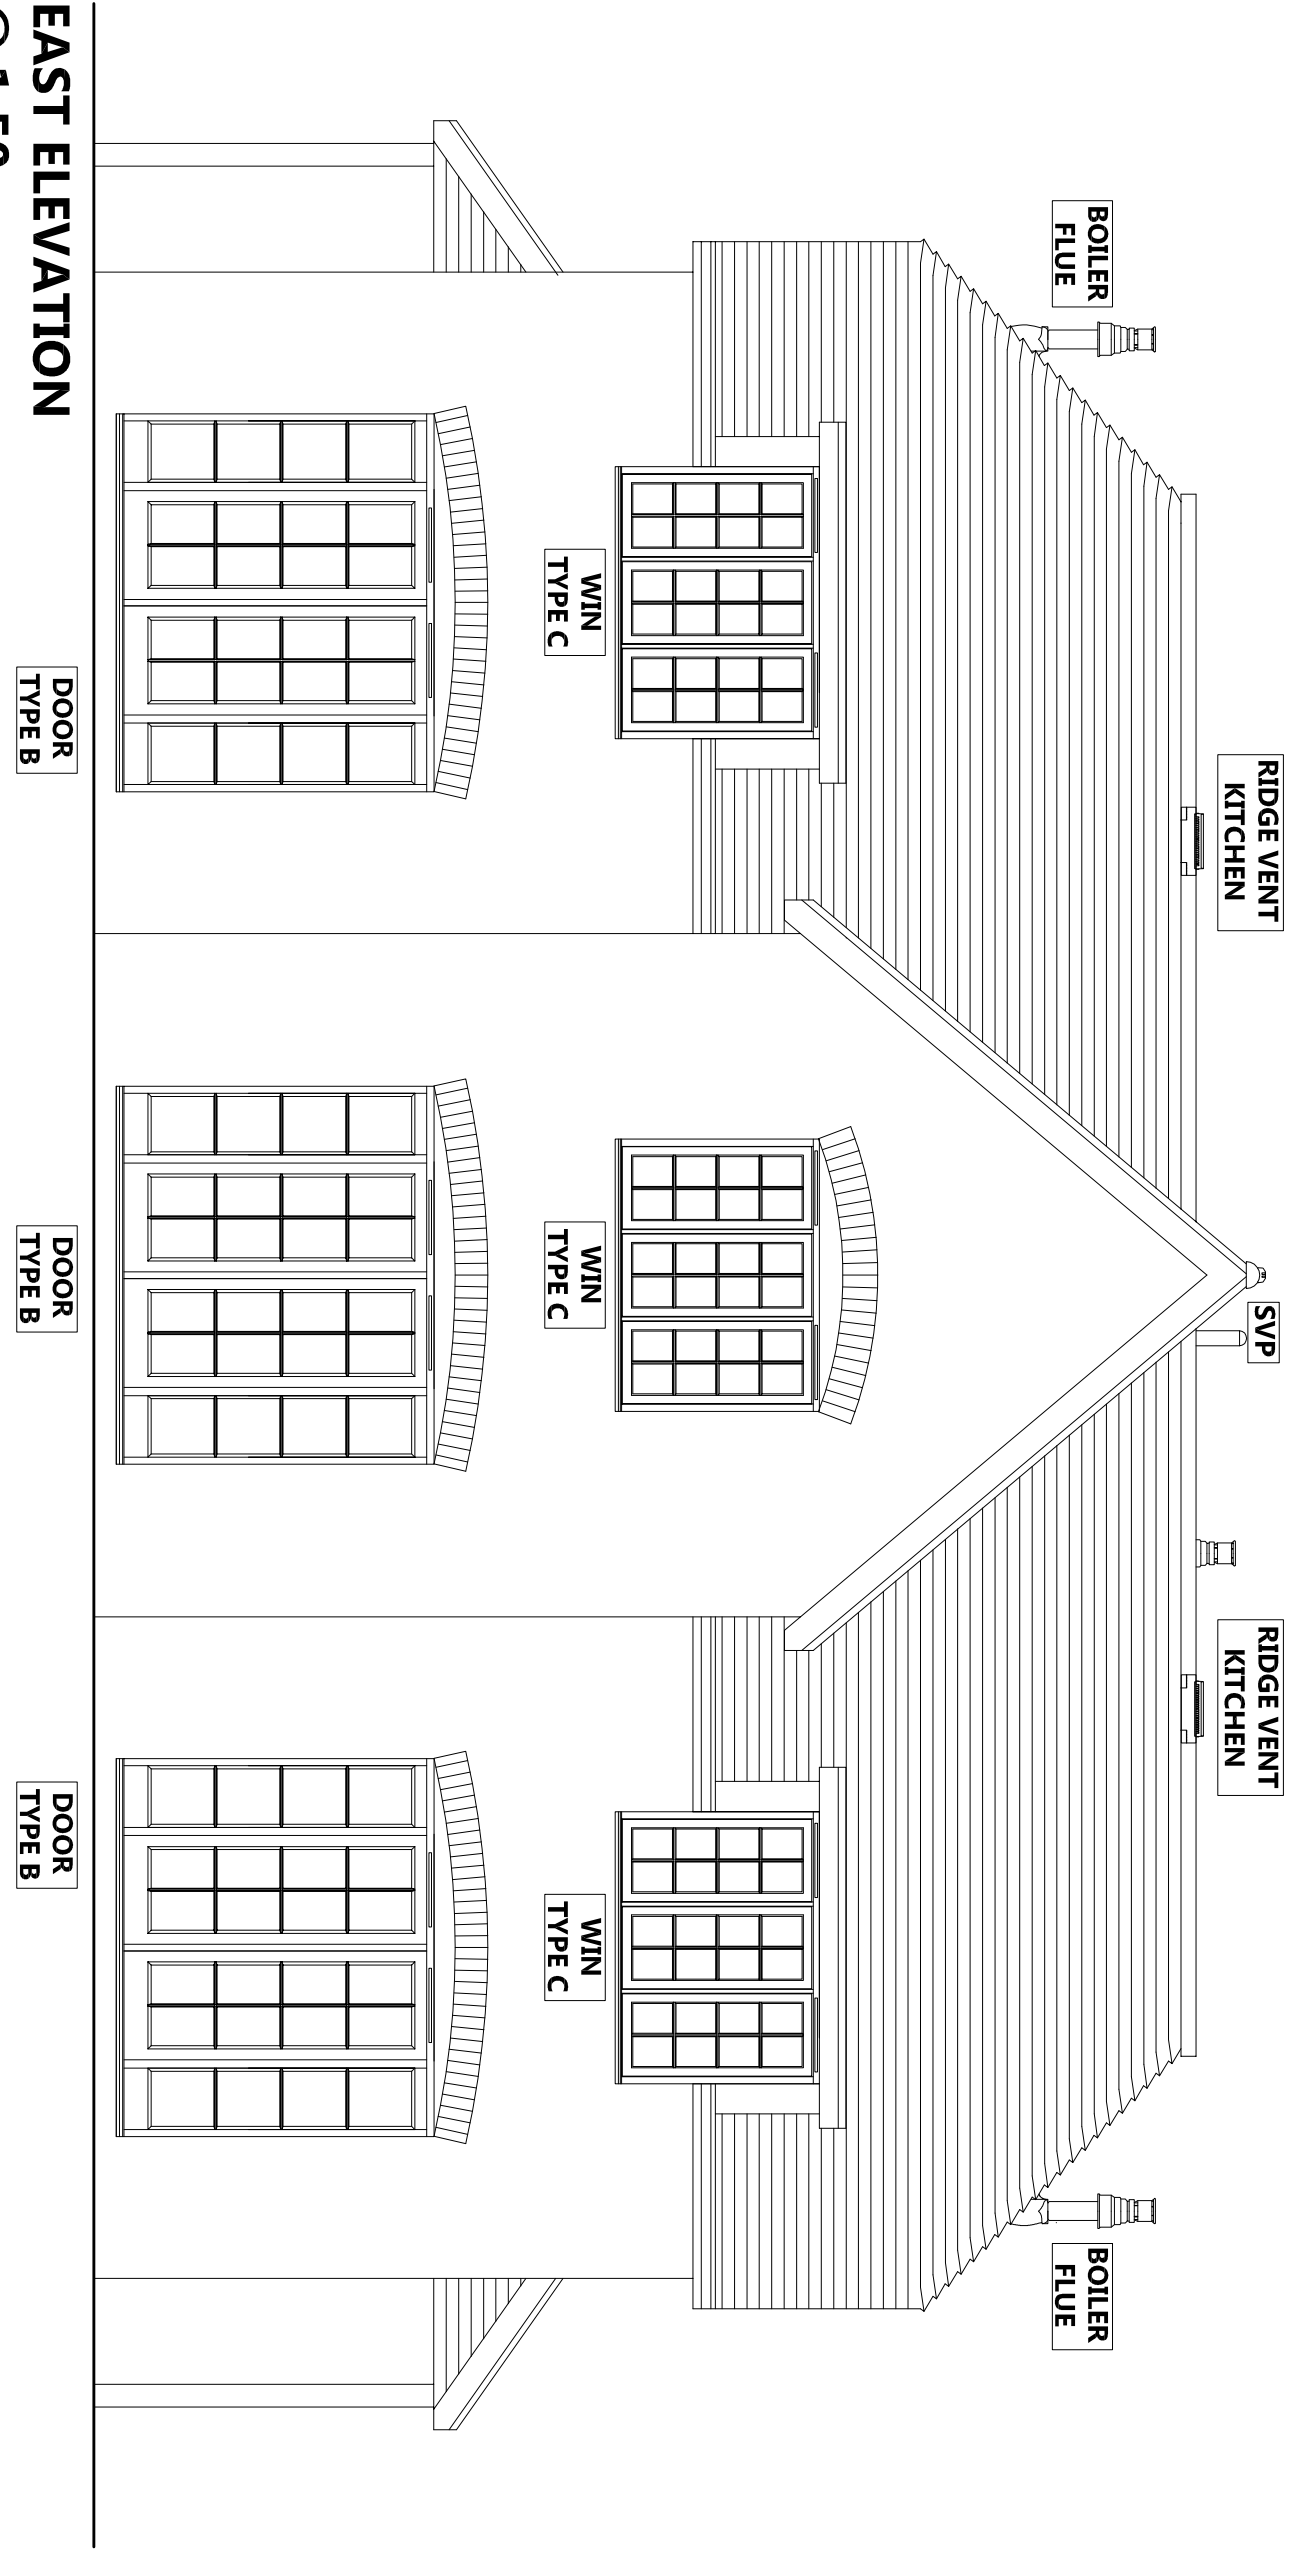

EAST ELEVATION
@ 1:50

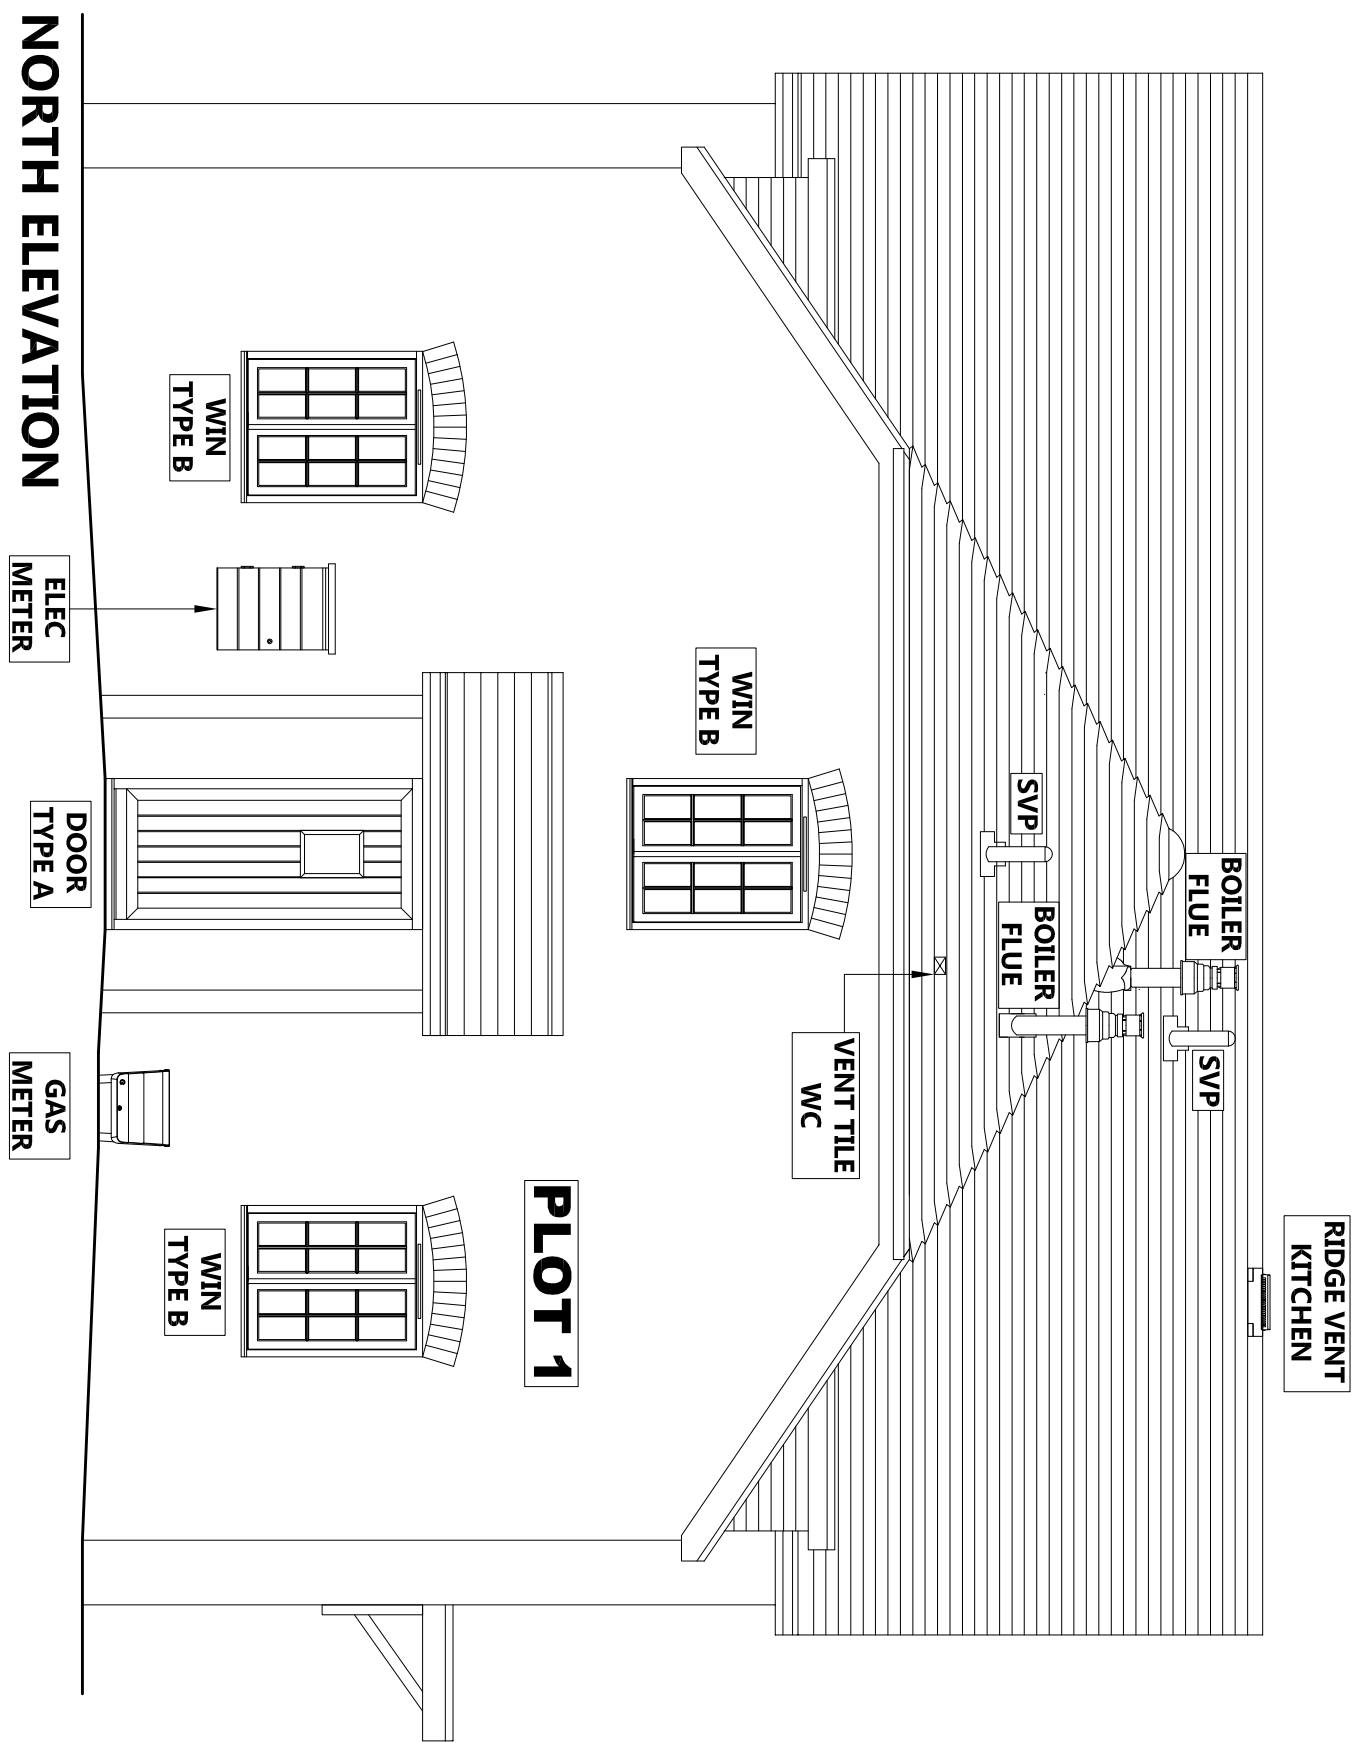

NORTH ELEVATION
@ 1:50

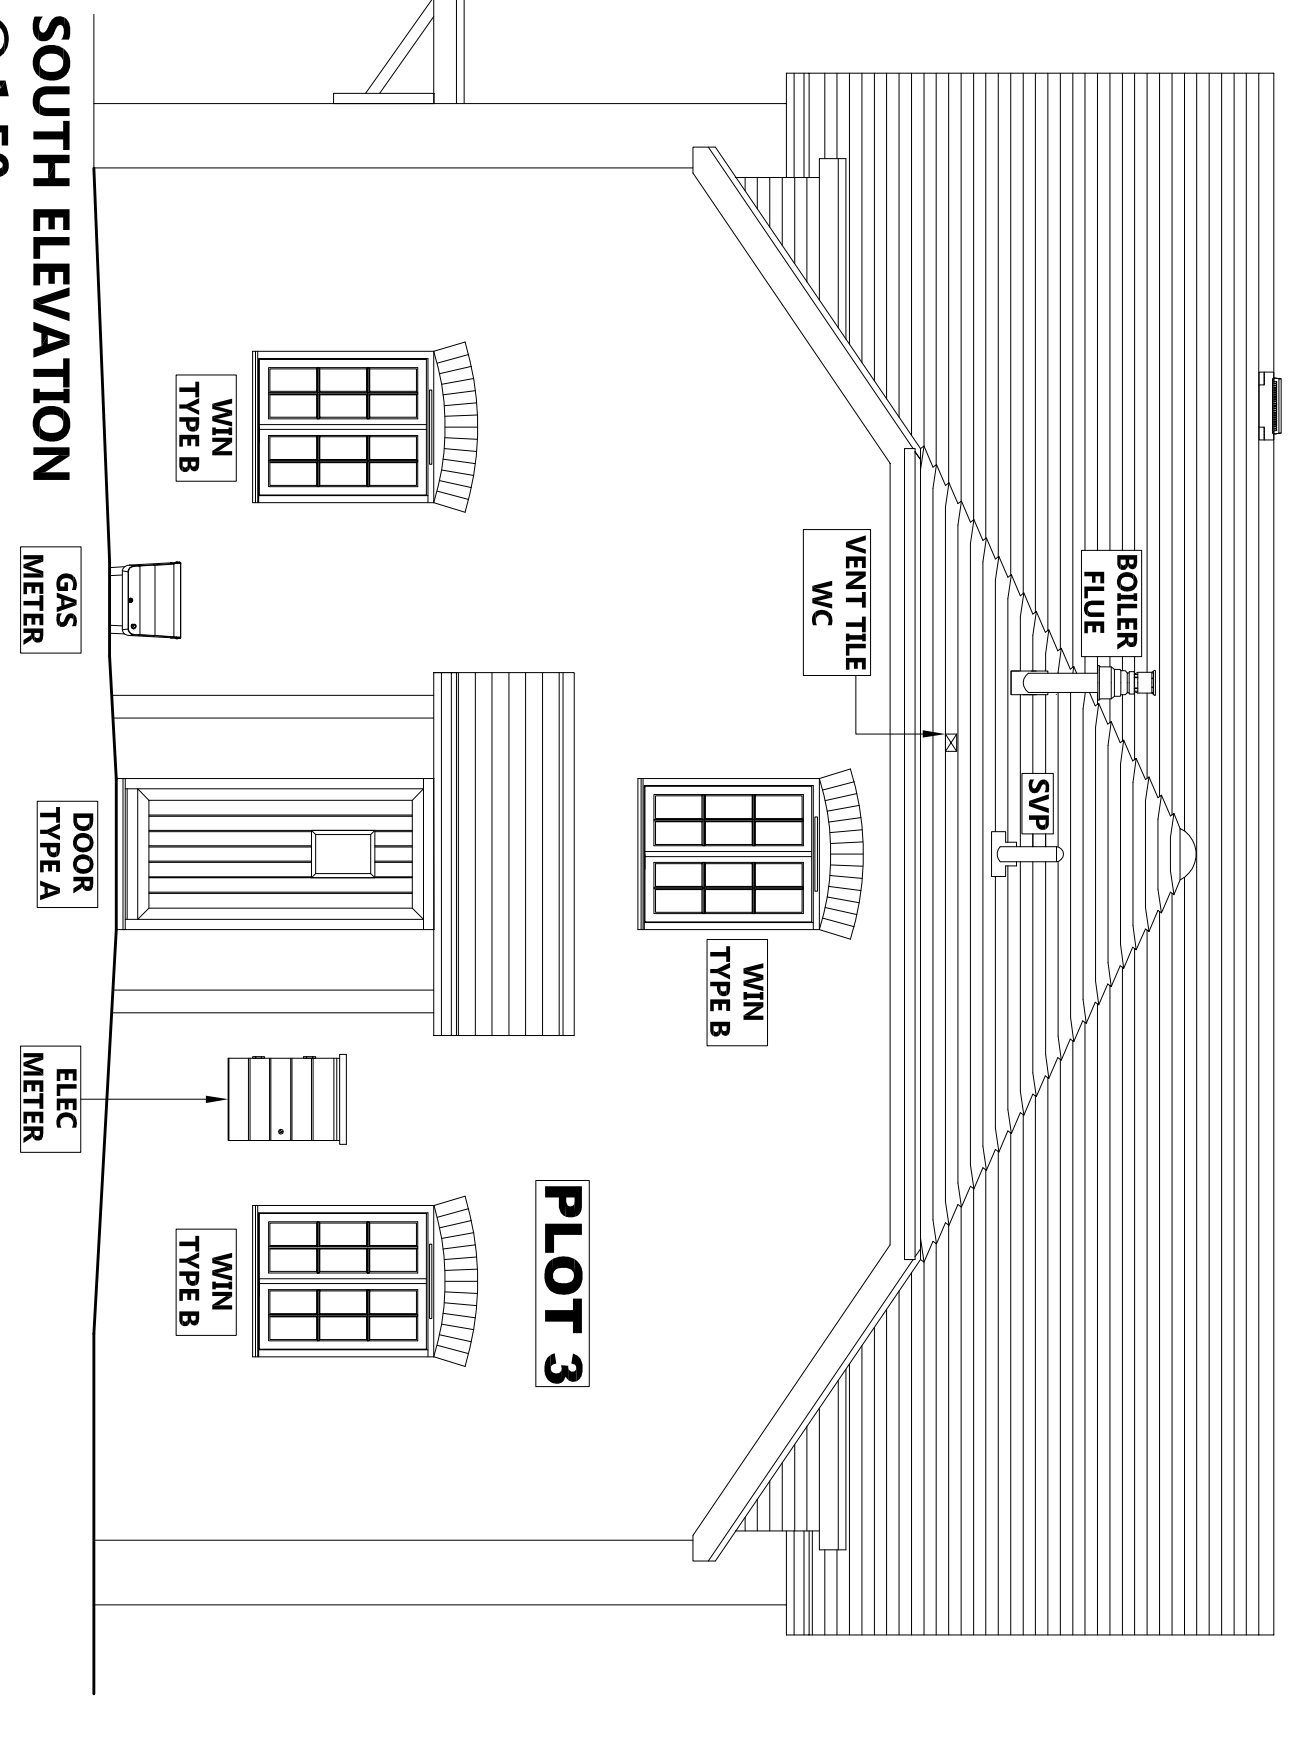

SOUTH ELEVATION
@ 1:50



PLAN SHOWING METER POSITIONS @ 1:100

THIS DRAWING IS TO BE READ IN CONJUNCTION
WITH THE FOLLOWING DRAWINGS:

WINDOWS

GRAHAM ASH ARCHITECTS DRAWING NO. 13.087.31 - WINDOW TYPE A
GRAHAM ASH ARCHITECTS DRAWING NO. 13.087.32 - WINDOW TYPE B
GRAHAM ASH ARCHITECTS DRAWING NO. 13.087.33 - WINDOW TYPE C

DOORS

GRAHAM ASH ARCHITECTS DRAWING NO. 13.087.34 - DOOR TYPE A
GRAHAM ASH ARCHITECTS DRAWING NO. 13.087.35 - DOOR TYPE B

FLUES AND ROOF VENTS

GRAHAM ASH ARCHITECTS DRAWING NO. 13.087.36
- SVP TERMINATION DETAIL
- TILE VENTILATION DETAIL
- RIDGE VENTILATION DETAIL
- BOILER FLUE TERMINATION DETAIL

METER BOXES

GRAHAM ASH ARCHITECTS DRAWING NO. 13.087.37
- GAS AND ELECTRIC METER BOX DETAILS



**GRAHAM ASH
ARCHITECTS**

CHARTERED ARCHITECTS' TOWN PLANNING CONSULTANTS
STATIONERS FORD, EASTLEIGH, HAMPSHIRE SO3 3BH
TELEPHONE 07788 452105
FAX 07788 452106
WEBSITE: www.grahamasharchitects.com

PROJECT:
3 New Houses
At Newtown House Hotel
Hayling Island, PO11 0QR

TITLE: Location of Meter Boxes , Flues, Vents & SVPs			
DESIGNED BY GA	DATE 18-02-21	DRAWN / DTMAD BY JAT	
SCALE 1:50	PLOTTED 18-02-21	REV.	
A1 0 @ 1:50 3m			
☒ Information ☐ Approval ☐ Audit ☐ Construction			
DWG. NO. 13.087.30			