


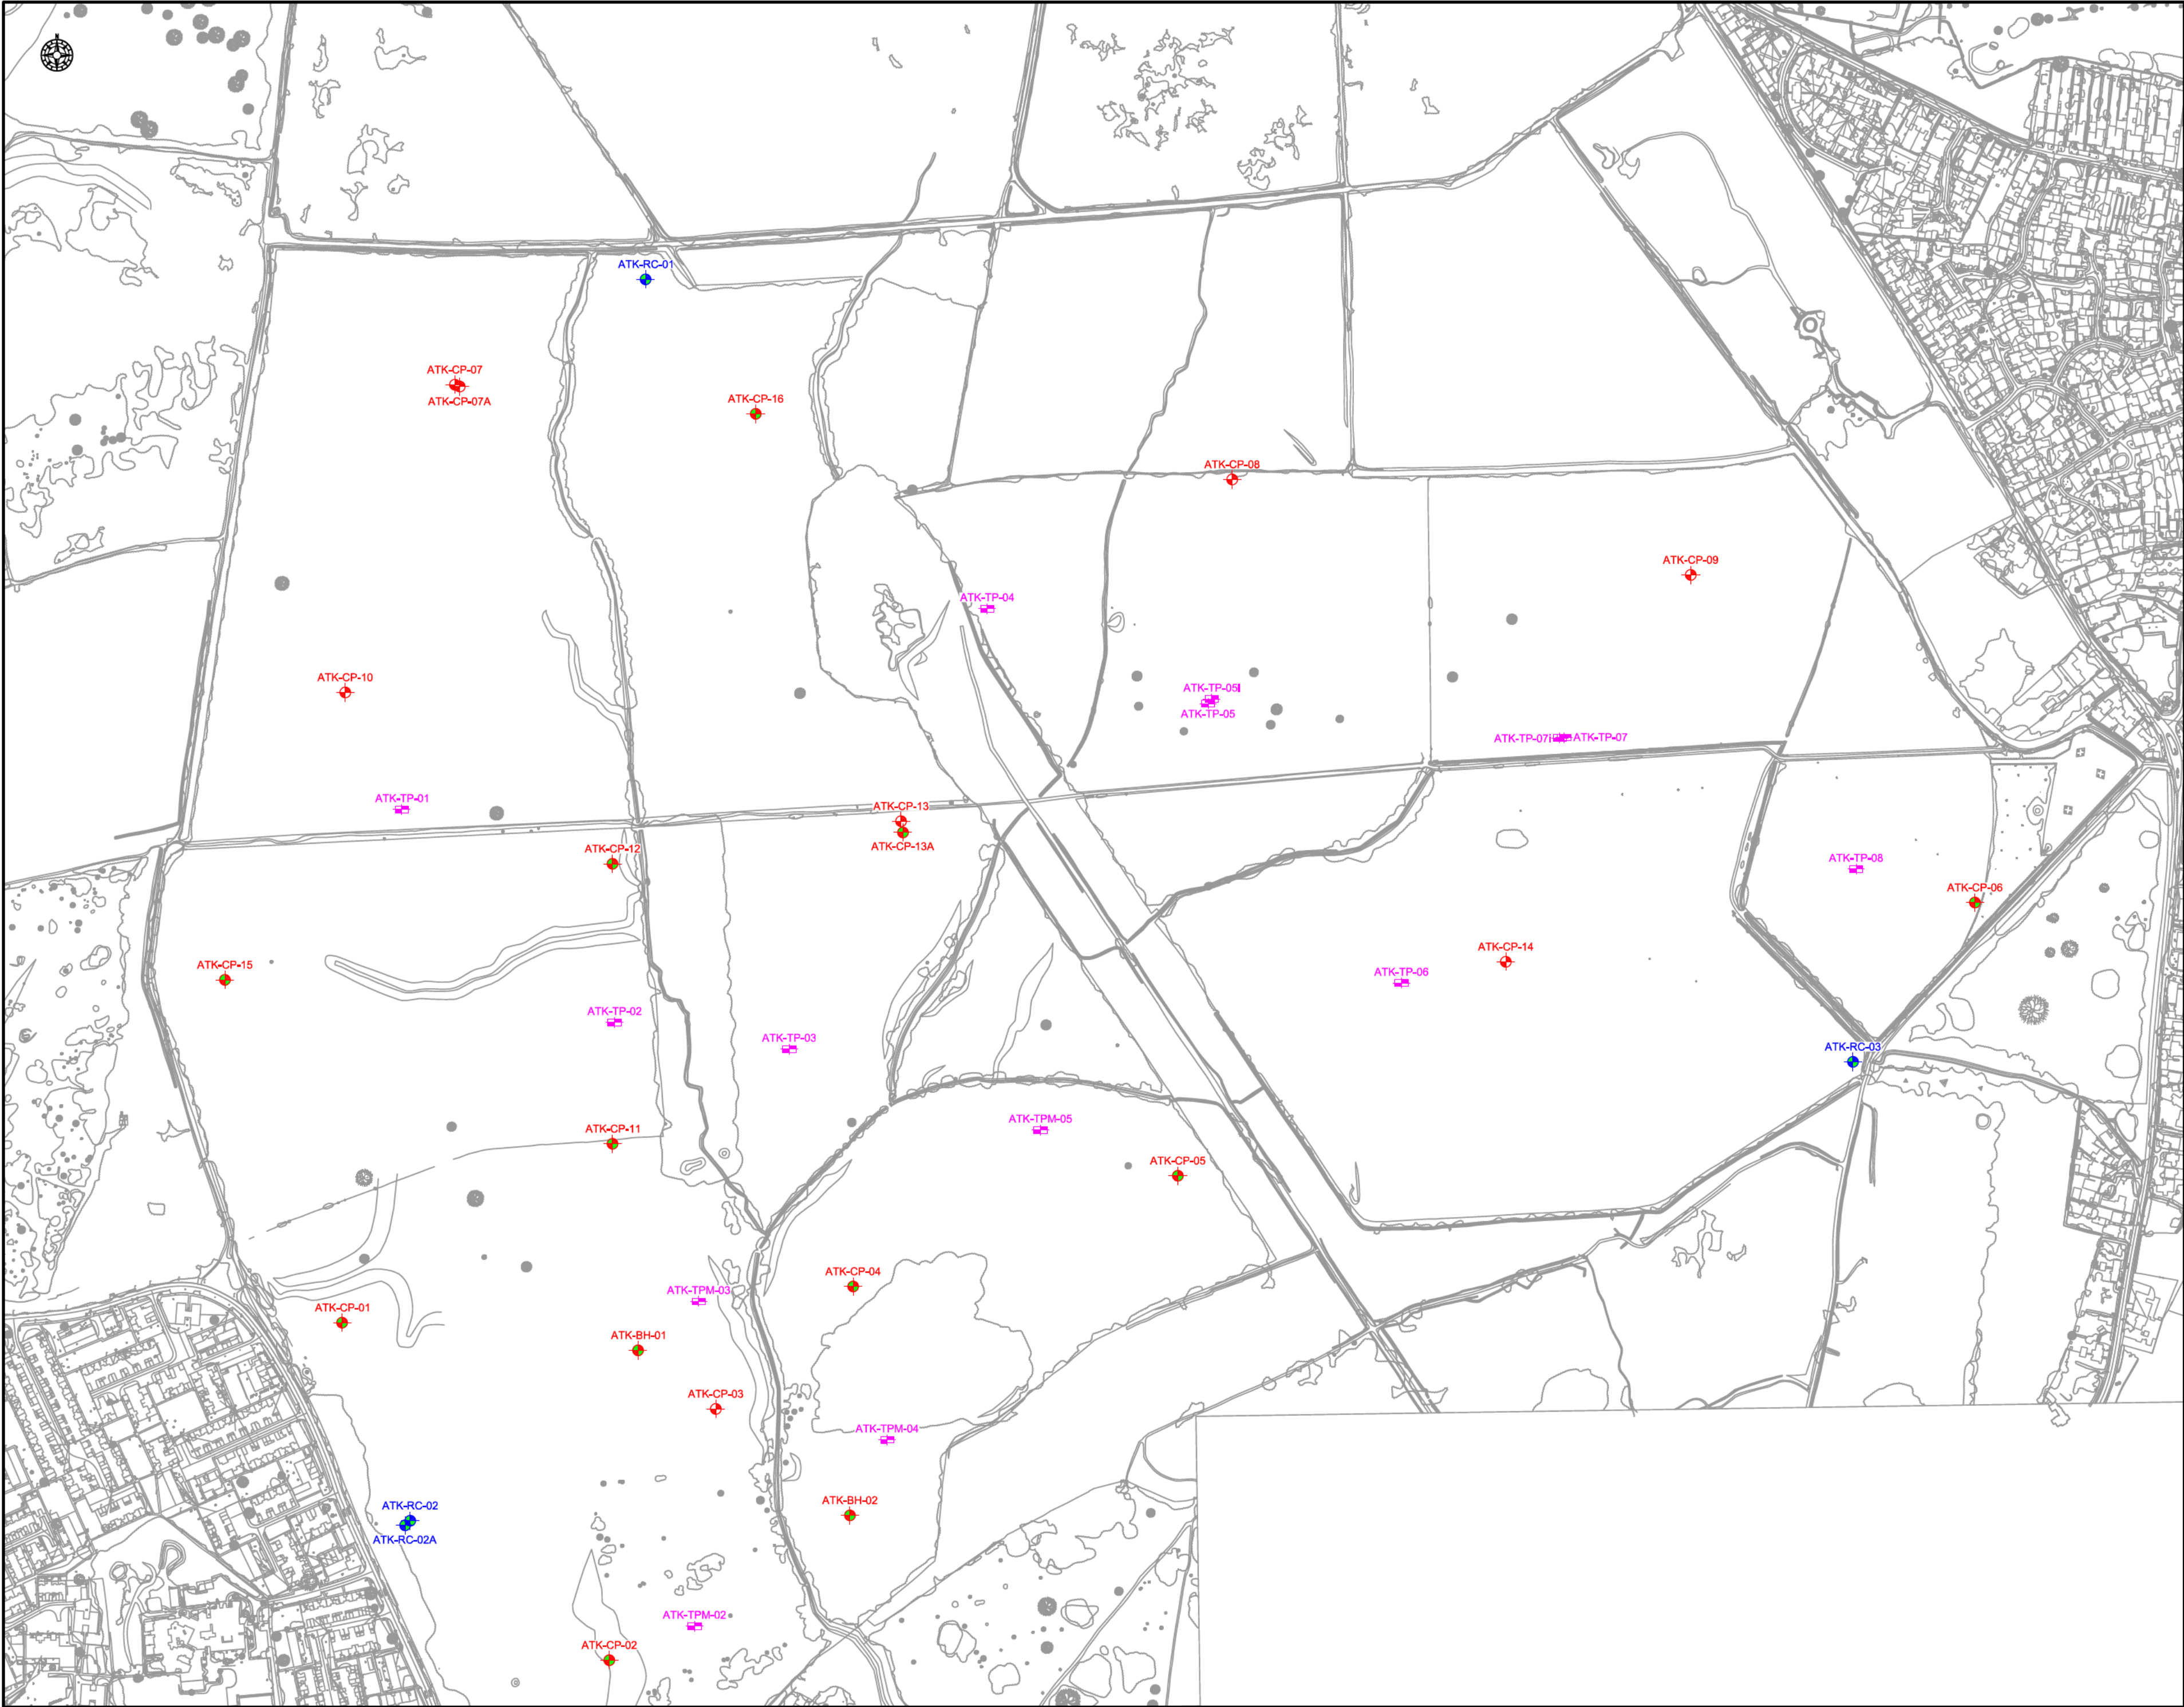

GENERAL NOTES

1. Reproduced from Portsmouth Water's Drawing

2. Hole Locations to National Grid Co-ordinate Reference System

3. Plan produced by permission of Ordnance Survey on behalf of The Controller of Her Majesty's Stationery Office, © Crown copyright, SOCOTEC UK Limited. All rights reserved. Licence Number 100006060

LEGEND TO SYMBOLS

Borehole (CP)

Borehole (CP with Installation)

Borehole (RC with Installation)

Trial Pit

Scale: 1:2000

0

20m

40

80

120

160

200

Rev	Drawn	Date	Apprv	Date	Modification Details
1	APV	3/4/2020	TC	3/4/2020	Position with Installation marked

AMENDMENTS

Title

SITE PLAN

Project

HAVANT THICKET
WINTER STORAGE
RESERVOIR

Client

PORTSMOUTH WATER

SOCOTEC

Date	Drawn By	Apprv By
13/03/2020	BS	PC
Sheet Size	Scale	Project No
A0	1:2000	A9031-19
Drawing No	Rev	
A2	1	