



Wilson Contract
Services Ltd

tel: 01924 256826
wilsoncontracts.co.uk

PAGE 1 OF 6

ASDA

EXTERNAL SIGNAGE

Petrol filling station canopy

21st May 2020 (Rev A)



NEW PFS CONCEPT
HAVANT
LARCHWOOD AVENUE
BEDHAMPTON
HAVANT
PO9 3QW

21/05/20 - SRL
Rev A




Wilson Contract
Services Ltd
tel: 01924 256826
wilsoncontracts.co.uk

DAY



NIGHT **Max 250 Candelas per square meter (cd/m²)**

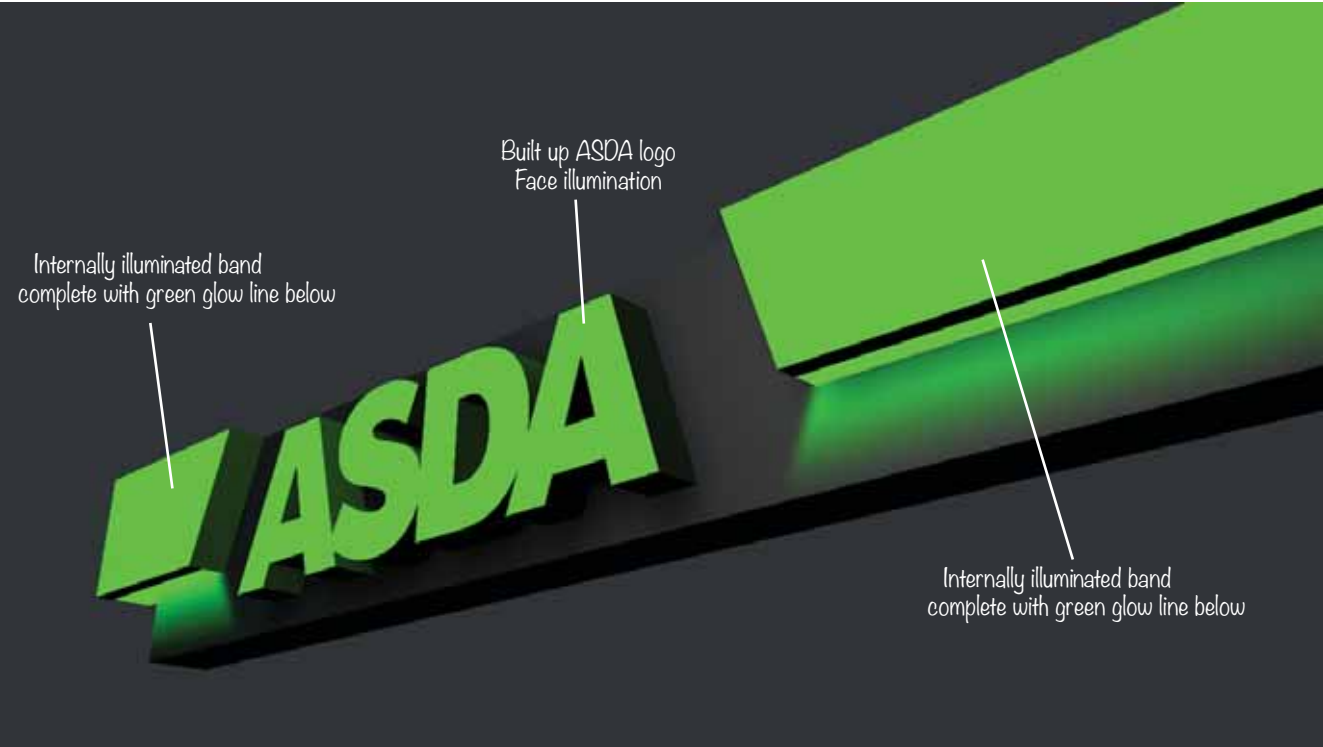

ASDA

NEW PFS CONCEPT
HAVANT
LARCHWOOD AVENUE
BEDHAMPTON
HAVANT
PO9 3QW

Site Plan



Wilson Contract
Services Ltd
tel: 01924 256826
wilsoncontracts.co.uk



NEW PFS CONCEPT
HAVANT
LARCHWOOD AVENUE
BEDHAMPTON
HAVANT
PO9 3QW







21/05/20 - SRL
Rev A

Proposed Canopy Signage (Elevation 04 to be non illuminated)



Wilson Contract Services Ltd

tel: 01924 256826
wilsoncontracts.co.uk

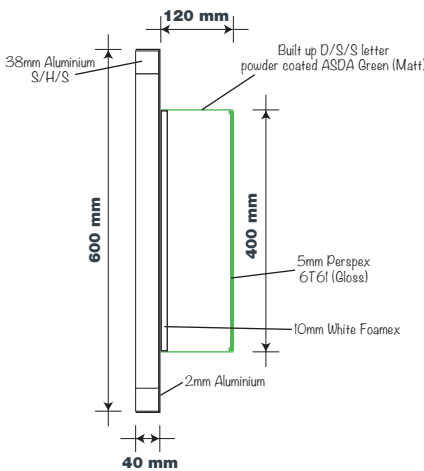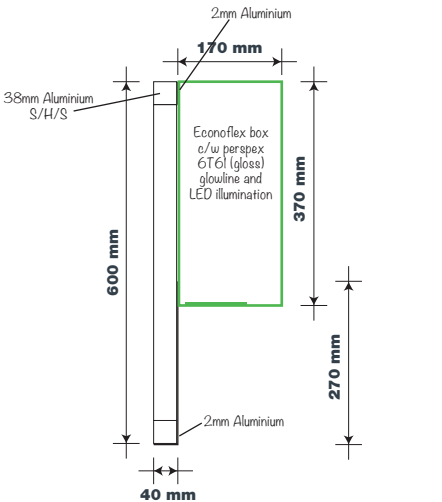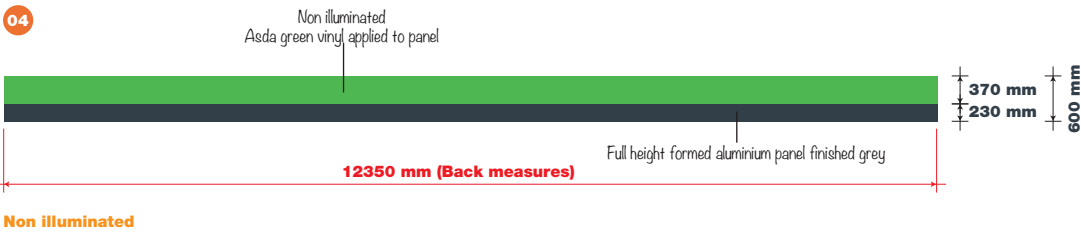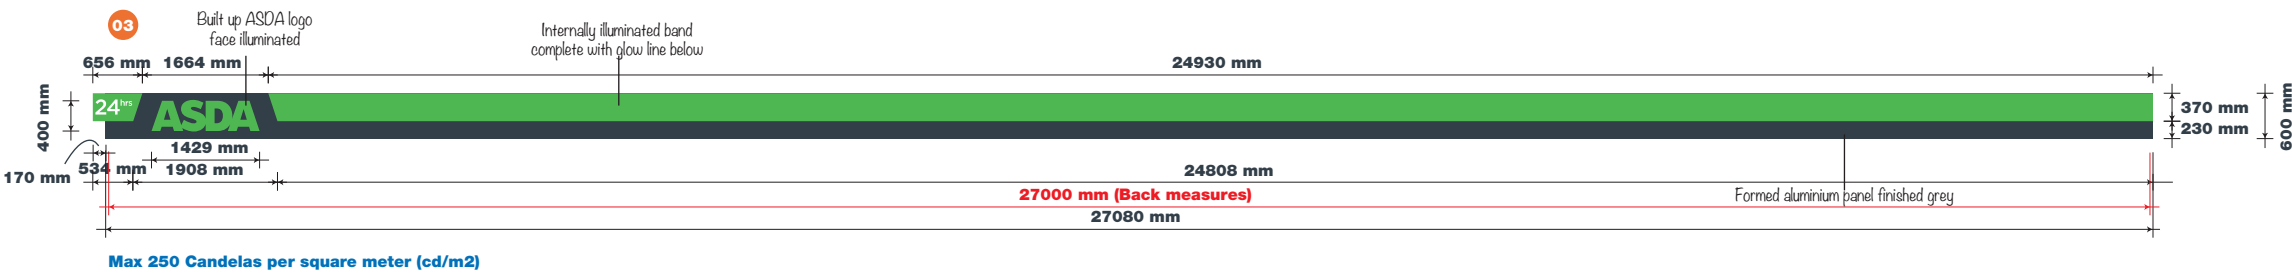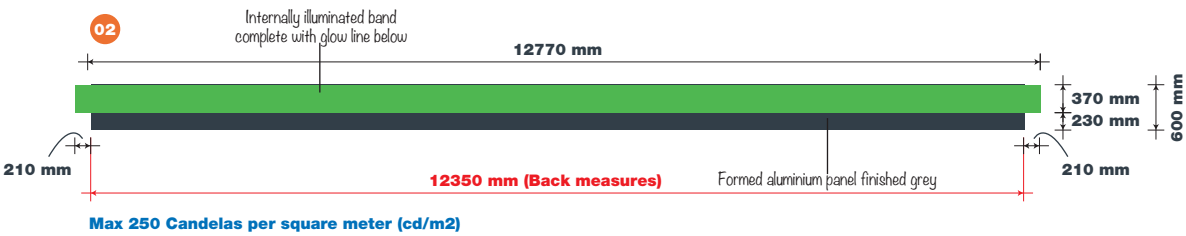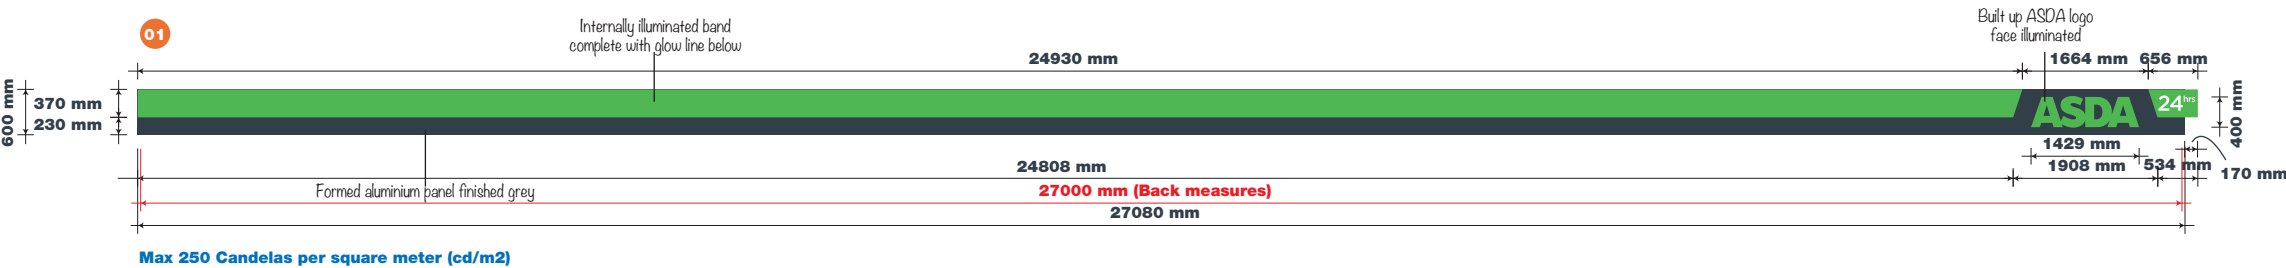



ASDA

NEW PFS CONCEPT
HAVANT
LARCHWOOD AVENUE
BEDHAMPTON
HAVANT
PO9 3QW




21/05/20 - SRL
Rev A



Scale 1:100 @ A3

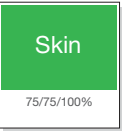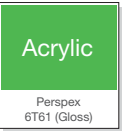

General Arrangement
Typical detail

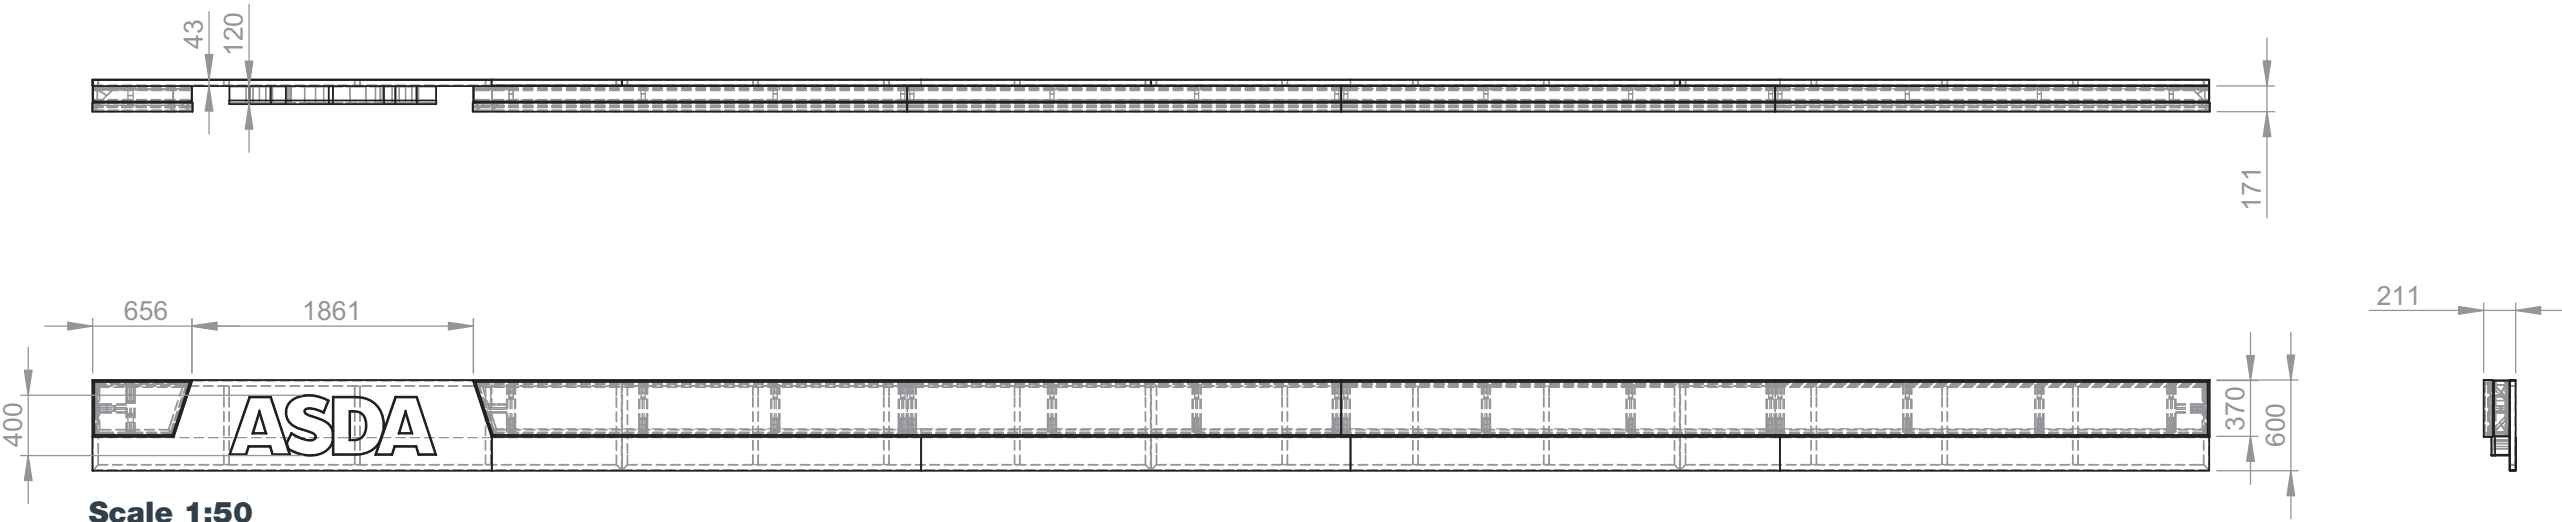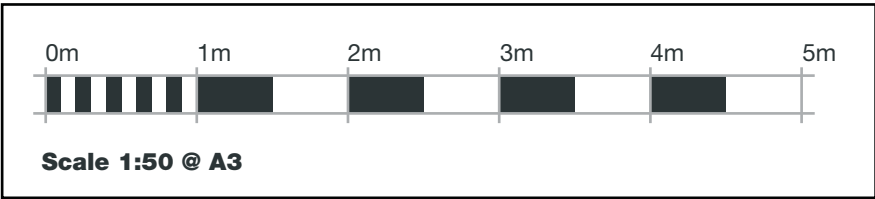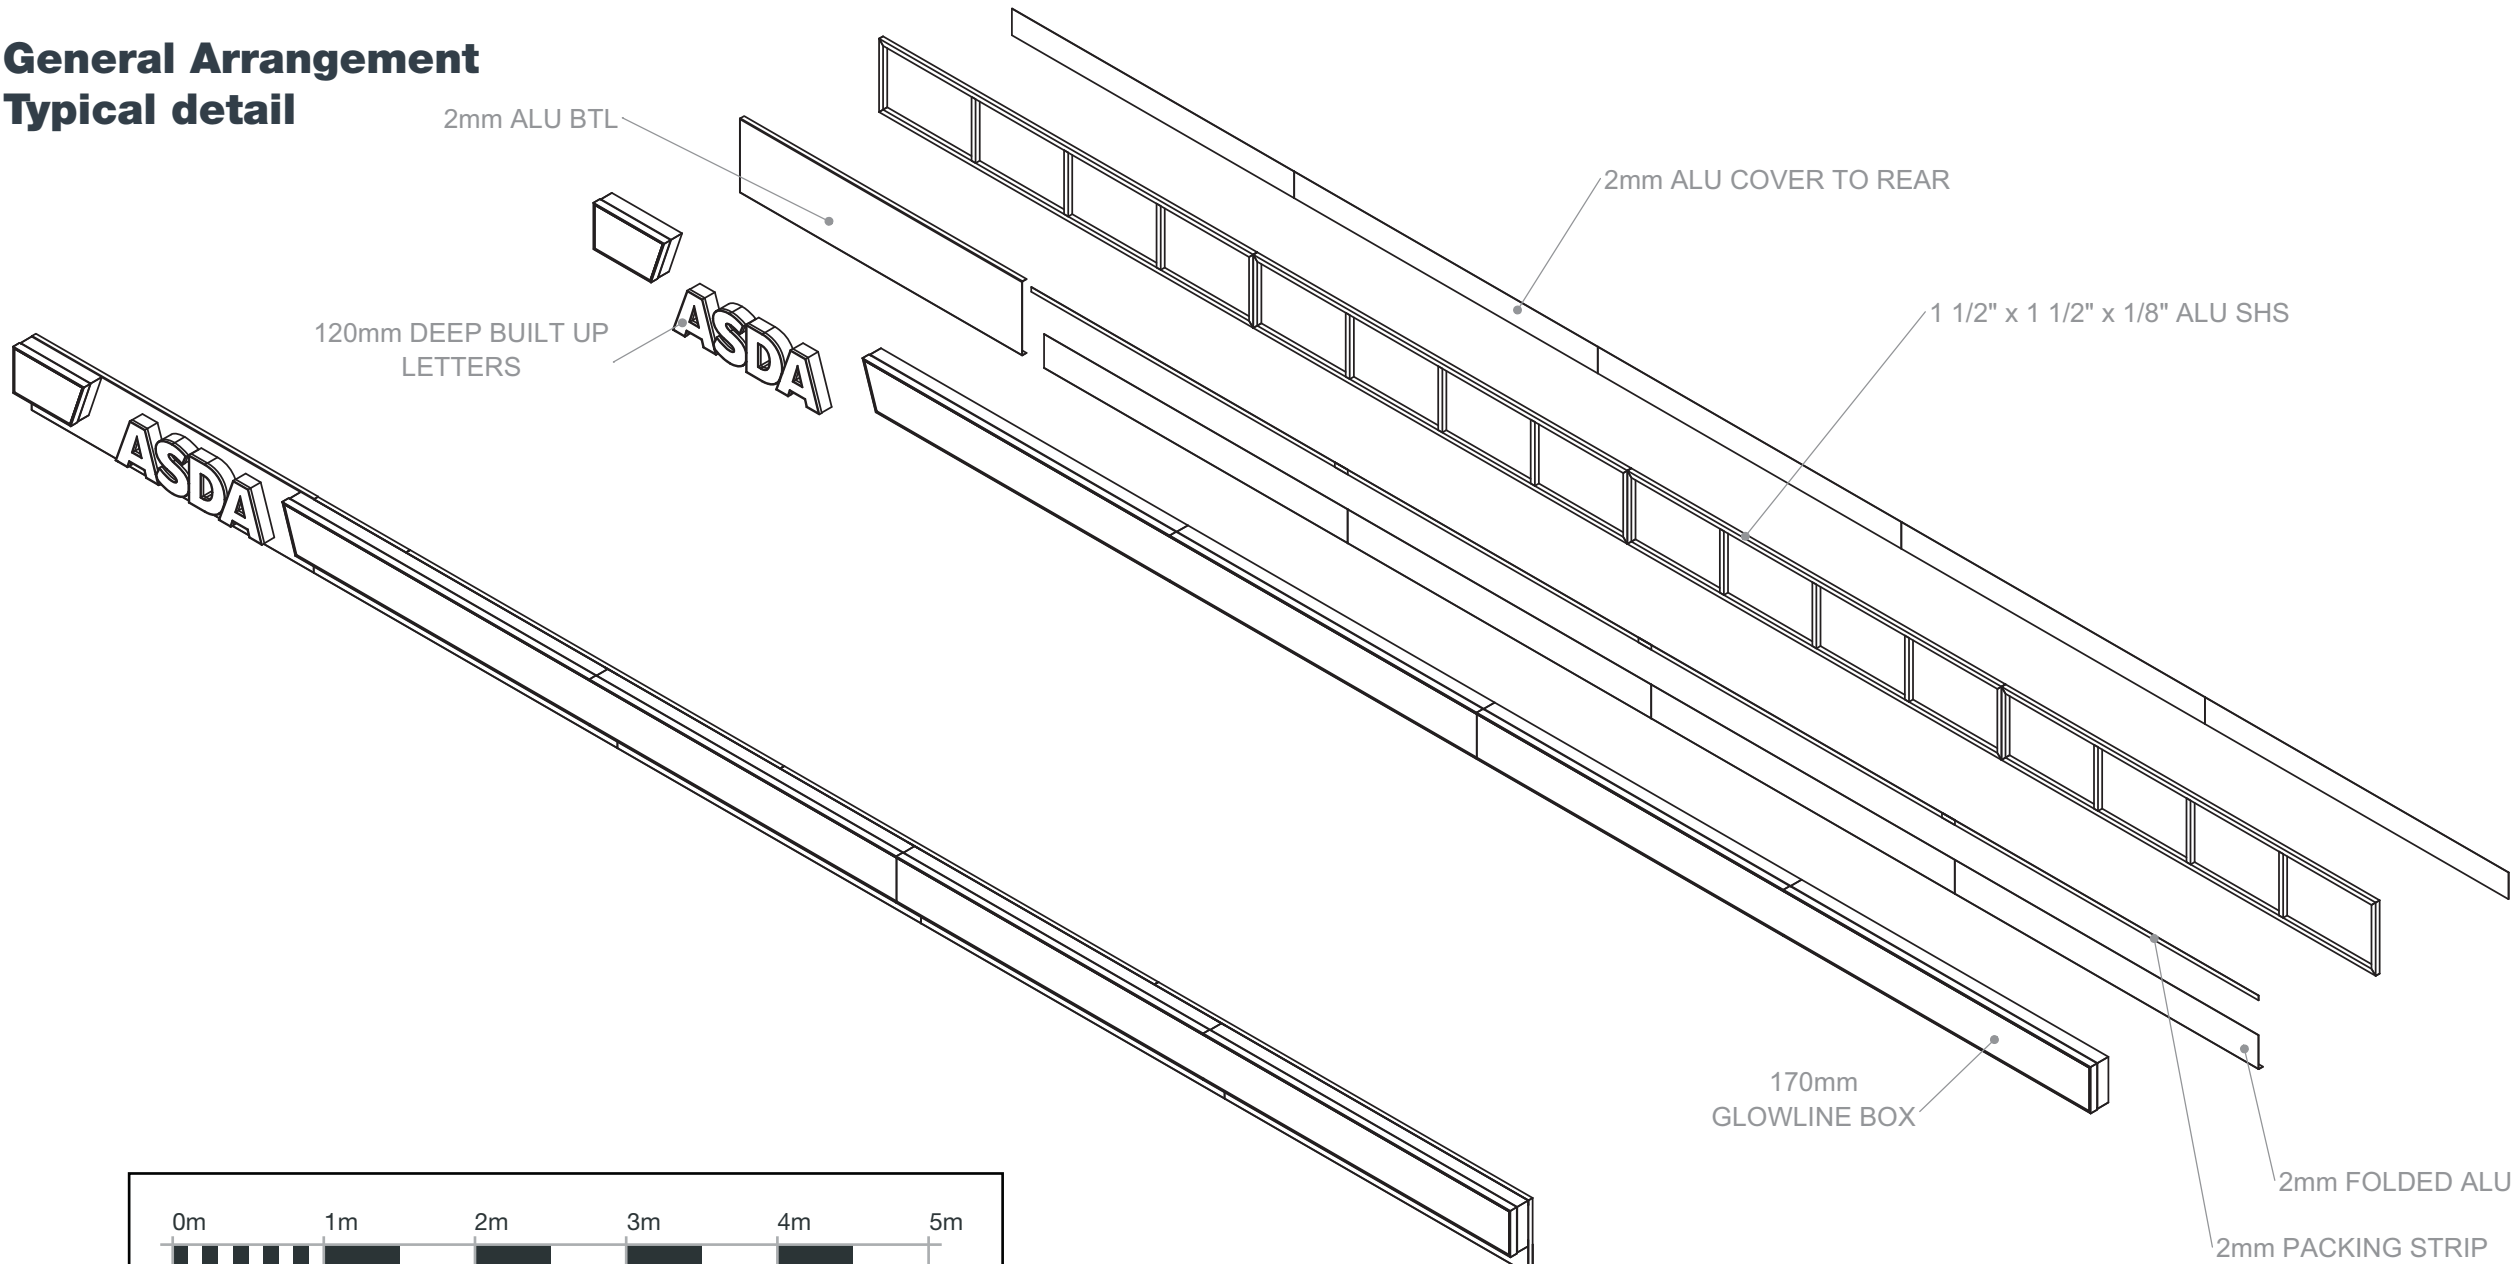

Wilson Contract
Services Ltd
tel: 01924 256826
wilsoncontracts.co.uk



NEW PFS CONCEPT
HAVANT
LARCHWOOD AVENUE
BEDHAMPTON
HAVANT
PO9 3QW

Location Plan



Wilson Contract
Services Ltd
tel: 01924 256826
wilsoncontracts.co.uk



NEW PFS CONCEPT
HAVANT
LARCHWOOD AVENUE
BEDHAMPTON
HAVANT
PO9 3QW