




NOTES

1. EACH DISH WILL HAVE LOCATED BEHIND THEM ASSOCIATED EQUIPMENT INCLUDING (BUT NOT LIMITED TO) AN ODU, A MEDIA CONVERTER AND 3G MODEM.

ANTENNA KEY							
REFERENCE	EXISTING/ PROPOSED	OPERATOR	ANTENNA TYPE	BEARING	HEIGHT TO ϕ	STATUS	COMMENTS
D1	PROPOSED	SSE	VHLP1-13	355°	15m	NEW	SUPPLIED BY OTHERS

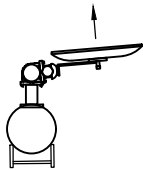


ANTENNA PLAN

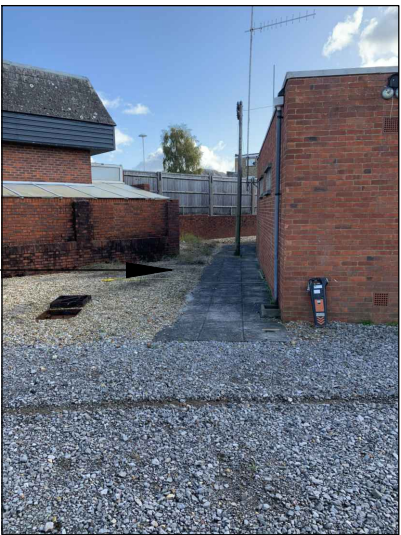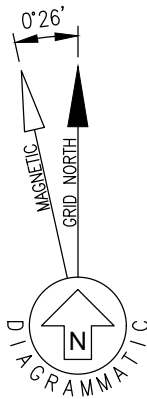

PROPOSED COLUMN
LOCATION

VIEW OF SITE WEST ELEVATION

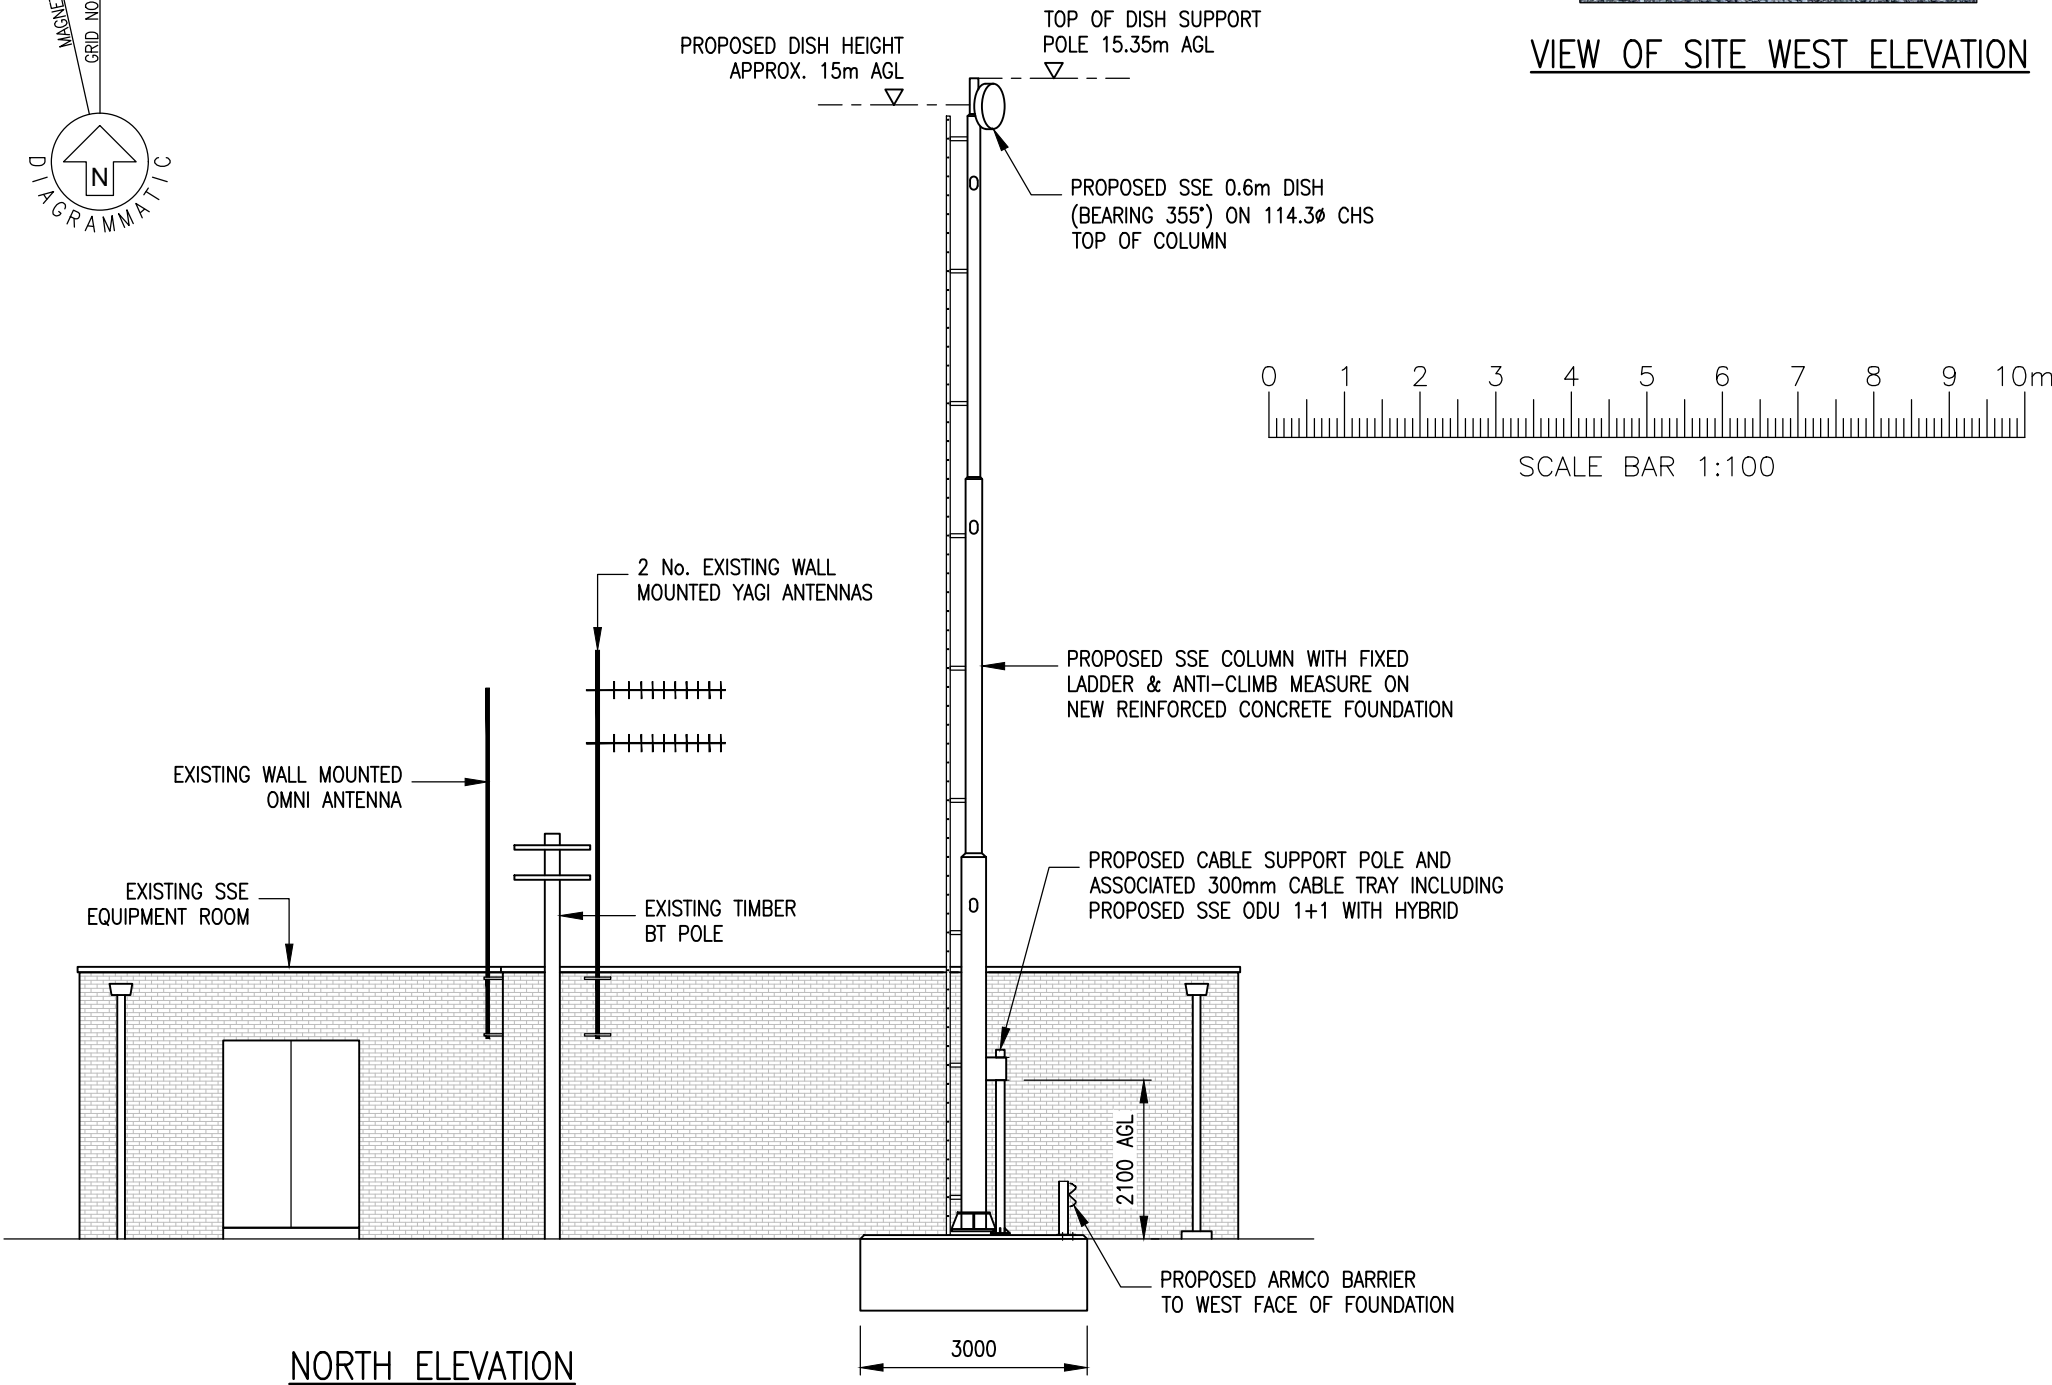

NORTH ELEVATION

REV	DATE	DESCRIPTION	CAD	CHKD
A	11.11.19	ISSUE FOR PLANNING	MDL	PB



MFD Communication Infrastructure Limited
Unit 41 t: 0800 058 8550
Basepoint Business Centre
Andersons Road e: enquiries@mfdci.co.uk
Southampton
SO14 5FE w: www.mfdci.co.uk



PROJECT
WATERLOOVILLE 132kV SUBSTATION
LONDON ROAD
WATERLOOVILLE PO7 7TW

TITLE
PROPOSED ELEVATION

SCALE AT A3 AS SHOWN	DATE 14.10.19
DESIGN/CAD PB/MDL	REVIEWED BY PB
DRAWING NUMBER 1509-P1/GA/203	REV A

PLANNING