


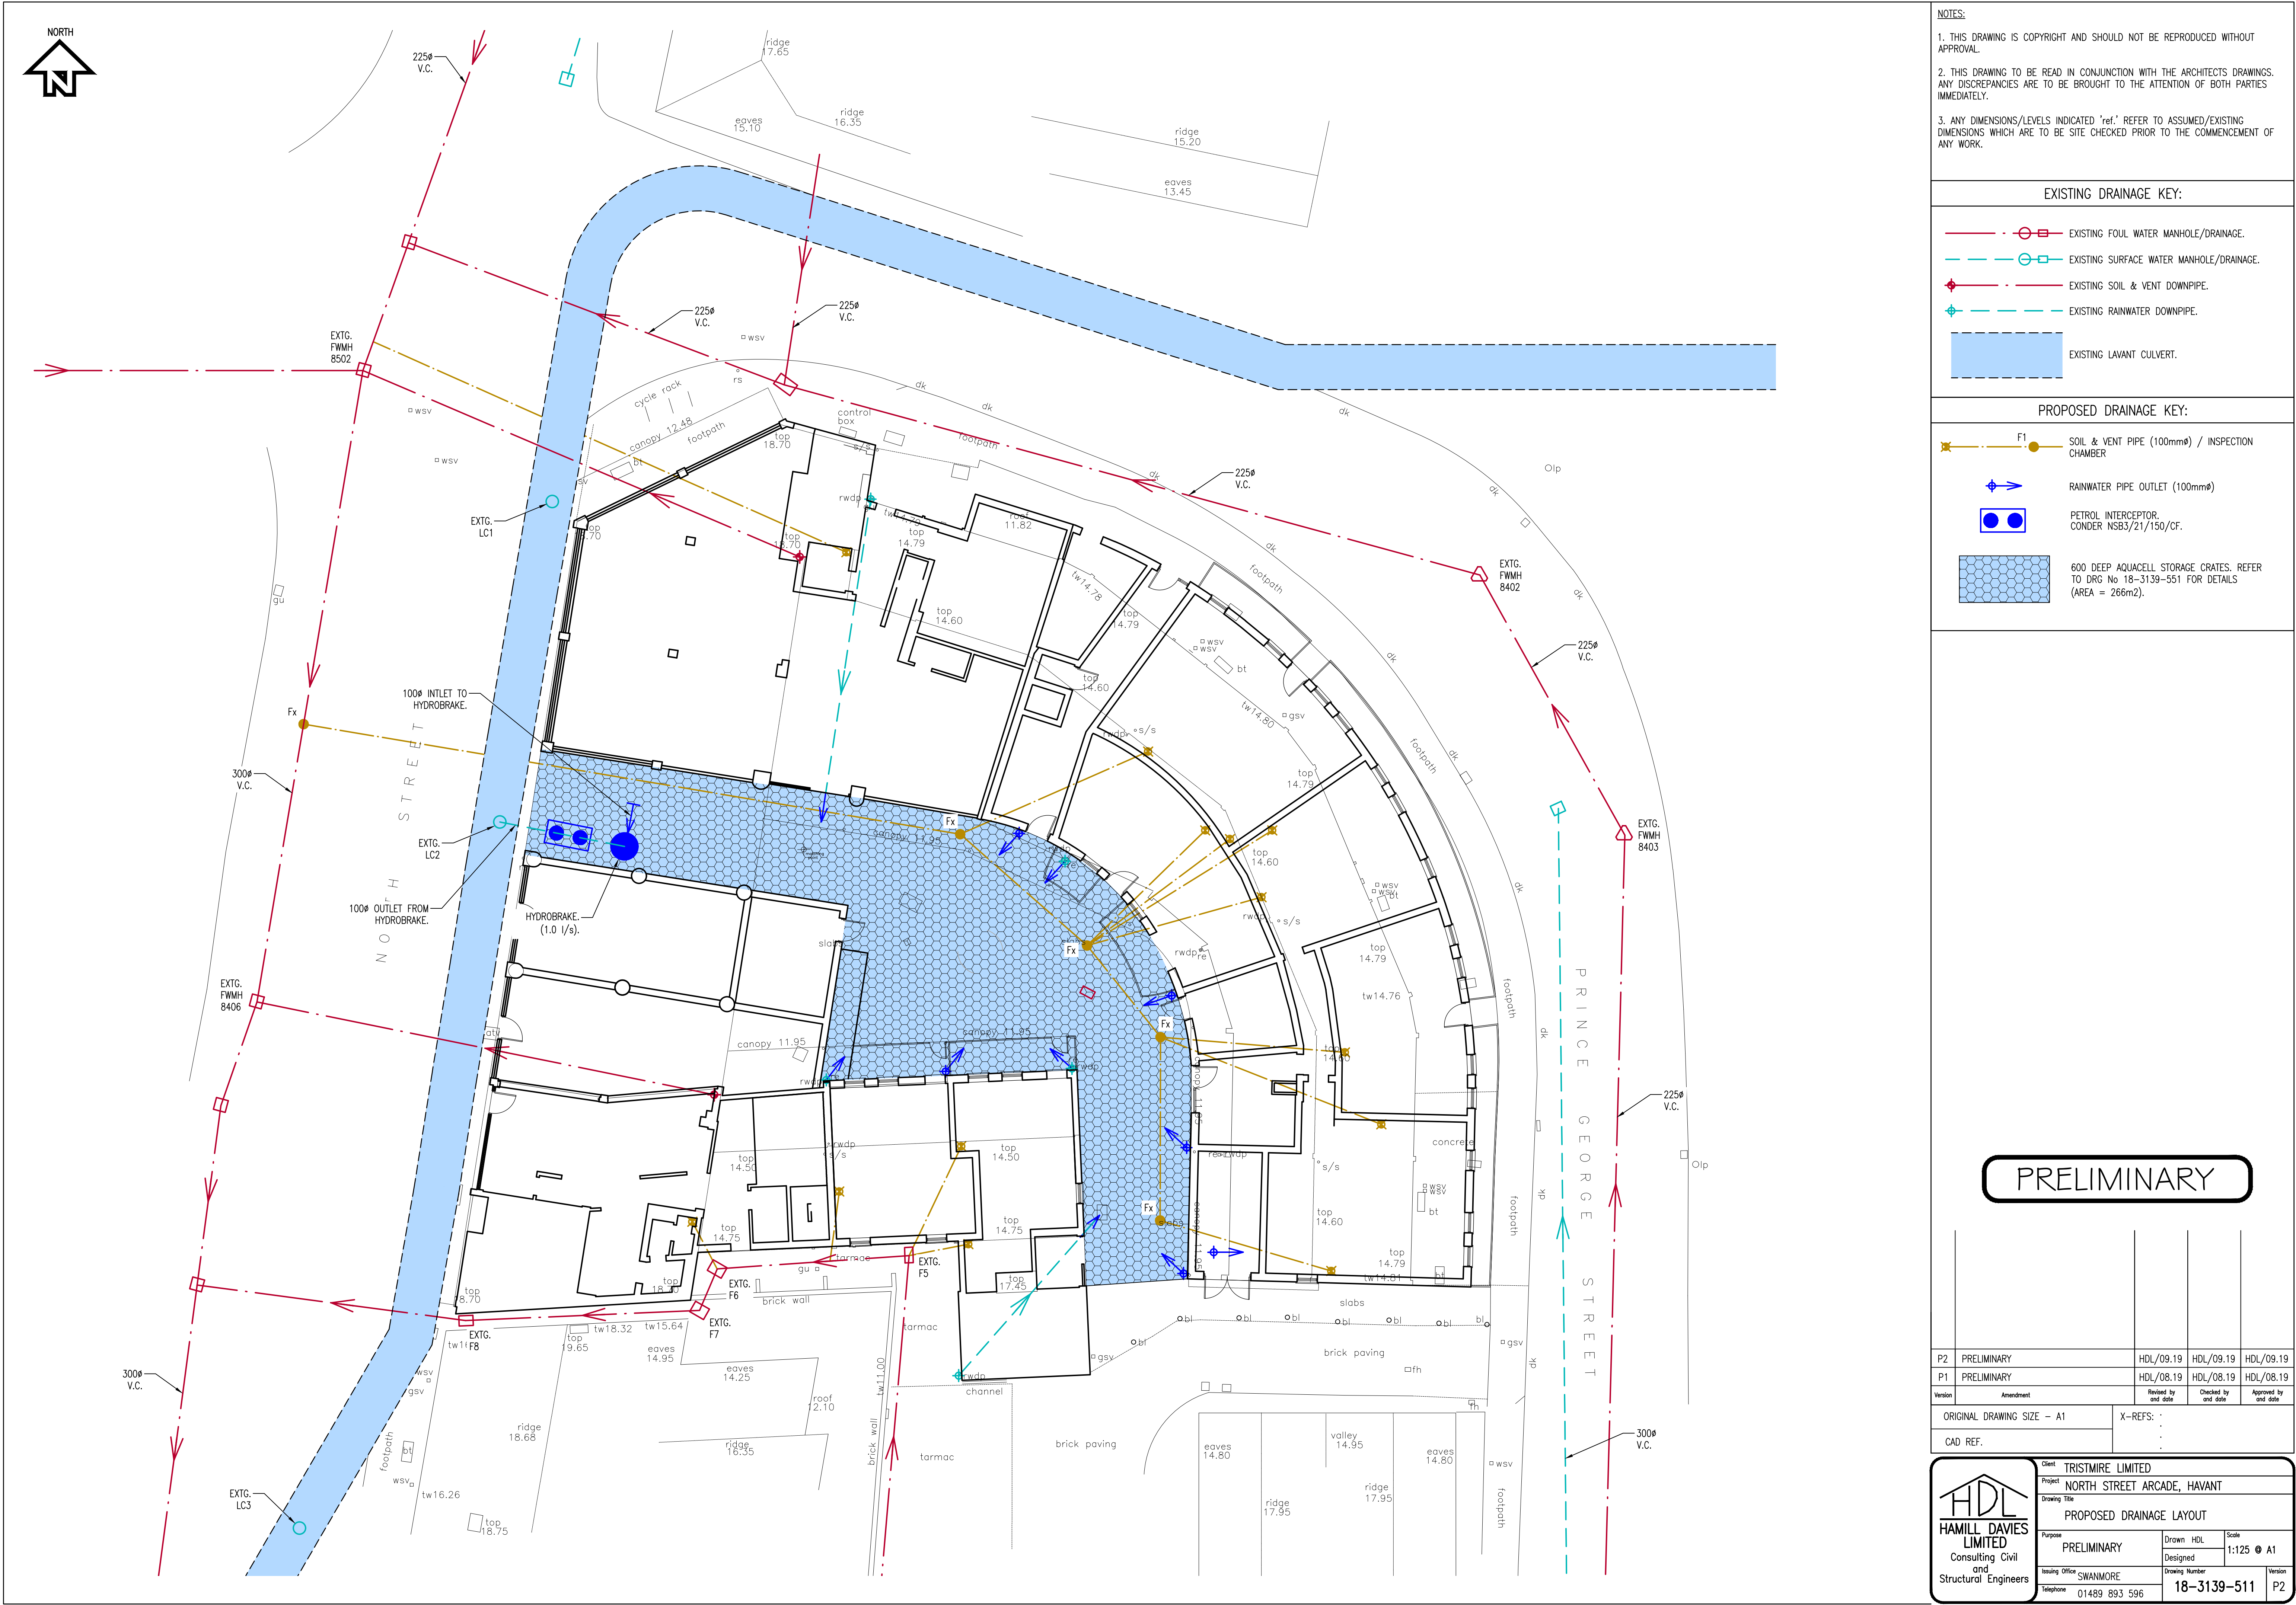

1. THIS DRAWING IS COPYRIGHT AND SHOULD NOT BE REPRODUCED WITHOUT APPROVAL.

2. THIS DRAWING TO BE READ IN CONJUNCTION WITH THE ARCHITECTS DRAWINGS. ANY DISCREPANCIES ARE TO BE BROUGHT TO THE ATTENTION OF BOTH PARTIES IMMEDIATELY.

3. ANY DIMENSIONS/LEVELS INDICATED 'ref.' REFER TO ASSUMED/EXISTING DIMENSIONS WHICH ARE TO BE SITE CHECKED PRIOR TO THE COMMENCEMENT OF ANY WORK.

 EXISTING FOUL WATER MANHOLE/DRAINAGE.
 EXISTING SURFACE WATER MANHOLE/DRAINAGE.
 EXISTING SOIL & VENT DOWNPIPE.
 EXISTING RAINWATER DOWNPIPE.
 EXISTING LAVANT CULVERT.

	SOIL & VENT PIPE (100mmØ) / INSPECTION CHAMBER
	RAINWATER PIPE OUTLET (100mmØ)
	PETROL INTERCEPTOR. CONDR NSB3/21/150/CF.
	600 DEEP AQUACELL STORAGE CRATES. REFER TO DRG NO 18-3139-551 FOR DETAILS (AREA = 266m2).

P2	PRELIMINARY	HDL/09.19	HDL/09.19	HDL/09.19
P1	PRELIMINARY	HDL/08.19	HDL/08.19	HDL/08.19
Version	Amendment	Revised by and date	Checked by and date	Approved by and date
ORIGINAL DRAWING SIZE - A1		X-REFS: : : :		
CAD REF.				

	Client		TRISTMIRE LIMITED	
	Project		NORTH STREET ARCADE, HAVANT	
	Drawing Title		PROPOSED DRAINAGE LAYOUT	
	Purpose	PRELIMINARY	Drawn HDL	Scale 1:125 @ A1
	Issuing Office	SWANMORE	Designed	Version
Telephone	01489 893 596		Drawing Number	18-3139-511
				P2