


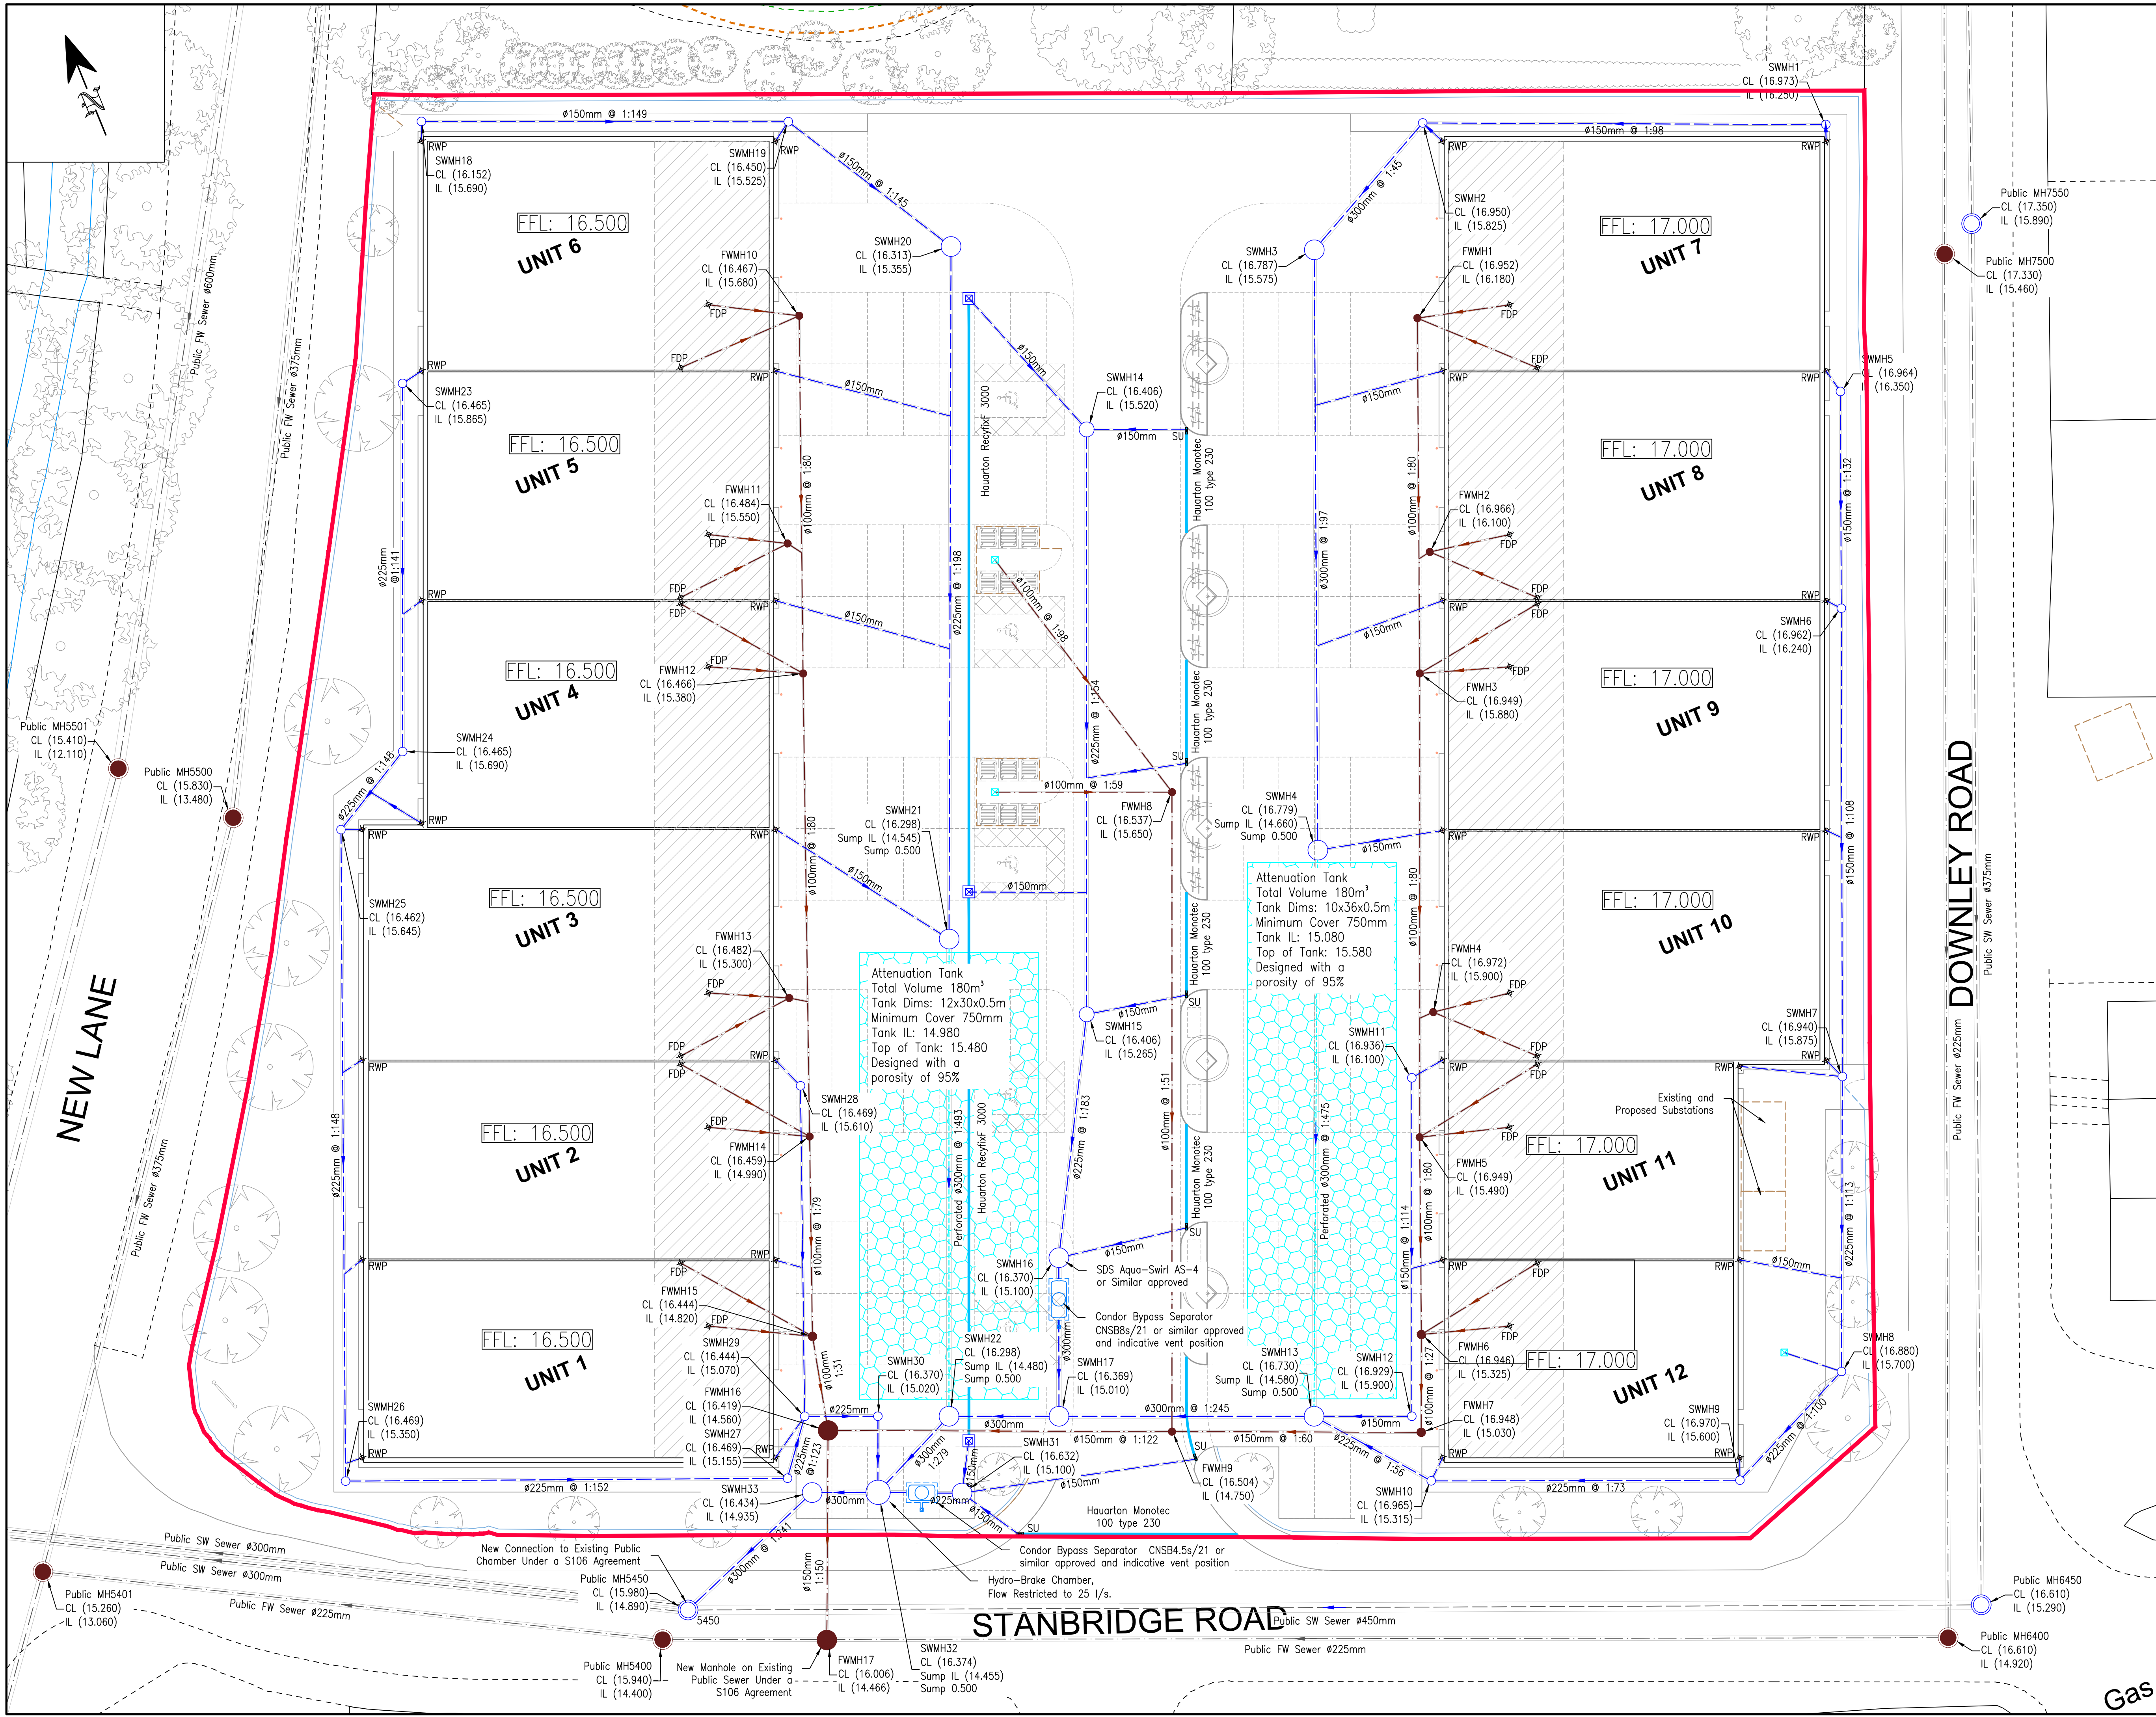

Notes:

- Do not scale from this drawing.
- In case of any discrepancies in drawings, details or bills, refer to engineers for clarification: unilateral decisions by the Contractor will not be accepted.
- This drawing is to be read in conjunction with all related Architects, Consultants & Sub-Contractors drawings and specifications.
- The Contractor is advised that all design drawings and information are to be read concurrently and any discrepancies or omissions reported directly to FTA Civils' Department.
- This drawing is based upon the survey by Shaw Colegate reference 13118_TP_Rev A dated December 2018 provided in digital format.
- All Levels are relative to O.S. Datum
- Existing drainage locations based on Southern Water Asset Plan, O.S. REF SU7207NE, Dated 14.12.19
- Rainwater pipes and Foul Drain Points taken from drawings by HNW architects dated 05.09.19 ref. 18041-HNW-ZZ-ZZ-DR-A-3210 and 3211
- Invert depths for manholes within Stanbridge road provided by Anglo Development Surveys dated 26.09.19.

Key:

- Site Boundary
- Existing Foul Water
- Existing Surface Water
- Proposed Foul Water
- Proposed Surface Water
- Drainage Channel
- Trash Box
- SU Sump Unit
- Attenuation Tank
- RWP Rain Water Pipe
- FDP Foul Drain Point

© Powell Tolner & Associates Ltd.
The contents of this drawing may not be reproduced in whole or in part without the prior written permission of Powell Tolner & Associates.

COMMENT/COSTING/APPROVAL
NOT FOR CONSTRUCTION

REV	DESCRIPTION	BY	DATE	CHKD
P06	Discharge Rate Revised to 25 l/s	TA	24.10.19	SLW
P05	Minor Changes to Drainage Invert Levels, First Defense Specification Changed to SDS Aqua-Swirl	TA	03.10.19	SLW
P04	Updated to RWP and Stack Locations	TA	06.09.19	SLW
P03	Proprietary Systems Added	TA	25.06.19	SLW
P02	Existing Drainage Added, Attenuation Tank Location Adjusted	TA	20.06.19	SLW
P01	First Issue	TA	10.06.19	SLW

PROJECT TITLE
Spring Business Park, Havant

DRAWING TITLE
Proposed Drainage Layout

DATE	June 19	FTA PROJ No	9641
DRAWN	TA	This drawing is issued only for the purposes described in the drawing status box.	REVISION
SCALE	1:200		P06
DWG SIZE	A1		
DRAWING No	9641-PTA-ZZ-XX-DR-C-8101		

Consulting Civil & Structural Engineers
29 Red Lion Street
Chesham Bucks.
HP5 1EJ
Tel. 01494 772721
www.ptaconsult.co.uk

Gas