




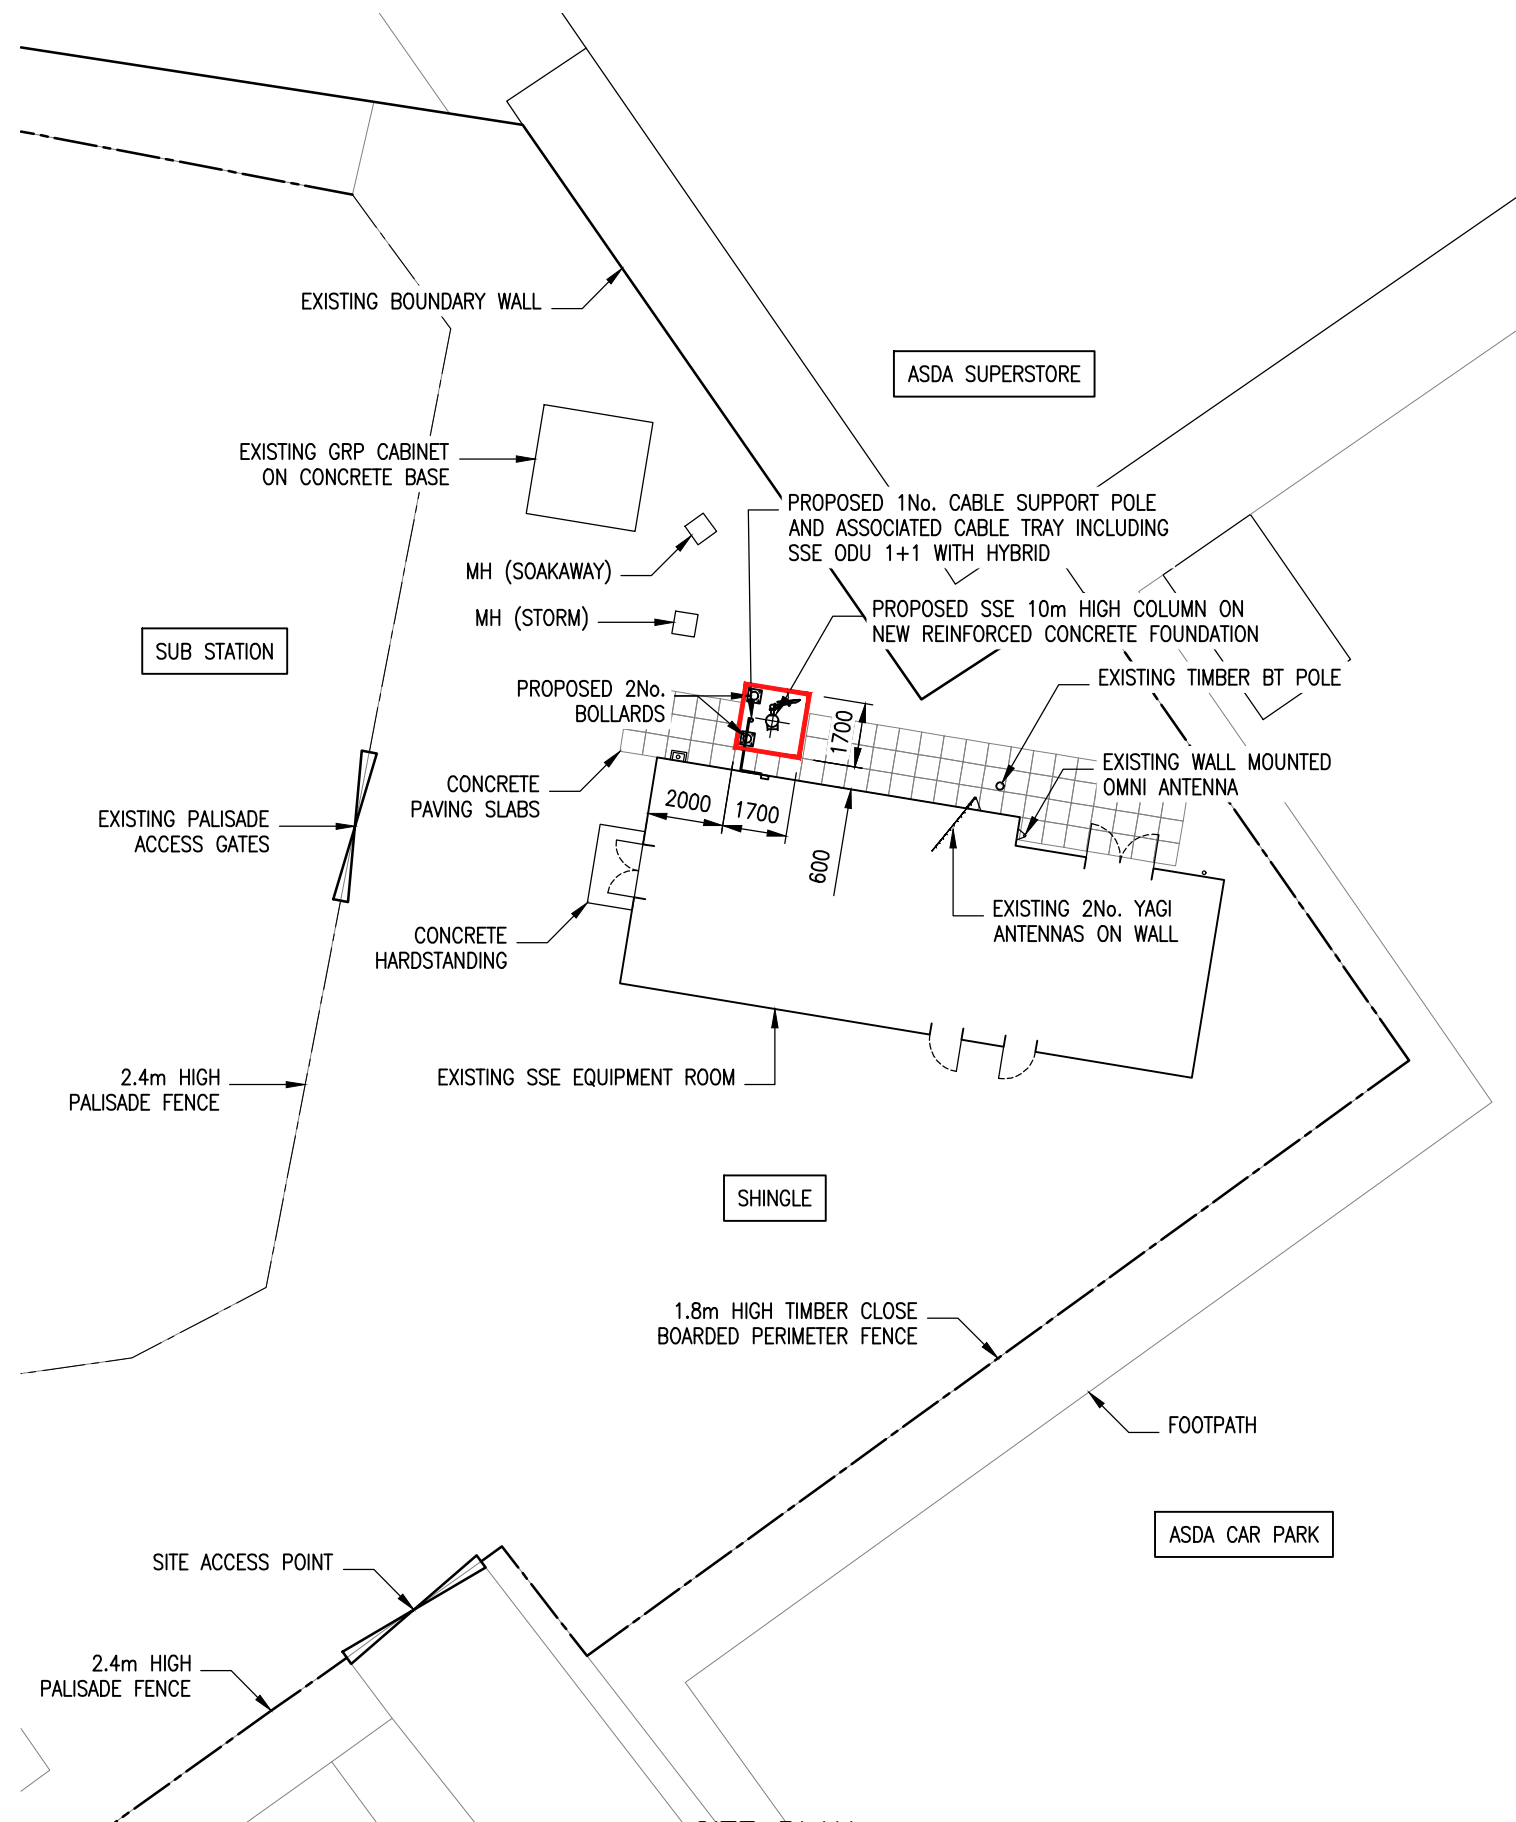

SITE PLAN
SCALE 1:200

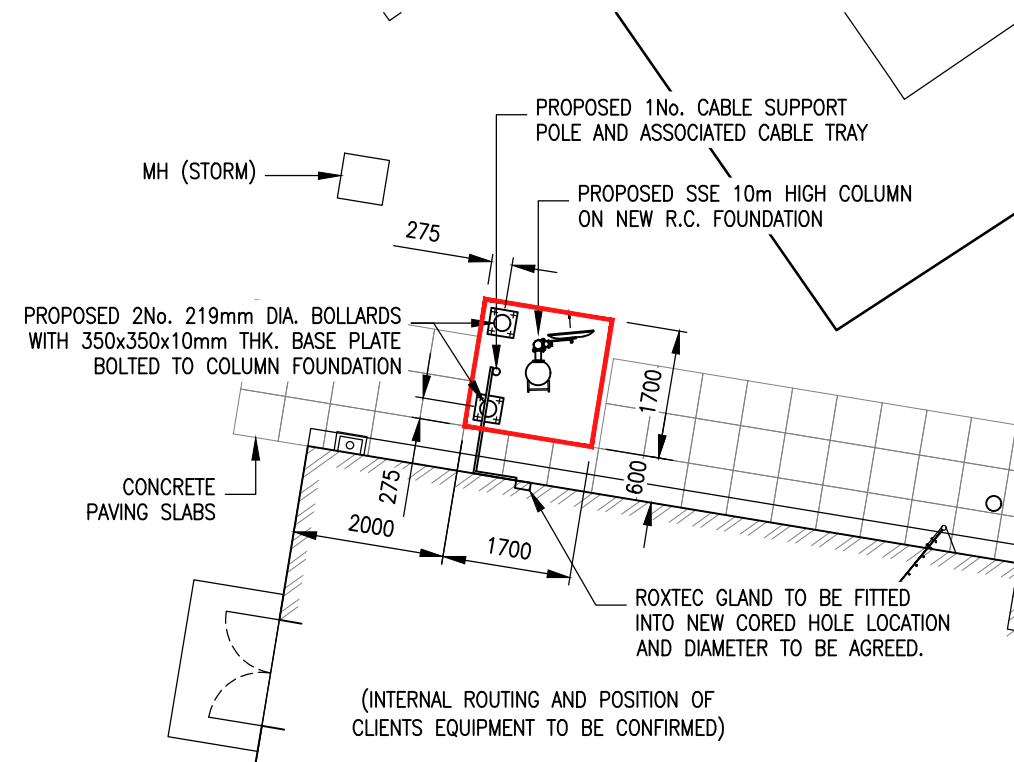

PLAN ON PROPOSED COLUMN
SCALE 1:100

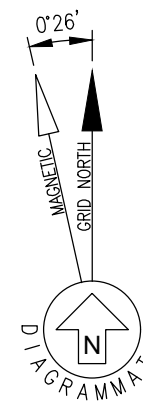

ORIGINAL PRINT SHEET SIZE A3

NOTES

1. EACH DISH WILL HAVE LOCATED BEHIND THEM ASSOCIATED EQUIPMENT INCLUDING (BUT NOT LIMITED TO) AN ODU, A MEDIA CONVERTER AND 3G MODEM.

REV	DATE	DESCRIPTION	CAD	CHKD
1	09.12.19	ISSUE FOR APPROVAL	MDL	PB

LARS
COMMUNICATIONS

MFDCl
Communication Infrastructure Consultants

MFD Communication Infrastructure Limited
Unit 41 t: 0800 058 8550
Basepoint Business Centre
Andersons Road e: enquiries@mfdci.co.uk
Southampton
SO14 5FE w: www.mfdci.co.uk

CLIENT
sse
Enterprise

PROJECT
WATERLOOVILLE 132kV SUBSTATION
LONDON ROAD
WATERLOOVILLE PO7 7TW

TITLE
SITE PLAN

SCALE AT A3 AS SHOWN	DATE 14.10.19
DESIGN/CAD PB/MDL	REVIEWED BY PB

DRAWING NUMBER 1509-P1/DD/202	REV 1
---	-----------------

FOR CONSTRUCTION