


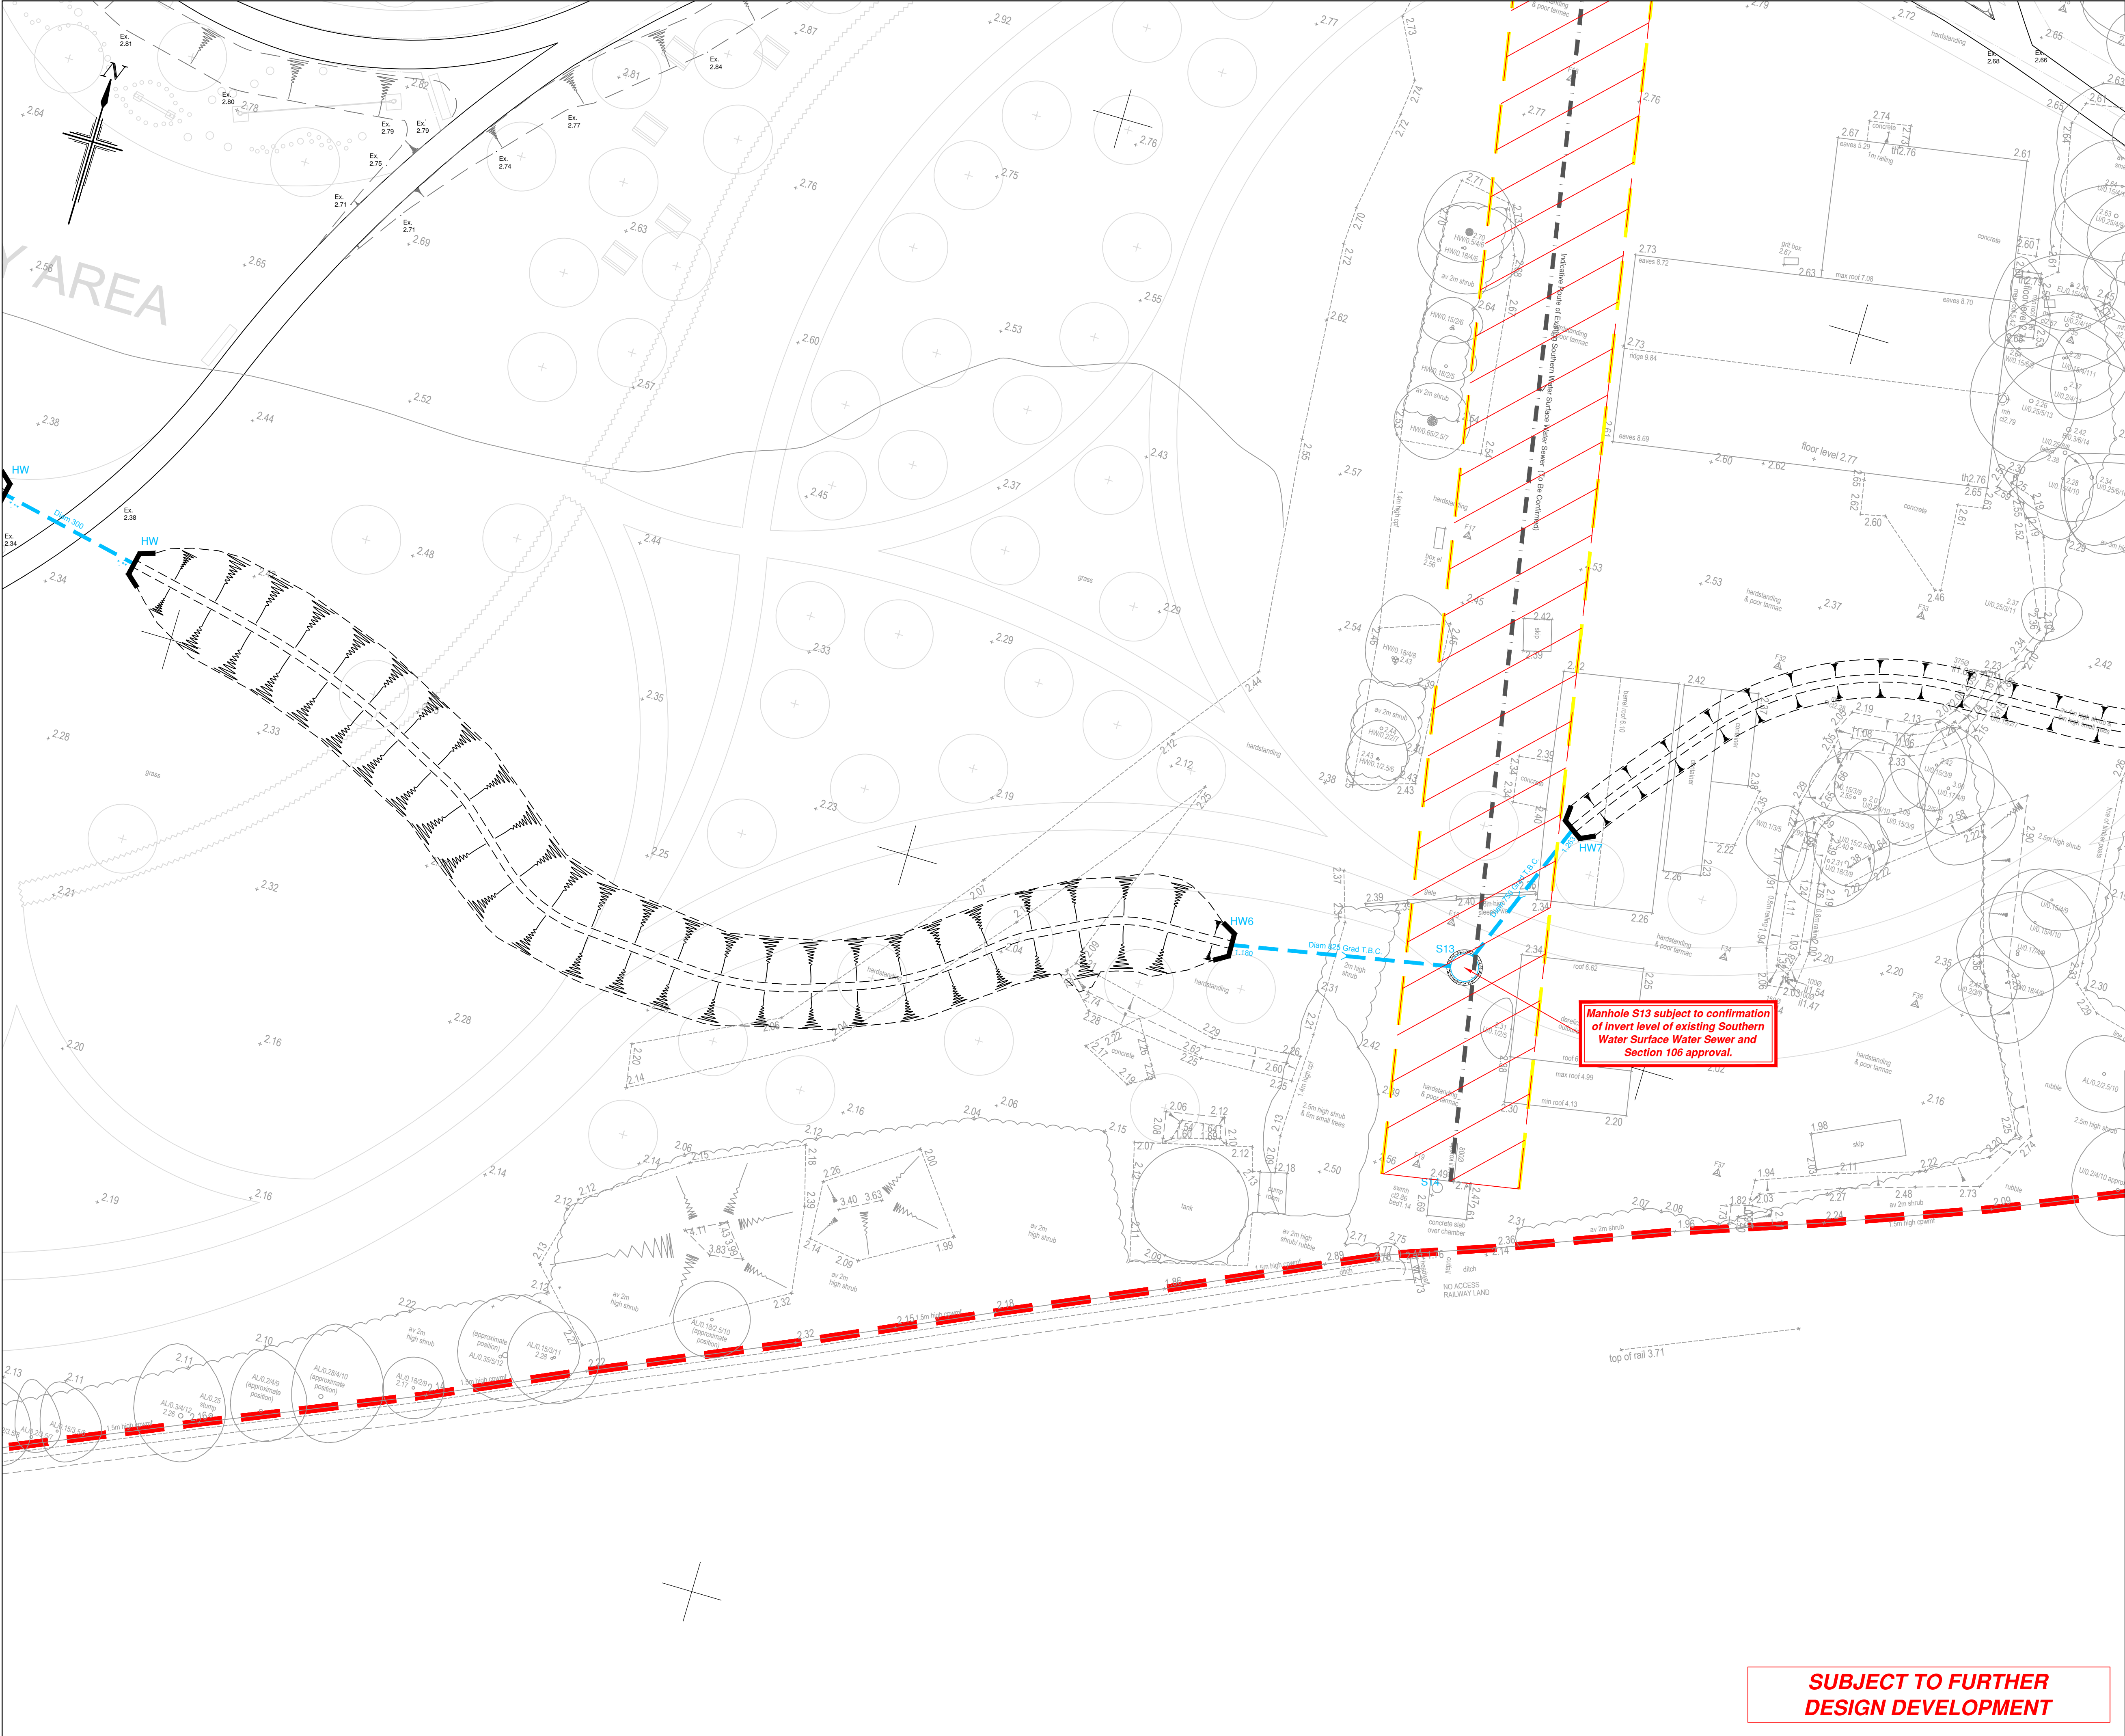

NOTES

- All dimensions are in metres unless stated otherwise.
- Do not scale from this drawing. Only written dimensions are to be used.
- FW & SW house drains are to be constructed in accordance with the Building Regulations & BS8301 & the WRc Guide Sewers for Adoption 7th Edition.
- Drains are to be constructed using flexible jointed vitrified clay pipes to BS EN 205-1991 "Super Strength" specification (i.e. Hagerorth Superstrength or similar) or uPVC drainage pipework to BS4540 & BS4544, bedded & backfilled in accordance with manufacturers instructions.
- Location of sewers & lateral drains to be in accordance with the WRc Guide Sewers for Adoption 6th Edition and specific requirements of local water.
- Backfilling of drain trenches adjacent to dwelling or other structure to be in accordance with BS8301 Fig. 9.
- Cover levels indicated on the Drainage Schedules are nominal & may be adjusted to suit finished ground levels as necessary.
- Generally inspection chamber covers should be Grade D400 in trafficked areas Grade B125 in parking areas and occasional traffic and A15 in pedestrian only areas.
- Rainwater downpipes to be connected direct to drain using an appropriate adaptor & removable section of downpipe to permit rodding access.
- The positions of SVPs, sub stacks, WC outlets, Back inlet gullies etc. & rainwater downpipes are to be accurately located from the house type working drawings.
- Generally FW drains are to be laid to falls of 1 in 40. SW drains are to be laid to falls of 1 in 60, both in 100mm diameter pipes. SW pipes are to be 150mm diameter when serving 2 dwellings or 2 RWP connections. FW pipes are to be 150mm diameter when serving 15 dwellings or more unless stated otherwise, or where a schedule is provided.
- 100mmØ Drains are to be laid to a minimum fall of 1 in 80 and 150mmØ Drains are to be laid to a minimum fall of 1 in 150.
- Gullies situated in areas accessible to wheeled vehicles to be of suitable construction for trafficked areas.
- Where land drain is identified on the Architect's details, connect into nearest SW system.
- Where catchpits have been shown in rear gardens connecting to land drains, 600mm PPVC catchpit to be used.
- This drawing should be read in conjunction with the Architect's and Structural Engineer's design drawings and specification.
- Site layout shown in this drawing is based on ID Partnership Proposed Site Layout Plan, drawing number PL-04 revision G, issued to RCP in .dwg format on 08/01/2019.
- Architectural blocks based on RCP Block Foundation Layout, drawing numbers 4519/AF-FOUND051 to 31 dated December 2018. Substitutions based on SSI Standard Substation Enclosures, drawing number MP/30/1644 revision A, as provided by Client on 10/1/2019.
- Topographical Survey as per Site/Field Site Survey, drawing number 36/A01, dated August 2016.
- Background landscaping proposals based on Fabric drawing number D0434, issued to RCP in .dwg format on 08/01/2019.
- This drawing should be read in conjunction with Adoptable Drainage Construction Details (BSO/E4519/411 & 412), Foul Water Sewer Manhole Schedules (BSO/E4519/413 & 414), Surface Water Sewer Manhole Schedules (BSO/E4519/415 to 417), other Drainage General Arrangements and Domestic Drainage Construction Details (BSO/E4519/471 & 472).
- Where backdrops is less than 1.0m for domestic drainage, backdrop to be accommodated with internal benching.
- ANY VARIANCE OR DISCREPANCY MUST BE REPORTED BACK TO RCP ENGINEERING BEFORE WORK BEGINS.**

KEY

Site Boundary
Section S276 Works By Others
(Refer to Paul Basham Associates Design Drawings for Details)

FFL=20.000
SSL=19.775

Existing Southern Water Foul & Surface Water Sewers

Adoptable Surface Water Sewers

Adoptable Foul Water Sewers

Adoptable Foul Water Rising Main

Concrete Bagwork / PCC Headwalls

Road Gully and Connection

Private Surface Water Domestic Drainage

Private Foul Water Domestic Drainage

House connection via 300mm dia. shallow access chamber not more than 600mm deep (Based on floor make-up of 75mm screed, 150mm insulation & 150mm Dimple & Block Floor).

In the event that conditions on-site result in maximum depth of 600mm being exceeded, then Type 4-F chambers to be used.

Internal Foul Connections

Soil Vent Pipe

Direct Drain (WHB, WC, WC, WM)

Sealed Floor Gully

Gully

Rodding Eye
(Refer to Vehicular Rodding Eye construction details for RE Located in Parking Bays)

*Acco Channel or similar

Yard Gully and Connection

Root Protection Areas.
(Based on Barratt Tree Consultancy Tree Protection Plan, drawing number 16270-8712, issued to RCP in .dwg format on 17/12/2018)

Tree Protection Fencing
(Based on Barratt Tree Consultancy Tree Protection Plan, drawing number 16270-8712, issued to RCP in .dwg format on 17/12/2018)

Any proposed works within Root Protection Areas are subject to supervision and approval by the Arboriculturist.

CDM NOTES

- EXISTING SERVICES.** Depth of existing services must be determined prior to works commencing. The contractor is responsible for establishing underground services in accordance with HSE Guidance note HS (G) 47. Any services which would be within the proposed construction layers must be lowered to below the sub-base.

SCALE BAR 1:200 at A1

Rev.	Date	Details	By	Chkd	Appd
B	21.10.19	Updated to Clients Comments and Updated Drainage in POS	RM	LD	TRS
A	XX.03.19	Updated Work in Progress	PJ	TS	TS

Client:-

BARRATT HOMES

DAVID WILSON HOMES
WHERE QUALITY LIVES

Site:-
**Harbour Place,
Forty Acre Farm,
Bedhampton**

Drawing Title:-
**DRAINAGE
GENERAL
ARRANGEMENT**
SHEET 10 OF 14

Date:- February 2019 Scales:- 1:200 at A1

Drawn:- AC Checked:- NW Approved:- TRS

Drawing No. **BSO/E4519/460 B**

TENDER ISSUE

SUBJECT TO ADOPTING AUTHORITY APPROVAL

RCP
ARCHITECTURE & CIVIL ENGINEERING

Rogers Cory Partnership
Architectural and Civil Consultants
The Old School Old School Road
Hook Hampshire RG27 9NJ

T: 01256 769269 E: mail@rcpconsultants.co.uk W: rcpconsultants.co.uk

**SUBJECT TO FURTHER
DESIGN DEVELOPMENT**