


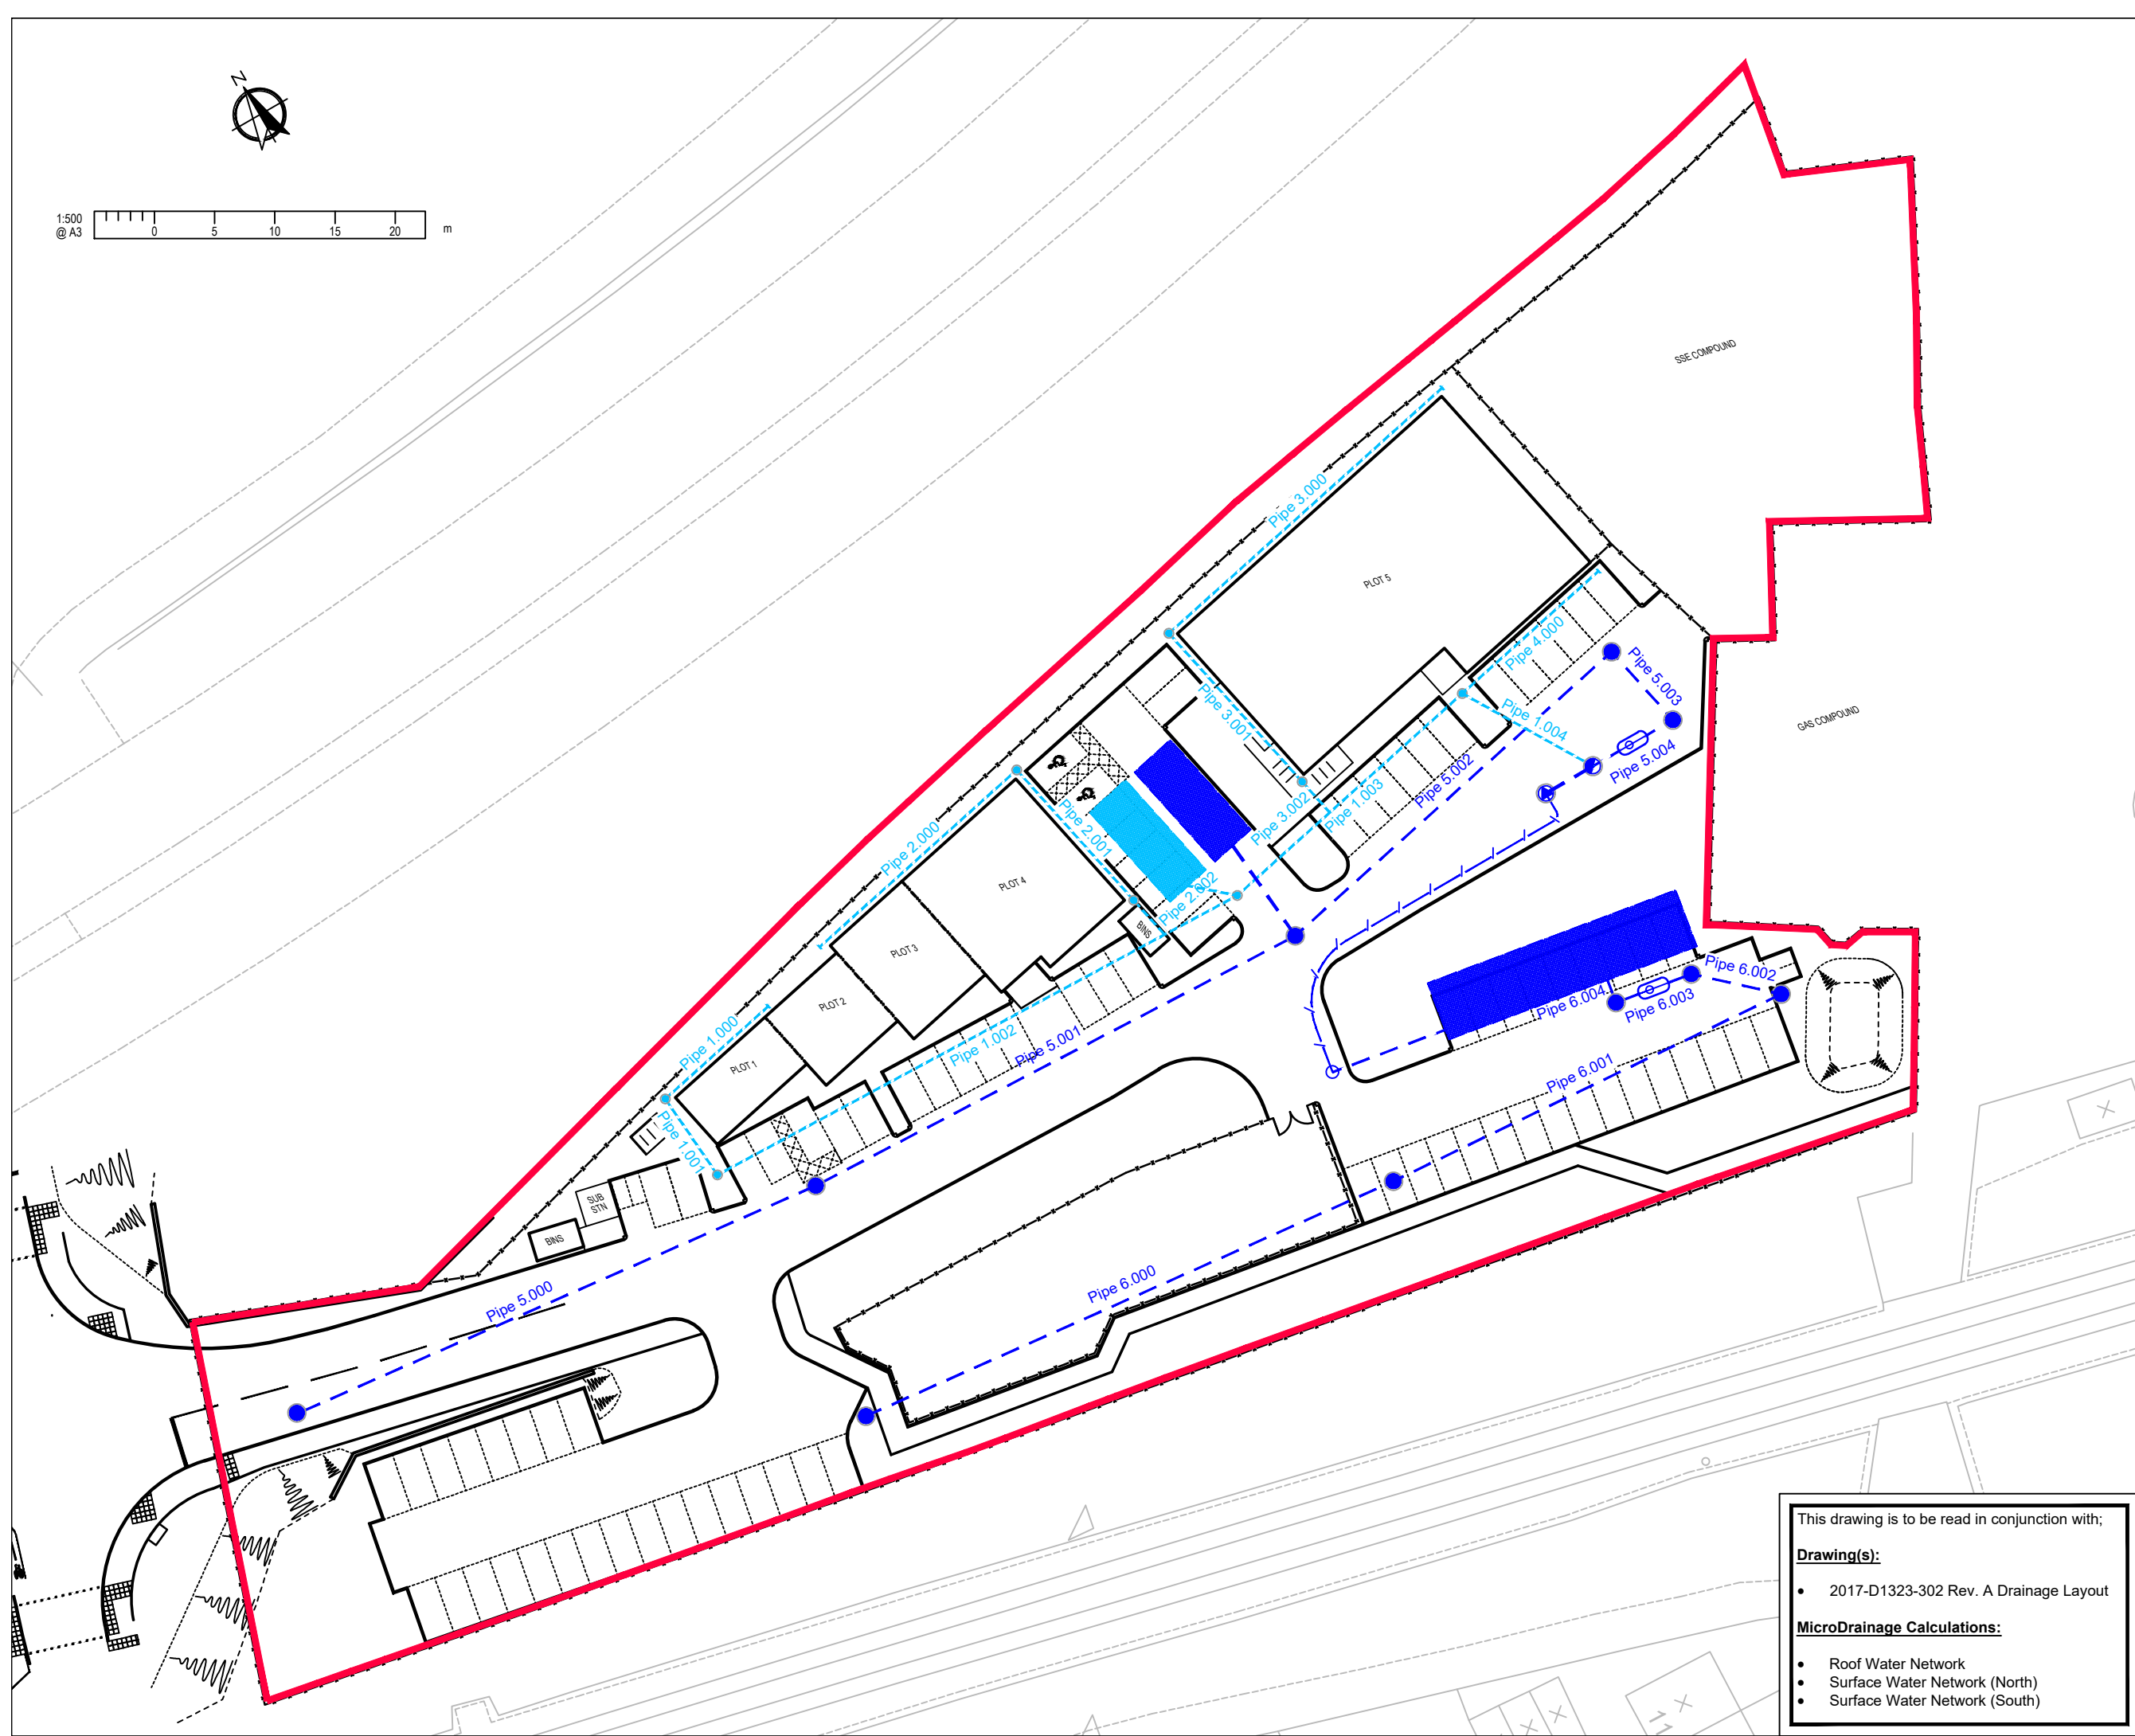

NOTES

A3

1. This drawing is to be read in conjunction with all other RGP drawings, and with all relevant Architect's and Engineer's drawings and specification. Any discrepancies found are to be reported immediately to the Engineer.
2. RGP accepts no responsibility for inaccuracies in data provided by third parties such as topographic surveys or Ordnance Survey mapping.
3. Do not scale, work to figured dimensions only. All dimensions are in millimeters unless noted otherwise and all levels are in metres from the topographic survey datum.
4. Any information given regarding existing underground services is given in good faith after consultation with the relevant authority, however accuracy is not certain.

PRELIMINARY



Transport Planning and Infrastructure Design Consultants
2 West Barn, Norton Lane, Chichester, West Sussex PO20 3AF
Tel: 01243 210418 Fax: 01483 861682 www.rgp.co.uk

Client
The Savoy Latham Partnership Ltd

Project
Interbridges, North Street,
Emsworth, Hampshire PO10 7PH

Drawing Title
MicroDrainage Network
Supporting Drawing

Scale	1:500	Drawn By	SPB	Checked By	MJA	Approved By	MJA
-------	-------	----------	-----	------------	-----	-------------	-----

Date	October 2018	Drawing No.	20017-D1323-SK2000	Rev.	A
------	--------------	-------------	--------------------	------	---

This drawing is to be read in conjunction with;

Drawing(s):

- 2017-D1323-302 Rev. A Drainage Layout

MicroDrainage Calculations:

- Roof Water Network
- Surface Water Network (North)
- Surface Water Network (South)