


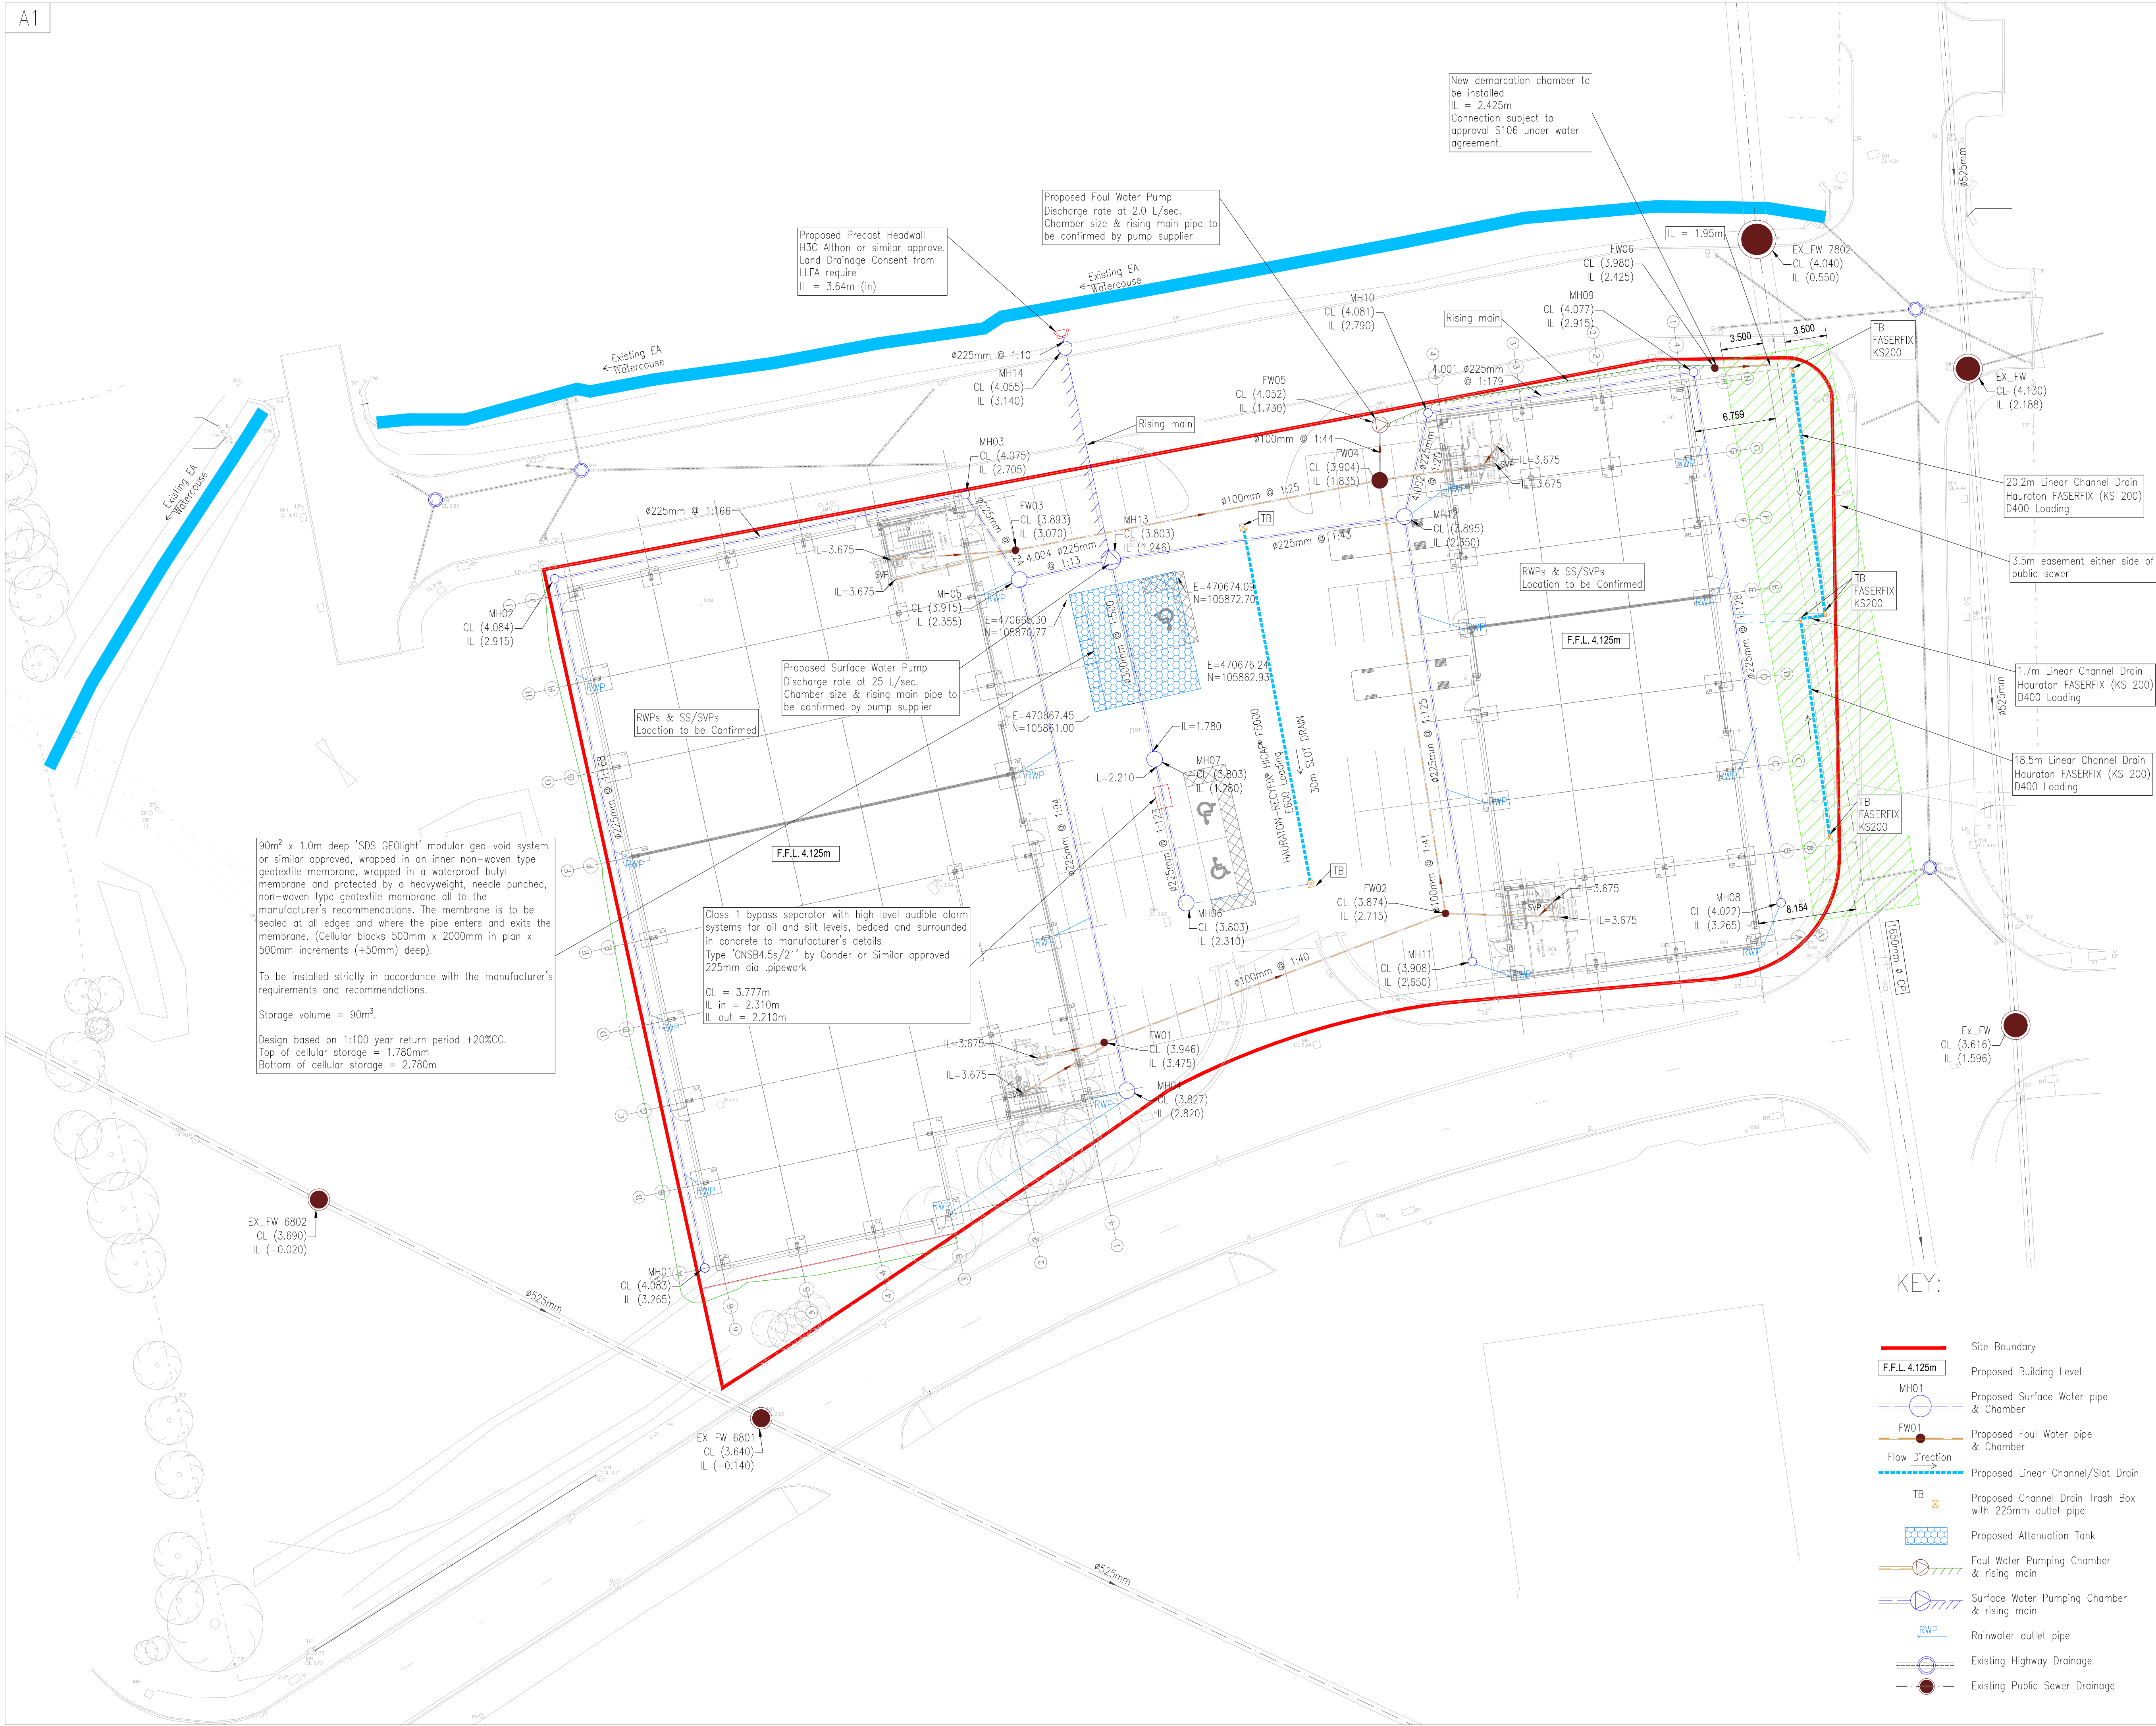

- Notes:
1. Do not scale from this drawing.
 2. In case of any discrepancies in drawings, details or bills, refer to engineers for clarification: unilateral decisions by the Contractor will not be accepted.
 3. This drawing is to be read in conjunction with all related Architects, Consultants & Sub-Contractors drawings and specifications.
 4. The Contractor is advised that all design drawings and information are to be read concurrently and any discrepancies or omissions reported directly to PTA Civils Department.
 5. The Contractor must check the levels of all existing drainage outfalls prior to construction of any drainage, unless otherwise agreed, to ensure the proposed design may be achieved. Any discrepancies must be reported immediately to PTA Civils Department.
 6. All external building dimensions are to be checked against the Architects drawings prior to any construction commencing.
 7. Proposed site plan is based on 'McCurdy Russell Architects' drawing no. 001.103.01.201
 8. Background Topographical survey is based on 'DesignBase Surveying & BIM' data dated 12.02.2018
 9. Reproduction of Existing public sewer is based on information received dated 18.04.2018 and As built information from 'Upton McGough' drawing 034.0036-2102 dated 02.07.2015.
 10. For Drainage Construction Refer to drawing 9591-9130 & 9131
 11. For Manhole Schedule refer to drawing: 9591-9150
 12. Rainwater outlet pipe to be 100mm Ø unless otherwise stated.

© Powell Tolner & Associates Ltd.
The contents of this drawing may not be reproduced in whole or in part without the prior written permission of Powell Tolner & Associates.

Drawing Status
FOR CONSTRUCTION
SUBJECT TO THE FOLLOWING:-

H	Foul water public connection amended. Easement dimension added	SN	20.11.18/SLW
G	FW02a & FW04a removed.	SN	31.10.18/SLW
F	FW2a relocated. Capped off drainage amended	SN	10.10.18/SLW
E	Foul Water pump discharge amended. New Foul Water Chamber and lateral pipe added	SN	28.09.18/SLW
D	Rainwater downpipe location for units 1 & 2 amended	SN	26.09.18/SLW
C	New Manhole MH14 added	SN	18.09.18/SLW
B	Drainage layout amended to suit Architect Plan	SN	12.09.18/SLW
A	Issue for Construction	SN	30.08.18/SLW
-	First Issue	SN	25.05.18/SLW
Rev.	Description	By	Date Chk'd

Project Title		
Harts Farm Way Havant		
Drawing Title		
Drainage General Arrangement Layout		
Date	May 2018	Checked DO
Drawn	SN	Checked ENG
Scale	1 : 250	SN
Project No.	9591	Rev.
Drawing No.	9100	
		H

structural Engineers

pta

29 Red Lion Street
Chesham
Bucks.
HP5 1EJ
Tel. 01494 772721