


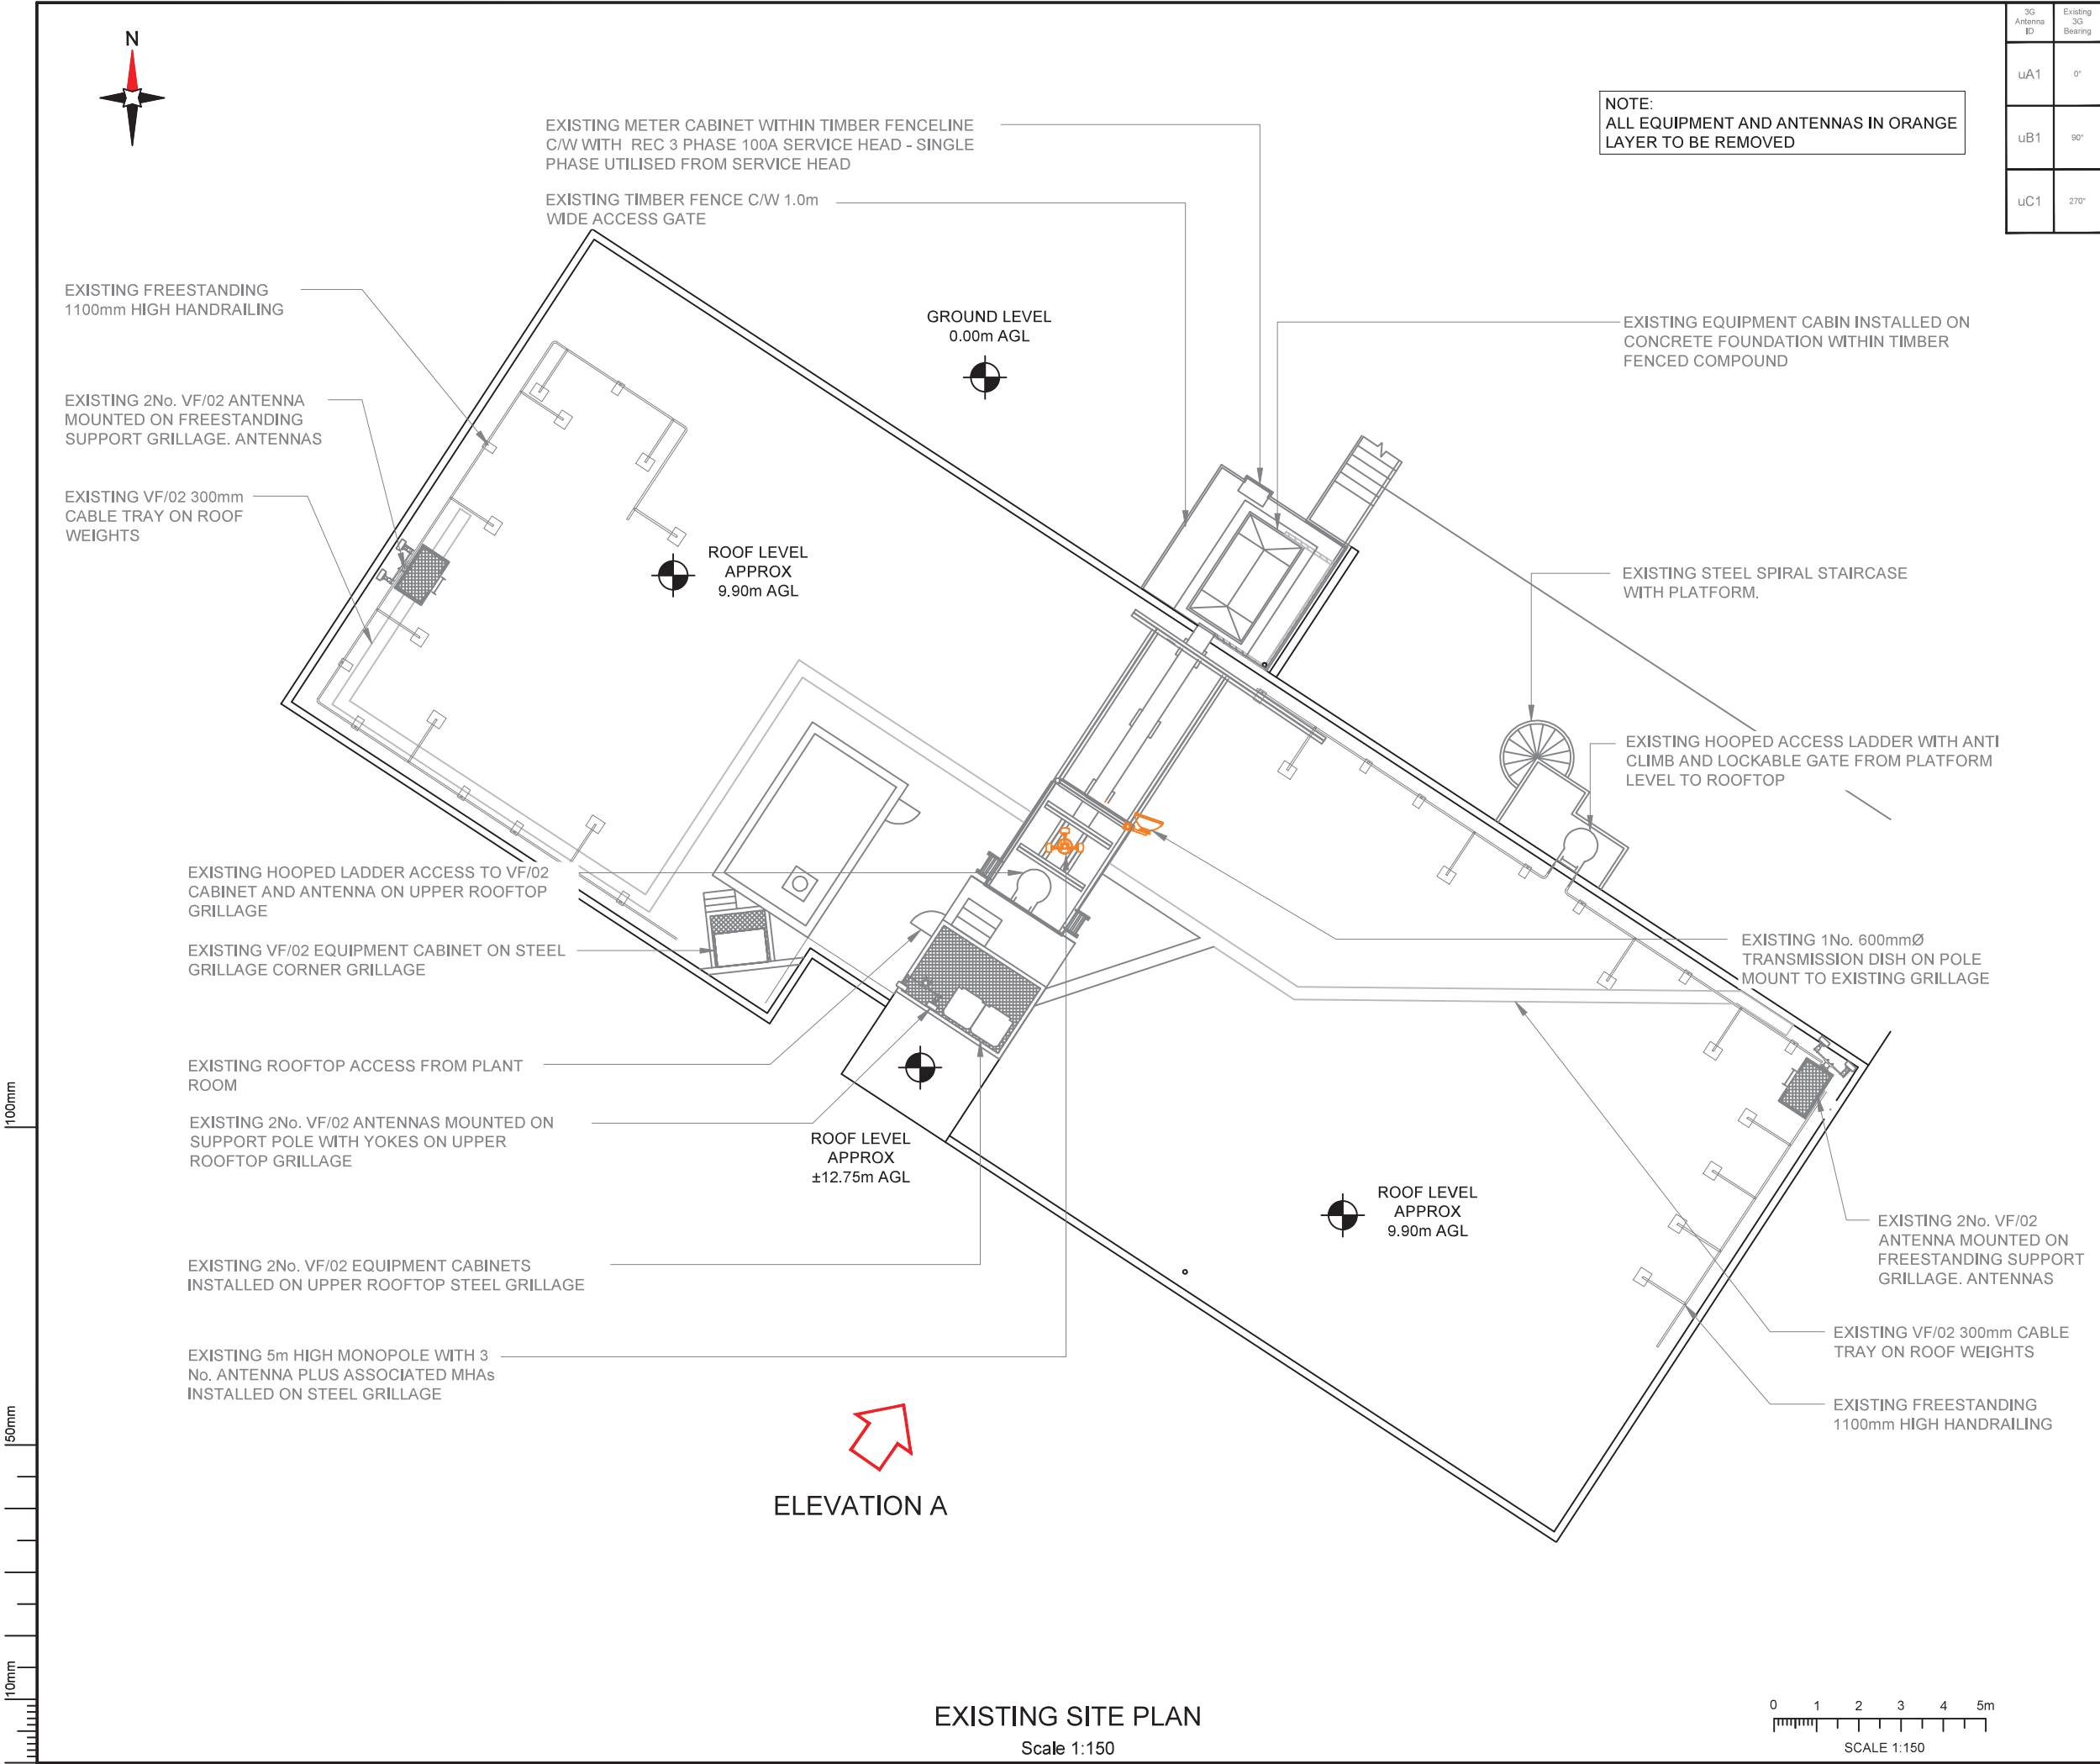

| 3G Antenna ID | Existing 3G Bearing |
|---------------|---------------------|
| uA1           | 0°                  |
| uB1           | 90°                 |
| uC1           | 270°                |

|           |                  |                                     |     |                   |          |        |   |
|-----------|------------------|-------------------------------------|-----|-------------------|----------|--------|---|
| Master:   | MBNL / EE / H3G: | Project:                            | T&A | Purpose of Issue: | Planning | Issue: | D |
| M004      | MBNL             |                                     |     |                   |          |        |   |
| Date:     | 05/07/2019       | Revision / Upgrade Description:     |     |                   |          |        |   |
| Drawn:    | DJM              | Notes amended                       |     |                   |          |        |   |
| Checked:  | DB               |                                     |     |                   |          |        |   |
| Approved: | DJM              |                                     |     |                   |          |        |   |
| Master:   | MBNL / EE / H3G: | Project:                            | T&A | Purpose of Issue: | Planning | Issue: | C |
| M003      | MBNL             |                                     |     |                   |          |        |   |
| Date:     | 01/07/2019       | Revision / Upgrade Description:     |     |                   |          |        |   |
| Drawn:    | KD               | ICNIRP Lobes Option 3 added         |     |                   |          |        |   |
| Checked:  | DB               |                                     |     |                   |          |        |   |
| Approved: | DJM              |                                     |     |                   |          |        |   |
| Master:   | MBNL / EE / H3G: | Project:                            | T&A | Purpose of Issue: | Planning | Issue: | B |
| M002      | MBNL             |                                     |     |                   |          |        |   |
| Date:     | 31/05/2019       | Revision / Upgrade Description:     |     |                   |          |        |   |
| Drawn:    | DJM              | Triage notes / ICNIRP zones amended |     |                   |          |        |   |
| Checked:  | DB               |                                     |     |                   |          |        |   |
| Approved: | JC               |                                     |     |                   |          |        |   |



Hutchison 3G UK Limited  
Star House, 20 Grenfell Road  
Maidenhead, SL6 1EH  
Tel: 01628 765 900  
Fax: 01628 765 901

H3G Base Station Information line  
0845 6043000  
Available 8am-6pm Monday to Friday



Hatfield Business Park  
Hatfield  
Hertfordshire  
AL10 9BW

Tel: 01707 315000  
Fax: 01707 319001



Mobile Broadband Network Limited  
Sixth Floor, Thames Tower, Station Road, Reading, RG1 1LX



|                                 |                                                                     |              |
|---------------------------------|---------------------------------------------------------------------|--------------|
| Site Name:                      | SILVESTER HOUSE                                                     |              |
| Site ID:                        | 712303                                                              |              |
| Address:                        | SILVESTER ROAD<br>COWPLAIN<br>WATERLOOVILLE<br>HAMPSHIRE<br>PO8 8TD |              |
| Title:                          | 100 EXISTING SITE PLAN                                              |              |
| Project:                        | T&A                                                                 |              |
| Purpose of Issue:               | GENERAL ARRANGEMENT                                                 |              |
| EE Cell ID:                     | MBNL Cell ID:                                                       | 3UK Cell ID: |
| 91485                           | HVT007                                                              | PO0296       |
| Master Drawing No:              |                                                                     | Issue:       |
| 712303_HVT007_91485_PO0296_M004 |                                                                     | D            |