


Col Ref	Easting	Northing
P01	468312	112030
P02	468274	112110
P03	468277	112139
P04	468290	112152
P05	468280	112014
P06	468283	112004
P07	468241	112006
P08	468251	111984
P09	468191	111986
P10	468194	111954
P11	468212	111933
P12	468171	111962
P13	468147	111953
P14	468148	111912
P15	468171	111906
P16	468100	111922
P17	468101	111907
P18	468059	111900
P19	468043	111910

Unit Type ID	Count	Mounting Height	Column Material	Column Type	Column Colour	Installation Type	Root Length	Mounting	Luminaire Tilt	Luminaire	Optic Setting	Output (klm)	Colour Temperature	Wattage	Luminaire Weight	Windage	Control Unit	Switching Unit	Isolator	Electricity Supply
A	8	6 metres	Galvanised steel	Stepped tubular	Not painted	Planted	Factory standard	Post top	0 degrees	Philips BGP615 Micro Luma	DW50	0.80	Warm white	6W (6 no. LEDs)	7.6kg	0.049	Electronic ballast	Lucy Zodion SS9 (part-night) photo-cell	DNO Isolator	DNO
B	9	6 metres	Galvanised steel	Stepped tubular	Not painted	Planted	Factory standard	Post top	0 degrees	Philips BGP615 Micro Luma	DM50	0.80	Warm white	6W (6 no. LEDs)	7.6kg	0.049	Electronic ballast	Lucy Zodion SS9 (part-night) photo-cell	DNO Isolator	DNO
C	2	6 metres	Galvanised steel	Stepped tubular	Not painted	Planted	Factory standard	Post top	0 degrees	Philips BGP615 Micro Luma	DW50	0.80	Warm white	6W (6 no. LEDs)	7.6kg	0.049	Electronic ballast	Lucy Zodion SS9 (part-night) photo-cell	DNO Isolator	DNO

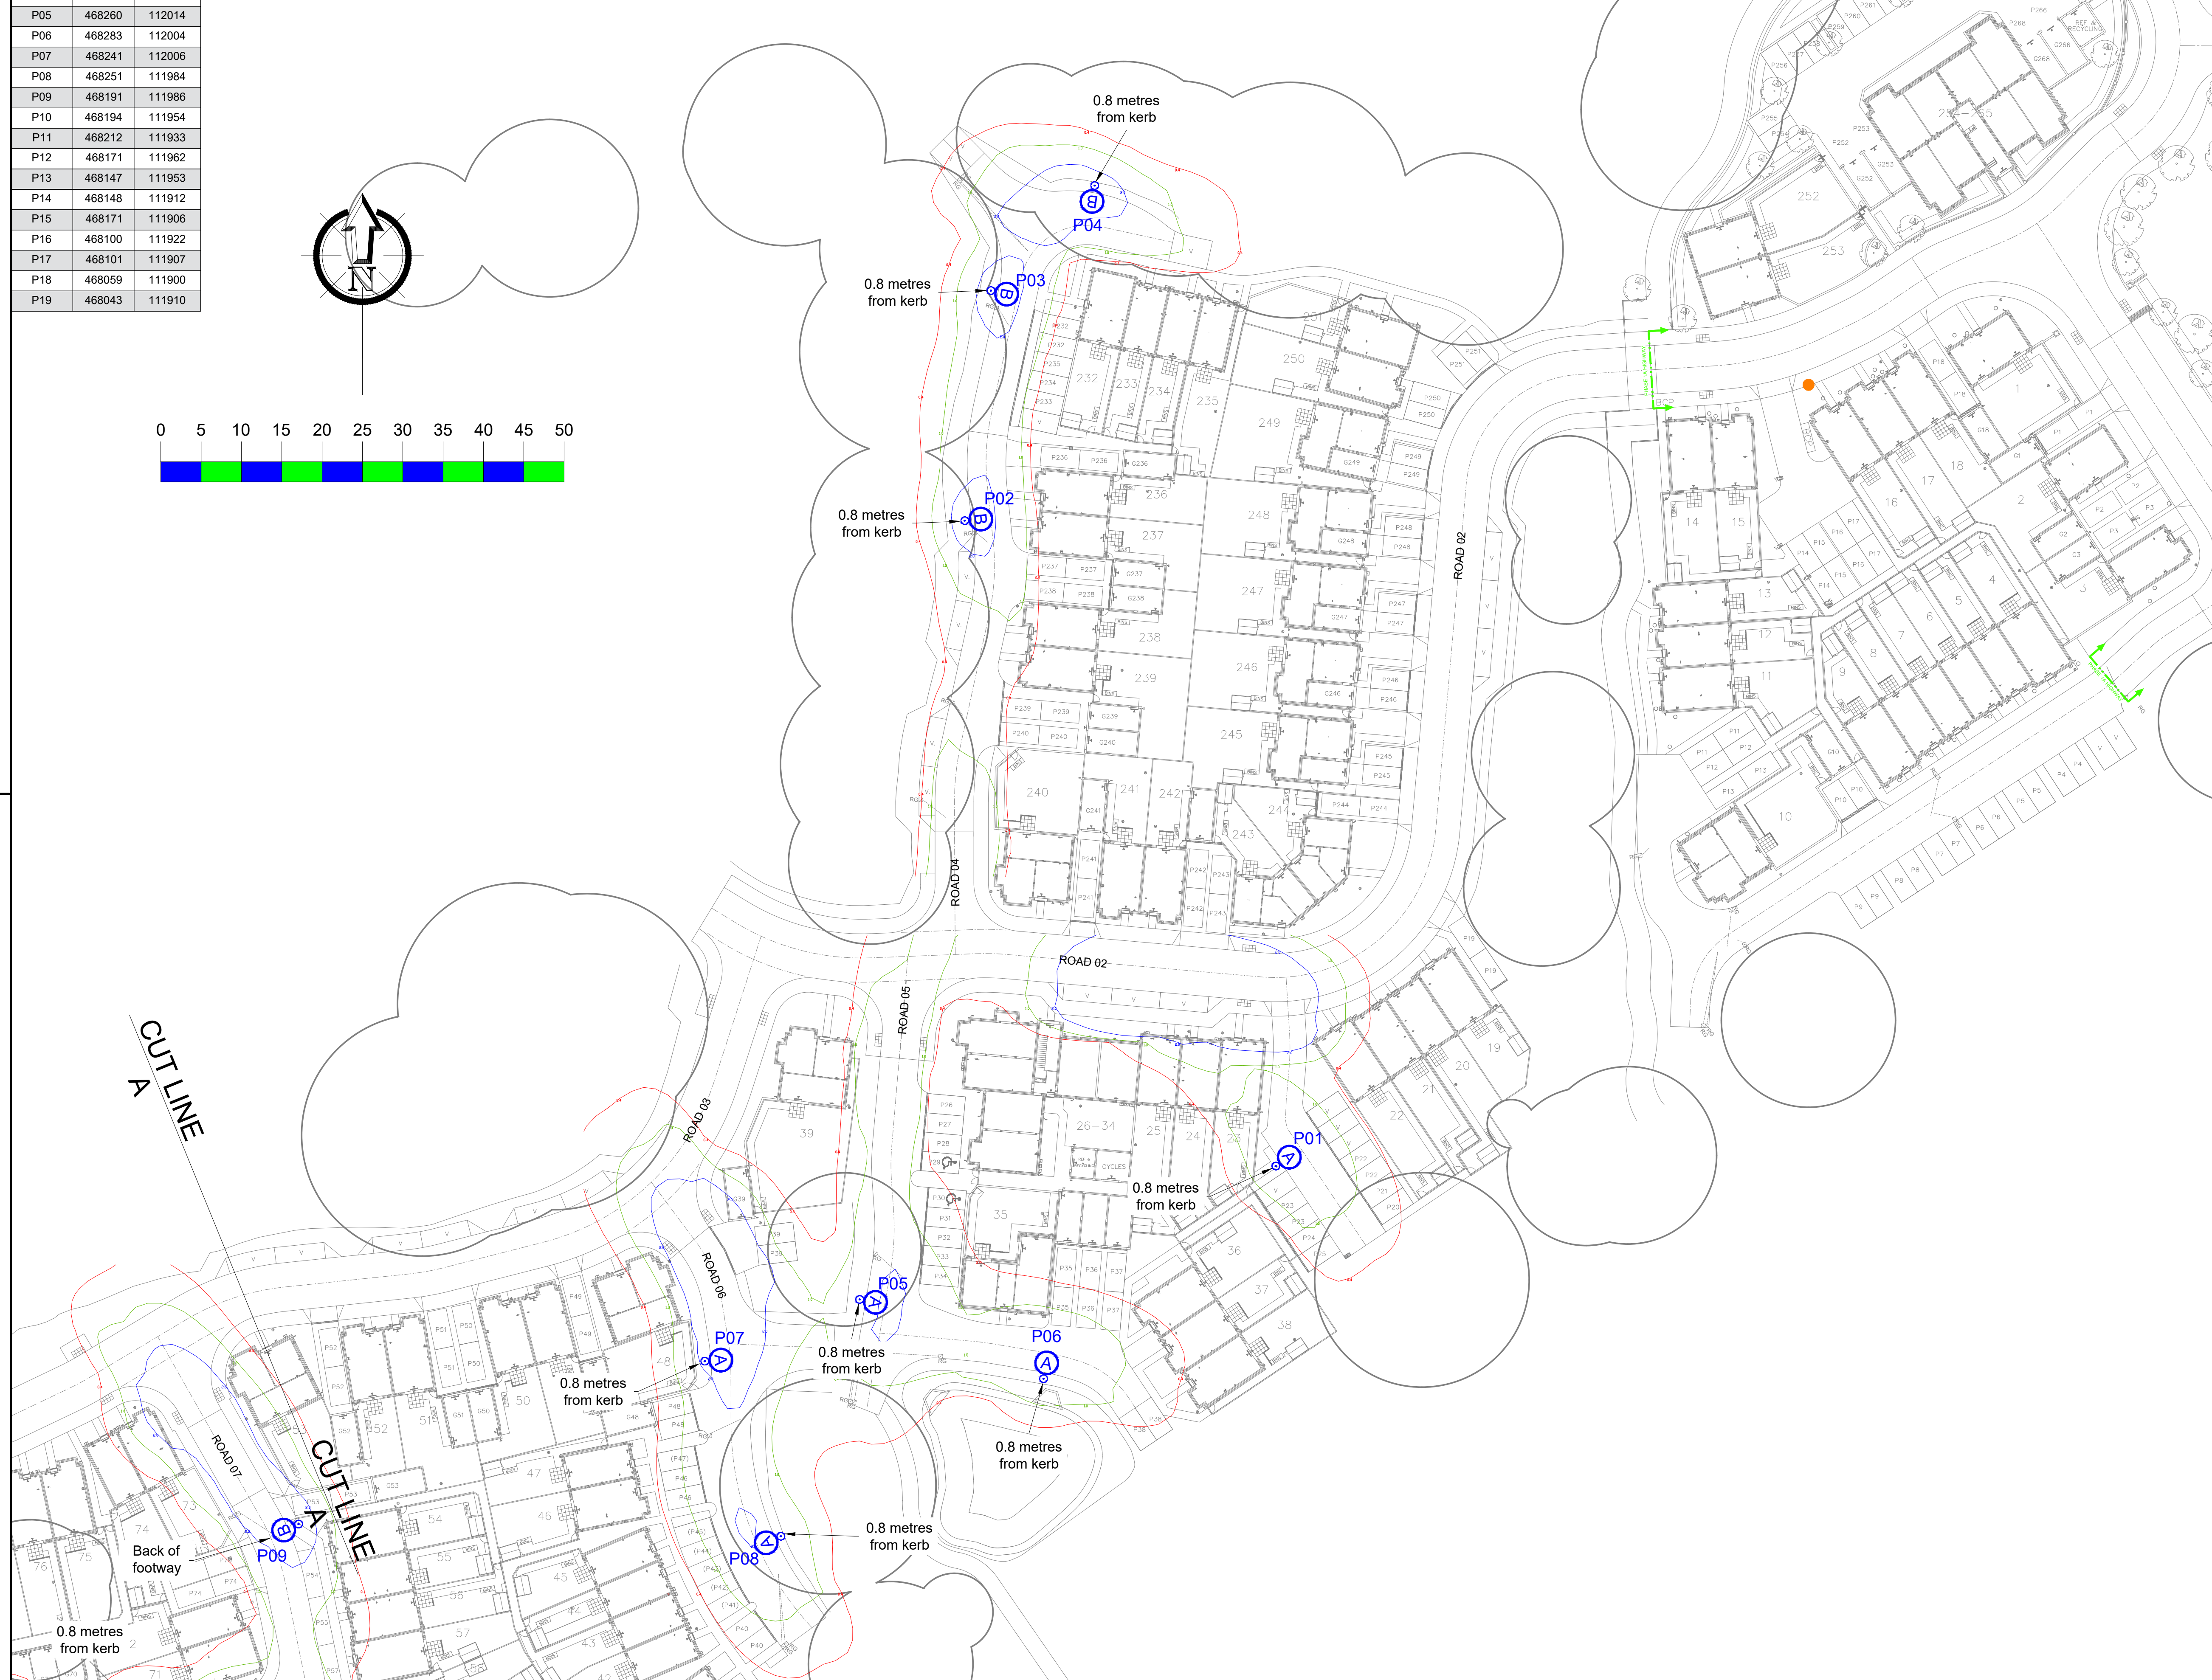

- | | |
|---|---|
| Key | |
|  | Proposed street lighting column (Unit ID displayed inside symbol). |
| Notes | |
| 1. | Do not scale from drawing if not printed at original paper size. |
| 2. | Contractor to confirm position of statutory undertakers plant before commencement of the works. For statutory undertaker's information visit www.innesearchbeforeyoudig.co.uk |
| 3. | During works all traffic management to be in accordance with Chapter 8 of the Traffic Signs Manual. |
| 4. | Lighting columns to be fed by DNO supply unless otherwise shown. |
| 5. | Columns to be numbered using adhesive labels suitable for exterior use. Letters and numerals shall be 50mm high black on a white background. |
| 6. | All apparatus are to be new at the time of installation and be supported by relevant manufacturer's guarantees. |
| 7. | All apparatus shall be sited so as to minimise, in so far as is reasonable and practical, nuisance, danger and obstruction to all residents, businesses and users of the highway. |
| 8. | All illuminated apparatus must be installed and tested in compliance with BS7671 at the time of adoption. |
| 9. | This detailed design has been prepared in accordance with the HEA-HEMSA guidance note - CDM2015 regulations, issue 1.1, dated 09/04/15 Procedure 3: information has been supplied by the client or another designer or the principal designer which forms the basis of this lighting scheme design and includes the hazards identified by others on their hazard elimination and management list. |

A	ORIGINAL ISSUE	29/05/19	MWG
REV	DESCRIPTION	DATE	BY



SSE Enterprise - Lighting, 1st Floor, Solent Park, Walton Road
Portsmouth, PO6 1UJ

TITLE	PRIVATE STREET LIGHTING LAYOUT DRAWING
-------	--

PROJECT WOODCROFT FARM HAVANT - PHASE 1B HAMPSHIRE

SCALE 1:500 @ A1	DATE	29/05/19
	DRAWN	MWG
	CHECKED	RHJ
PAPER SIZE A1	APPROVED	SAB

DRAWING NUMBER	REVISION
SSE251853-LD-003	A