


- KEY:
- bt British Telecom
 - cb Control Box
 - cl Cover Level
 - ctv Cable Television
 - dk Drop Kerb
 - el Electric
 - ep Electricity Pole
 - fh Fire Hydrant
 - gu Gully
 - gsv Gas Stop Valve
 - ht Height
 - ic Inspection Cover
 - il Invert Level
 - lp Lamp Post
 - mkr Marker
 - o/h Overhead
 - pb Post Box
 - pxg Prawn Crossing
 - np Name Plate
 - rs Road Sign
 - sv Stop Valve
 - tb Telephone Box
 - tl Traffic Light
 - tt Top of Tree
 - th Threshold
 - tw Top of Wall
 - utl Unable to Lift
 - vp Vent pipe
 - wm Water Meter
 - wsv Water Stop Valve

NOTES:
LEVELS RELATE TO O.S. DATUM
TREE SPECIES SHOULD BE VERIFIED WHERE OF
CRITICAL IMPORTANCE
THE ARCHITECT SHALL SATISFY HIMSELF THAT ALL TREES
LIKELY TO AFFECT HIS DESIGN HAVE BEEN SHOWN
WITH CORRECTION OF HANDLES SHOULD BE VERIFIED
WHERE OF CRITICAL IMPORTANCE USING CCV
PIPE SIZES & INVERTS DETERMINED WITHOUT
ENTRY INTO MANHOLE

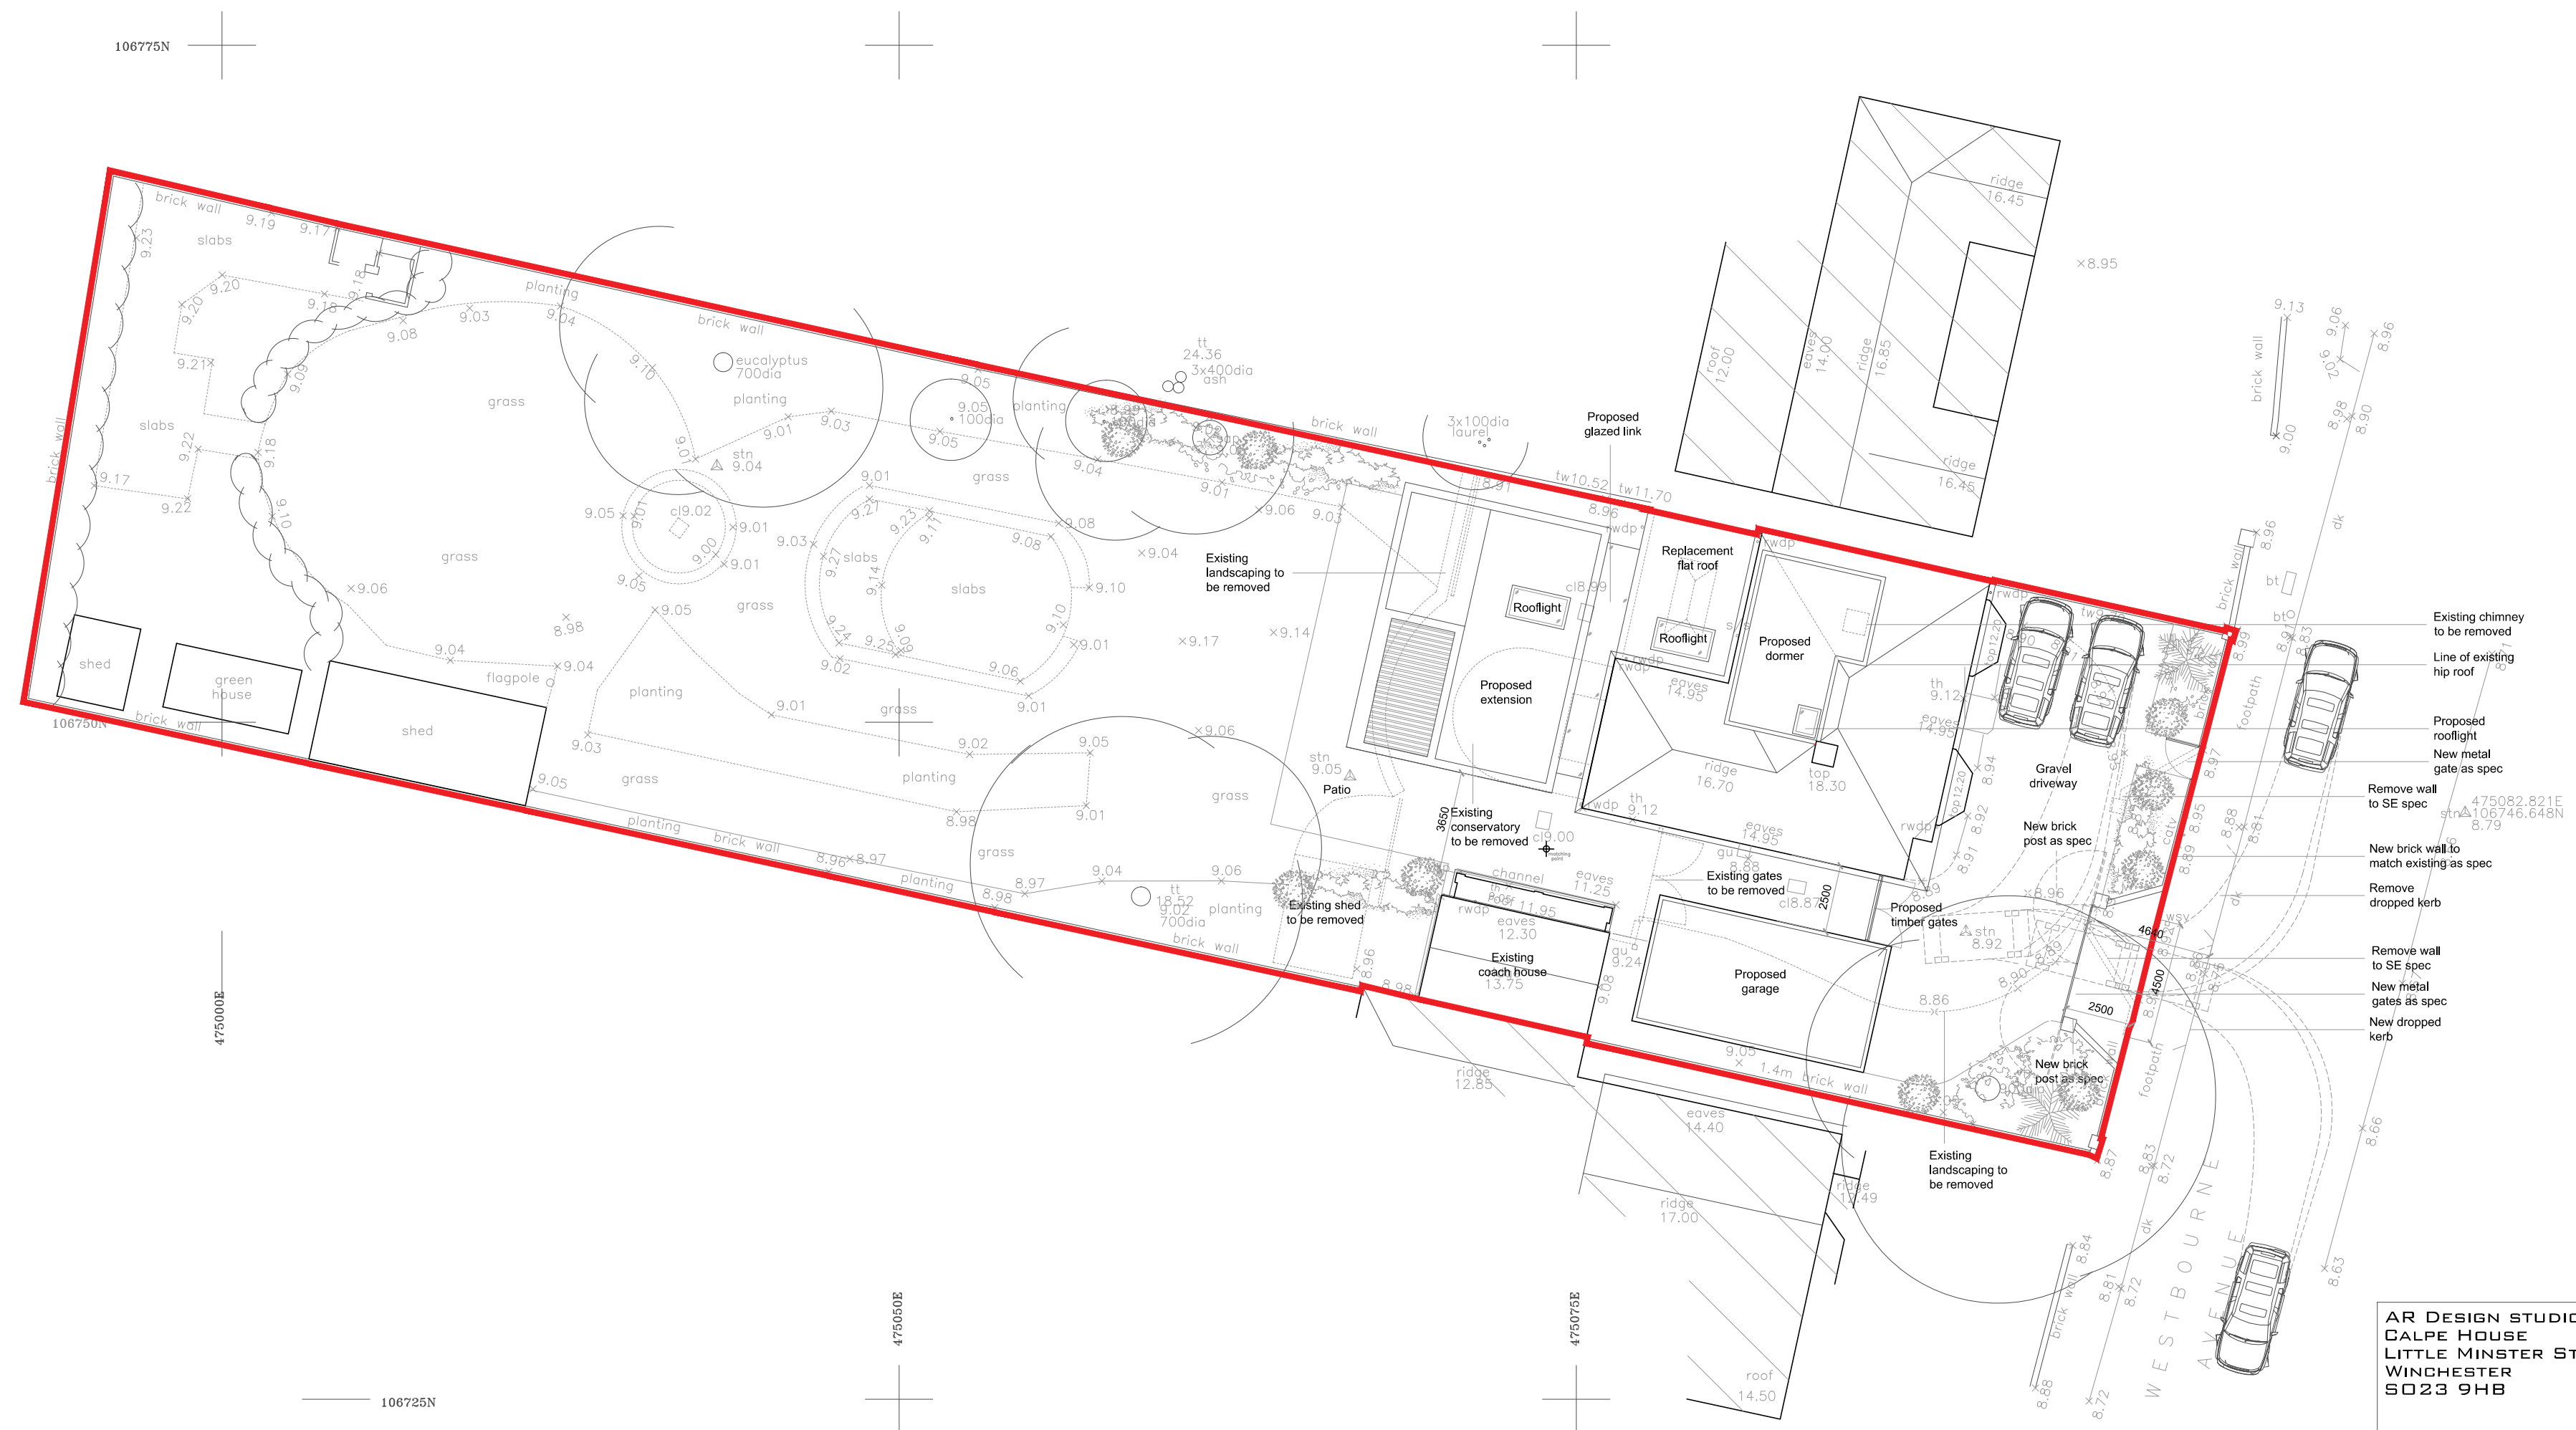


AR DESIGN STUDIO LTD
CALPE HOUSE
LITTLE MINSTER ST
WINCHESTER
SO23 9HB

AR

T. 01962 864545
E. INFO@ARDESIGNSTUDIO.CO.UK
WWW.ARDESIGNSTUDIO.CO.UK

Copyright: All rights reserved. This drawing and design must not be reproduced without permission. Dimensions are in millimetres unless specified. Only written dimensions to be worked from. Do not scale from this drawing.				
Job title				
Westbourne Ave				
Drawing title				
Proposed Site Plan				
Status				
Planning				
Drawn by	Checked by	Date	Scale at A3	Scale at A2
GM	AB	June 2018	-	1:100
Job No.	Dwg No.	Revision		
745	P102	-		

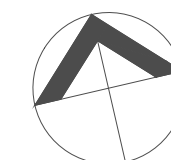

Draft

