


1 PROPOSED ATTIC FLOOR PLAN
Scale: 1:50

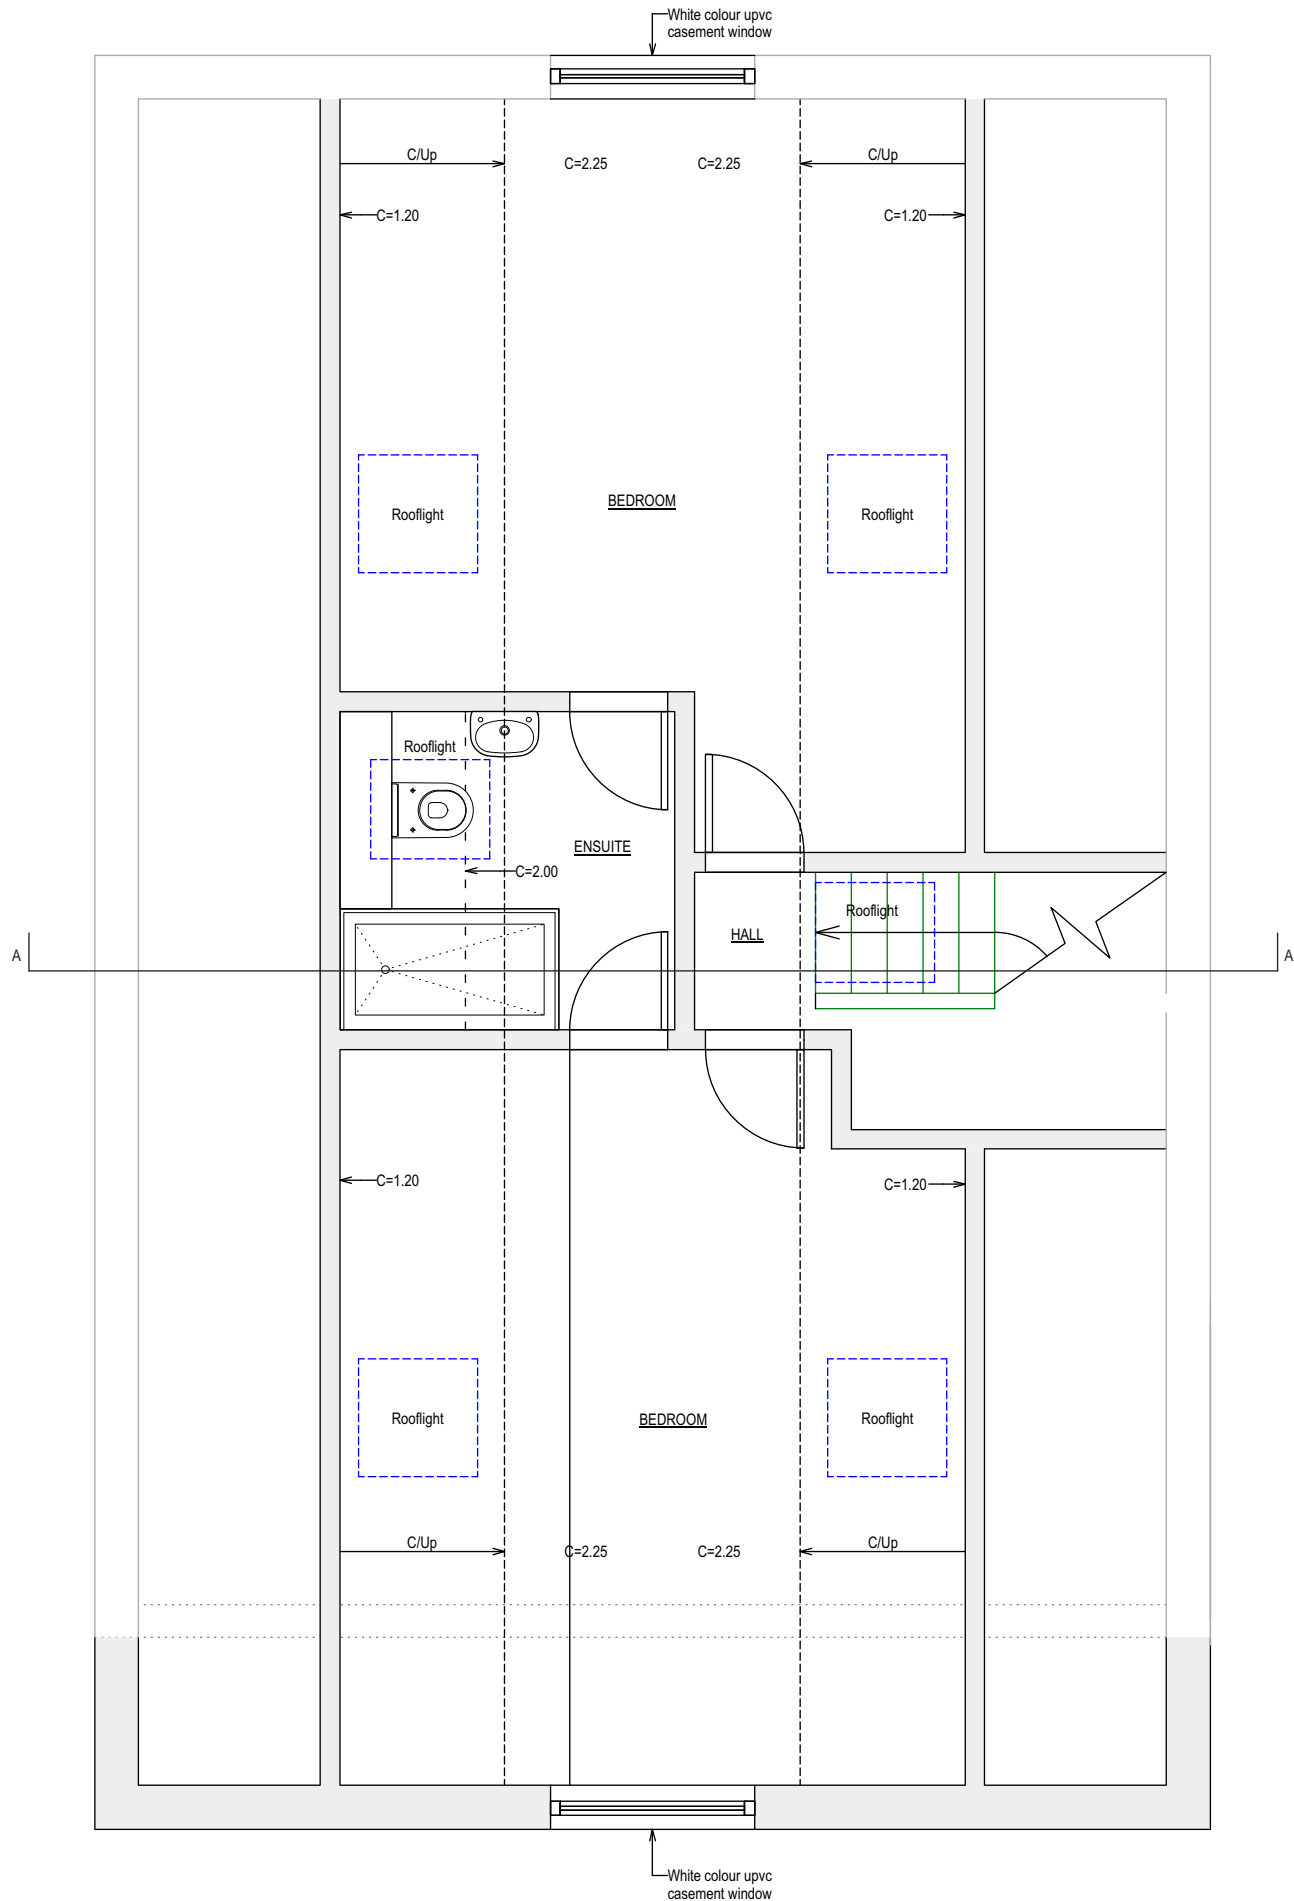

PLANNING

STATION SCHEDULE

STN	B	500.0000	1000.0000	50.0000
STN	A	499.8264	985.6333	50.1699
STN	C	509.9048	994.7463	50.1100
STN	D	510.2428	973.3945	50.2779
STN	E	500.3983	971.9018	50.2569

LEVEL DATUM

Levels are based on Temporary Bench Mark (TBM)
located on Station B, Value = 50.00m

NOTES

- All dimensions and levels to be checked on site by contractor prior to fabrication/construction.
- This drawing is to be read in conjunction with all relevant consultant's and/or specialist's drawings and documents. Any discrepancies or variations are to be notified to SurveyCloud Ltd before the affected work commences.
- This drawing and the copyrights and patents therein are the property of SurveyCloud Ltd and may not be used or reproduced without prior consent.

KEY

A	Approximate	LB	Litter Bin
AB	Air Brick	LP	Lamp Post
AC	Arch Crown Height	LTB	Lighting Bollard
Agg	Aggregate	MH	Manhole
AS	Arch Spring Height	MK	Marker Post
Asph	Asphalt	MPO	Metal Post
B	Bollard	NP	Name Plate
BB	Belisha Beacon	OH	Overhead Cable
BH	Borehole	OHIB	Overhead Building
Bpav	Brick Pavers	OHE	Overhead Electric Cable
BIG	Back Inlet Gully	OHT	Overhead Telecom Cable
BRW	Brick Wall	PB	Post Box
BS	Bench Seat	PM	Parking Meter
C	Ceiling Height	PO	Post
C/up	Ceiling Slopes Up	PWL	Parapet Wall Level
CF	False Ceiling Height	RB	Removable Bollard
CH	Ceiling Hatch	RE	Rodding Eye
CL	Cover Level	RG	Road Gully
Cob	Cobbles	RL	Ridge Level
Conc	Concrete	RPO	Reflective Post
Cpav	Crazy Paving	RS	Road Sign
Cpd	Cupboard	RWP	Rainwater Pipe
CPO	Concrete Post	SH	Window Sill to Head Height
CPS	Concrete Paving Slabs	SP	Soil Pipe
CWT	Cold Water Tank	SSL	Structural Slab Level
D	Depth (metres)	STN	Survey Station
DC	Drainage Channel	SVP	Soil Vent Pipe
DH	Door Head Height	SWIC	Surface Water IC
DPC	Damp Proof Course	TCB	Telephone Call Box
EL	Eaves Level	TFL	Top Fence Level
EP	Electric Pole	TL	Traffic Light
ER	Earth Rod	TLCB	Traffic Light Control Box
FB	Fixed Bollard	Tmac	Tarmac
FFL	Finished Floor Level	TP	Telegraph Pole
FH	Fire Hydrant	Tpav	Tactile Paving
FL	Flood Light	TPO	Timber Post
FP	Flag Pole	TWL	Top Wall Level
FPO	Fence Post	U	Unknown
FRL	Flat Roof Level	UB	Underside of Beam Height
FWIC	Foul Water IC	Ubox	Underside of Boxing Height
G	Gully	UD	Underside of Ducting Height
GM	Gas Meter	UP	Underside of Pipe Height
GP	Gas Pipe	US	Underside
GPO	Gate Post	UTL	Unable to Lift
H	Height (metres)	VP	Vent Pipe
HB	Hinged Bollard	WAC	Window Arch Crown Height
HWC	Hot Water Cylinder	WAS	Window Arch Spring Height
IC	Inspection Cover	WH	Window Head Height
ID	Invert Depth	WL	Water Level
IL	Invert Level	WM	Water Meter
JB	Junction Box	WP	Water Pipe
KIG	Kerb Inlet Gully	WS	Window Sill Height
L	Level	WSV	Water Stop Valve

B	Revision	planning amendments	03/04/2019
	Comment		Date
Client			
MR & MRS PARKER			
Project			
68 CHARLESWORTH DRIVE WATERLOOVILLE HAMPSHIRE PO7 6AZ			
Title			
PROPOSED ATTIC FLOOR PLAN			
Drawing Number		Revision	Status
SD18529-P1.2		B	PLANNING
Scale	Sheet Size	Drawn By	Date
AS SHOWN	A3	DW	FEBRUARY 2019
			
10 Church Road Steep Hampshire GU32 2DW		Phone 07900 808 808 Office 01730 262 485 mail@surveycloud.co.uk www.surveycloud.co.uk	