


KEY:	
bt	British Telecom
cb	Control Box
cl	Cable Level
ctv	Cable Television
dk	Drop Kerb
el	Electric
ep	Electricity Pole
fh	Fire Hydrant
gu	Gully
gsv	Gas Stop Valve
ht	Height
ic	Inspection Cover
il	Invert Level
lp	Lamp Post
mkr	Marker
o/h	Overhead
pb	Post Box
pxg	Pan Crossing
np	Name Plate
rs	Road Sign
sv	Stop Valve
tb	Telephone Box
tl	Traffic Light
tt	Top of Tree
th	Threshold
tw	Top of Wall
utl	Unable to Lift
vp	Vent pipe
wm	Water Meter
wsv	Water Stop Valve


NOTES:
LEVELS RELATE TO OS DATUM
TREE SPECIES SHOULD BE VERIFIED WHERE OF
CRITICAL IMPORTANCE
THE ARCHITECT SHALL SATISFY HIMSELF THAT ALL TREES
LIKELY TO AFFECT HIS DESIGN HAVE BEEN SHOWN
WITH CORRECTION OF HANDLES SHOULD BE VERIFIED
WHERE OF CRITICAL IMPORTANCE USING CCV
PIPE SIZES & INVERTS DETERMINED WITHOUT
ENTRY INTO MANHOLE

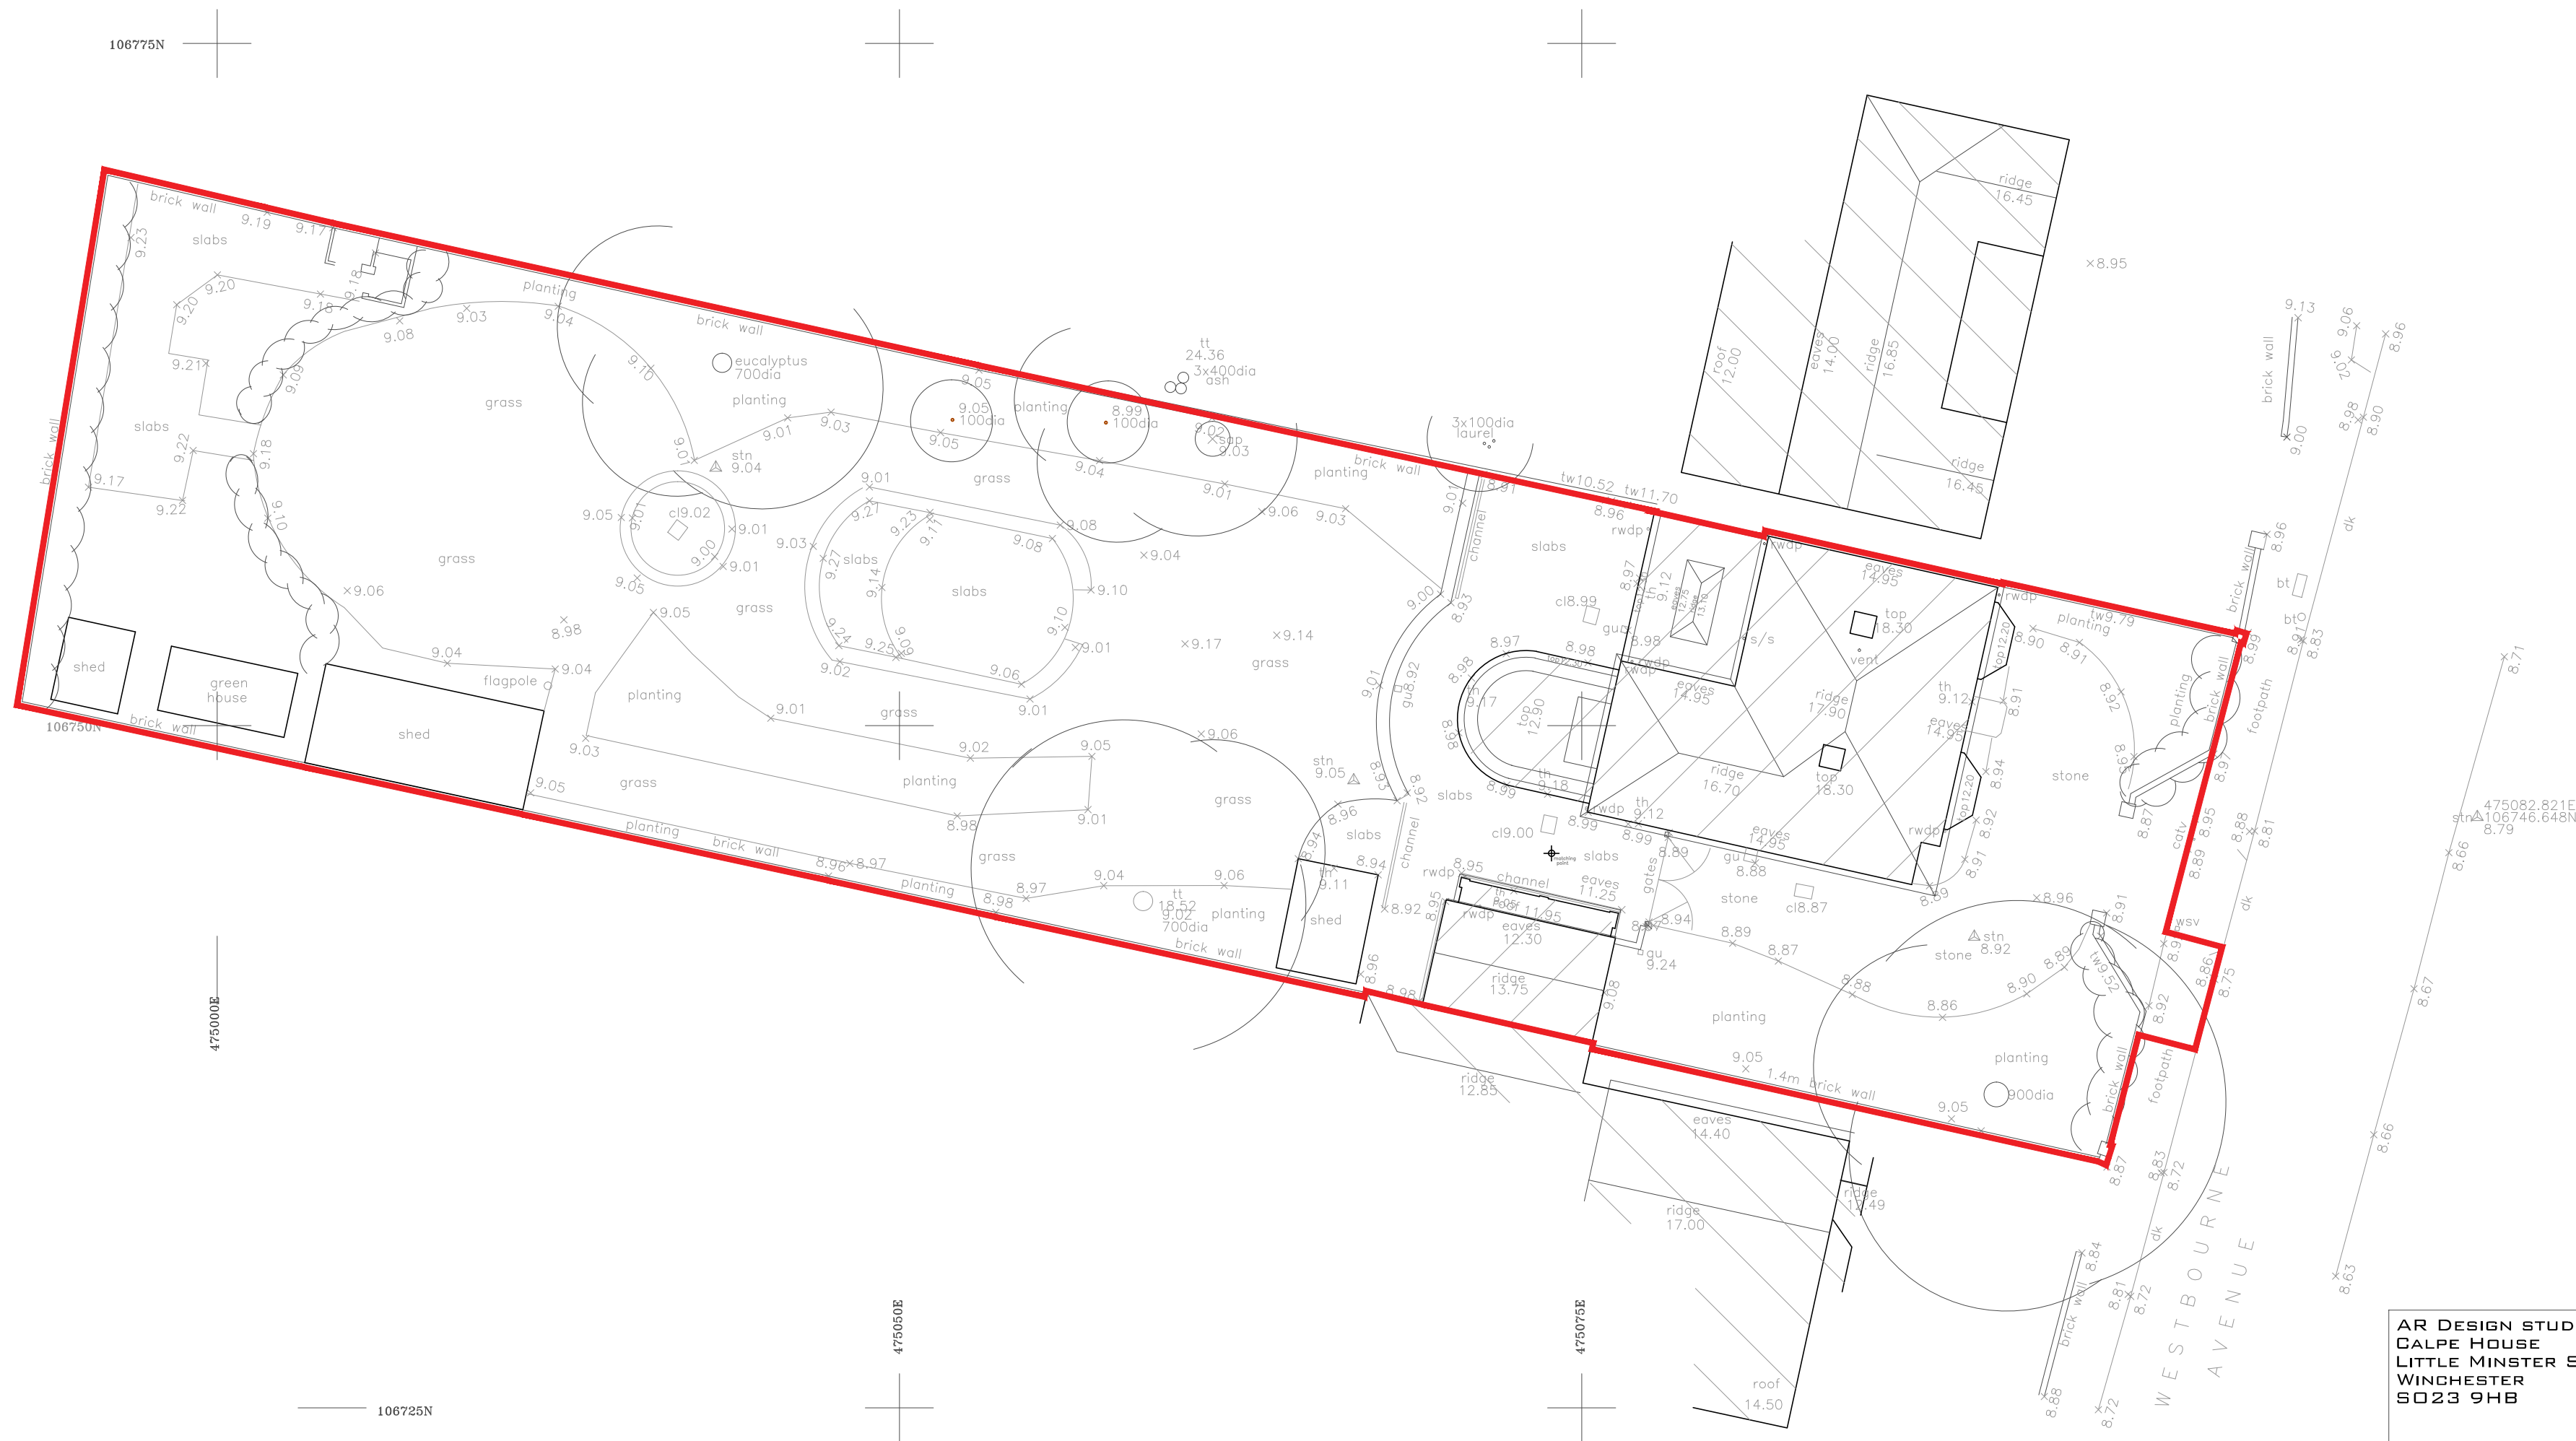

AR DESIGN STUDIO LTD
CALPE HOUSE
LITTLE MINSTER ST
WINCHESTER
SO23 9HB

T. 01962 864545
E. INFO@ARDESIGNSTUDIO.CO.UK
WWW.ARDESIGNSTUDIO.CO.UK

Copyright: All rights reserved. This drawing and design must not be reproduced without permission. Dimensions are in millimetres unless specified. Only written dimensions to be worked from. Do not scale from this drawing.				
Job title Westbourne Avenue				
Drawing title Existing Site Plan				
Status Lawful Development				
Drawn by AB	Checked by -	Date 11/18	Scale at A3 -	Scale at A2 1:200
Job No. 745	Dwg No. P002		Revision -	

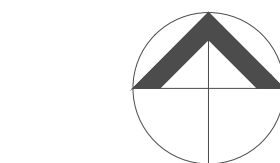

Draft

