


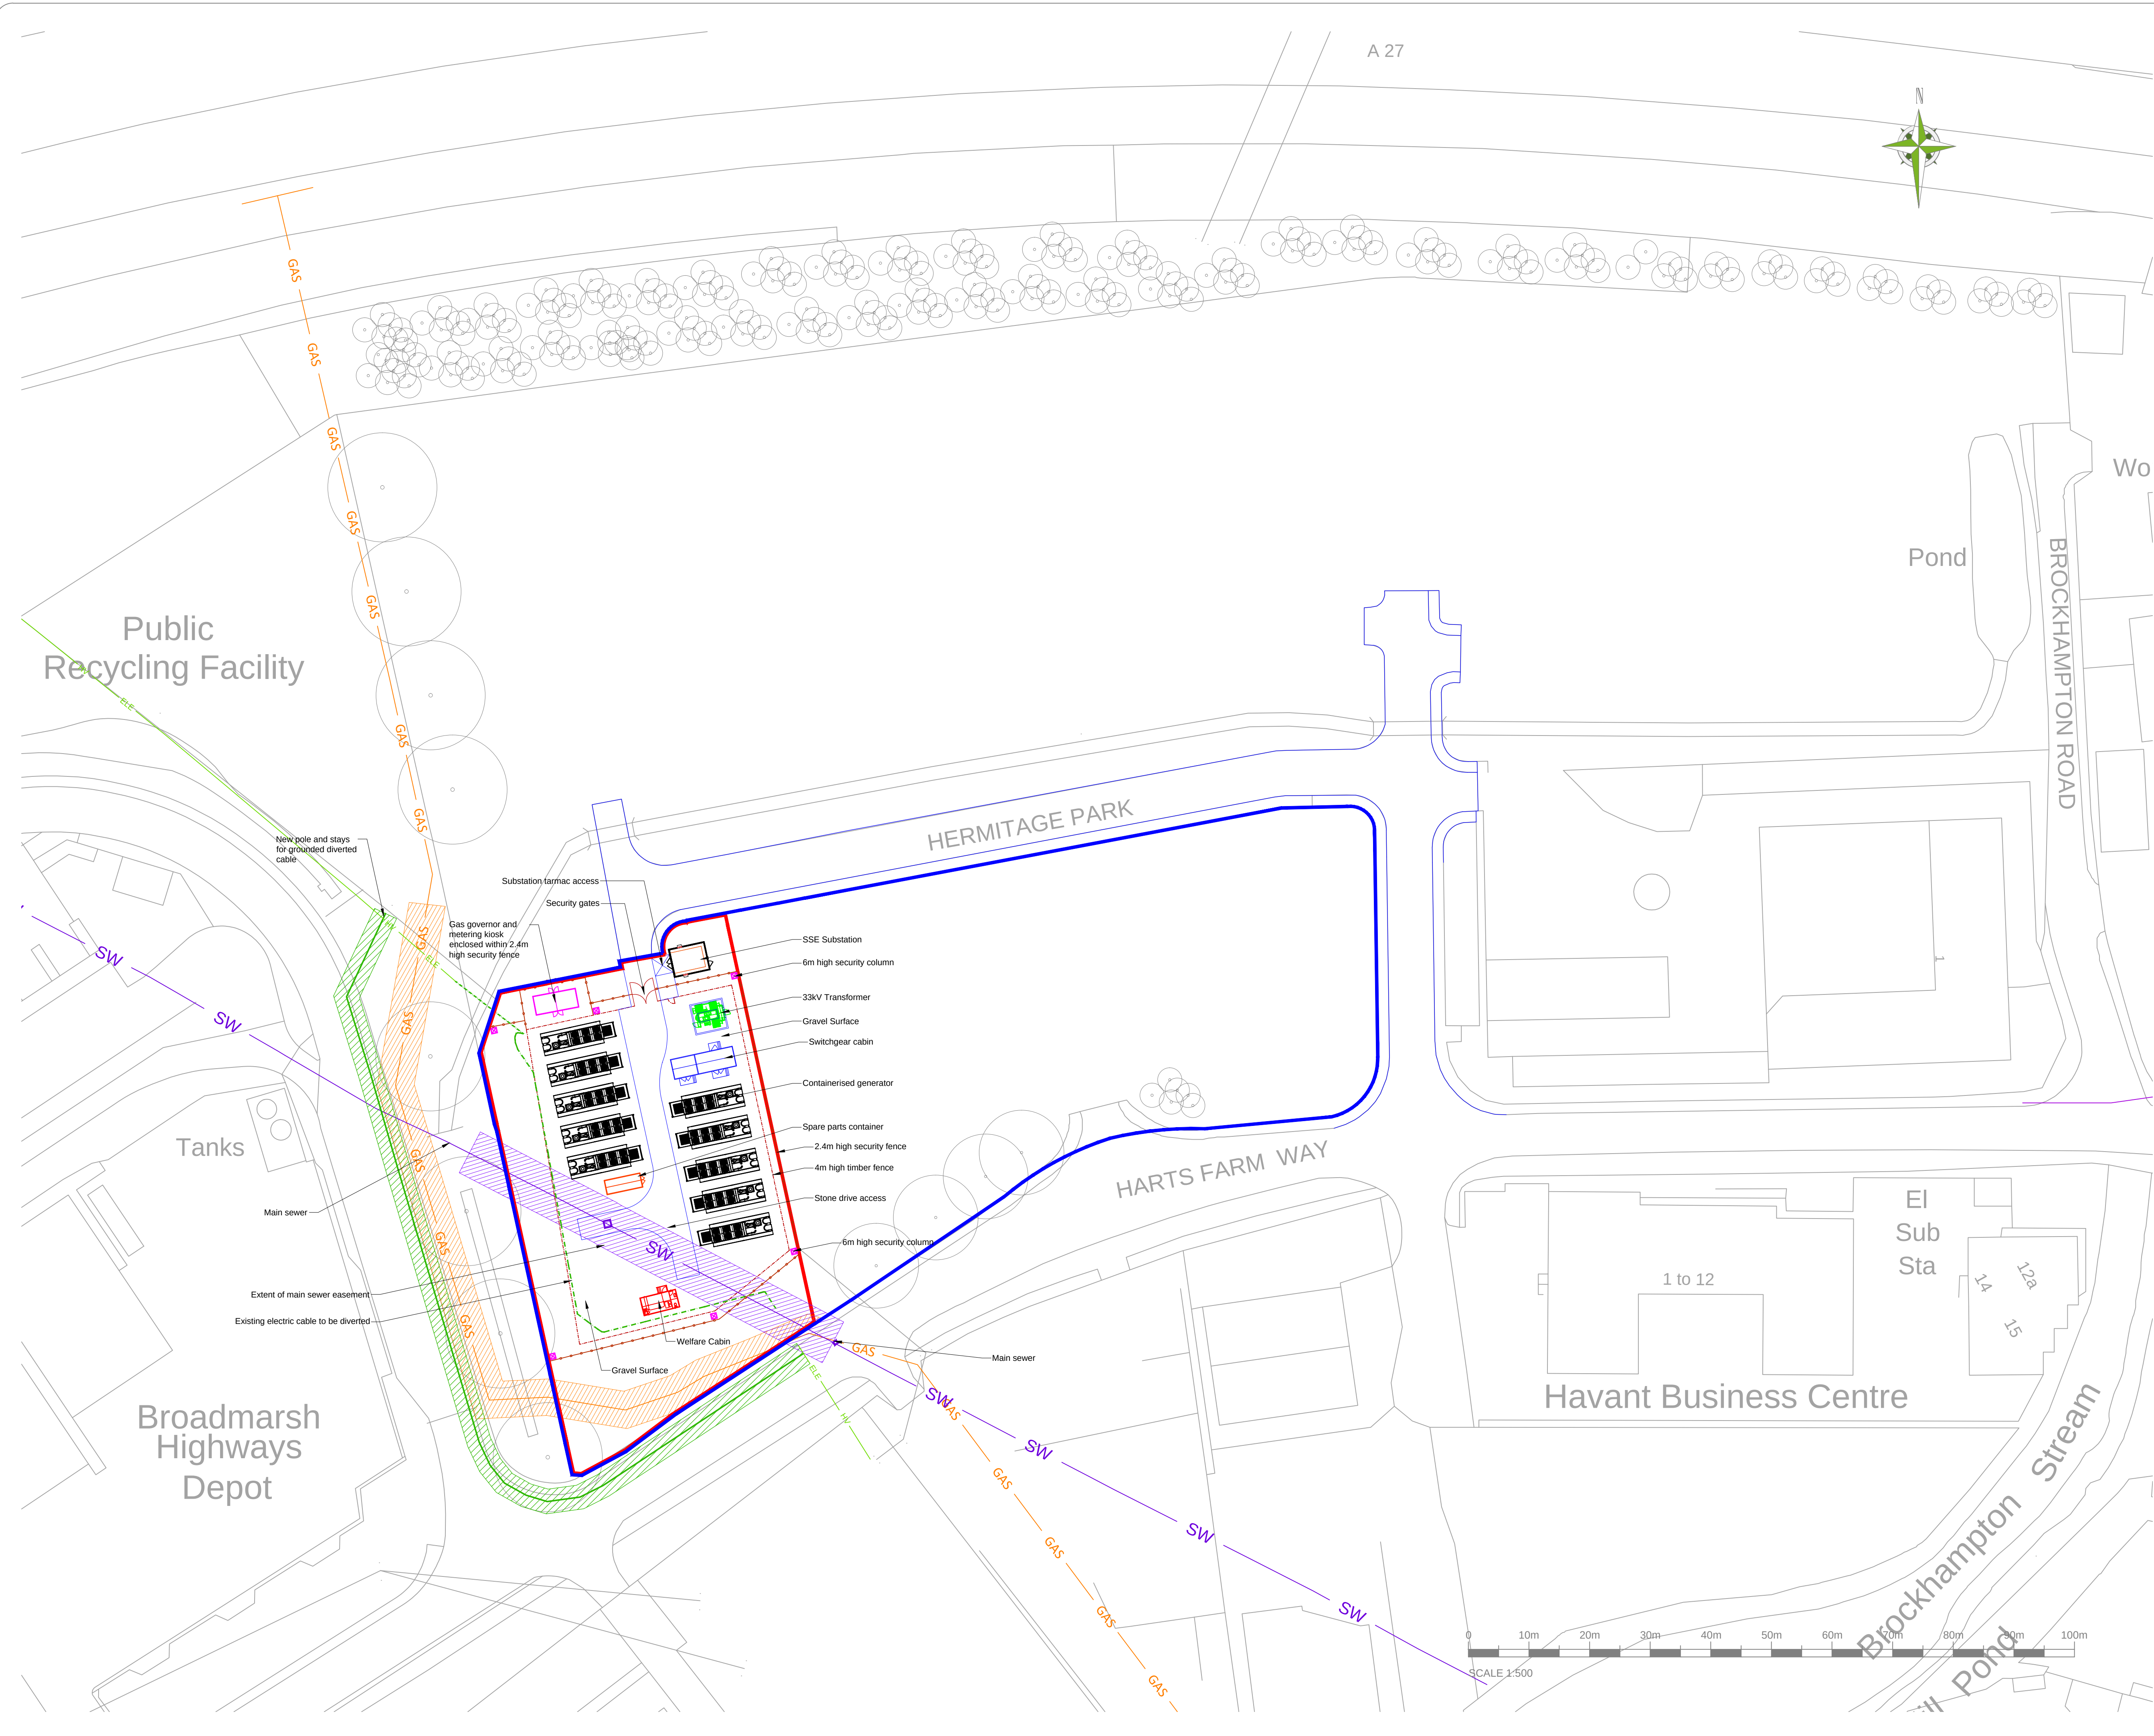

PLANNING PLAN

LEGEND:

- SITE INFRASTRUCTURE:**
- LANDLORDS PROPERTY
 - PROPOSED SITE
 - DRIVE ACCESS
 - PERIMETER FENCELINE
 - INNER FENCELINE

- DNO SUBSTATION
- SECURITY COLUMN
- GAS GOVERNORS
- SPARE PARTS ROOM
- SWITCHGEAR
- SECURITY GATE
- WELFARE CABIN
- GENERATOR

- GAS—GAS— EXISTING HP GAS ROUTE —GAS—GAS—
- HIGH PRESSURE GAS EASEMENT 6m
- SW—SW— EXISTING SEWER TO BE RETAINED —SW—SW—
- SEWER EASEMENT - APP 7.6m
- EXISTING ELECTRIC CABLE TO BE DIVERTED
- PROPOSED DIVERTED ELECTRIC CABLE
- EASEMENT TO PROPOSED DIVERTED ELECTRIC CABLE 4m

A	Engines type altered and layout configured accordingly. Sewer retained. Transformers removed a single 33kV transformer added. SSE substation altered and fence along the compound access slightly amended	05.12.18
rev	revision notes	date
REVISIONS		

Planning

ALL DIMENSIONS TO BE CHECKED ON SITE
WORK TO FIGURED DIMENSIONS ONLY
REPORT DISCREPANCIES TO THE CFP
AT ONCE BEFORE PROCEEDING
COPYRIGHT ACT APPLIES



GreenFrog Power

Green Frog Power Ltd, Gorseley Lane, Colehill, Birmingham, B46 1JA
Tel: 01675 437777

Project Title:
GENERATION COMPOUND
HARTS FARM WAY
PO9 1HS

Drawing Title:

PROPOSED SITE PLAN

Scale @A1: 1:500
Drawn: TB
Drawing No: 4000_GF_DR_PP_103

Date: Apr 2017
Checked: DS
Rev: A