


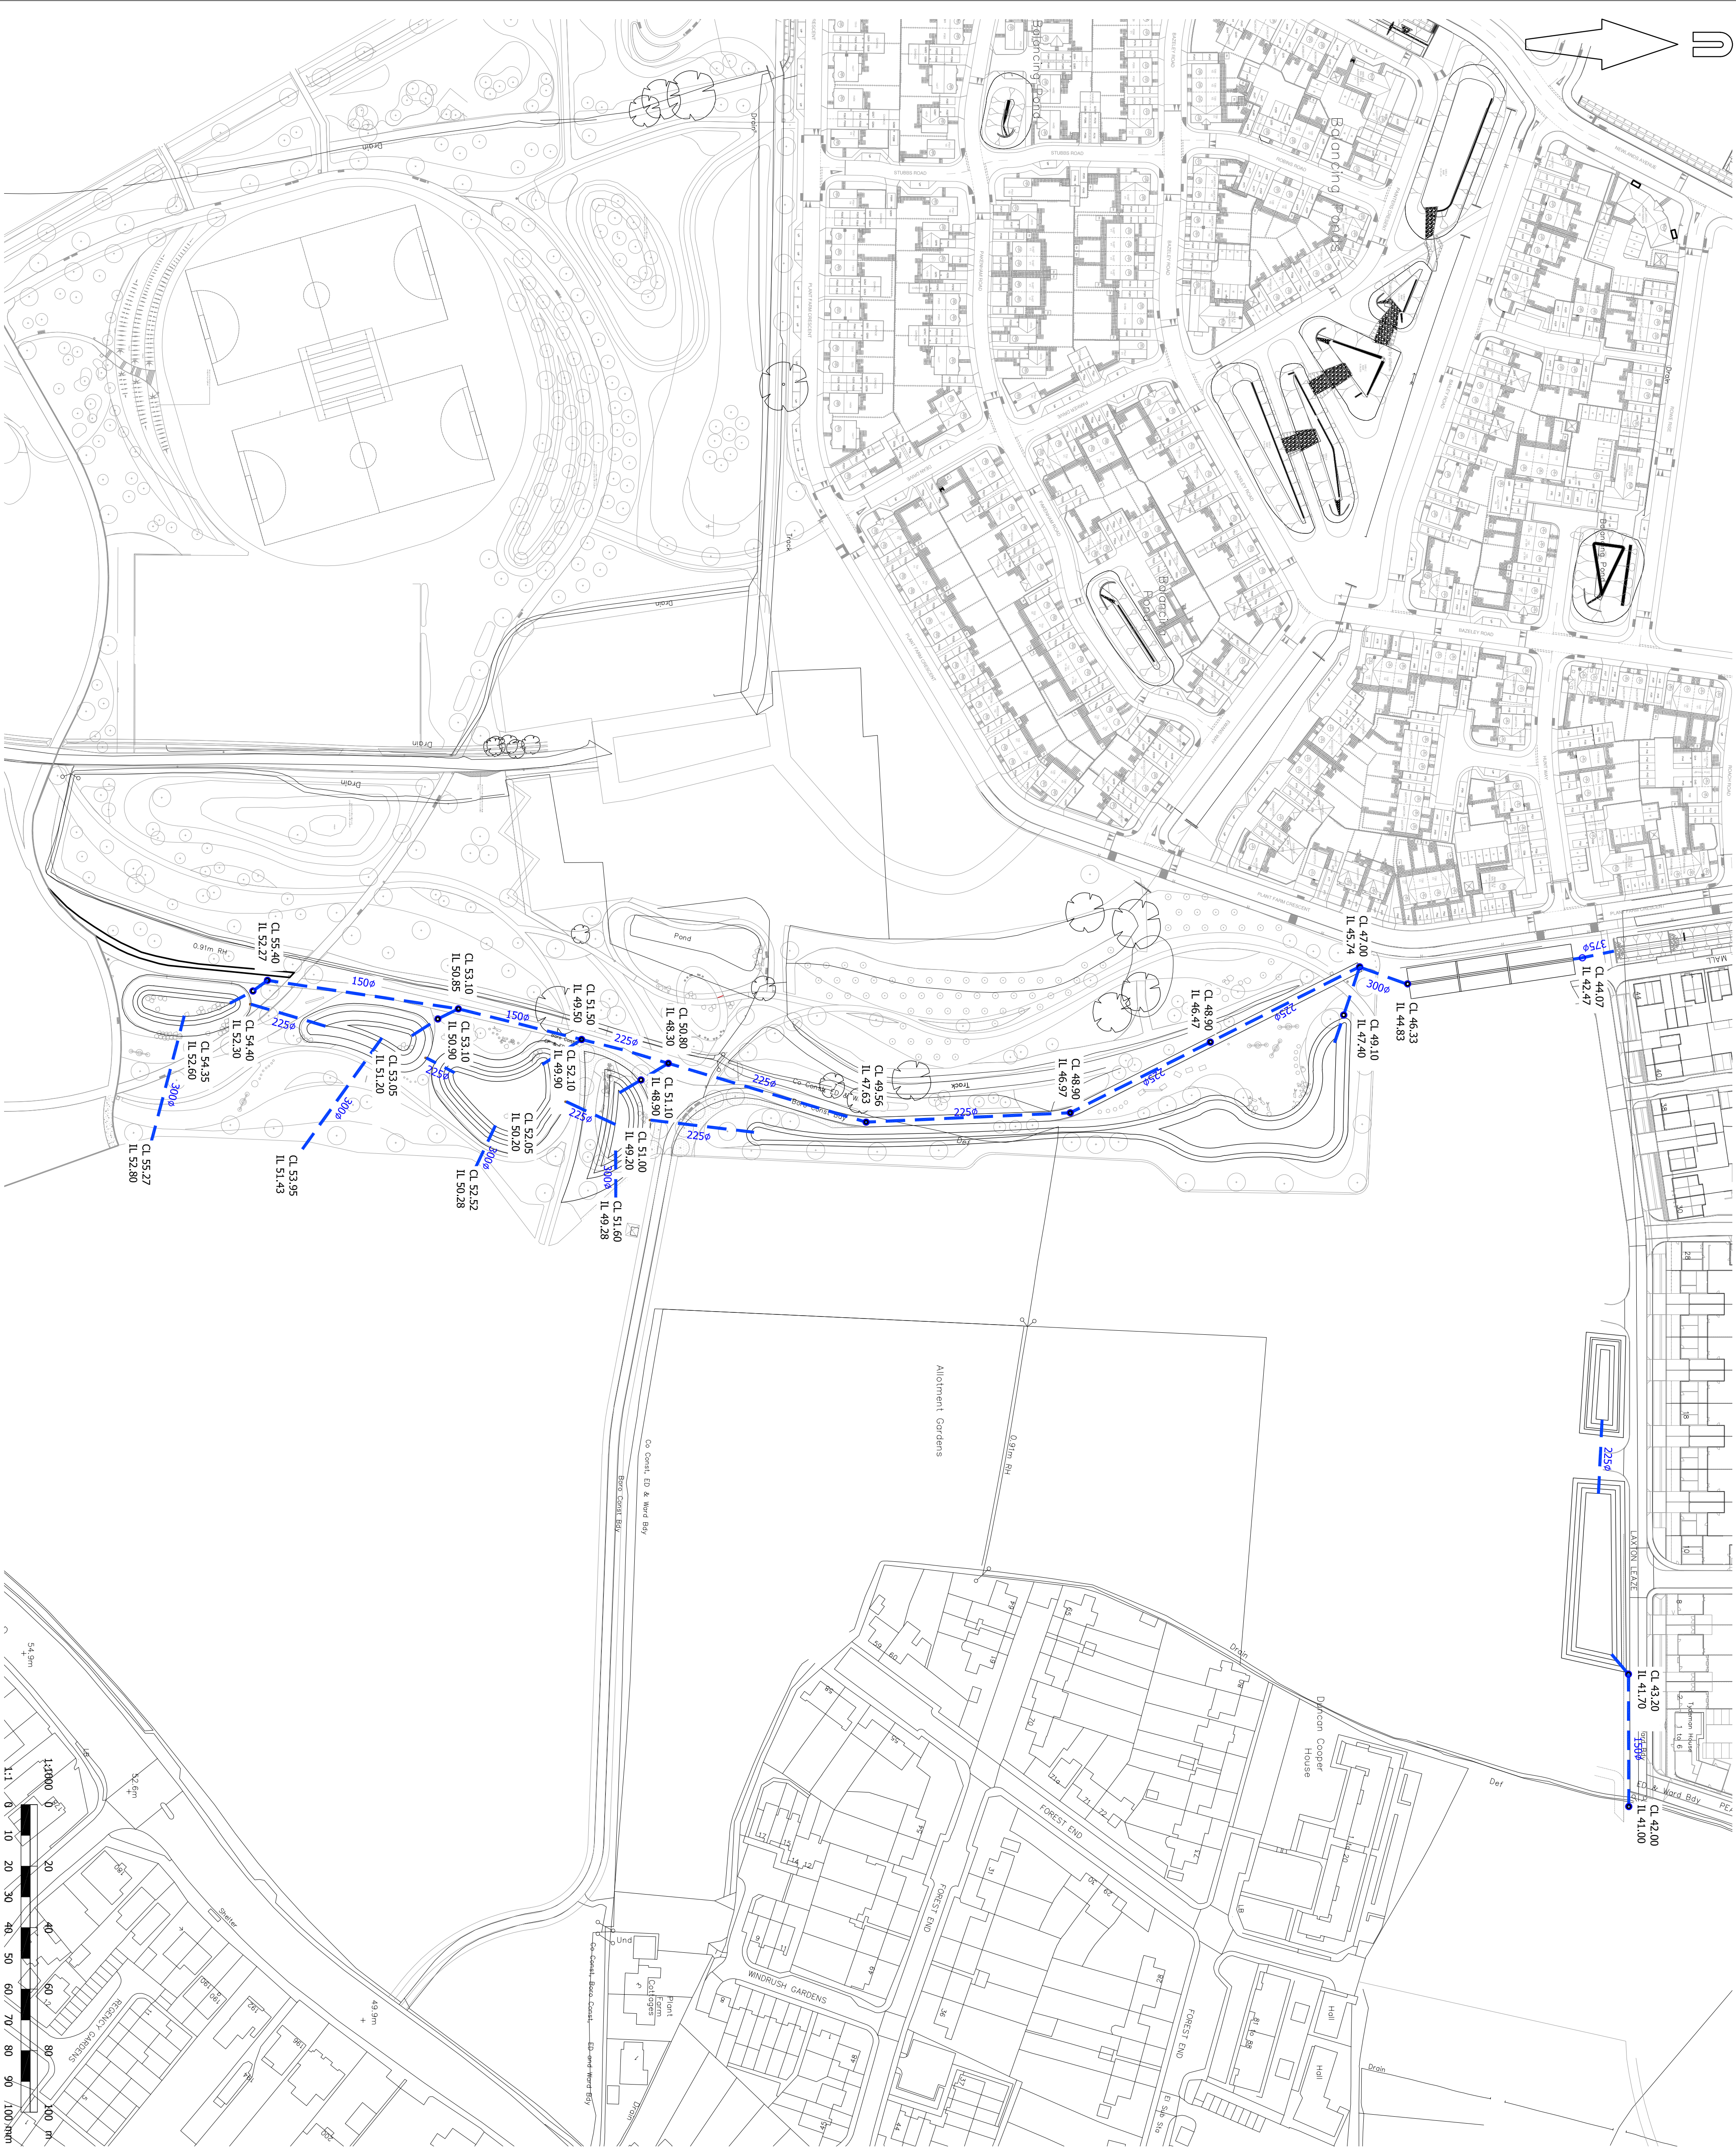

© Mayer Brown Limited Copyright. The drawings, information and data recorded in this document ("this information") is the property of Mayer Brown. This document may not be used, copied or reproduced in whole or part for any purpose other than which it was prepared. Mayer Brown and its affiliates accept no responsibility for any loss, liability, duty and accepts no responsibility to any third party who may use or rely upon this document or the information.

A1 ORIGINAL

© Crown Copyright and database rights 2019 Ordnance Survey 0100031673

Key	
	Proposed Manhole
	Proposed Surface Water Pipes




Berewood

HAMPSHIRE

FOR APPROVAL
NOT FOR CONSTRUCTION

rev	amendment	checked	date

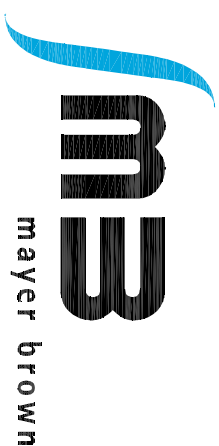

Mayer Brown Limited, Lion House
Oriental Road, Basing, Surrey, GU24 0AB
Telephone: 01430 823000 Fax: 01430 823001
www.mayerbrown.co.uk

granger plc

project
BEREWOOD, WATERLOOVILLE
PHASE 8

scale 1:1000 drawn by KDB checked by RHA

date January 2019 cad file DR_01.dwg

title
PHASE 3B & PHASE 8
DRAINAGE LAYOUT

drawing number GTWVILLE_P8/DR/01 rev.