

FOULWATER MANHOLE SCHEDULE				
Manhole	Manhole Type	Invert Level	Cover Level	Depth (m)
F1	450 Ø IC (PP)	54.50	55.30	0.80
F2	450 Ø IC (PP)	54.41	55.15	0.74
EX	Existing Manhole (Invert Level)	52.89	53.78	0.89


FOULWATER DRAIN / SEWER SCHEDULE				
Manhole References	Pipe s	Pipe Material	Pipe Length (m)	Pipe Gradient
F1 - F2	100	PVCu	3.70	1 : 40
F2 - EX	100	PVCu	12.98	1 : 9

SURFACE WATER MANHOLE SCHEDULE				
Manhole	Manhole Type	Invert Level	Cover Level	Depth (m)
YG1	Yard Gully (PP)	54.90	92.65	37.75
SA1	Soakaway - Aquacell	54.63	92.80	38.17
S1	300 Ø IC (PP)	54.70	55.30	0.60
SA1	Soakaway - Aquacell	54.63	54.95	0.32
RWP1	Yard Gully (PP)	54.85	55.15	0.30
SA2	Soakaway - Aquacell	54.05	54.35	0.30

SURFACE WATER DRAIN / SEWER SCHEDULE				
Manhole References	Pipe s	Pipe Material	Pipe Length (m)	Pipe Gradient
YG1 - SA1	100	PVCu	4.10	1 : 15
S1 - SA1	100	PVCu	5.89	1 : 80
RWP1 - SA2	100	PVCu	4.10	1 : 5

DRAINAGE KEY

SYMBOL	DESCRIPTION
	Stormwater Inspection Chamber
	Stormwater Soakaway
	Proposed Rainwater Pipe
	Rainwater Pipe
	Stormwater Yard Gully
	Existing Storm Inspection Chamber
	Existing Storm Water Drain Run
	Existing Storm Water Manhole
	Foul Water Inspection Chamber
	Foul Water Soil Vent Pipe
	Foul Water Sink Waste
	Foul Water Sub Stack
	Existing Foul Inspection Chamber
	Existing Foul Water Drain Run
	Existing Foul Water Manhole

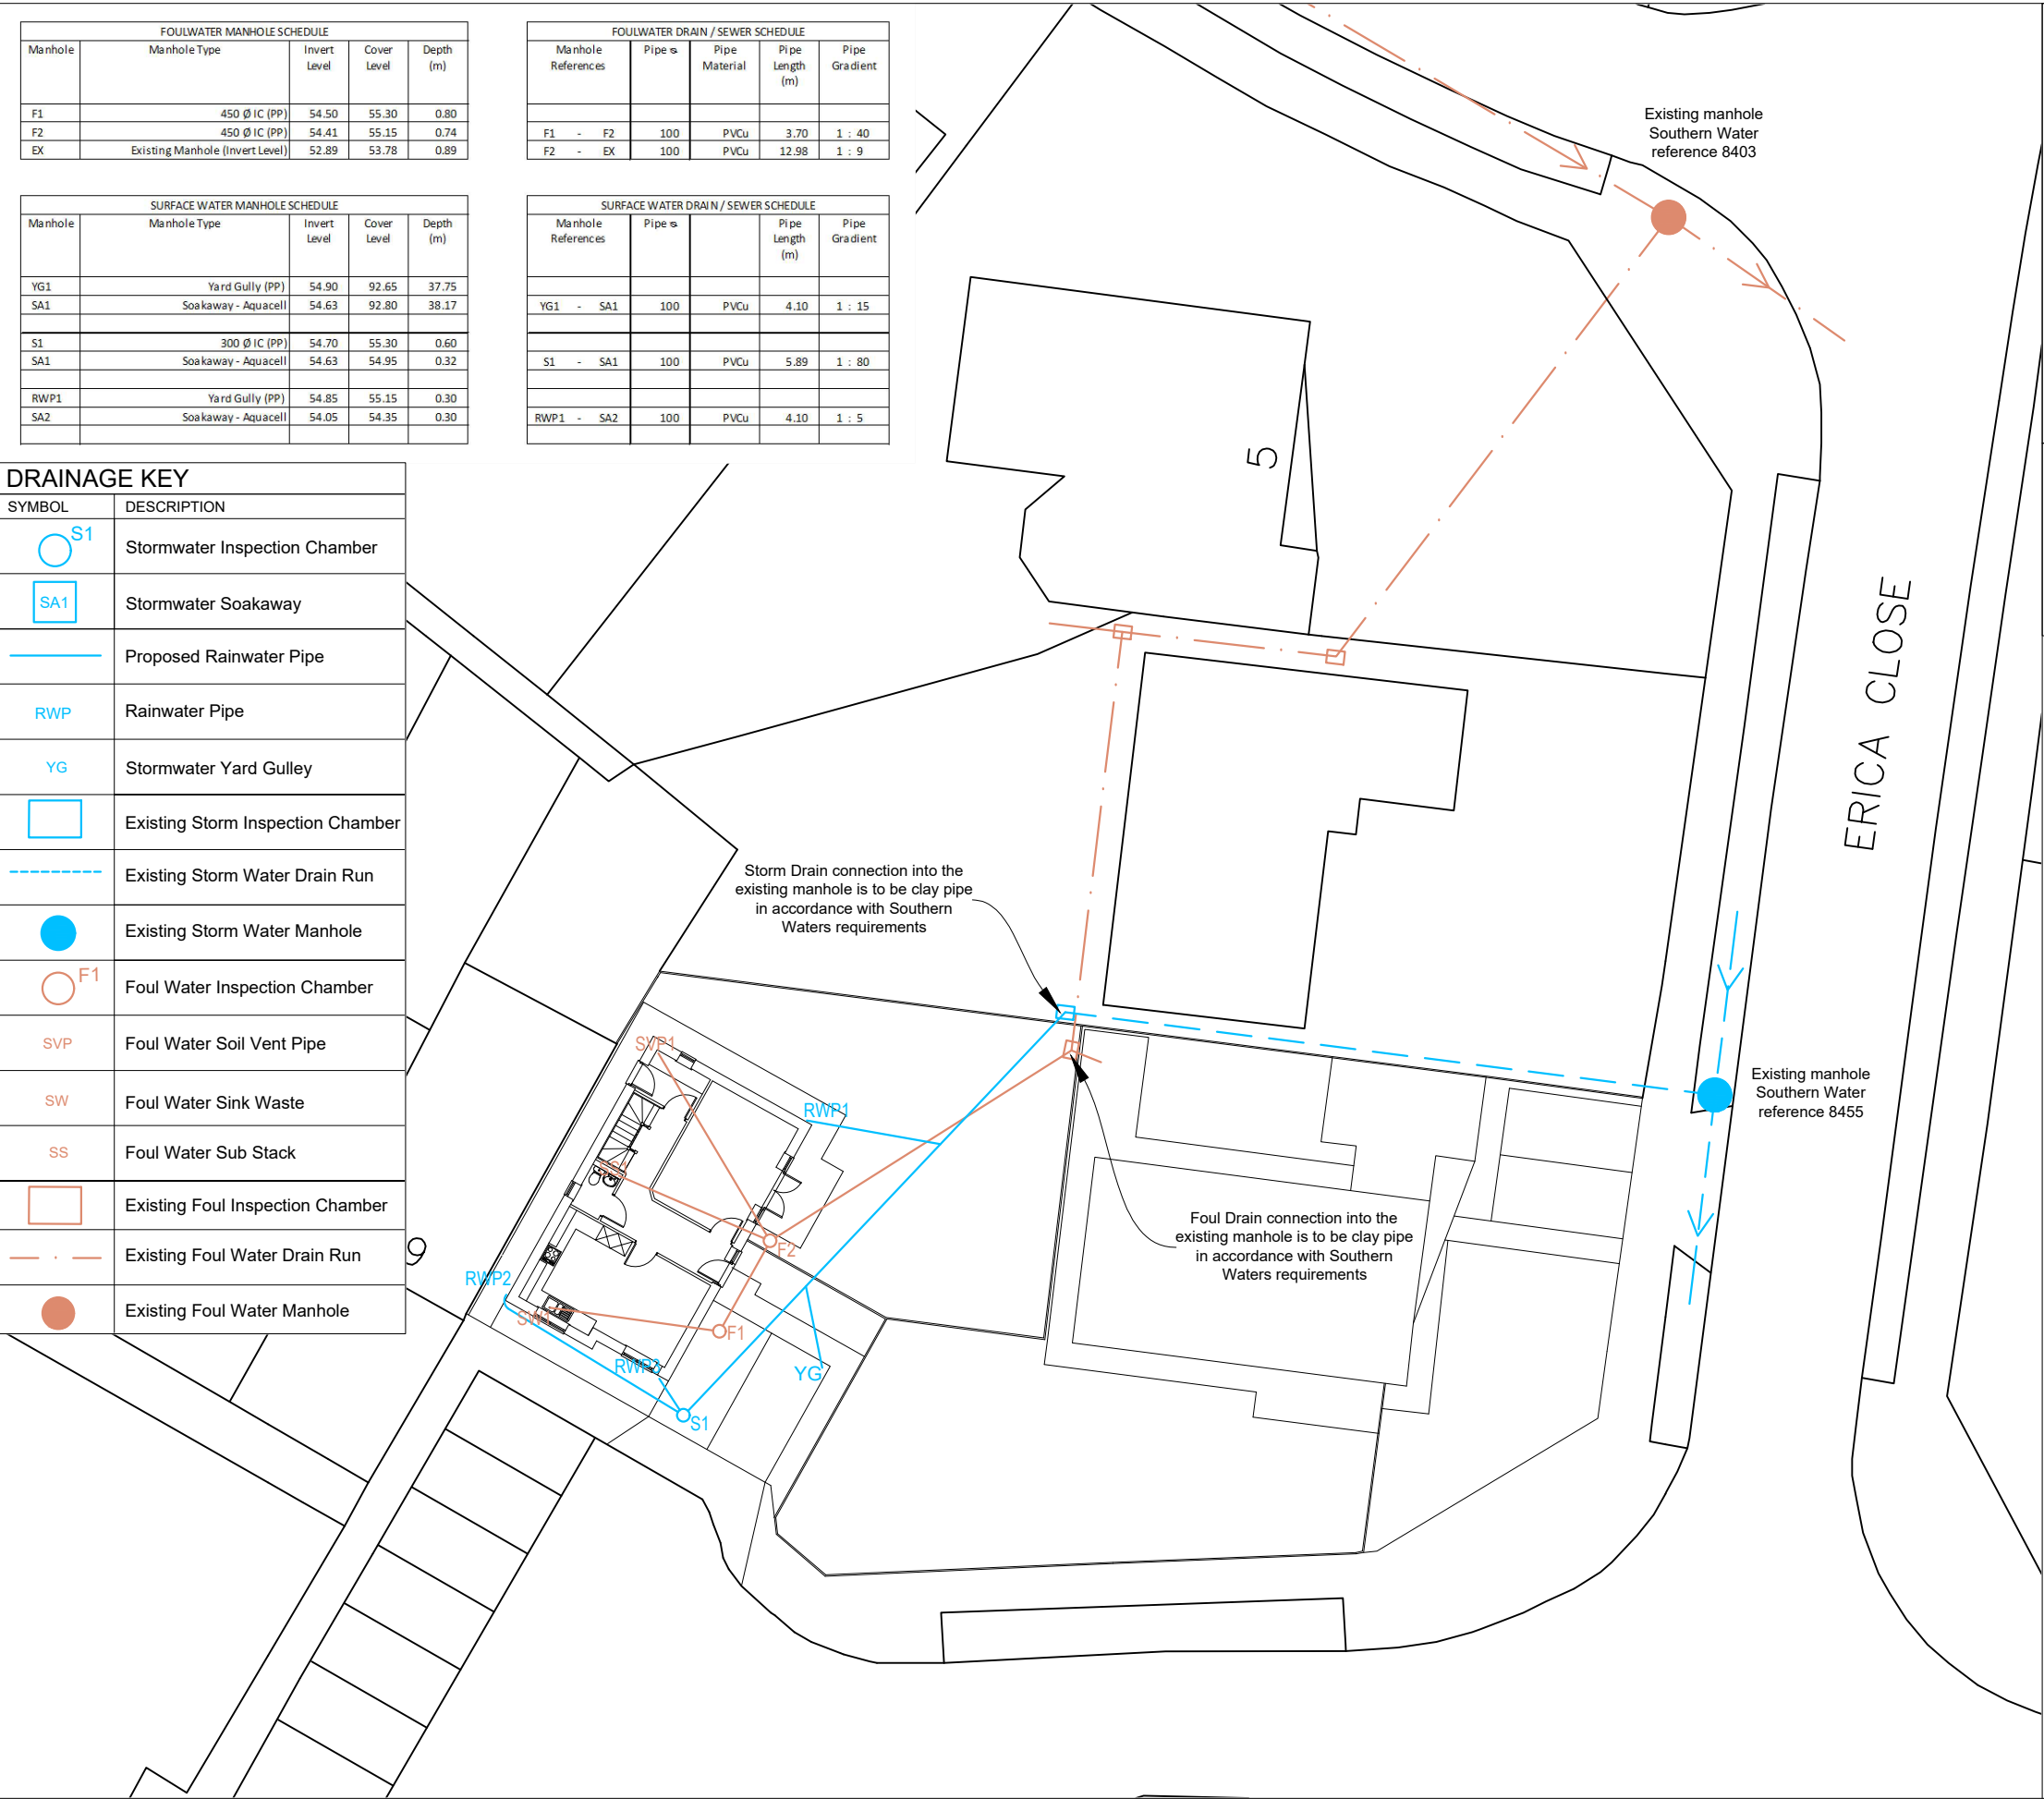

WARNING TO HOUSE PURCHASERS - Property Misdescriptions Act 1991

Buyers are warned that this is a working drawing and is not intended to be treated as descriptive material describing, in relation to any particular property or development, any of the Specified Matters prescribed by any Order made under the above Act. The contents of this drawing may be subject to change at any time and alterations and variations can occur during the process of the works without revision of the drawing.

Consequently the layout, form, content and dimensions of the finished construction may differ materially from those shown. Nor do the contents of this drawing constitute a contract, part of any contract or a warranty.

THIS DRAWING IS TO BE READ IN CONJUNCTION WITH THE CLIENTS STANDARD SPECIFICATION AND STRUCTURAL ENGINEERS DESIGN AND DETAILS. DO NOT SCALE OFF THIS DRAWING. USE FIGURED DIMENSIONS ONLY. ALL DIMENSIONAL DISCREPANCIES TO BE BROUGHT TO THE IMMEDIATE ATTENTION OF THE CLIENT.

Scale 1:250



CLIENT		
Sovereign Land Developments Ltd		
SITE		
Land to the rear of 1 Erica Close, Cowplain		
TITLE		
Drainage Plan - Including connection points		
SCALE 1:250 (A3)	DRAWING NO. KALO.0142.406	REVISION
DATE June 18		
DRAWN PDB	CHECK	
Kalotec Limited, Cams Hall, Fareham, Hampshire, PO16 8AB Telephone: 01329 227 424 Email: info@kalotec.co.uk Website: www.kalotec.co.uk		
COPYRIGHT © KALOTEC LIMITED		