


NOTE:
BLUE LINE REPRESENTS
UNDERGROUND WATER PIPES

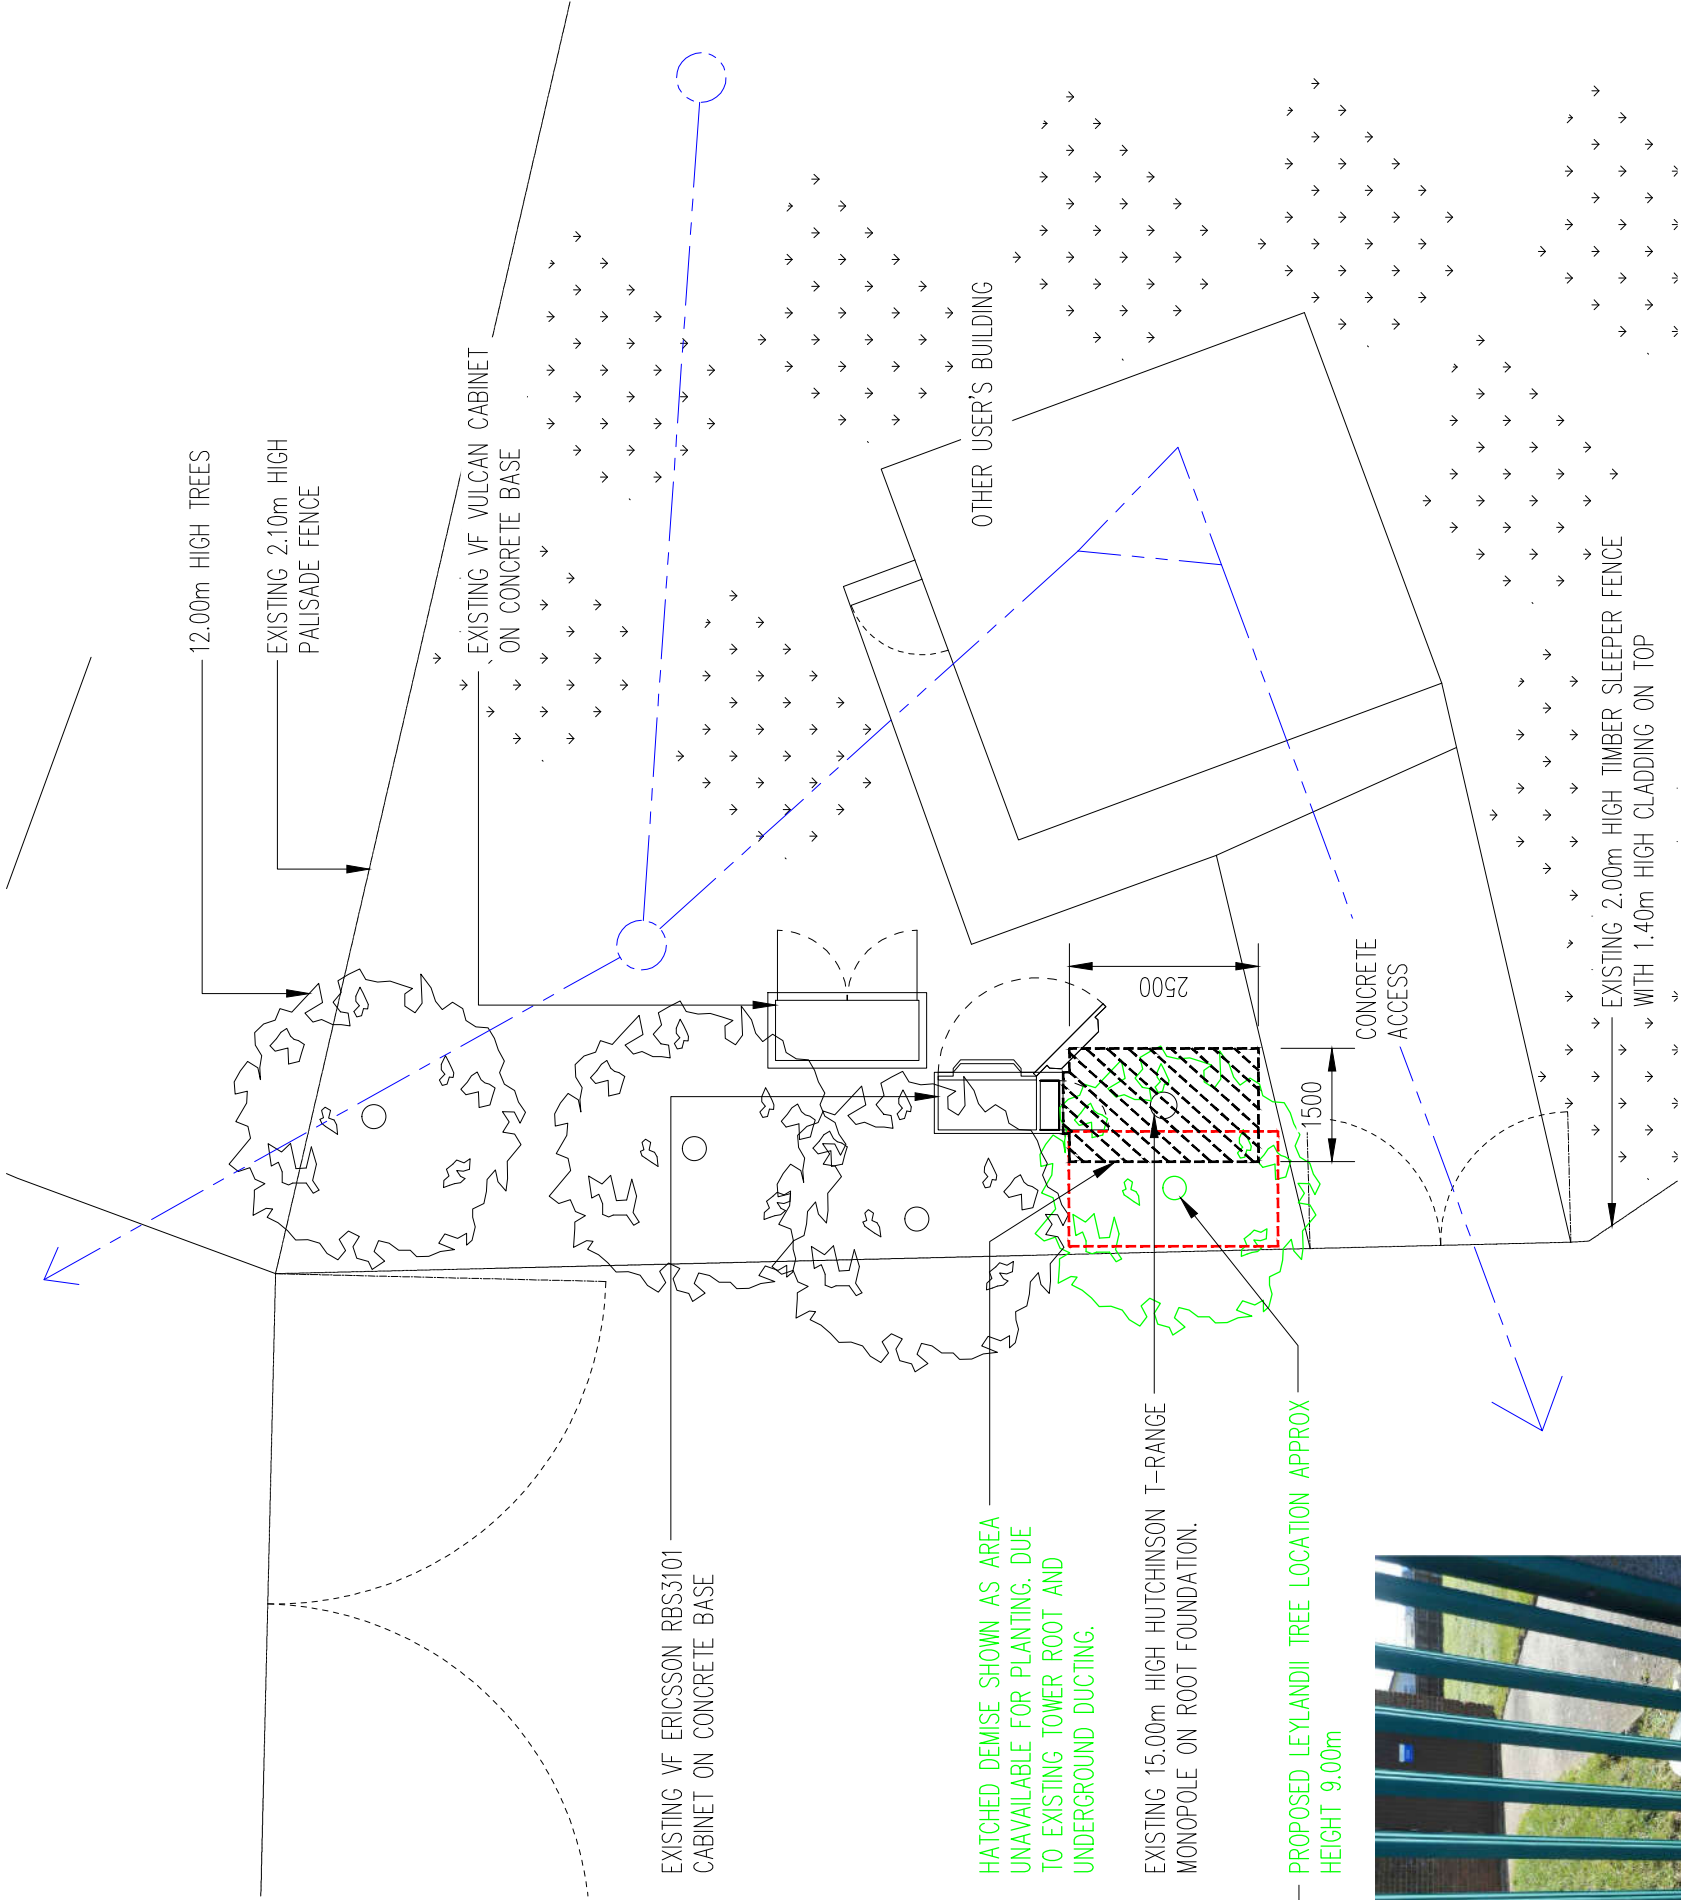

SITE PLAN
SCALE 1:100

C	DEMISE SHOWN FOR AREA NOT AVAILABLE FOR PLANTING	20.12.18	PK	DA
B	PROPOSED TREE HEIGHT REVISED	08.10.18	RY	DA
A	PROPOSED TREE DETAILS REVISED. SITE LOCATION ADDED.	05.10.18	PK	DA
-	SKETCH ISSUE	03.11.17	PK	GH
No.	Revision	Date	By	ckd



CTIL

Site Name & Address:
FISHERY LANE, SOUTHERN WATER
COMPOUND ADJACENT TO TIP, SOUTH
HAYLING, PO11 9NF

Title:
TELECOMMUNICATIONS
GREENFIELD UPGRADE
SITE PLAN

Purpose of Issue:
SITE LOCATION

Drawing No:
130542 - 02

CTIL No:	VF No:	TEF No:
130542	46549	45932
Issue:	Scale:	Ch'd:
C	AS STATED	GH
Dwn:	Date:	Date:
PK	03.11.17	03.11.17
App:	GH	GH