


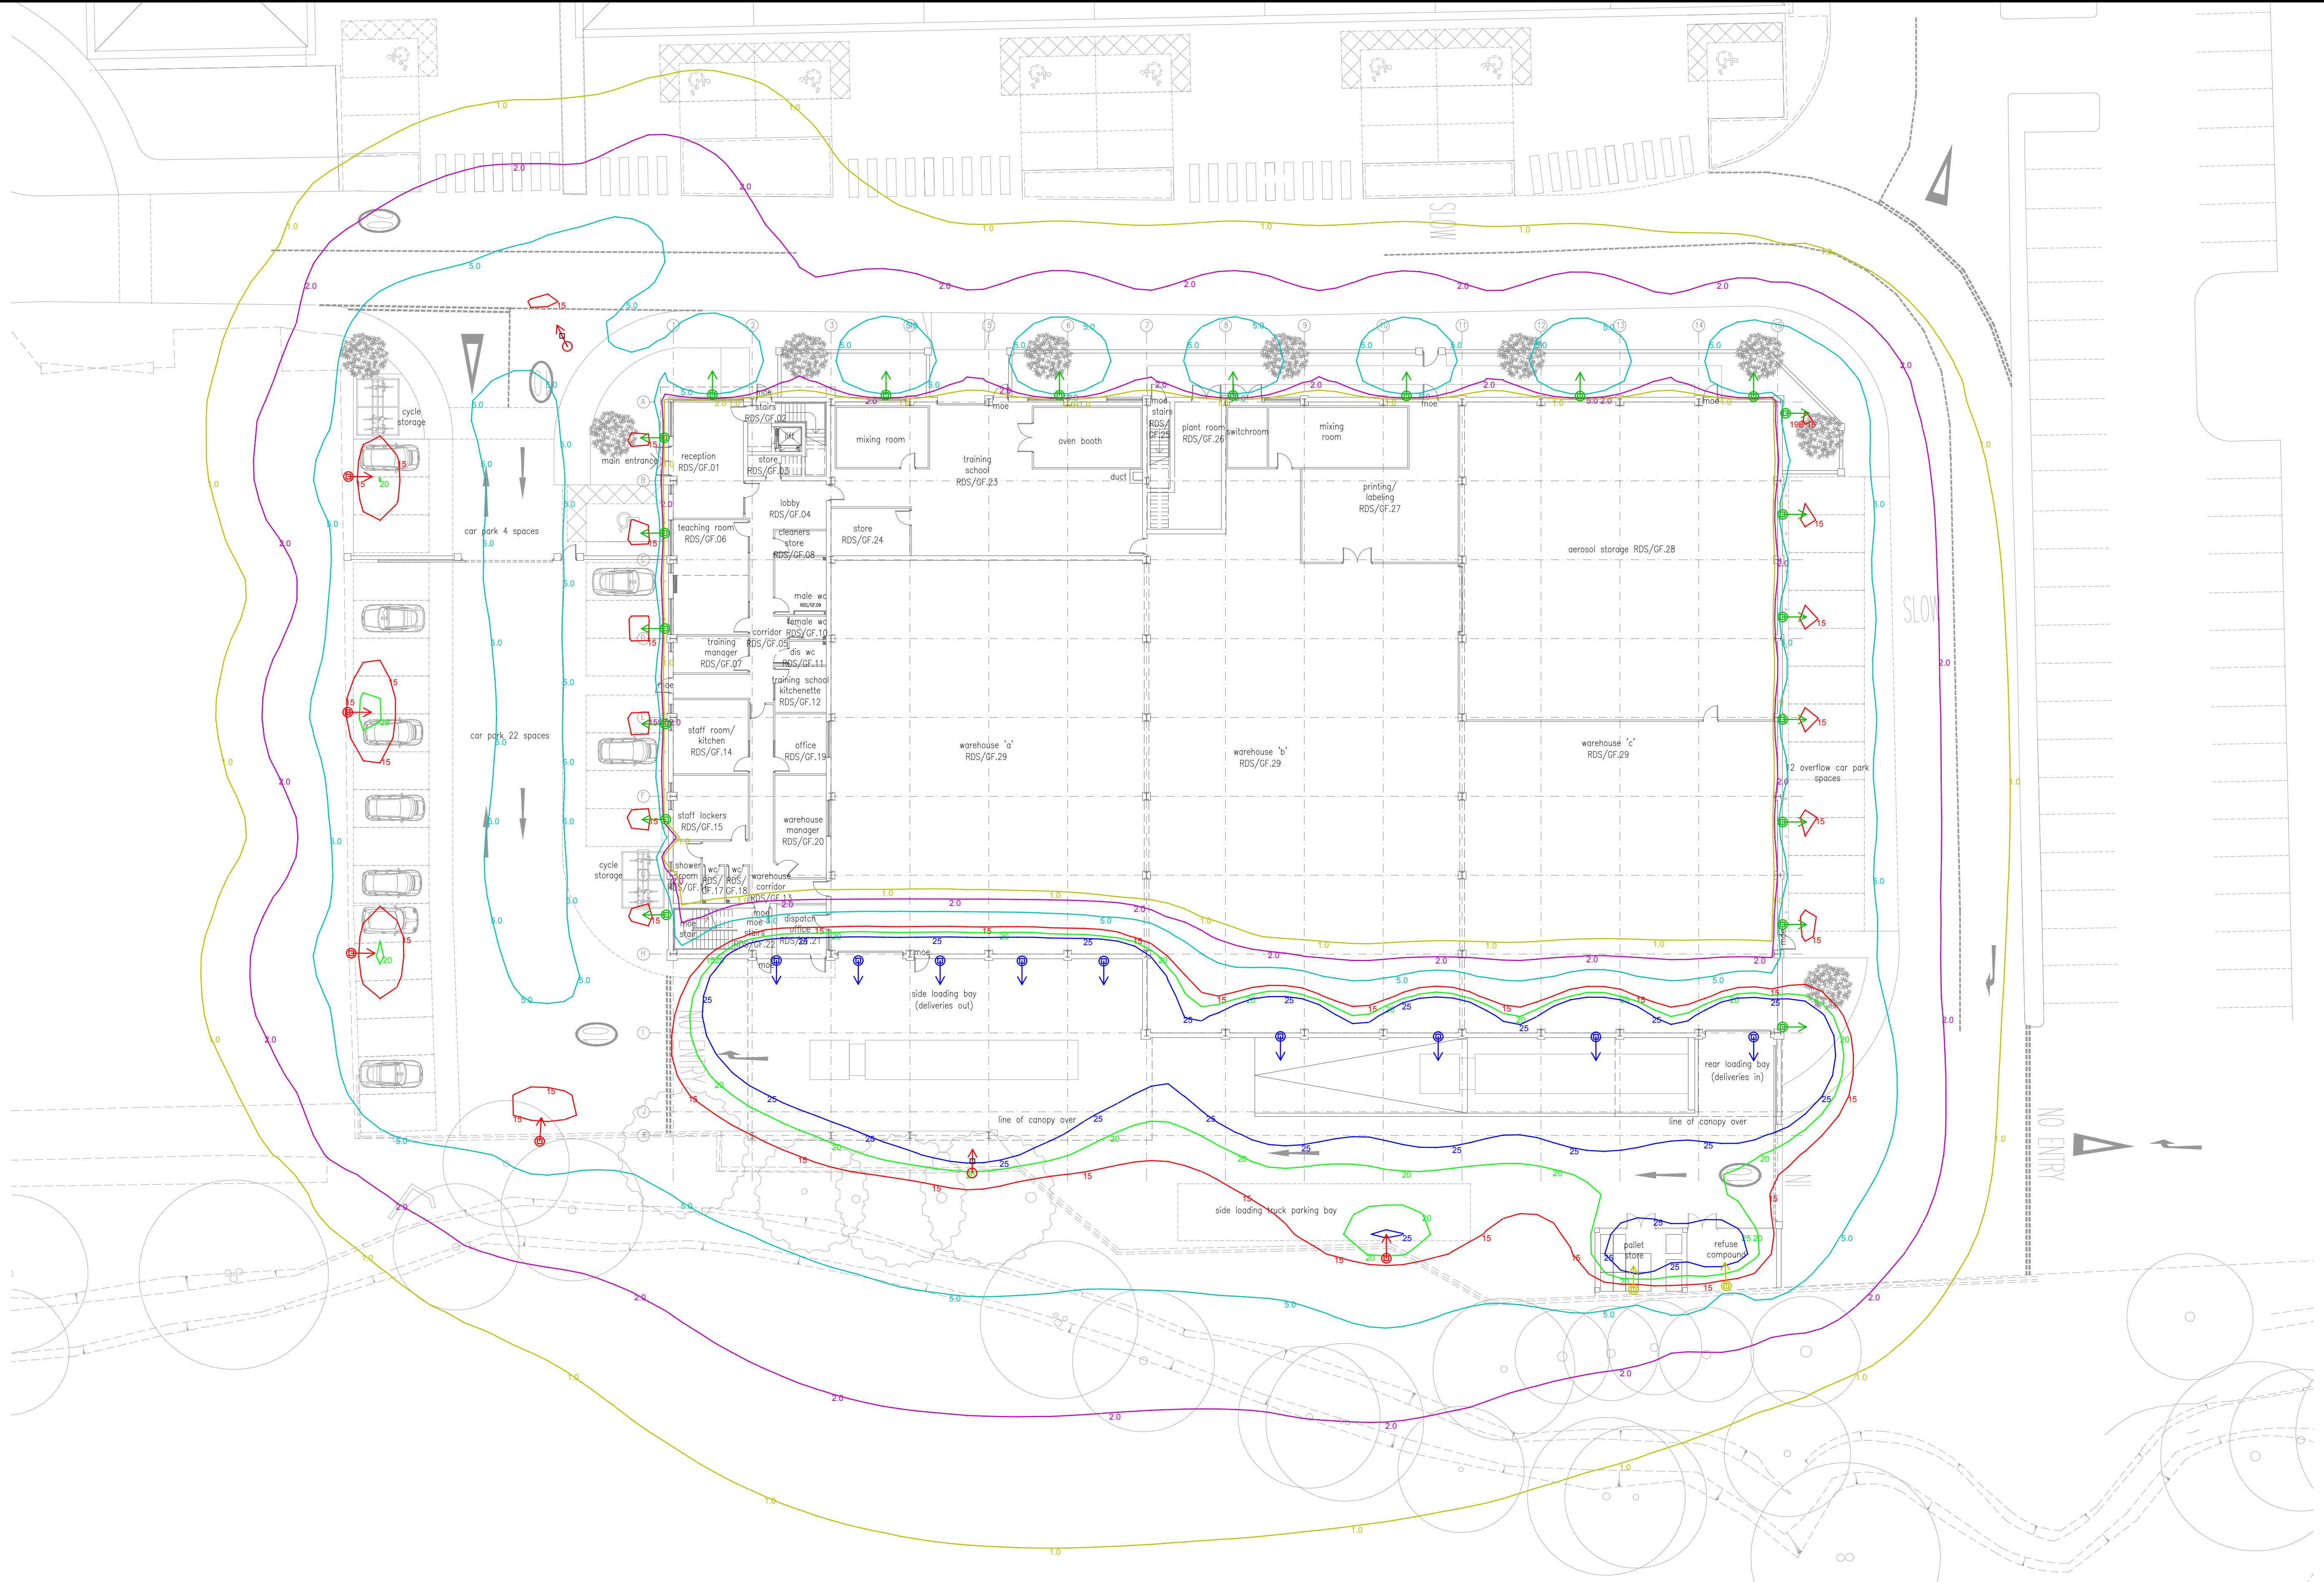

BACKGROUND INFORMATION			
ION XREF DRG No.	X18-038 GF PROP (2018-08-15)		
RECEIVED FROM	DRAWING NUMBER	REV	DATE REC'D
PDP	27974-TD202		2018-07-13
NOTES			
DO NOT SCALE FROM THIS DRAWING - CHECK ALL DIMENSIONS ON SITE			
THIS DRAWING IS INDICATIVE ONLY. THEREFORE, INSTALLING CONTRACTORS MUST CHECK ALL INFORMATION SHOWN FOR ACCURACY, PRIOR TO USING THIS DRAWING FOR ANY INSTALLATION WORK			
ANY INACCURACIES WITH THIS DRAWING MUST BE REPORTED TO ION CONSULTING ENGINEERS AT THE EARLIEST OPPORTUNITY			

NOTES
1. THIS DRAWING SHALL BE READ IN CONJUNCTION WITH THE ION CONSULTING ENGINEERS SPECIFICATION FOR THE ELECTRICAL SERVICES INSTALLATION.

--

--

THIS DRAWING IS INDICATIVE ONLY & DOES NOT REPRESENT A DESIGN SOLUTION - IT IS PROVIDED TO ASSIST THE CONTRACTOR WITH INTERPRETING THE SPECIFICATION & EMPLOYER'S REQUIREMENTS ONLY			
T1	07.09.18	TENDER ISSUE	LDG/PS
REV	DATE	DESCRIPTION	DRN CHK

CLIENT:	mipa Professional Coating Systems
PROJECT:	MIPA PAINTS WAREHOUSE HAVANT
TITLE:	EXTERNAL LIGHTING LAYOUT

STATUS:	TENDER	SCALE:	1:200
Building Services Consulting Engineers			
ION Consulting Engineers Ltd Hill Barn, Grosvenor Court, Amplefield Hill, Amplefield, Romsey, Hampshire, SO51 9BD T: 01794 368693 F: 01794 368484 E: admin@ion-consulting.co.uk		SIZE:	
DWG No. 18-038 E004		REV: T1	