
 
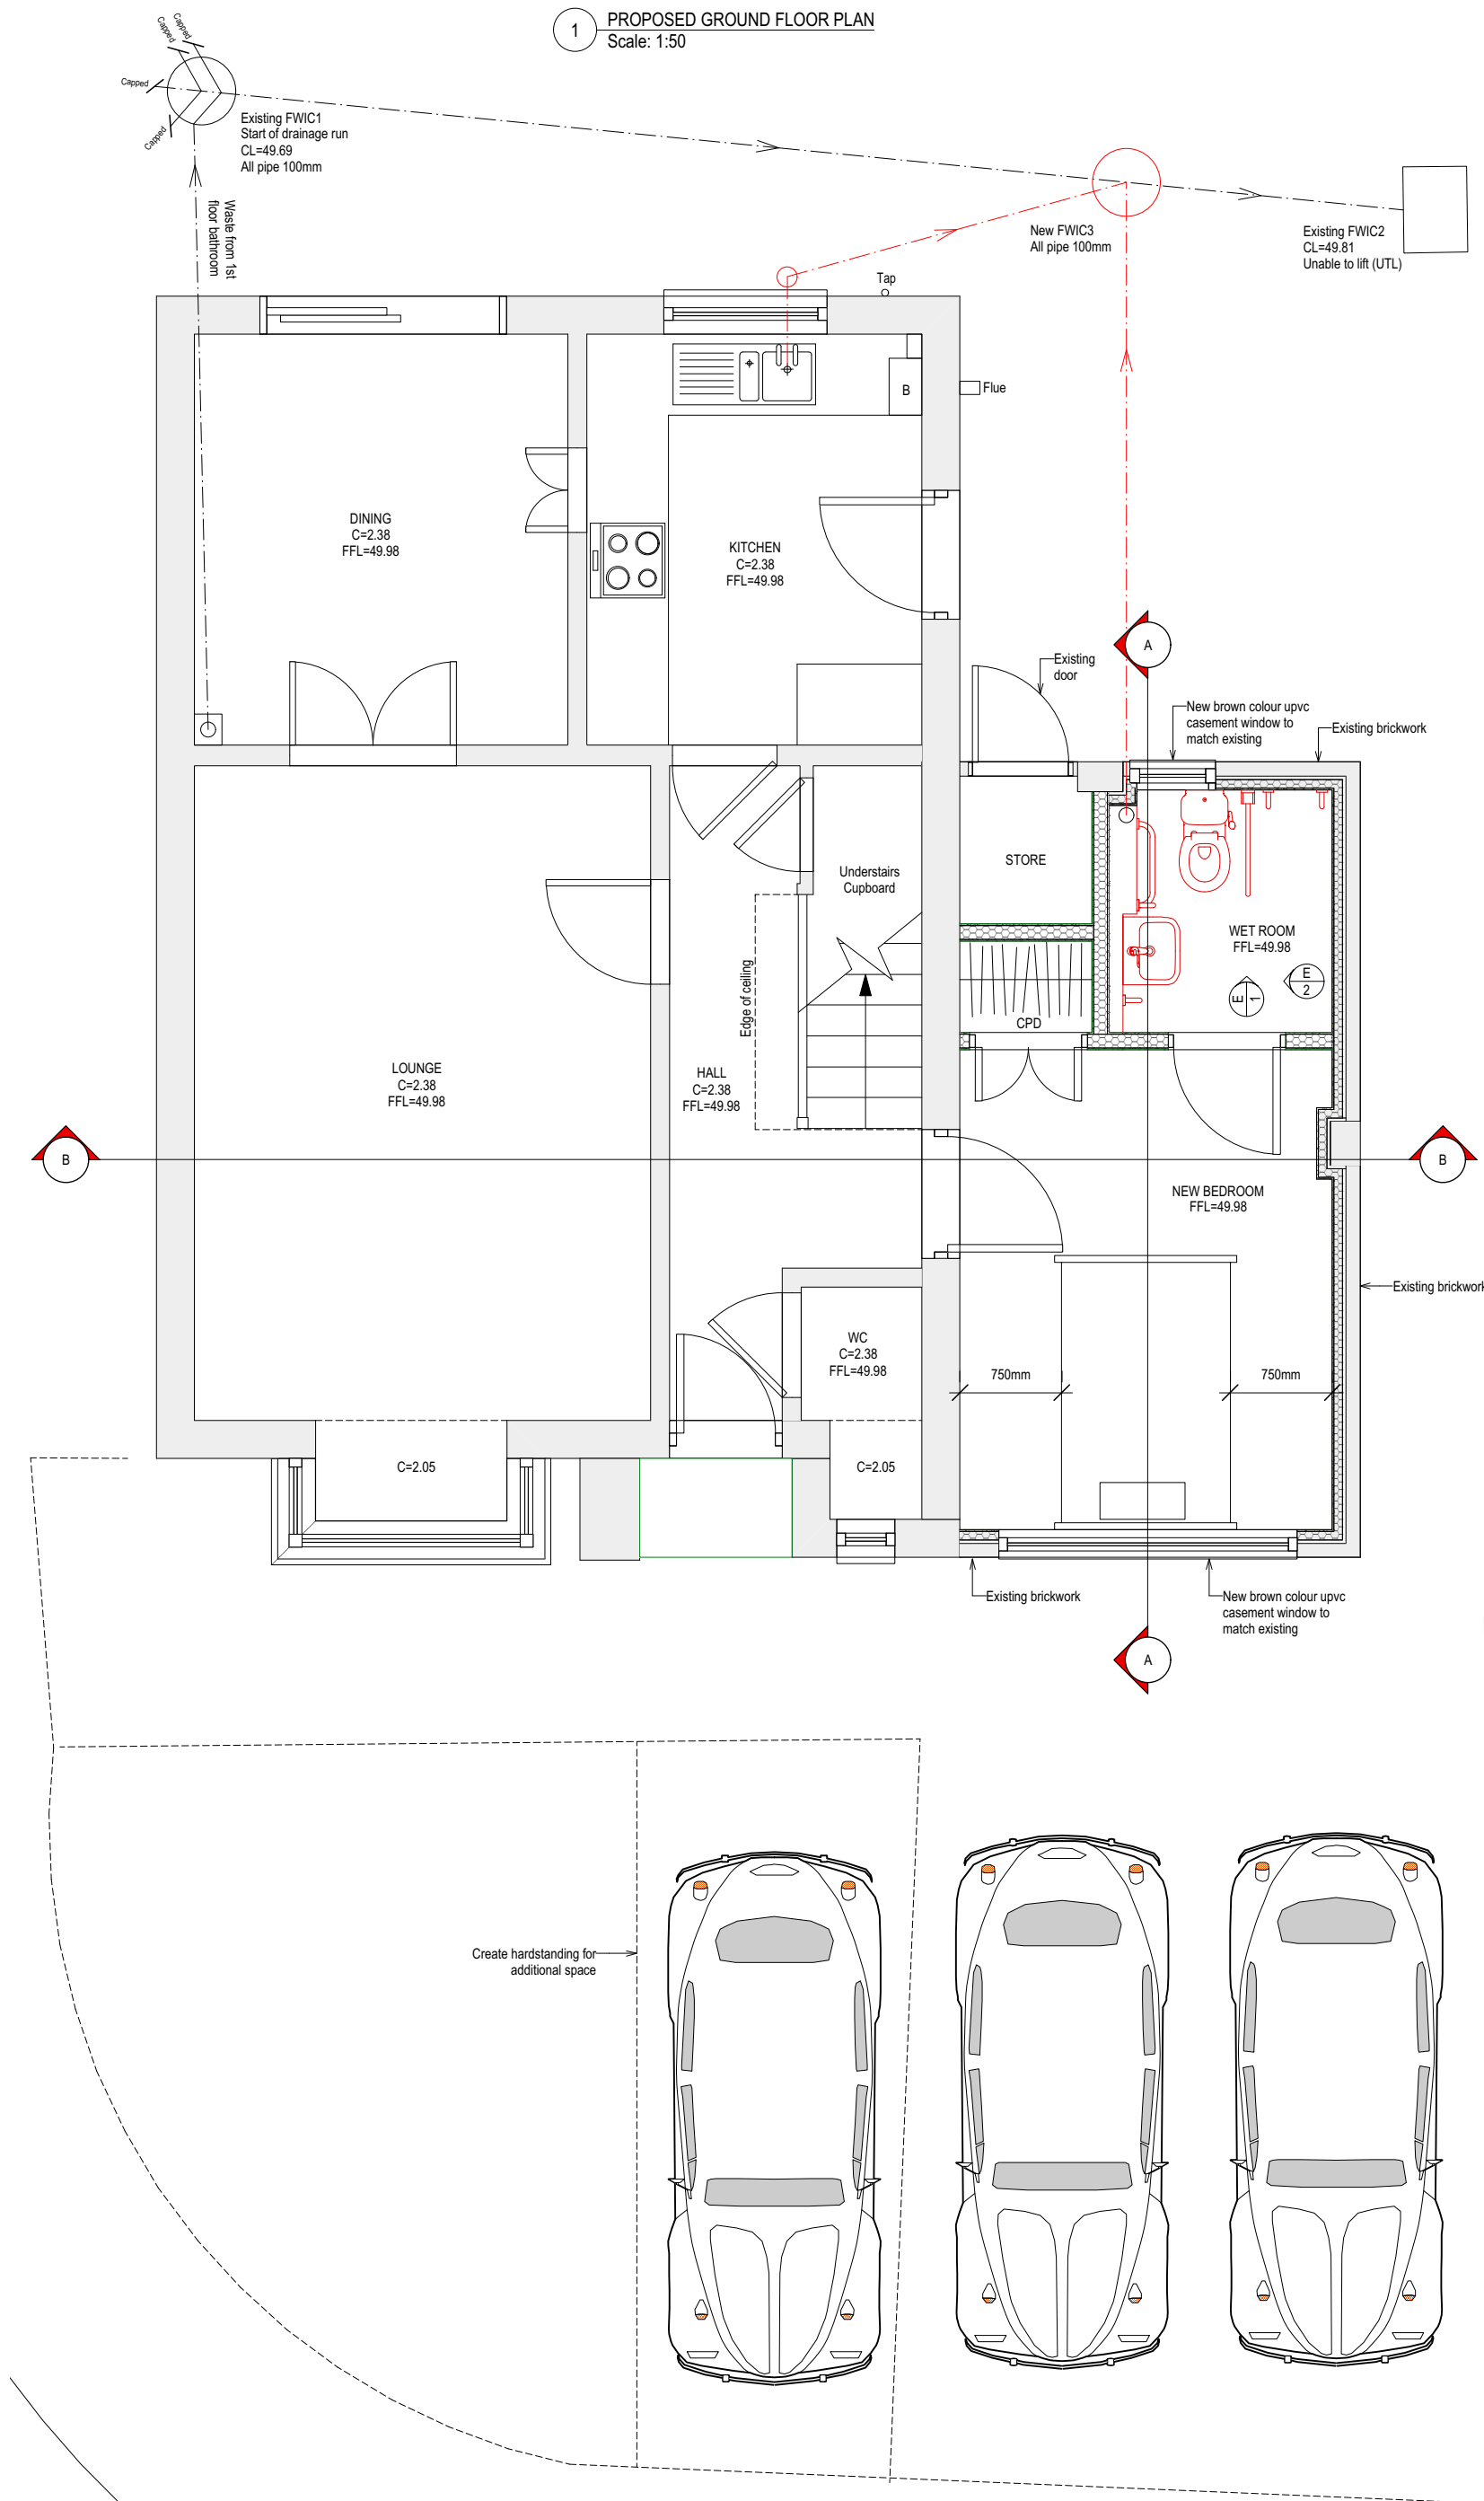





Harkness Drive

9 PROPOSED REAR ELEVATION
Scale: 1:50

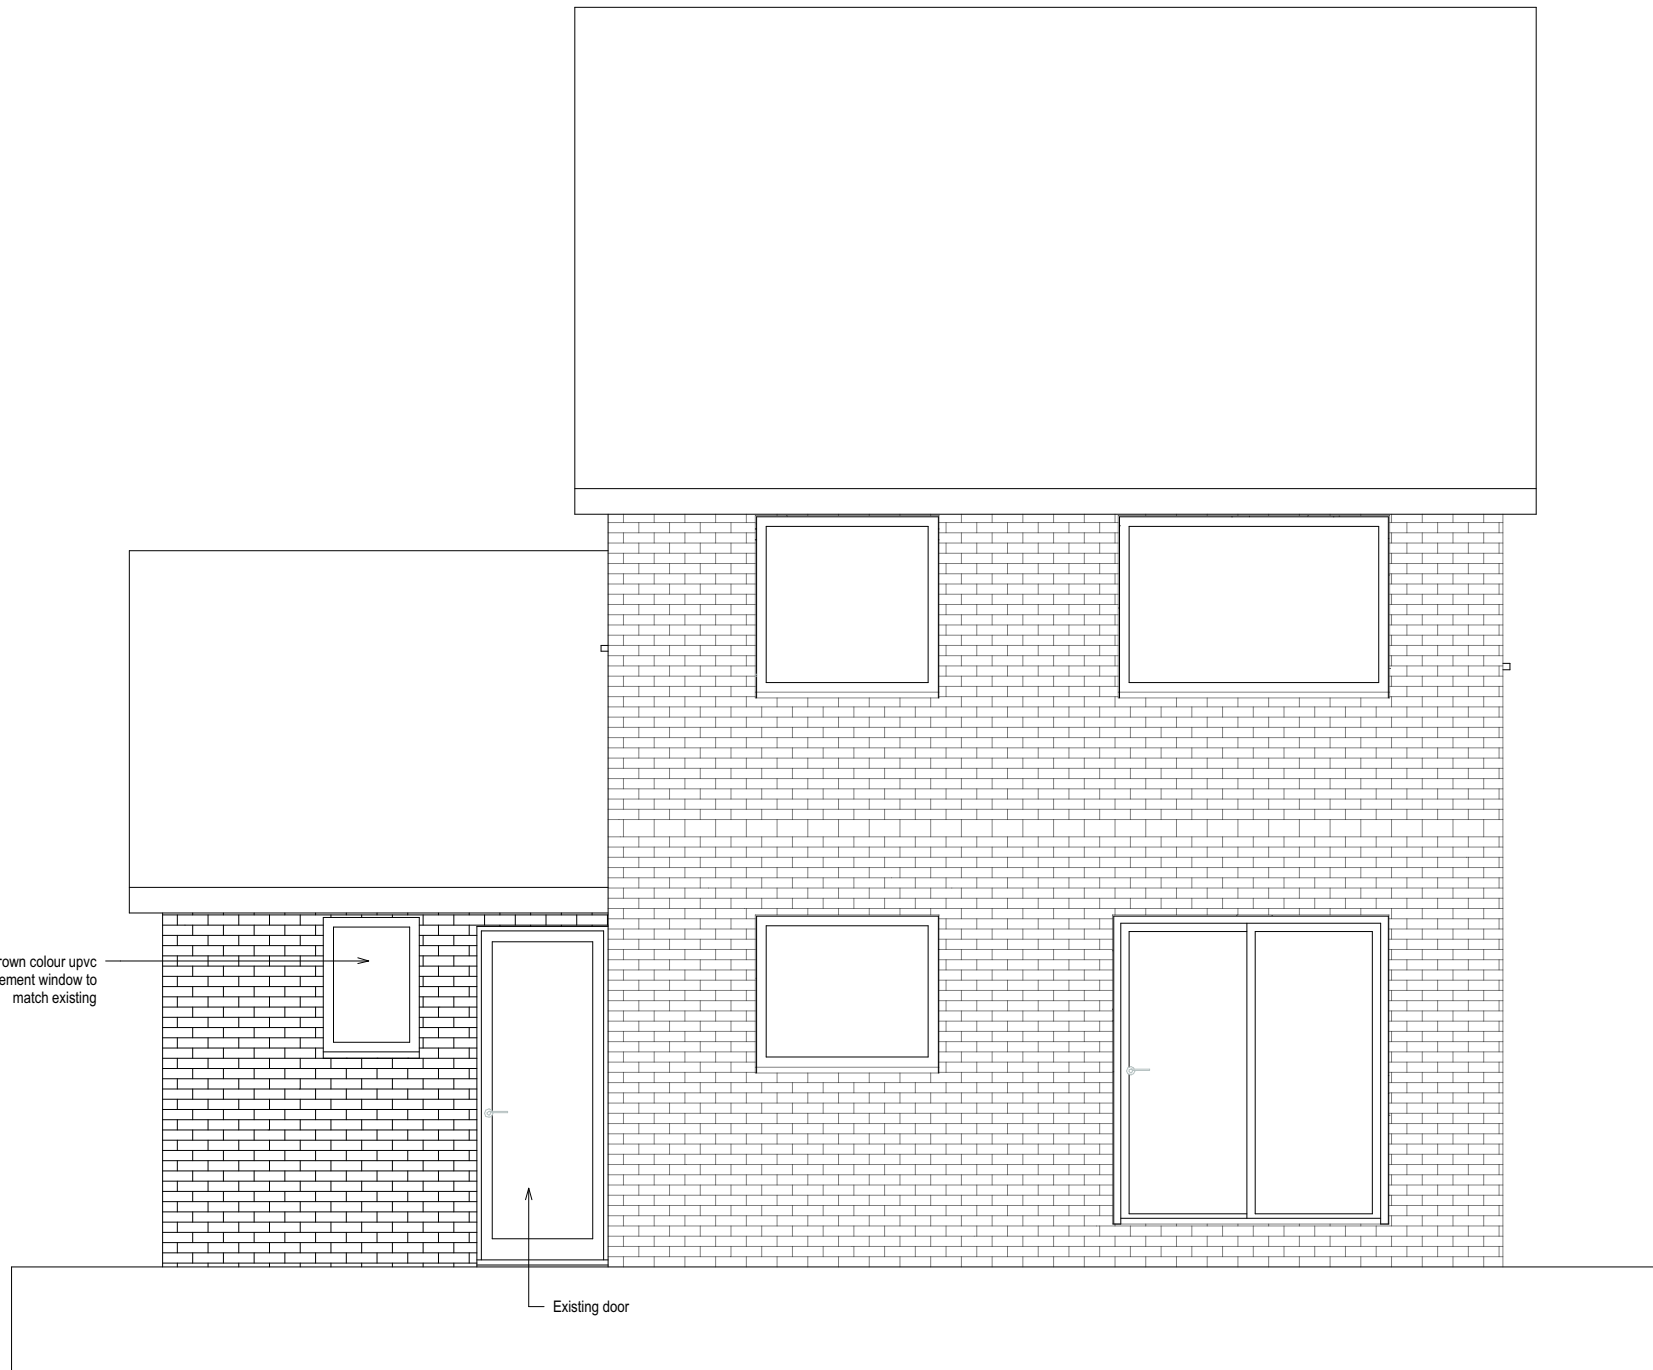

10 PROPOSED FRONT ELEVATION
Scale: 1:50

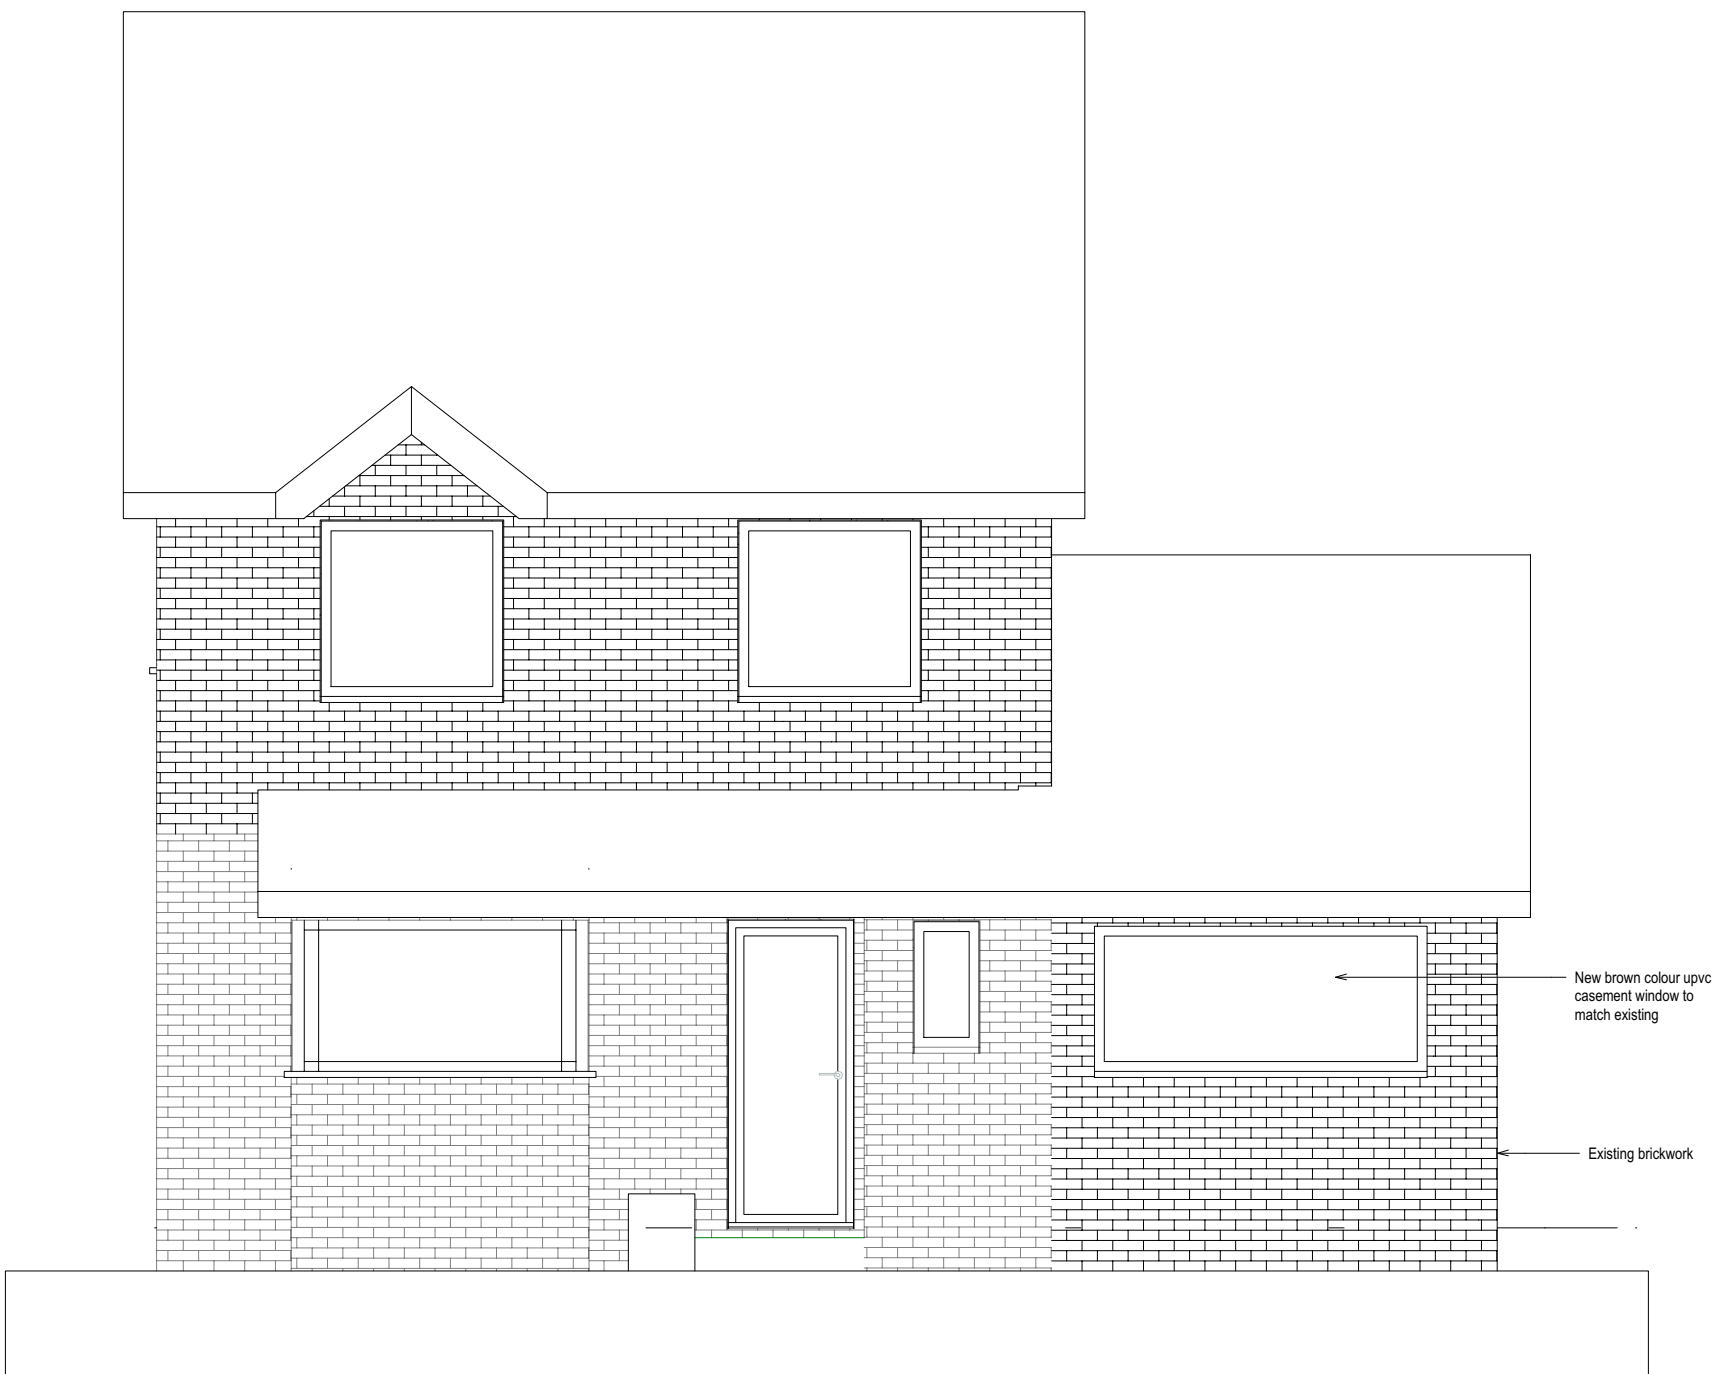

PLANNING

LEVEL DATA

Levels are based on Temporary Bench Mark (TBM) located on Station A, Value = 50.00m

NOTES

- All dimensions and levels to be checked on site by contractor prior to fabrication/construction.
- This drawing is to be read in conjunction with all relevant consultant and/or specialist's drawings and documents. Any discrepancies or variations are to be notified to SurveyCloud Ltd before the affected work commences.
- This drawing and the copyrights and patents therein are the property of SurveyCloud Ltd and may not be used or reproduced without prior consent.

KEY

A	Approximate	LB	Liter Bin
AB	Air Brick	LP	Lamp Post
AC	Arch Crown Height	LTB	Lighting Bollard
Agg	Agggregate	MH	Manhole
AS	Arch Spring Height	MK	Marker Post
Asph	Asphalt	MPO	Manhole Post
B	Bulldoz	NP	Name Plate
BB	Beltina Beacon	OH	Overhead Cable
BH	Bonhole	OB	Overhead Building
Brew	Brick Pavers	OE	Overhead Electric Cable
BKG	Back Inset Gully	OHT	Overhead Telecom Cable
BRW	Brick Wall	PB	Post Box
BS	Brick Slat	PM	Parking Meter
C	Ceiling Height	PO	Post
Clap	Ceiling Slopes Up	PWL	Parapet Wall Level
CF	False Ceiling Height	RB	Removable Bollard
CH	Ceiling Hatch	RE	Road Edge
CL	Cover Level	RG	Road Gully
Cob	Cobbles	RL	Ridge Level
Conc	Concrete	REC	Reflective Post
Cover	Cover	RS	Road Sign
Cpd	Cupboard	RWP	Rainwater Pipe
GPO	Gate Post	SH	Window Sill to Head Height
GPS	Concrete Paving Slab	SP	Soil Pipe
OWT	Cold Water Tank	SSL	Structural Slat Level
D	Depth (metres)	STN	Survey Station
DC	Drainage Channel	SVF	Soil Vent Pipe
DH	Door Head Height	SWC	Surface Water IC
DPC	Damp Proof Course	TCB	Telephone Cell Box
EL	Earth Level	TFL	Top Fence Level
EP	Electric Pole	TL	Traffic Light
ER	Earth Road	TLCB	Traffic Light Control Box
FB	Fixed Bollard	Tmac	Tarmac
FFL	Finished Floor Level	TP	Telegraph Pole
Flt	Fire Hydrant	Tpr	Traffic Pole
FL	Flood Light	TPO	Timber Post
FP	Flag Pole	TWL	Top Wall Level
FPD	Front Post	U	Unknown
FRL	Flat Roof Level	UB	Underside of Beam Height
FWC	Four Water IC	UBov	Underside of Boiling Height
G	Gully	UD	Underside of Ducting Height
GM	Gas Meter	UP	Underside of Pipe Height
GP	Gas Pipe	US	Underside
GPO	Gate Post	UTL	Unable to Lift
H	Height (metres)	VF	Vent Pipe
HB	Hinged Bollard	WAC	Window Arch Crown Height
HWC	Hot Water Cylinder	WAS	Window Arch Spring Height
IC	Inspection Cover	WH	Window Head Height
ID	Invert Depth	WL	Water Level
IL	Invert Level	WM	Water Meter
JB	Junction Box	WP	Water Pipe
KIG	Kids Inlet Gully	WS	Window Sill Height
L	Level	WSP	Water Stop Valve

Revision	Comment	Date
Client MR. LEE FRASER SMITH		
Project 41 HARKNESS DRIVE WATERLOOVILLE HAMPSHIRE PO7 6SP		
Title PROPOSED PLANNING		
Drawing Number SD/18500-P3.0A	Revision A	Status PLANNING
Scale AS SHOWN	Sheet Size A1	Drawn By Date MARCH 2018
10 Church Road Steep Hampshire GU32 2DW		
SURVEYCLOUD LTD Phone 01700 808 808 Office 01700 802 486 mail@surveycloud.co.uk www.surveycloud.co.uk		