


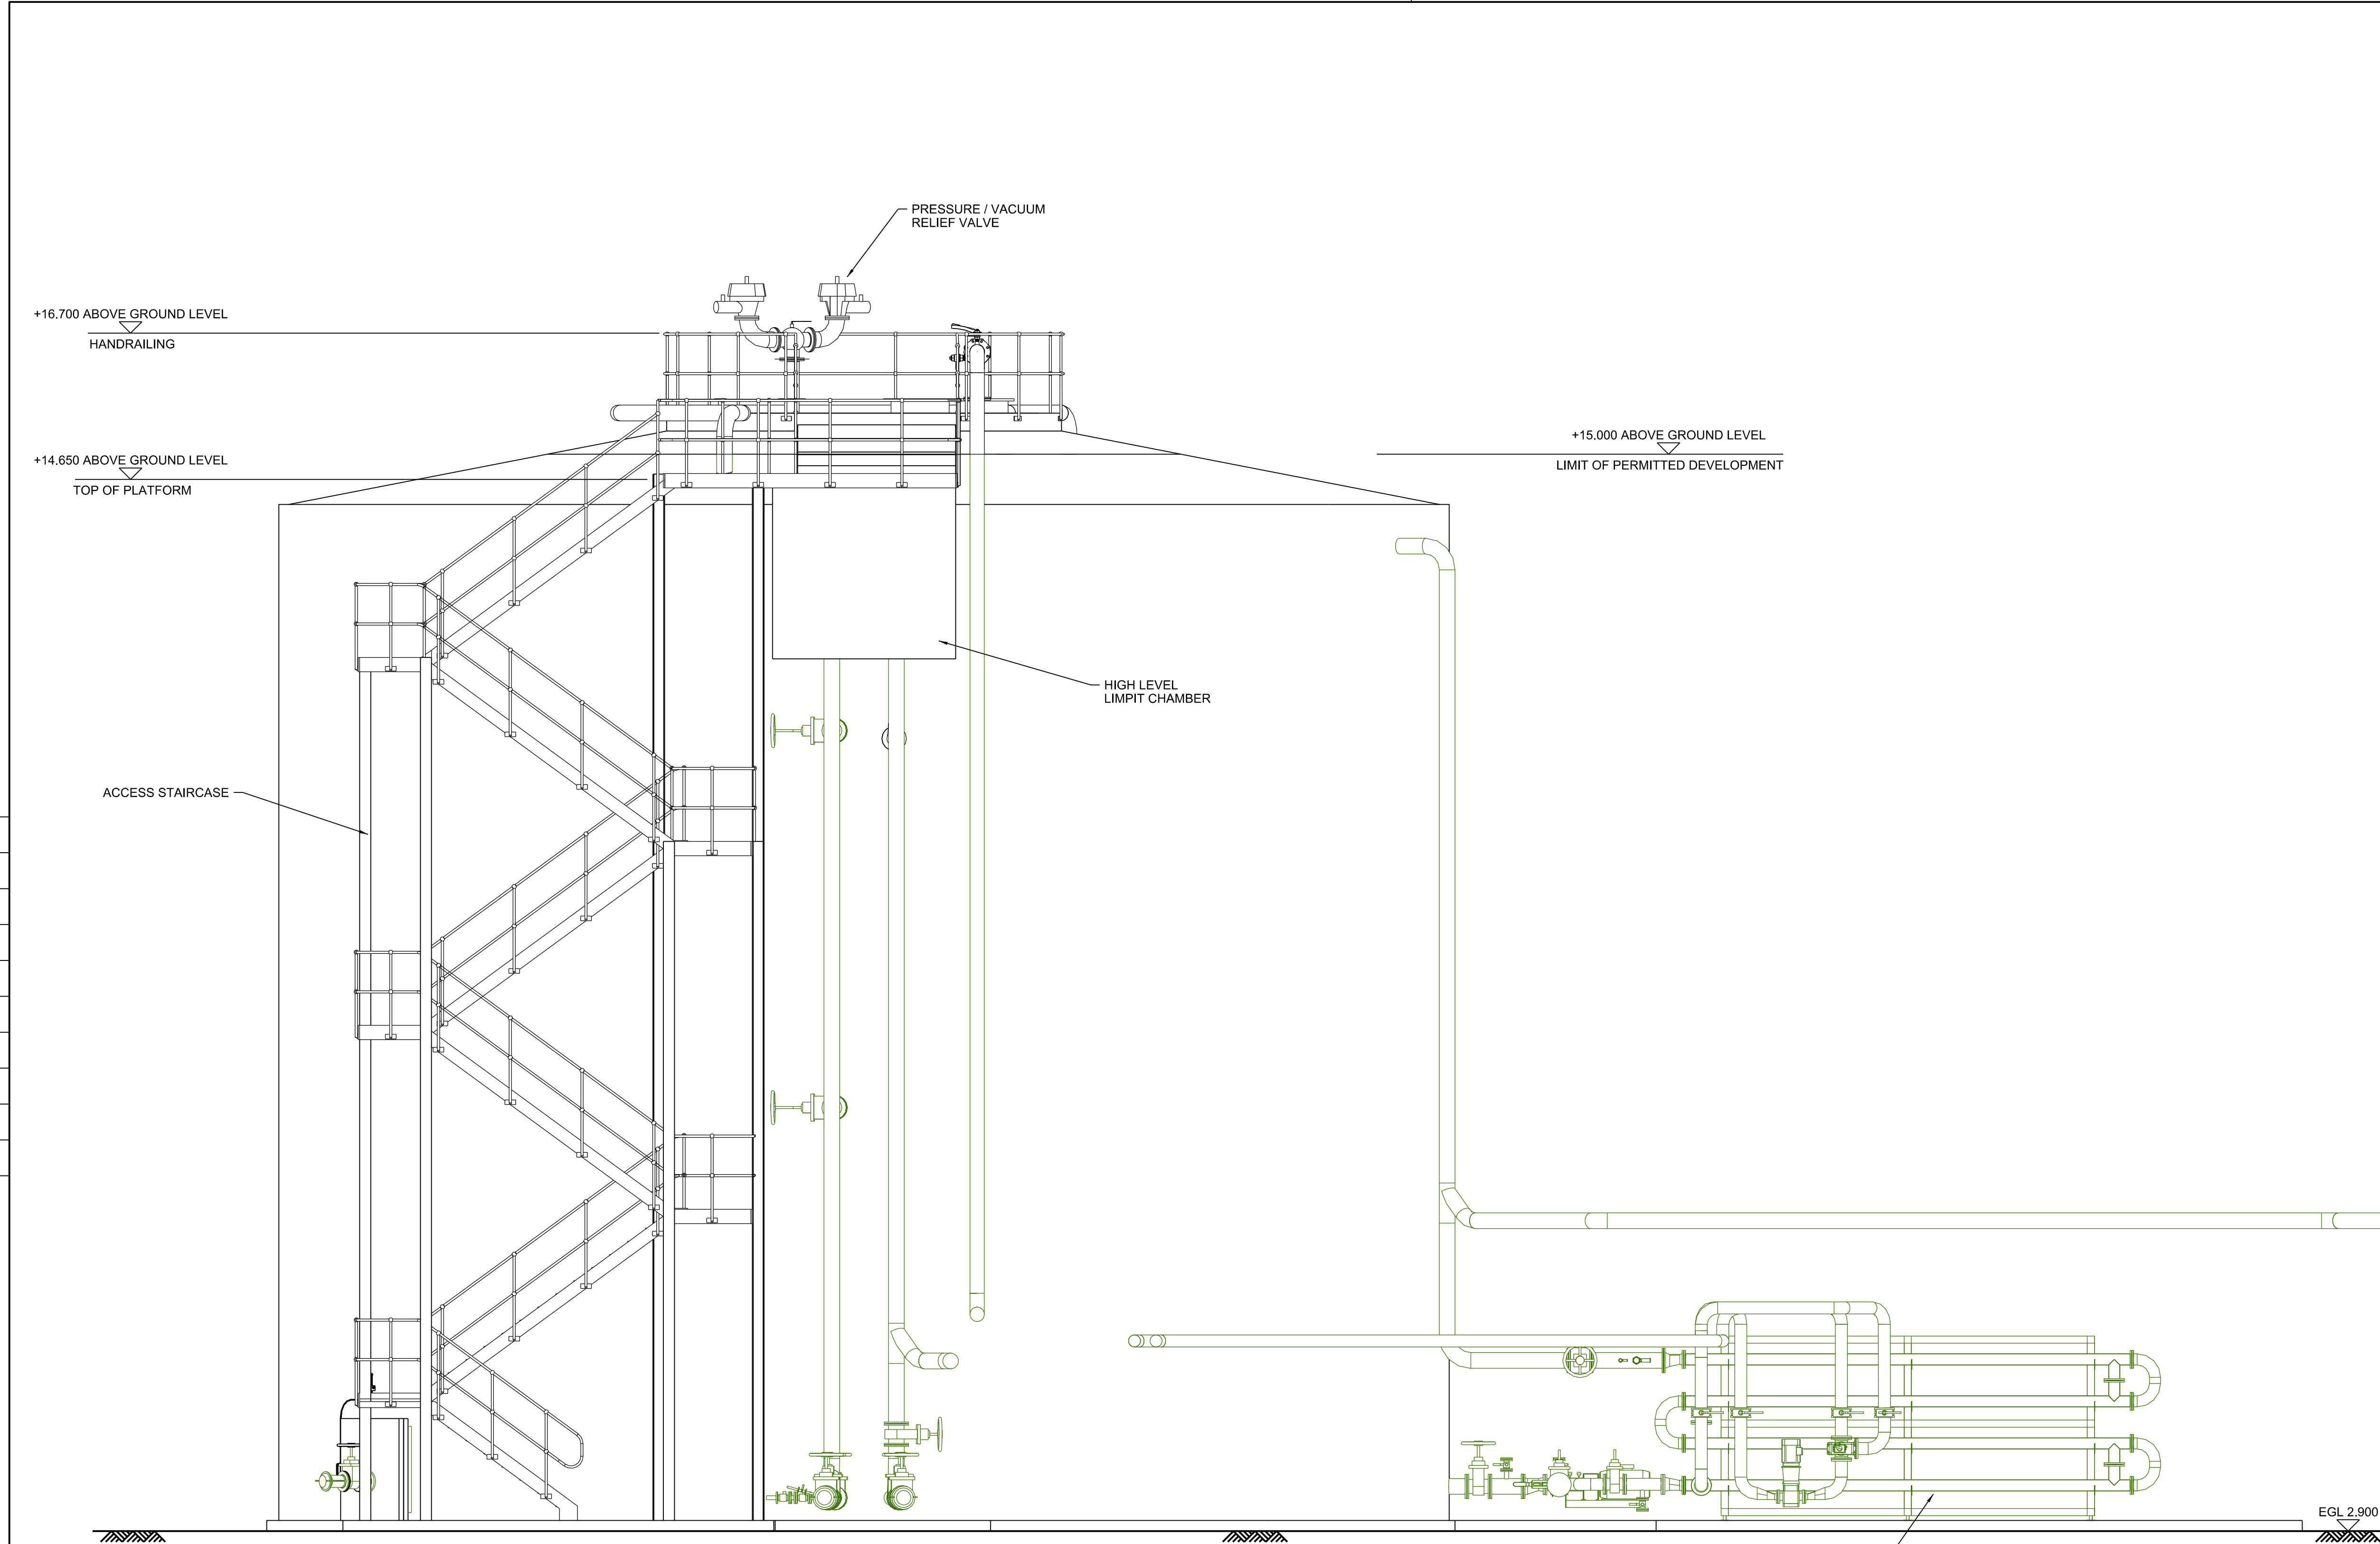

SECTION A - A
(020705)

S.W. DRAWING NO.
JN.639264.0Z0706

REVISION
A

NOTES

- ALL DIMENSIONS IN MILLIMETRES AND ALL LEVELS IN METRES UNLESS SHOWN OTHERWISE.
- DIGESTER TANK COLOUR : MATT GREY CORRUGATED CLADDING AS PER 4No. EXISTING DIGESTERS.
- ACCESS STAIRWAY FABRICATED IN GALVANISED STEEL.

REFERENCES

JN.639264.0Z0701	PLANNING APPLICATION - SITE LOCATION PLAN
JN.639264.0Z0702	PLANNING APPLICATION - LOCATION PLAN
JN.639264.0Z0703	PLANNING APPLICATION - SITE PLAN
JN.639264.0Z0704	PLANNING APPLICATION - CENTRIFUGE FEED PUMPING STATION - KIOSK PLAN AND SECTIONS
JN.639264.0Z0705	PLANNING APPLICATION - DIGESTER No. 5 PLAN
JN.639264.0Z0707	PLANNING APPLICATION - DIGESTER No. 5 SECTION B-B
JN.639264.0Z0708	PLANNING APPLICATION - DIGESTER No. 5 SECTION C-C
JN.639264.0Z0709	PLANNING APPLICATION - DIGESTER No. 5 SECTION D-D

LEGEND

	DEVELOPMENT REQUIRING PLANNING PERMISSION
	PERMITTED DEVELOPMENT ABOVE GROUND

SCALE 1 : 50

CURRENT VERSION INFORMATION

19.04.2017	AJB	LM	BK	A	FOR PLANNING
DATE	DRWN	CHKD	REVD	REV	REASON FOR ISSUE

THIS DRAWING IS ISSUED BY SOUTHERN WATER SUBJECT TO THE CONDITIONS THAT IT IS NOT COPIED EITHER IN WHOLE OR IN PART OR DISCLOSED TO THIRD PARTIES UNLESS PRIOR WRITTEN AUTHORISATION IS GIVEN BY SOUTHERN WATER. PREVIOUS VERSIONS OF THIS DRAWING SHOULD BE STAMPED SUPERSEDED OR DESTROYED. DO NOT SCALE THIS DRAWING - IF IN DOUBT ASK

Southern Water

In Partnership with

MWH

Southern House
Yeoman Road
Worthing
West Sussex
BN13 3NX
telephone (01903) 264444
fax (01903) 691435

PROJECT TITLE
BUDDS FARM SLUDGE TREATMENT CENTRE

DRAWING TITLE
**PLANNING APPLICATION
DIGESTER No. 5
SECTION A-A**

SITE UNIT MNEUMONIC BUFMHAVA	SITE UNIT NO. 102480	
PRN 639264	SCALE 1:50	MASTER SIZE A1
S.W. DRAWING NO. JN.639264.0Z0706		REVISION A