


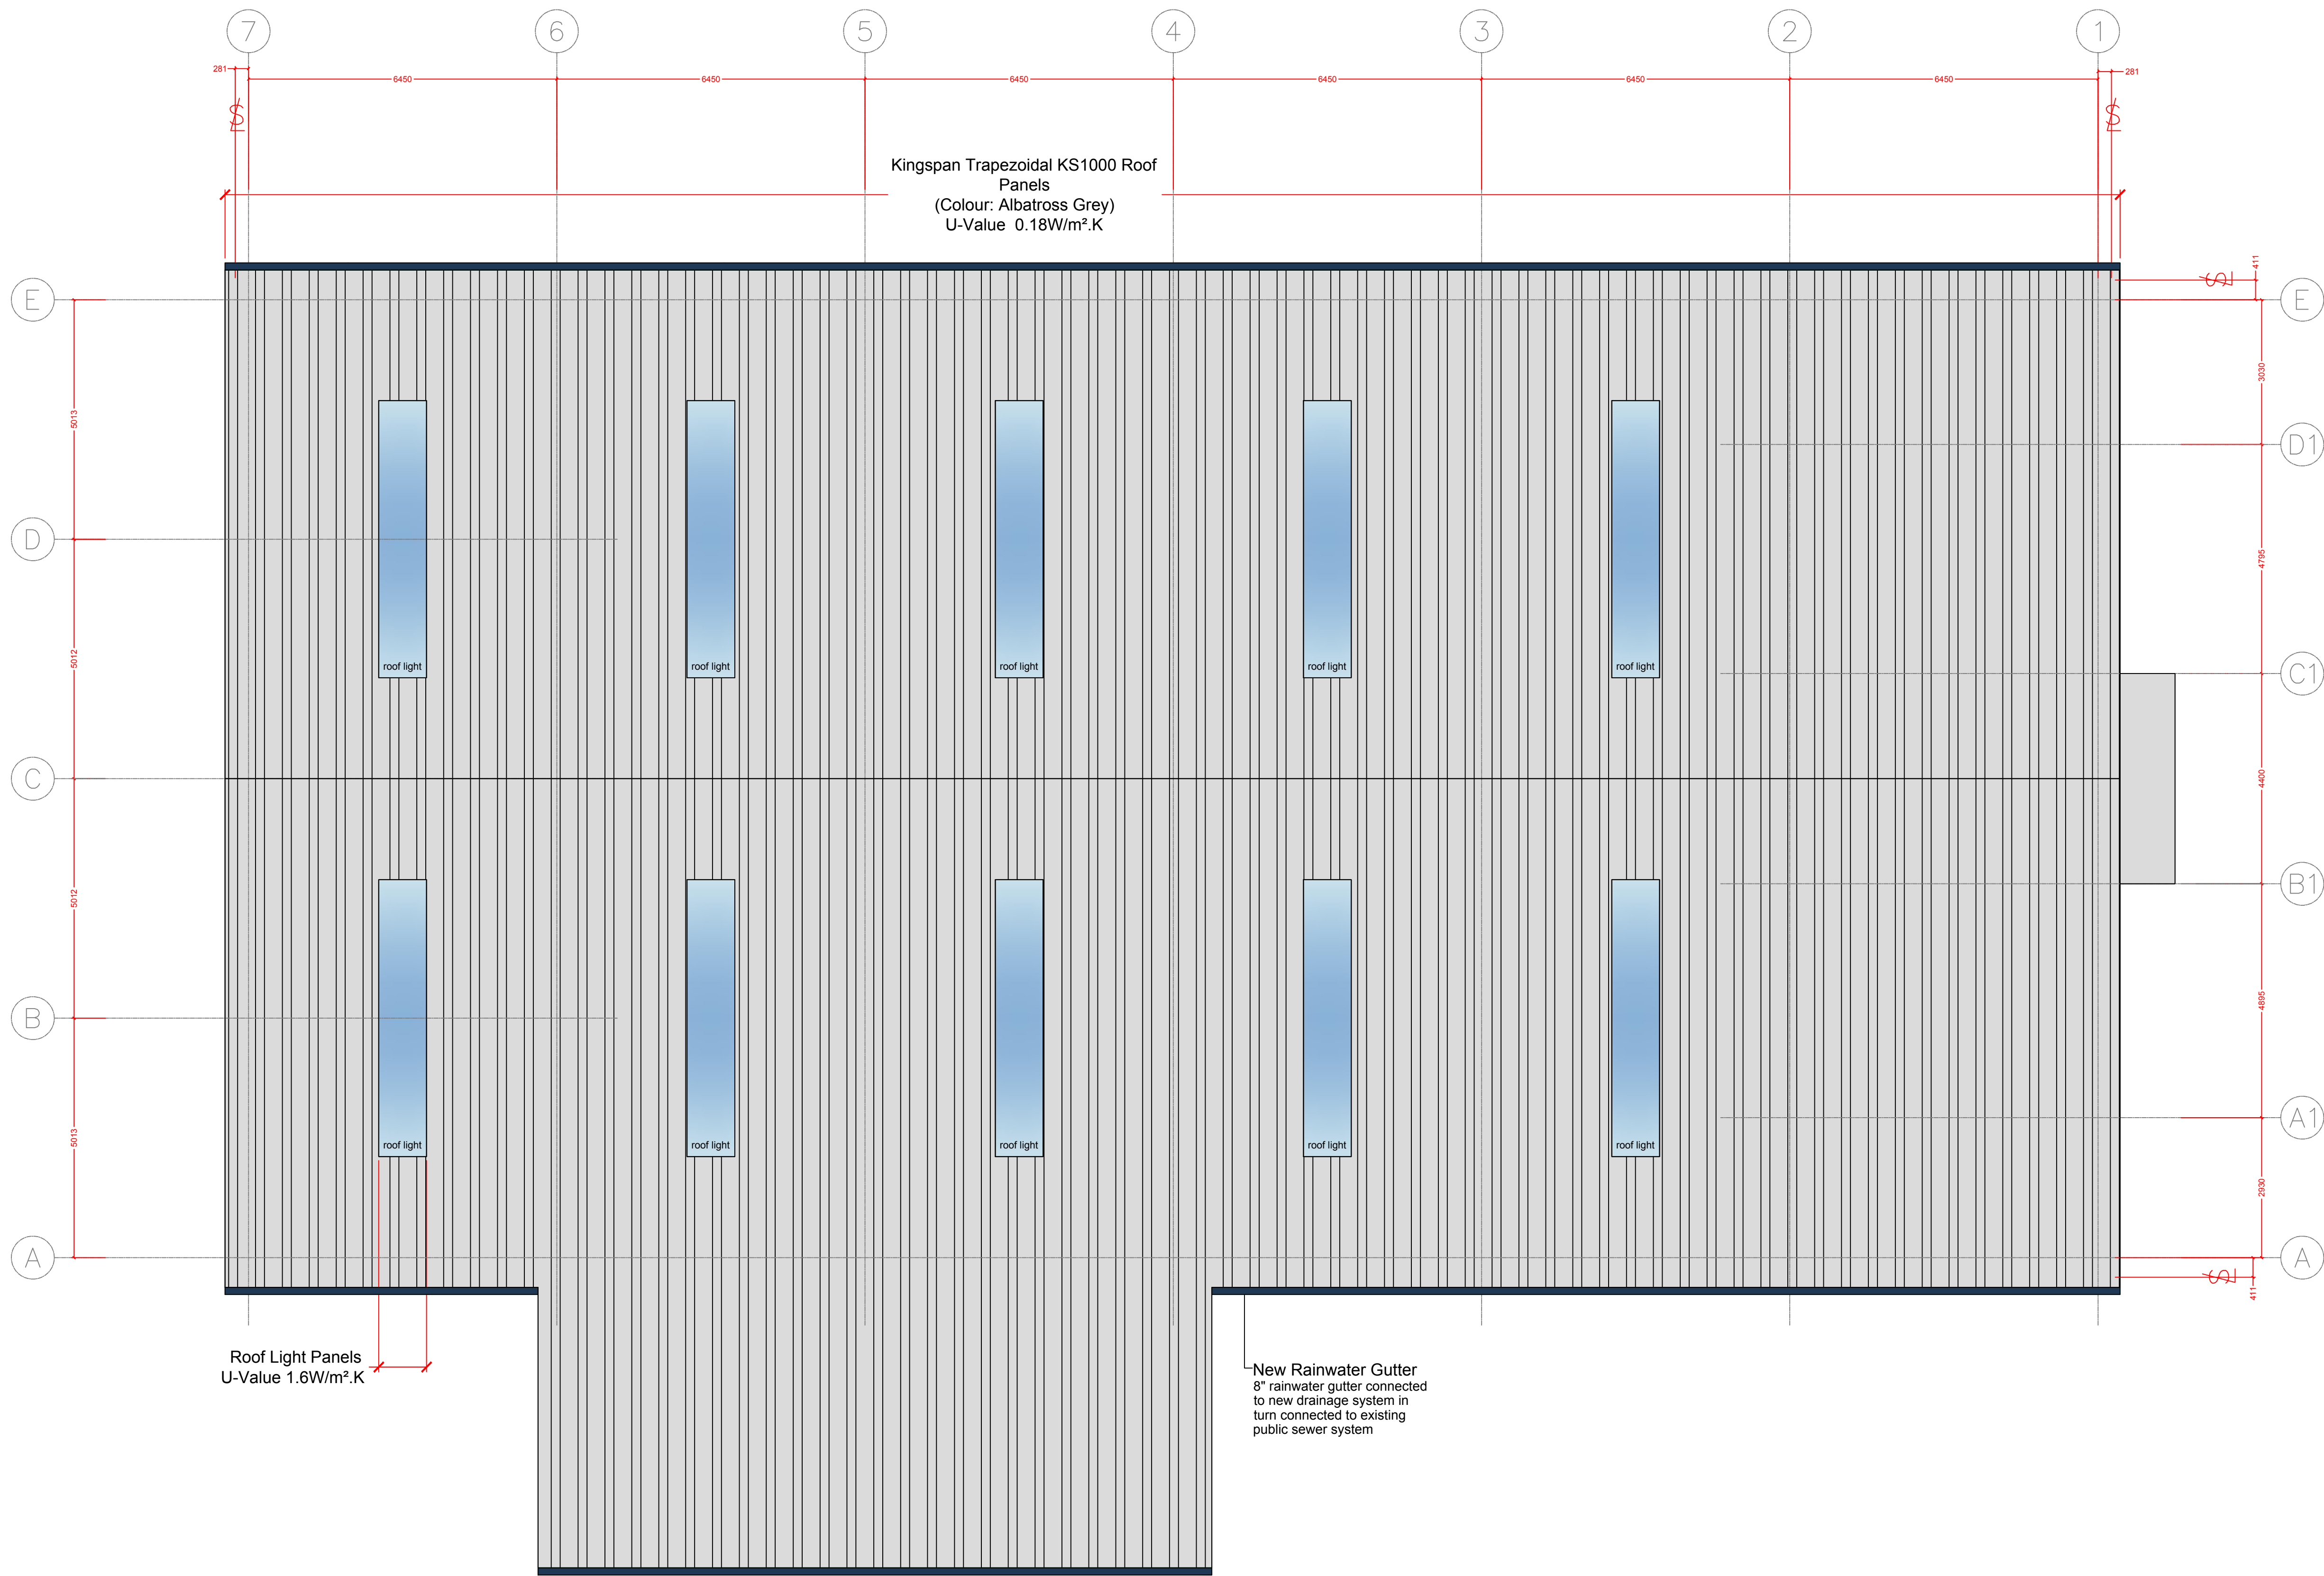

Roof Light Panels
U-Value 1.6W/m².K

New Rainwater Gutter
8" rainwater gutter connected
to new drainage system in
turn connected to existing
public sewer system

Proposed Roof Plan

Rev A dmc 11.10.17
Roof updated to match plan changes, Full
address added

Rev: Description: By: Date:
Job Title:
Proposed New Gap Plant Hire Depot
Unit 3, Hermitage Park, Harts Farm
Way, Havant, Hampshire.
PO9 1FA

Drawing Name:
Proposed Roof Plan

Project Ref: B2529_17

Date: 10.08.17 Scale:

Drawn: dmc 1:75 @ A1

Drg No: A103 Rev:

Drg Status: Planning A

