
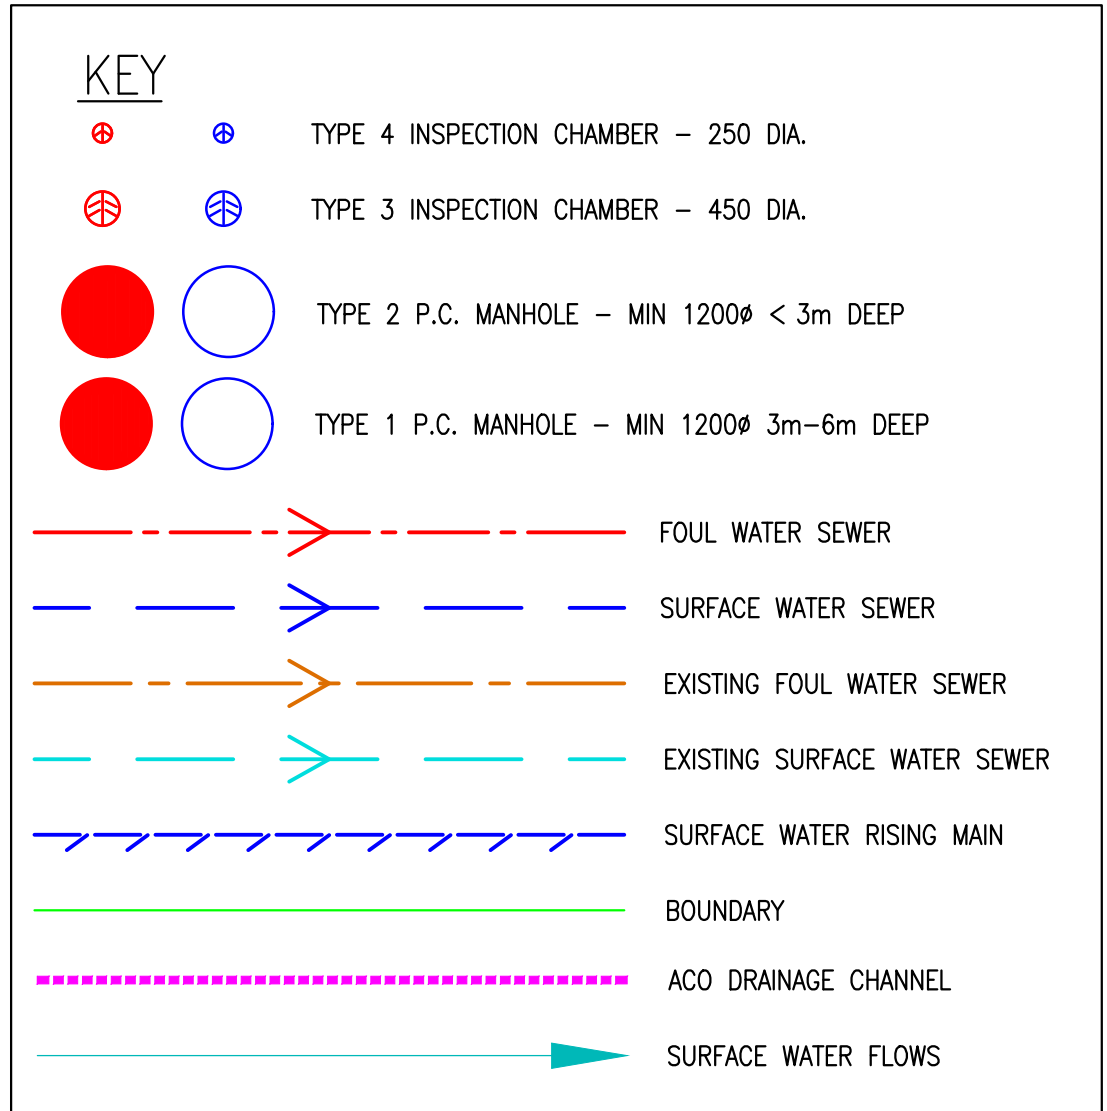


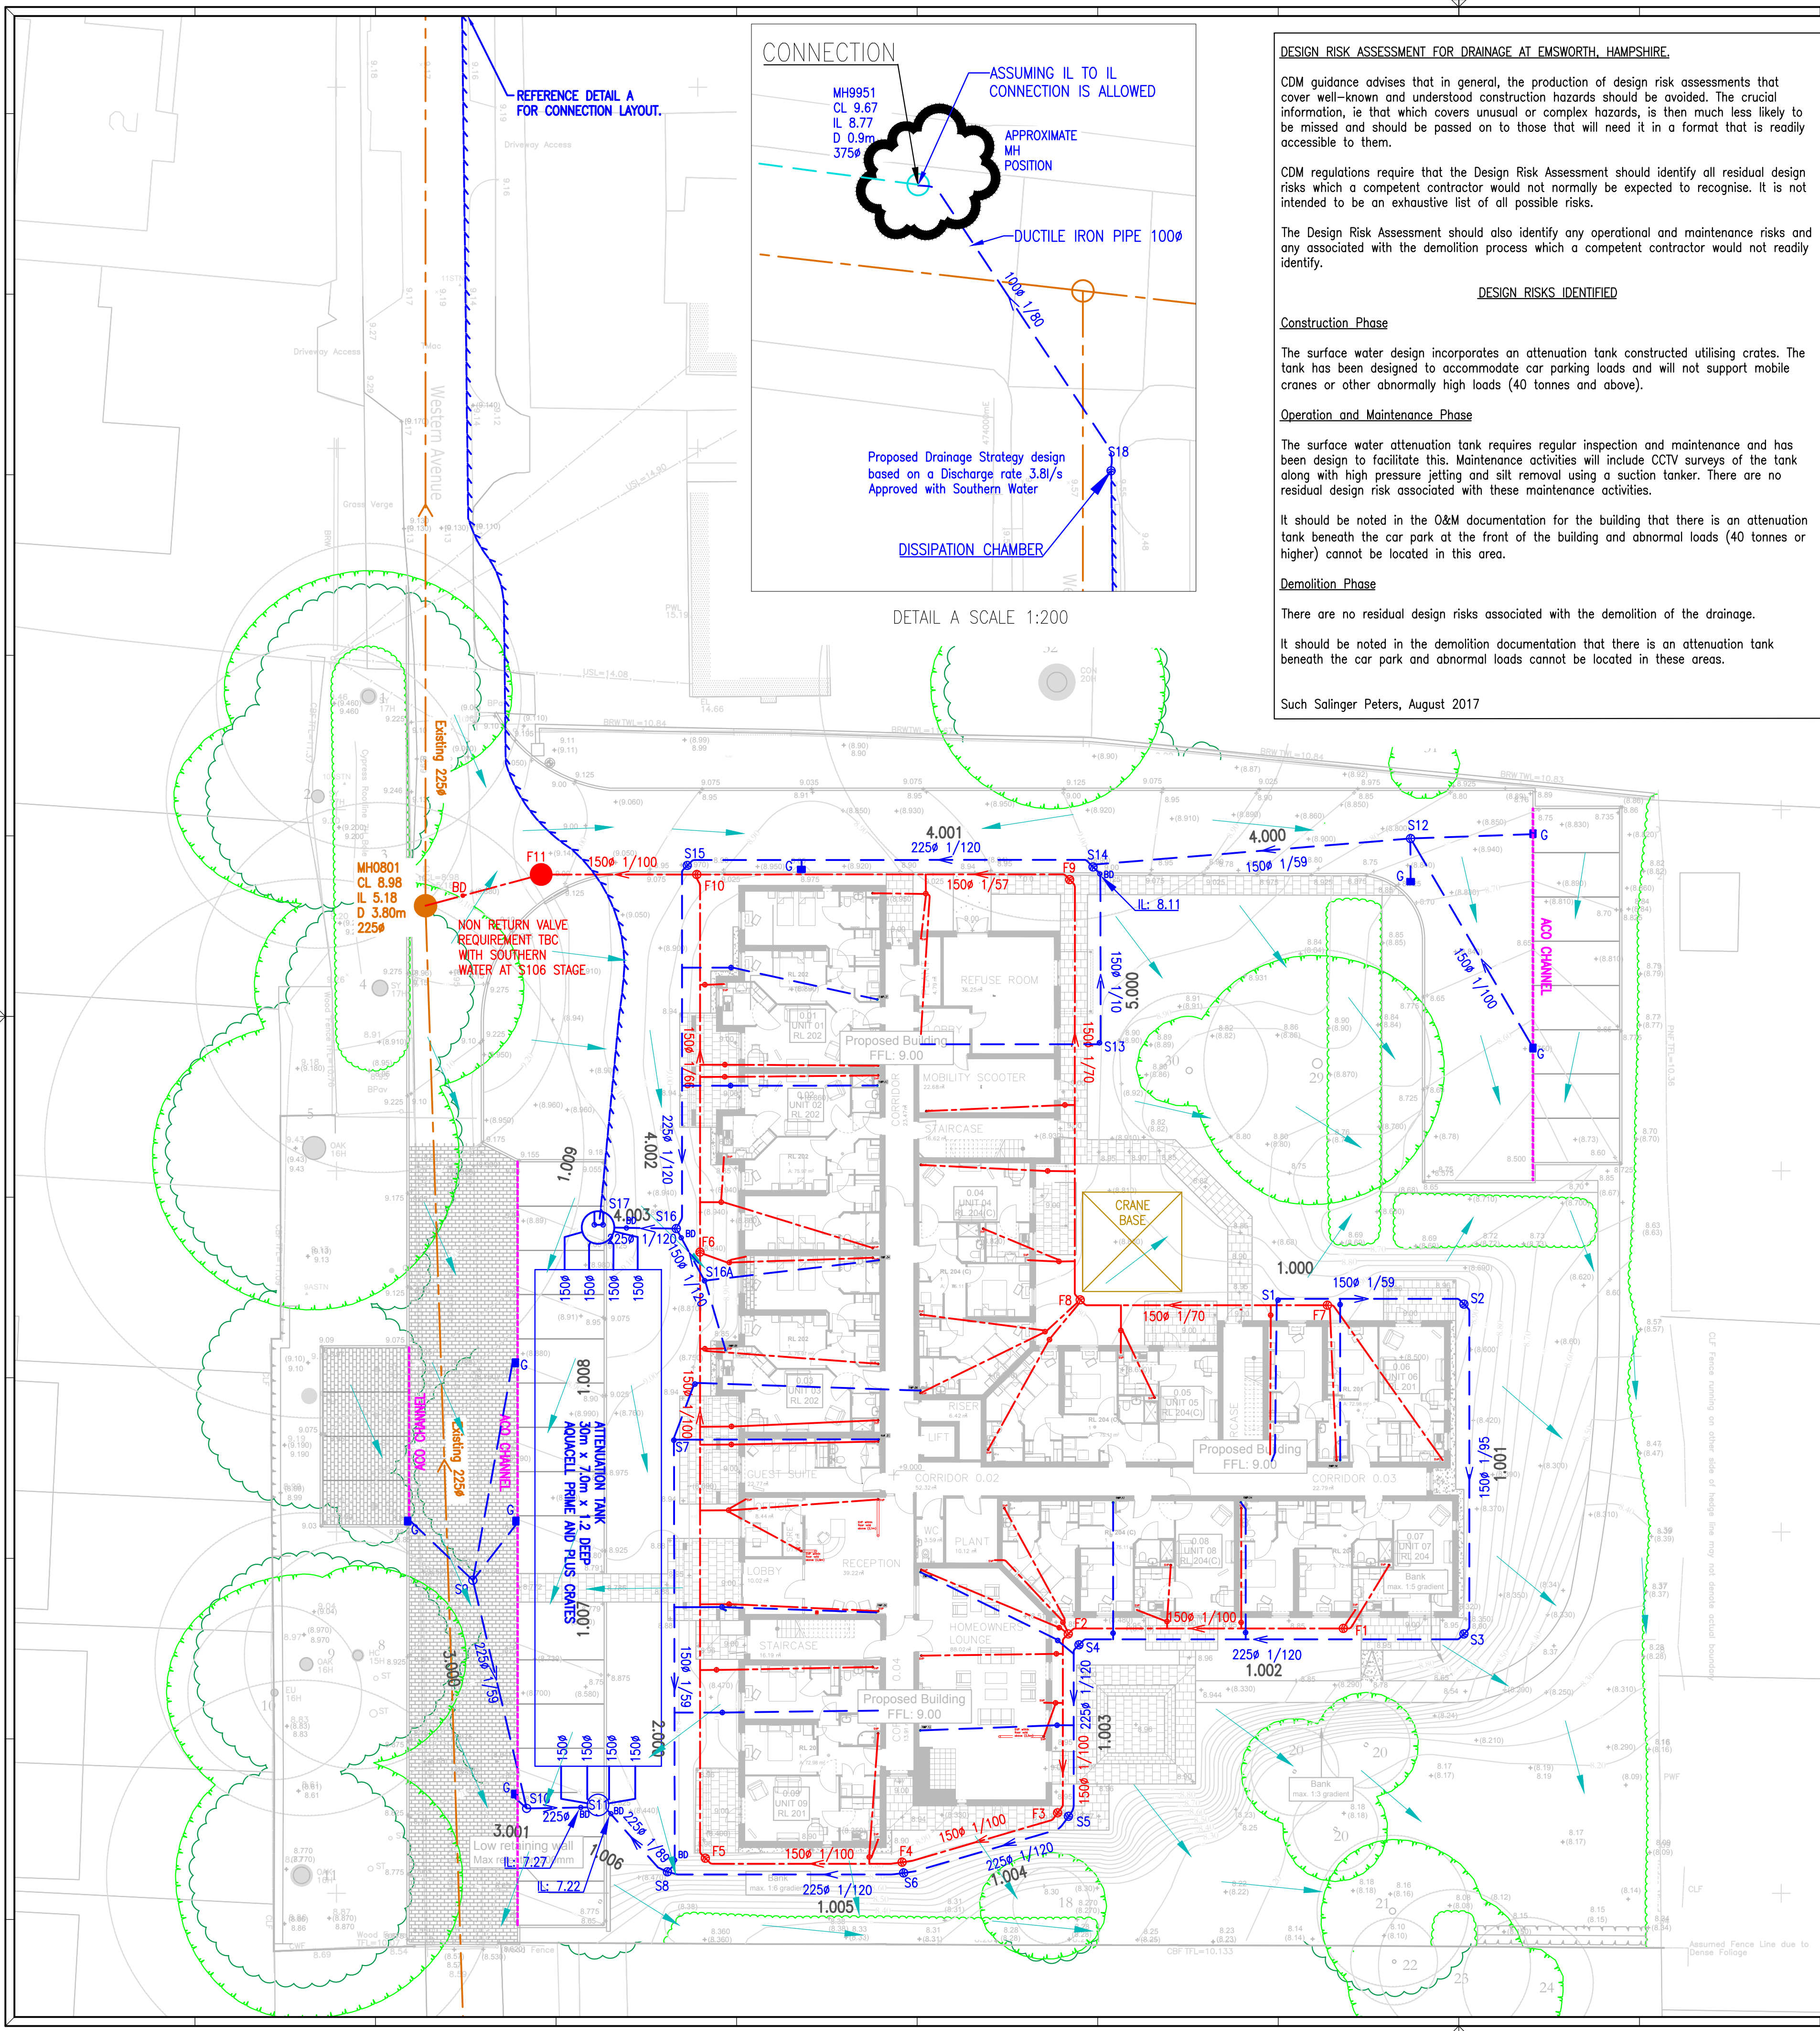

FOUL MANHOLE SCHEDULE

MH No.	COVER	INVERT LEVEL		DEPTH	MAX PIPE	MH	COVER TYPE
		IN	OUT				
F1	8.95	7.84	7.84	1.11	150	3	A15
F2	8.85	7.69	7.69	1.16	150	3	A15
F3	8.80	7.59	7.59	1.21	150	3*	A15
F4	8.80	7.50	7.50	1.30	150	3*	A15
F5	8.85	7.39	7.39	1.46	150	3*	A15
F6	9.00	7.06	7.06	1.94	150	3*	A15
F7	8.90	7.69	7.69	1.21	150	3	A15
F8	8.80	7.50	7.50	1.30	150	3*	A15
F9	9.07	7.17	7.17	1.90	150	3*	A15
F10	9.05	6.75	6.75	2.30	150	3*	A15
F11	9.02	6.65	6.65	2.37	150	2	D400

ALL LEVELS TBC BEFORE WORKS AND REPORTED BACK TO ENGINEER.
ALL PIPEWORK TO BE 100 Ø AT MIN. 1/70 UNLESS STATED OTHERWISE.
* RESTRICTED ACCESS.

SURFACE WATER MANHOLE SCHEDULE

MH No.	COVER	INVERT LEVEL		DEPTH	MAX PIPE	MH	COVER TYPE
		IN	OUT				
S1	8.95	–	8.30	0.65	150	4	A15
S2	8.95	8.03	8.03	0.92	150	3	A15
S3	8.80	7.85	7.85	0.95	150	3	A15
S4	8.85	7.63	7.56	1.29	225	3*	A15
S5	8.82	7.46	7.46	1.36	225	3*	A15
S6	8.70	7.38	7.38	1.32	225	3*	A15
S7	8.94	–	8.30	0.64	150	4	A15
S8	8.75	7.27	7.27	1.48	225	3*	A15
S9	8.80	–	7.55	1.25	225	3*	D400
S10	8.70	7.33	7.33	1.37	225	3*	D400
S11	8.70	7.21	6.45	2.25	225	1200	D400
S12	8.78	–	7.55	1.23	150	3*	D400
S13	8.95	–	8.30	0.65	100	4	A15
S14	9.00	7.25	7.25	1.75	150	3*	D400
S15	8.97	7.02	6.95	2.02	225	3*	D400
S16A	9.02	–	8.30	0.72	150	4	A15
S16	9.05	6.70	6.70	2.35	225	3*	A15
S17	9.00	6.74	6.35	2.65	225	2100	D400
S18	9.56	9.01	9.01	0.55	150	3	D400
9951	9.67	8.77	8.77	0.90	375	Ex	Ex

ALL LEVELS TBC BEFORE WORKS AND REPORTED BACK TO ENGINEER.
ALL PIPEWORK TO BE 100 Ø AT MIN. 1/80 UNLESS STATED OTHERWISE.
* RESTRICTED ACCESS.
S14 TO HOUSE PUMPING STATION WITH 2 PUMPS WORKING; ONE DUTY AND ANOTHER STANDBY AT 3.8l/s.
S8 AND S14 TO HAVE ADDITIONAL 500mm DEEP SILT TRAP

ATTENUATION TANK SCHEDULE

PLAN DIMENSIONS	EFFECTIVE DEPTH	TOP OF TANK	BASE OF TANK	LOWEST COVER LEVEL	LOWEST IL IN	MAX. CONSTRUCTION DEPTH
30 x 7m	1.2	7.65–7.55	6.45–6.35	8.85	6.45	2.50

NOTES:

- ALL DIMENSIONS IN MILLIMETRES UNLESS OTHERWISE STATED.
- ALL LEVELS IN METRES ABOVE ORDNANCE DATUM.
- SURFACE WATER DESIGN BASED ON A 1 IN 100 YEAR RAINFALL EVENT (PLUS 40% CLIMATE CHANGE) REMAINING BELOW GROUND WITH NO RISK OF SURFACE FLOODING ON OR OFF THE SITE.
- MANHOLE TYPES ON THE SCHEDULES RELATE TO TYPES AS USED IN SEWERS FOR ADOPTION 7TH EDITION. REFER TO CONSTRUCTION DRAWINGS IN THE SERIES FOR STANDARD DETAILS.
- WHERE A SPECIFIC DIAMETER IS SHOWN IN THE MANHOLE SCHEDULE (EG. 2100), THE MANHOLE SHOULD BE CONSTRUCTED TO THE STANDARDS FOR EITHER A TYPE 1 OR TYPE 2 MANHOLE IN SEWERS FOR ADOPTION 7TH EDITION.
- MANHOLES NOT SCHEDULED ARE TYPE 4 INSPECTION CHAMBERS.
- ALL RWP AND SVP CONNECTING PIPEWORK TO BE 100Ø UNLESS NOTED OTHERWISE.
- 100Ø FOUL PIPEWORK TO BE LAID NO FLATTER THAN 1 IN 40 INTERNALLY AND 1 IN 70 EXTERNALLY.
- MINIMUM DEPTH AT HEAD OF INTERNAL SURFACE WATER TO BE 450MM AND FOUL WATER RUNS TO BE 750MM BELOW FINISHED FLOOR LEVEL UNLESS OTHERWISE STATED.
- FOUNDATIONS TO BE LOCALLY STEPPED WHERE NECESSARY AS PER STRUCTURAL ENGINEERS DETAILS. WHERE SUB STACKS ARE USED, SPECIAL DETAILS WILL BE PROVIDED.
- PUBLIC MANHOLE DETAILS FROM PUBLIC SEWER RECORDS.
- AREA CONTRIBUTING TO THE SW SYSTEM TAKEN AS 2350 m².
- THIS DRAWING IS FOR STRATEGY PURPOSES ONLY AND MUST NOT BE USED FOR CONSTRUCTION.
- FORMAL APPLICATION AND APPROVAL FOR CONNECTIONS INTO PUBLIC SYSTEM MUST BE OBTAINED BEFORE WORKS.
- SOIL INVESTIGATION LOOKING @ 500mm INFILTRATION TESTS AFTER PLANNING FOR POSSIBLE PERMEABLE PAVING OPTION.

PRELIMINARY
ONLY

REV	DESCRIPTION	DATE	BY	CHK	APP	DATE
G	New RWP locations added into layout. Indicative directional flow of runoff added.	DL	KD	KD		03.08.2017
F	Updated drawing with proposed levels. Updated cover levels on manholes.	DL	KD	KD		02.08.2017
E	Added the CDM note onto the drawing.	DL	KD	KD		24.07.2017
D	Rising main route amended	DL	PP	KD		06.06.2017
C	Rising Main route amended	KD	PP	KD		25.05.2017
B	Rising main and attenuation tank moved as requested. F11 moved back and RP'S added.	KD	DL	KD		25.05.2017
A	FIRST ISSUE	DL	KD	KD		19.05.2017
MX	REVISIONS	DRN	CHK	APP		DATE

Such·Salinger·Peters
CONSULTING ENGINEERS

Fourth Floor
Dean Park House
10 Dean Park Crescent
Bournemouth, Dorset, BH1 1HL
Tel (01202) 293 213
enquiries@spsconsulting.co.uk www.spsconsulting.co.uk

CLIENT: MCCARTHY AND STONE
SOUTHERN REGION

PROJECT: THE ORCHARD HOUSE
EMSWORTH

DRAWING TITLE: 'T' BUILDING
DRAINAGE LAYOUT

SCALE: 1:200 DATE: 03/08/2017

DRAWN: DL CHECKED: KD APPROVED: KD

DRAWING No. 64007-03 REVISION: F