



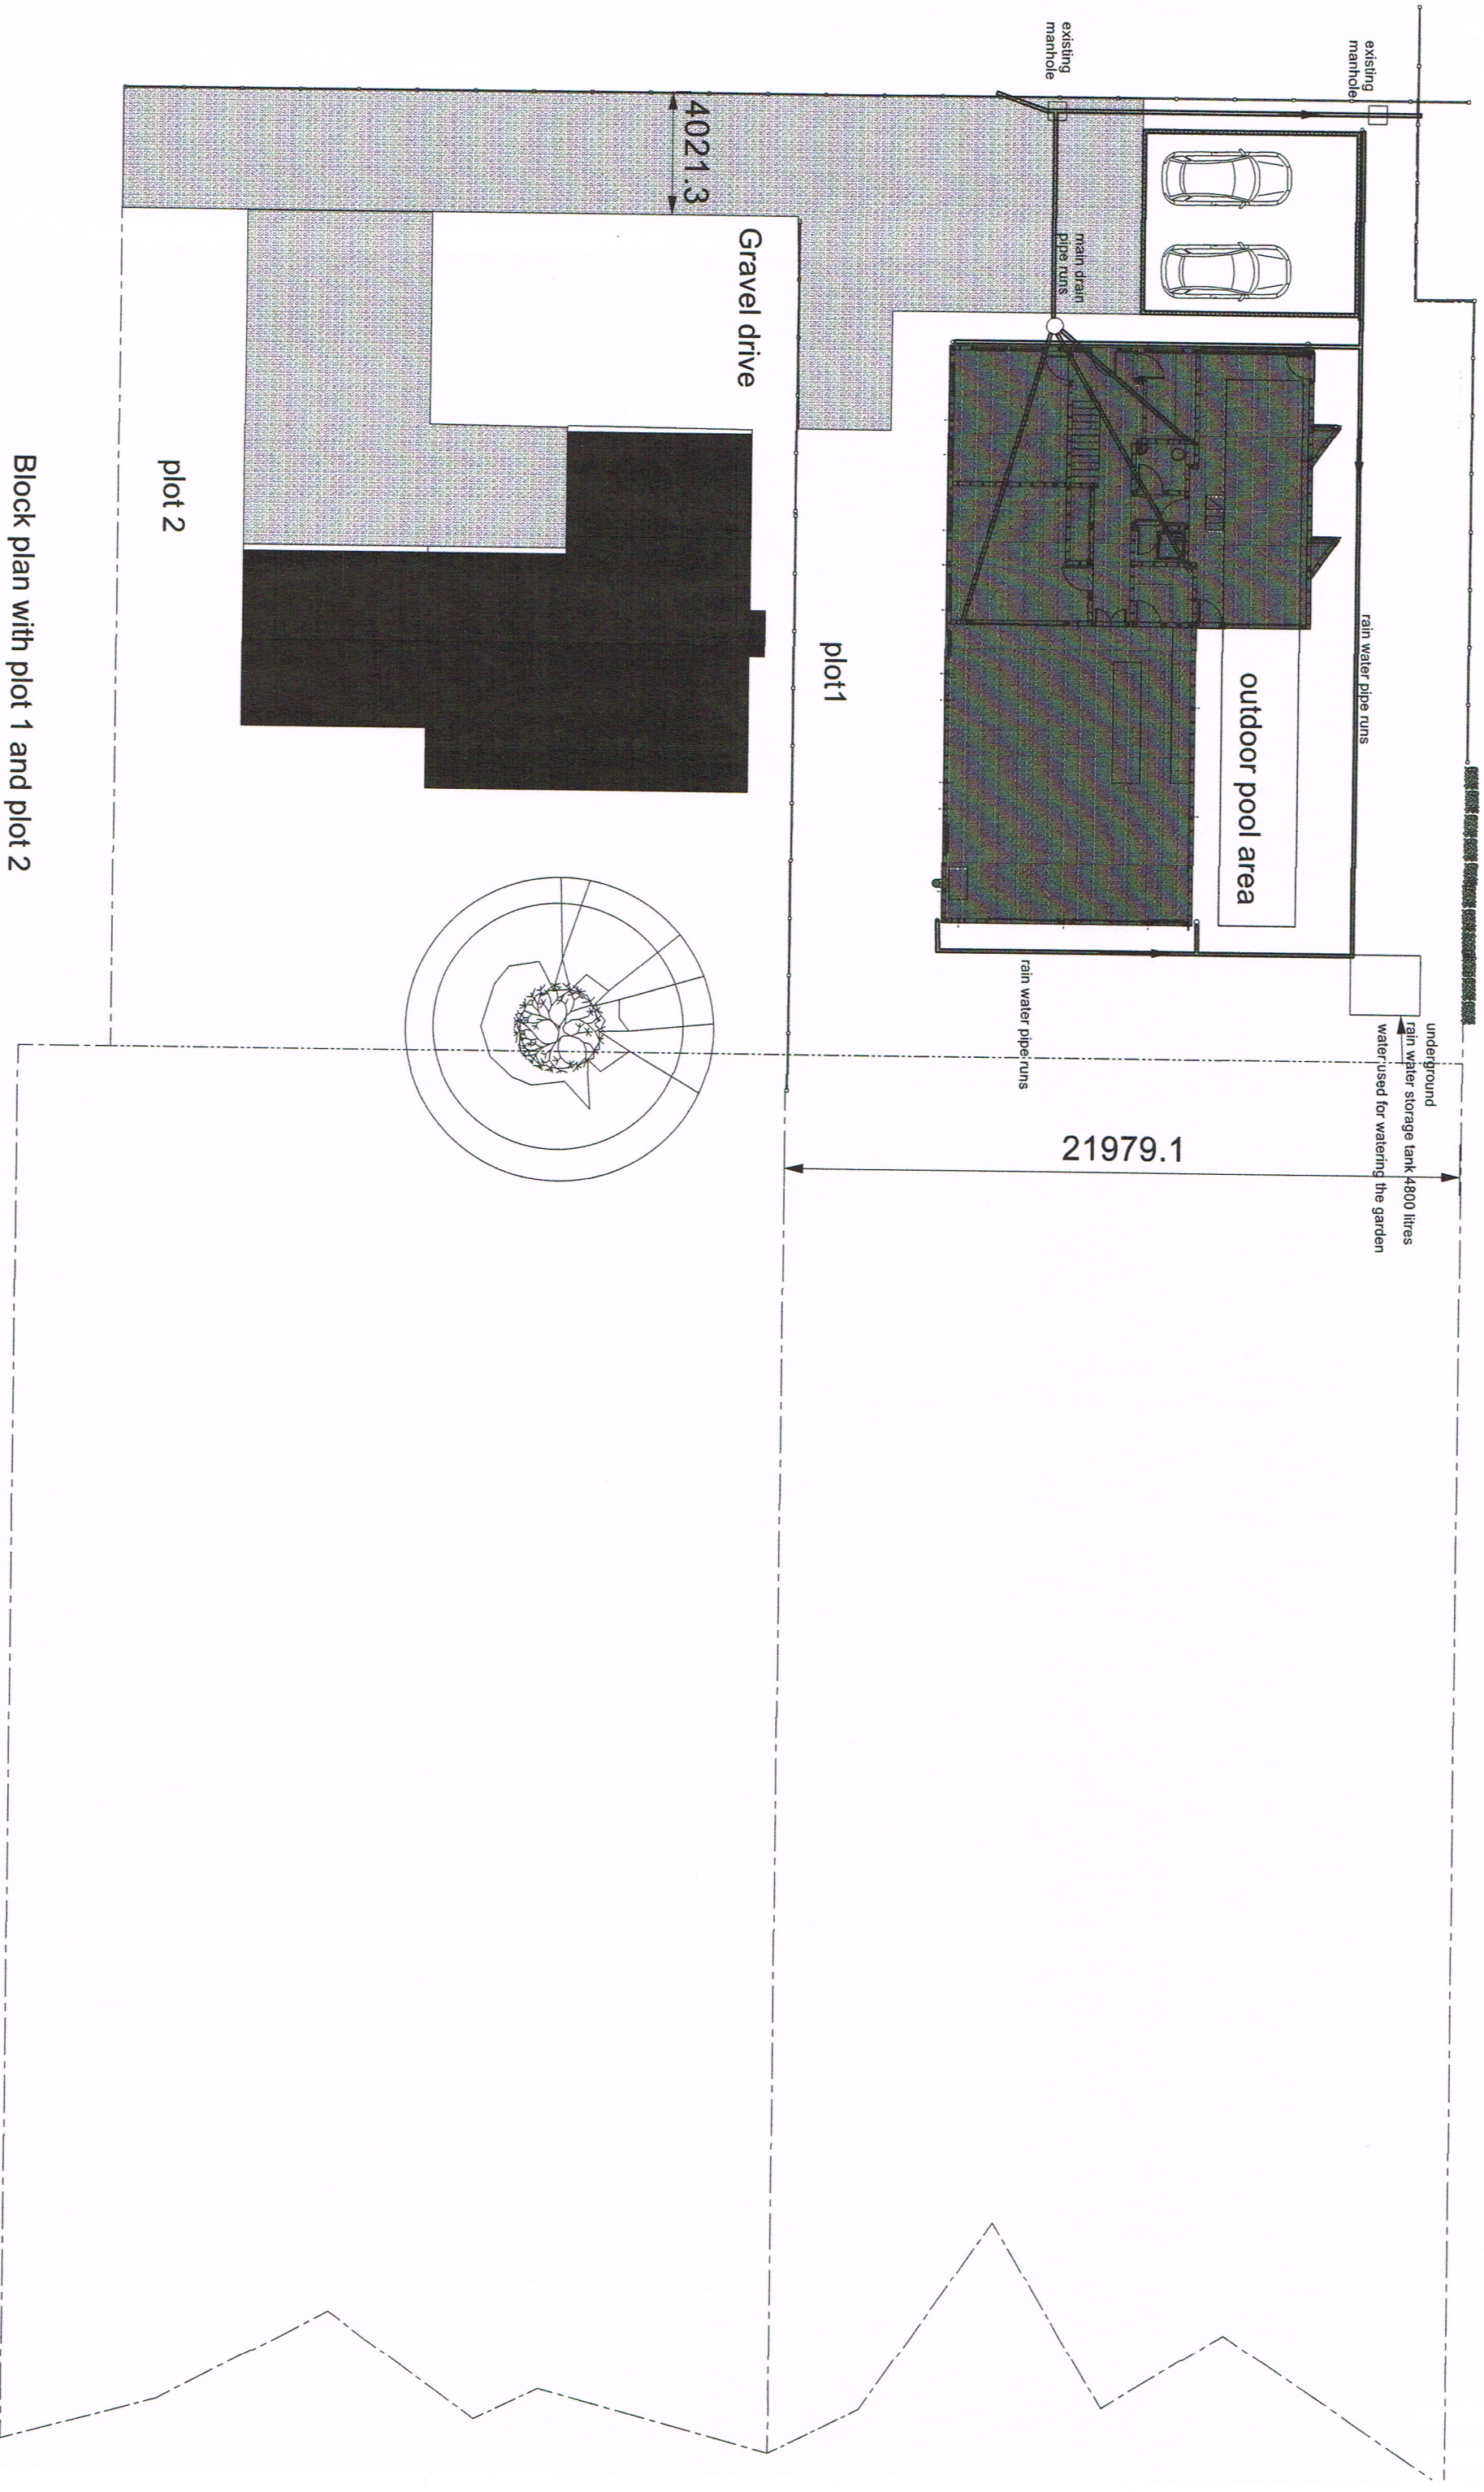

existing manhole
rain water pipe runs
underground
rain water storage tank 4800 litres
water used for watering the garden

outdoor pool area

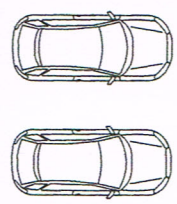

existing manhole

main drain pipe runs

rain water pipe runs

plot1

Gravel drive

4021.3

plot 2

Block plan with plot 1 and plot 2



Date sept 2016

Peter Milburn
Peter Hewlins Designs
128 Duke Road
London
W4 2DF
Mobile: 07973 814 108

Email: phewlins@aol.com

HEWLINS HOUSE

Proposed Ground Floor Plan 200

0 5 1 2 3 4 5 6 7 8 9 10m

Scale 1:200
on A3

Site: Plot 1 next to the Retreat
Croft Lane
Hayling Island
Drawing No Block plan 1 + 2

updated showing rain water and soil drain runs