


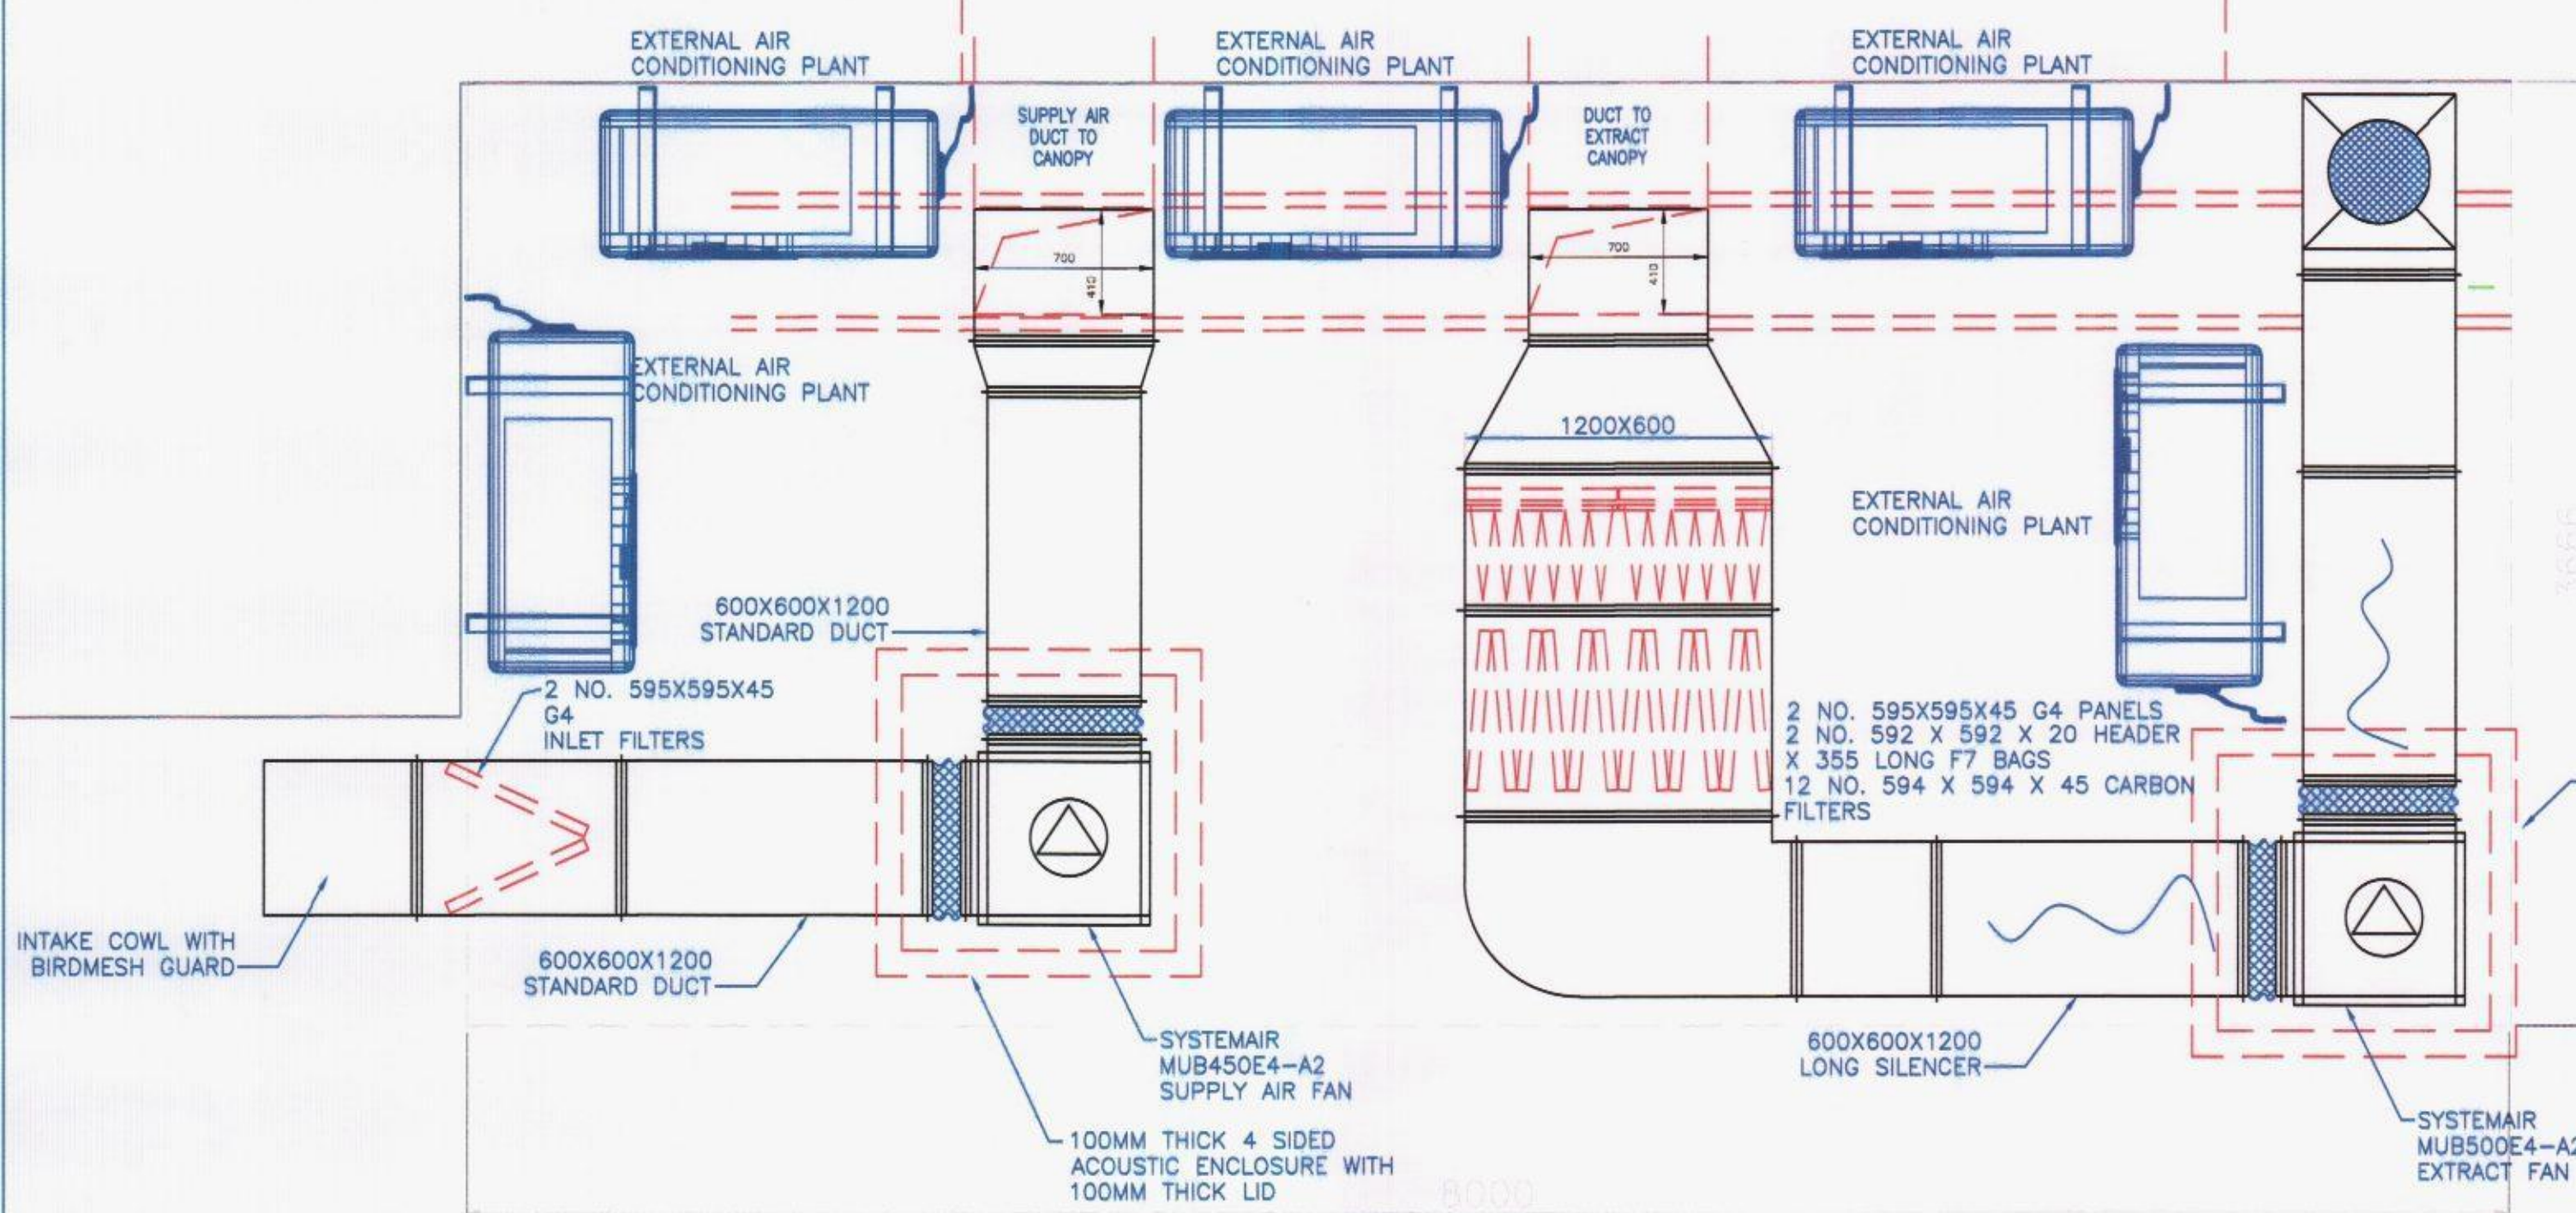


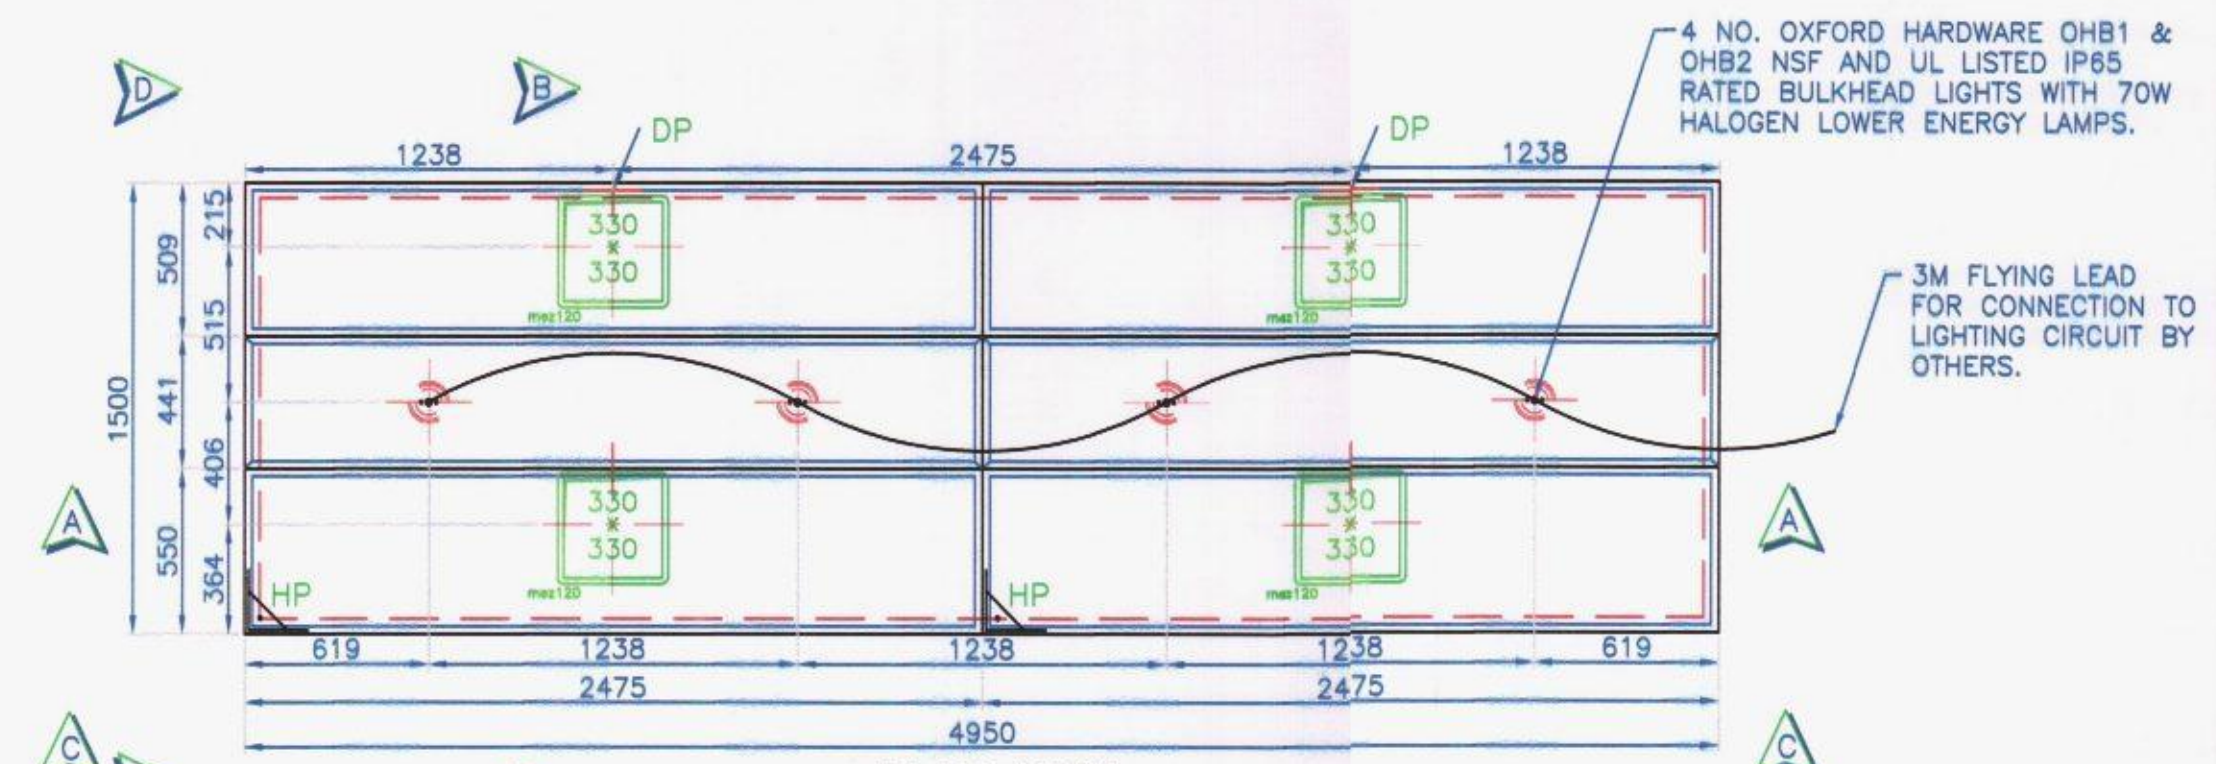


PLAN VIEW
ROOFSIDE VENTILATION, ODOUR REDUCTION AND ATTENUATION PLANT

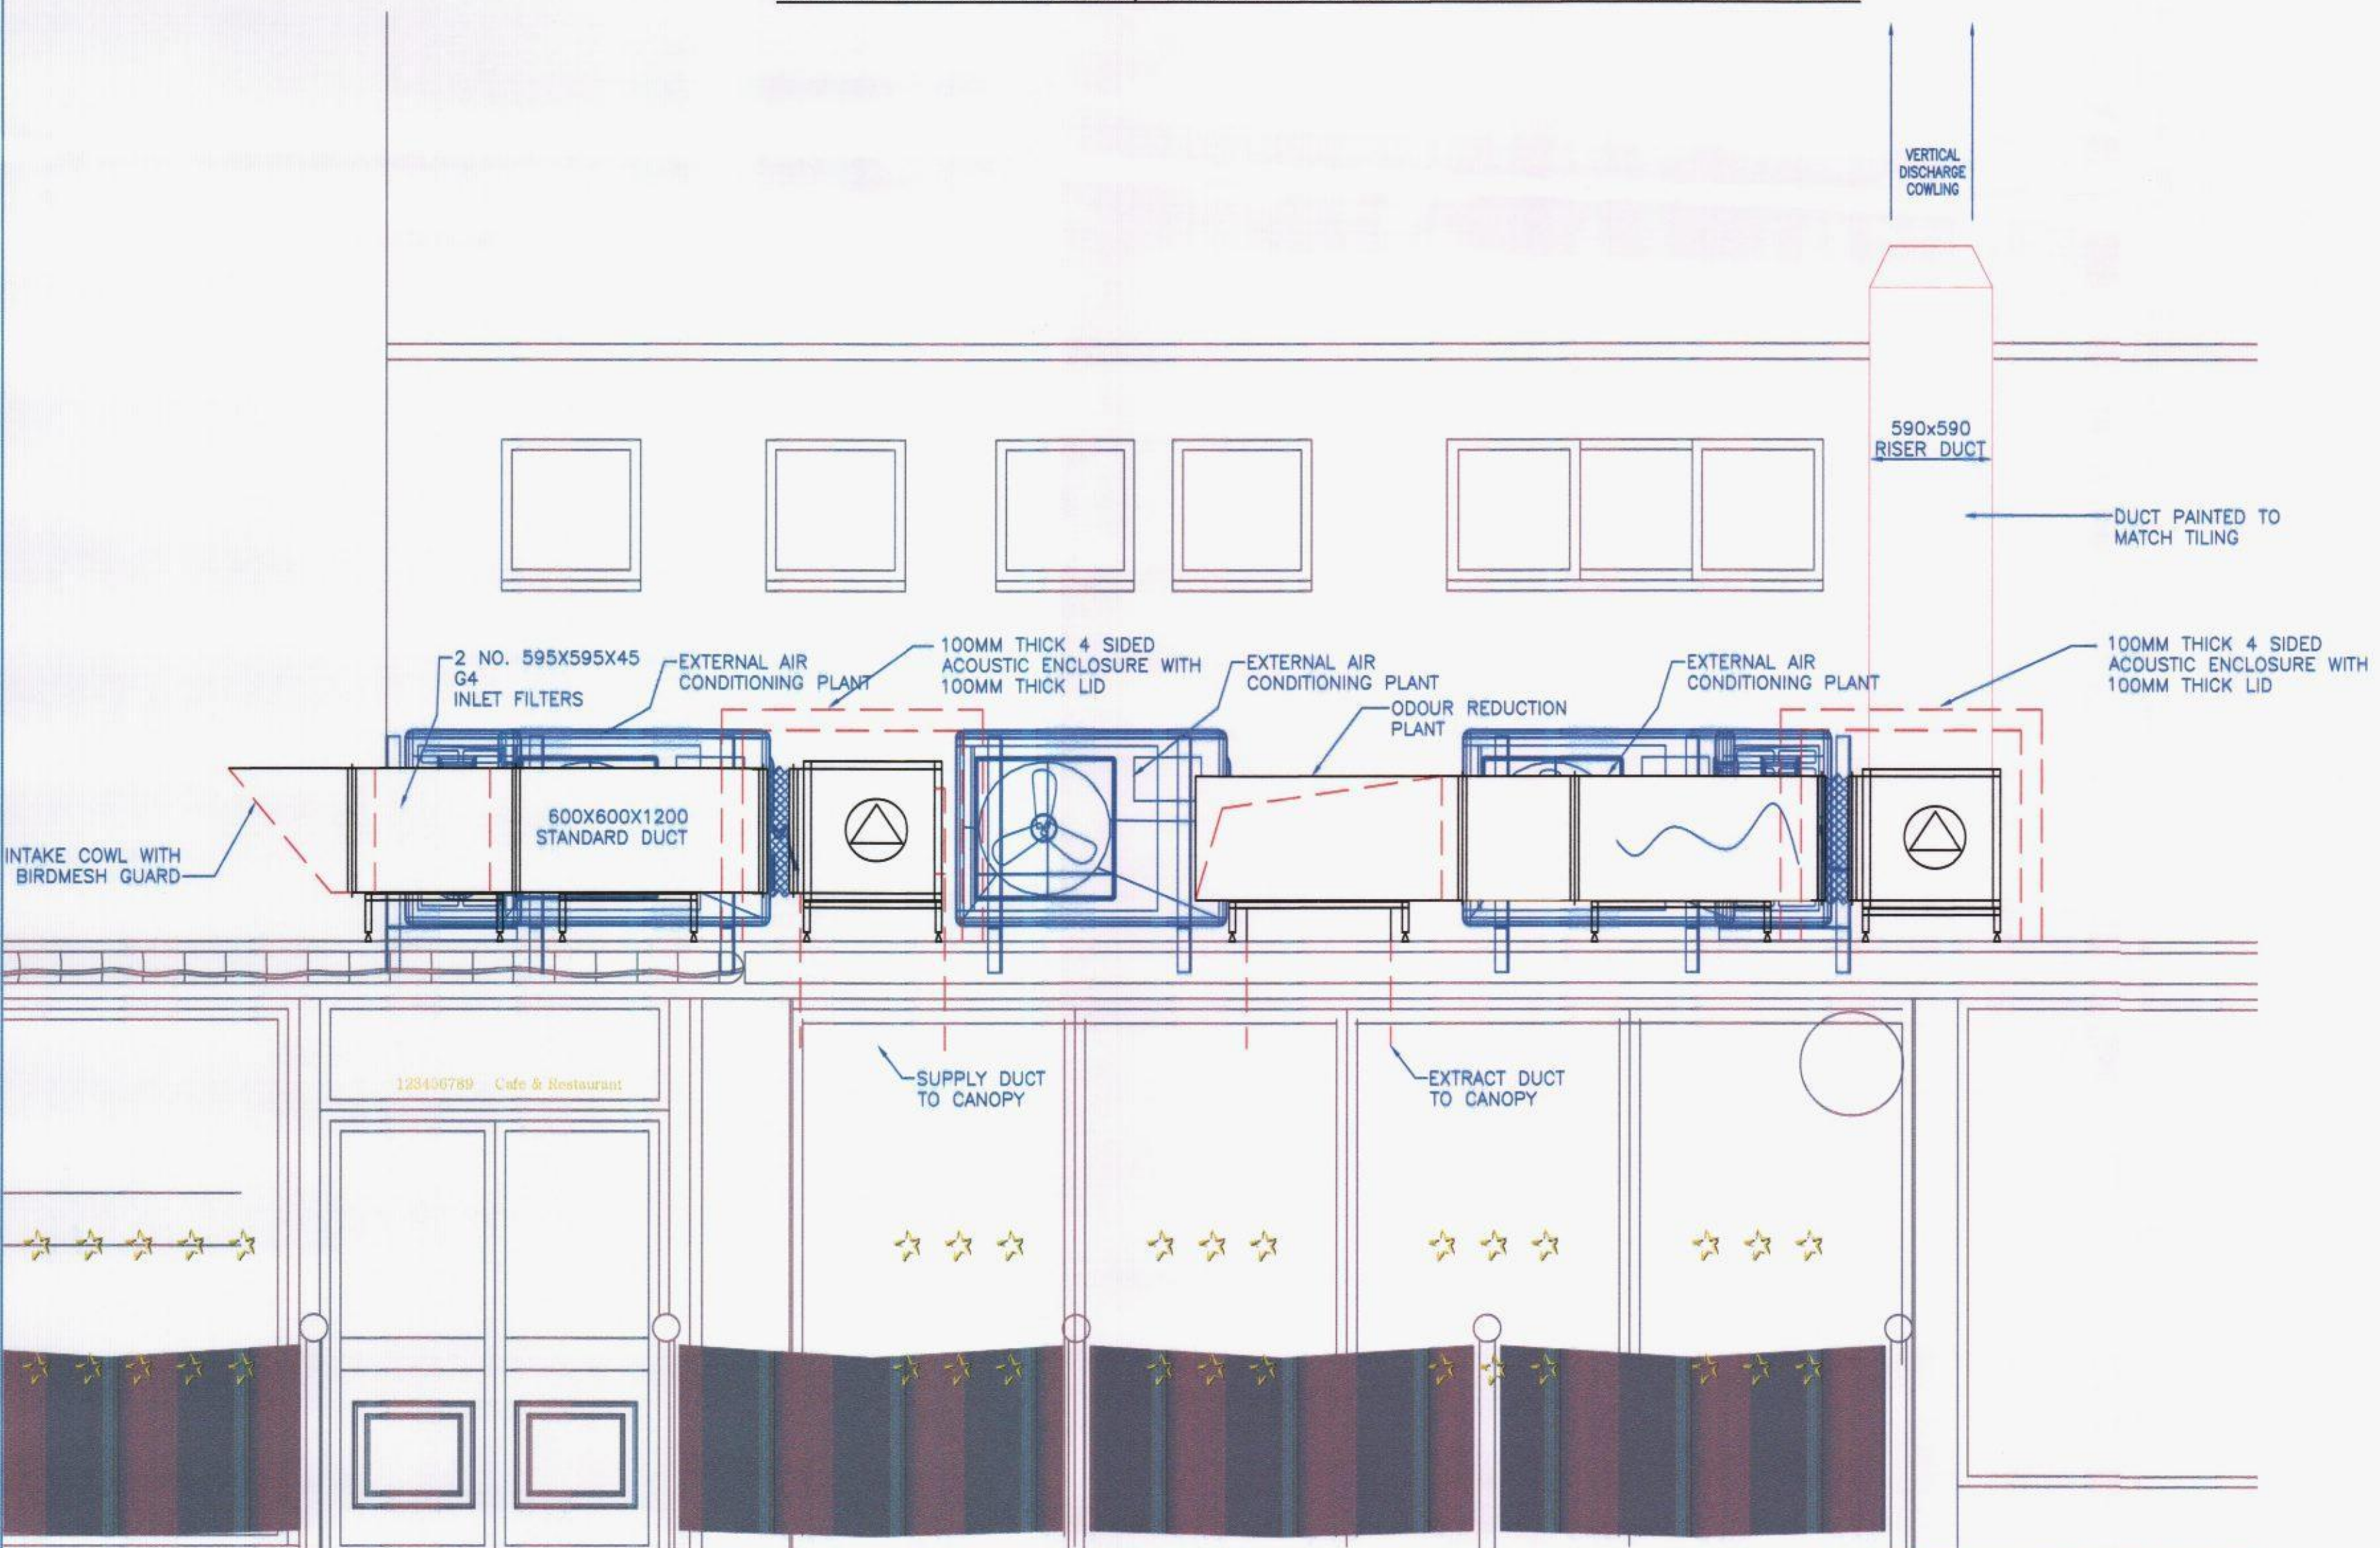


PLAN VIEW
MAIN KITCHEN CANOPY

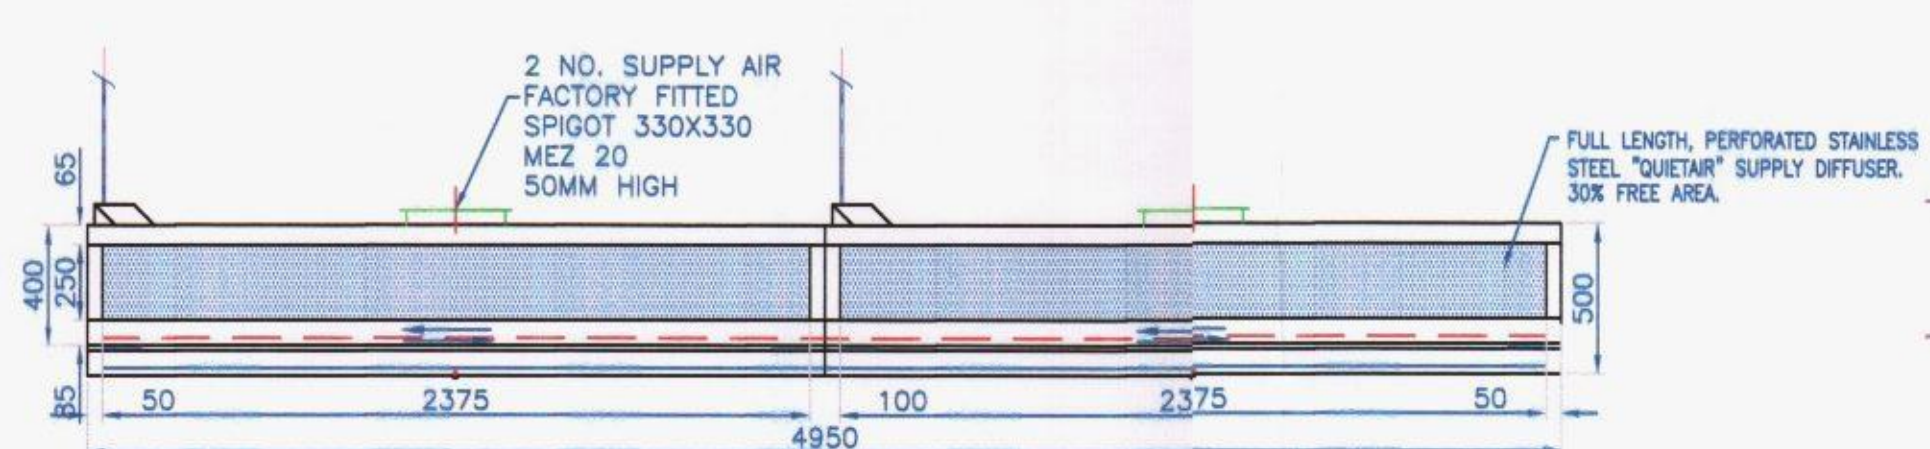


FRONT ELEVATION C-C

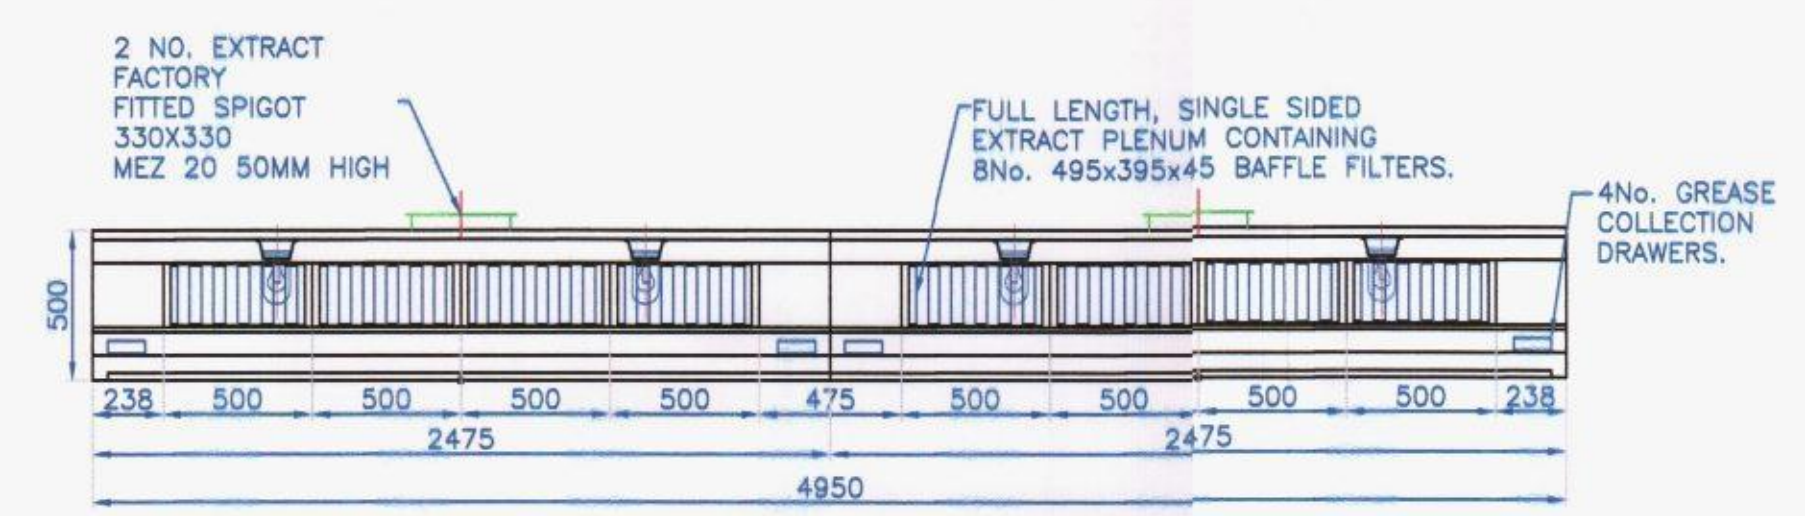


SECTION A-A

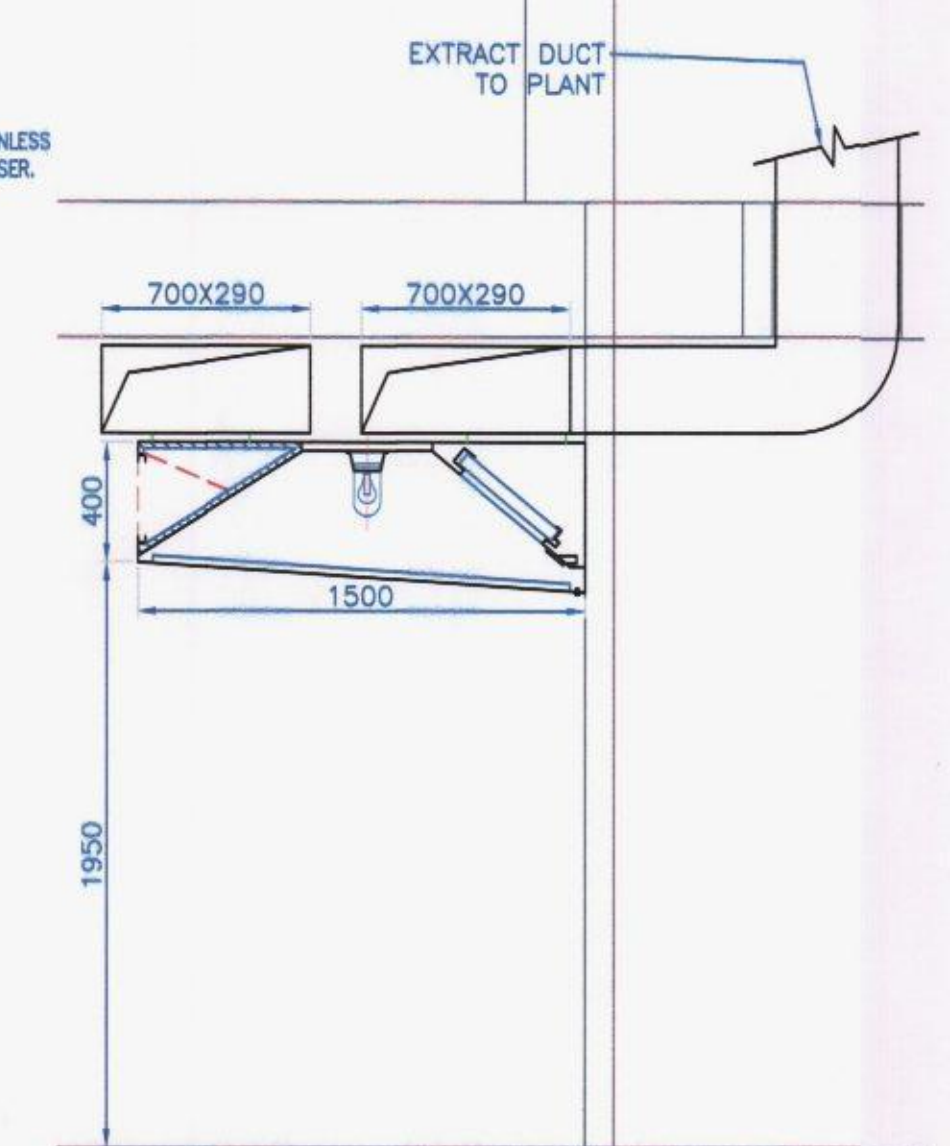


SECTION E-E

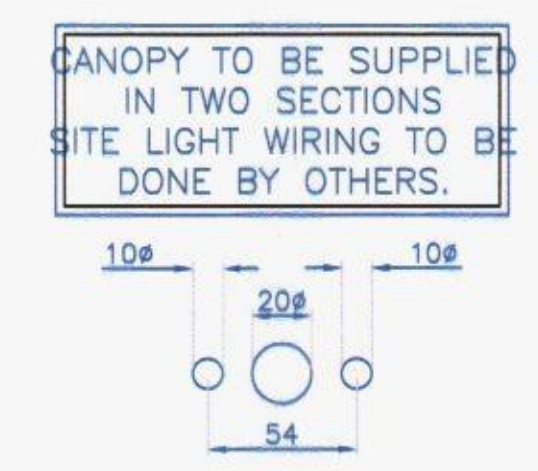


4 NO. CANOPY LIGHT
FACTORY PUNCHING DETAIL
LIGHTS SHALL BE SITE FITTED BUT
HOLES SHALL BE FACTORY PUNCHED

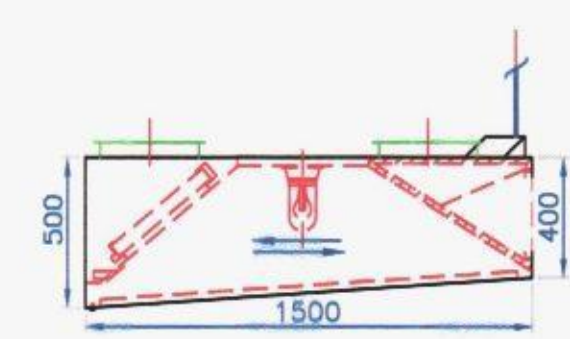

SIDE ELEVATION D-D

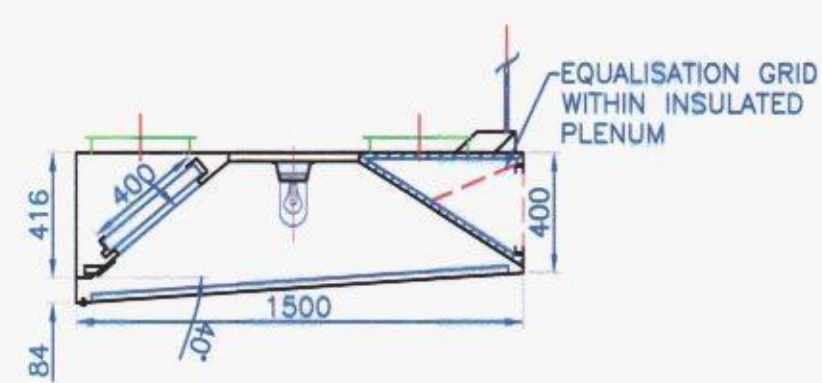

SECTION B-B

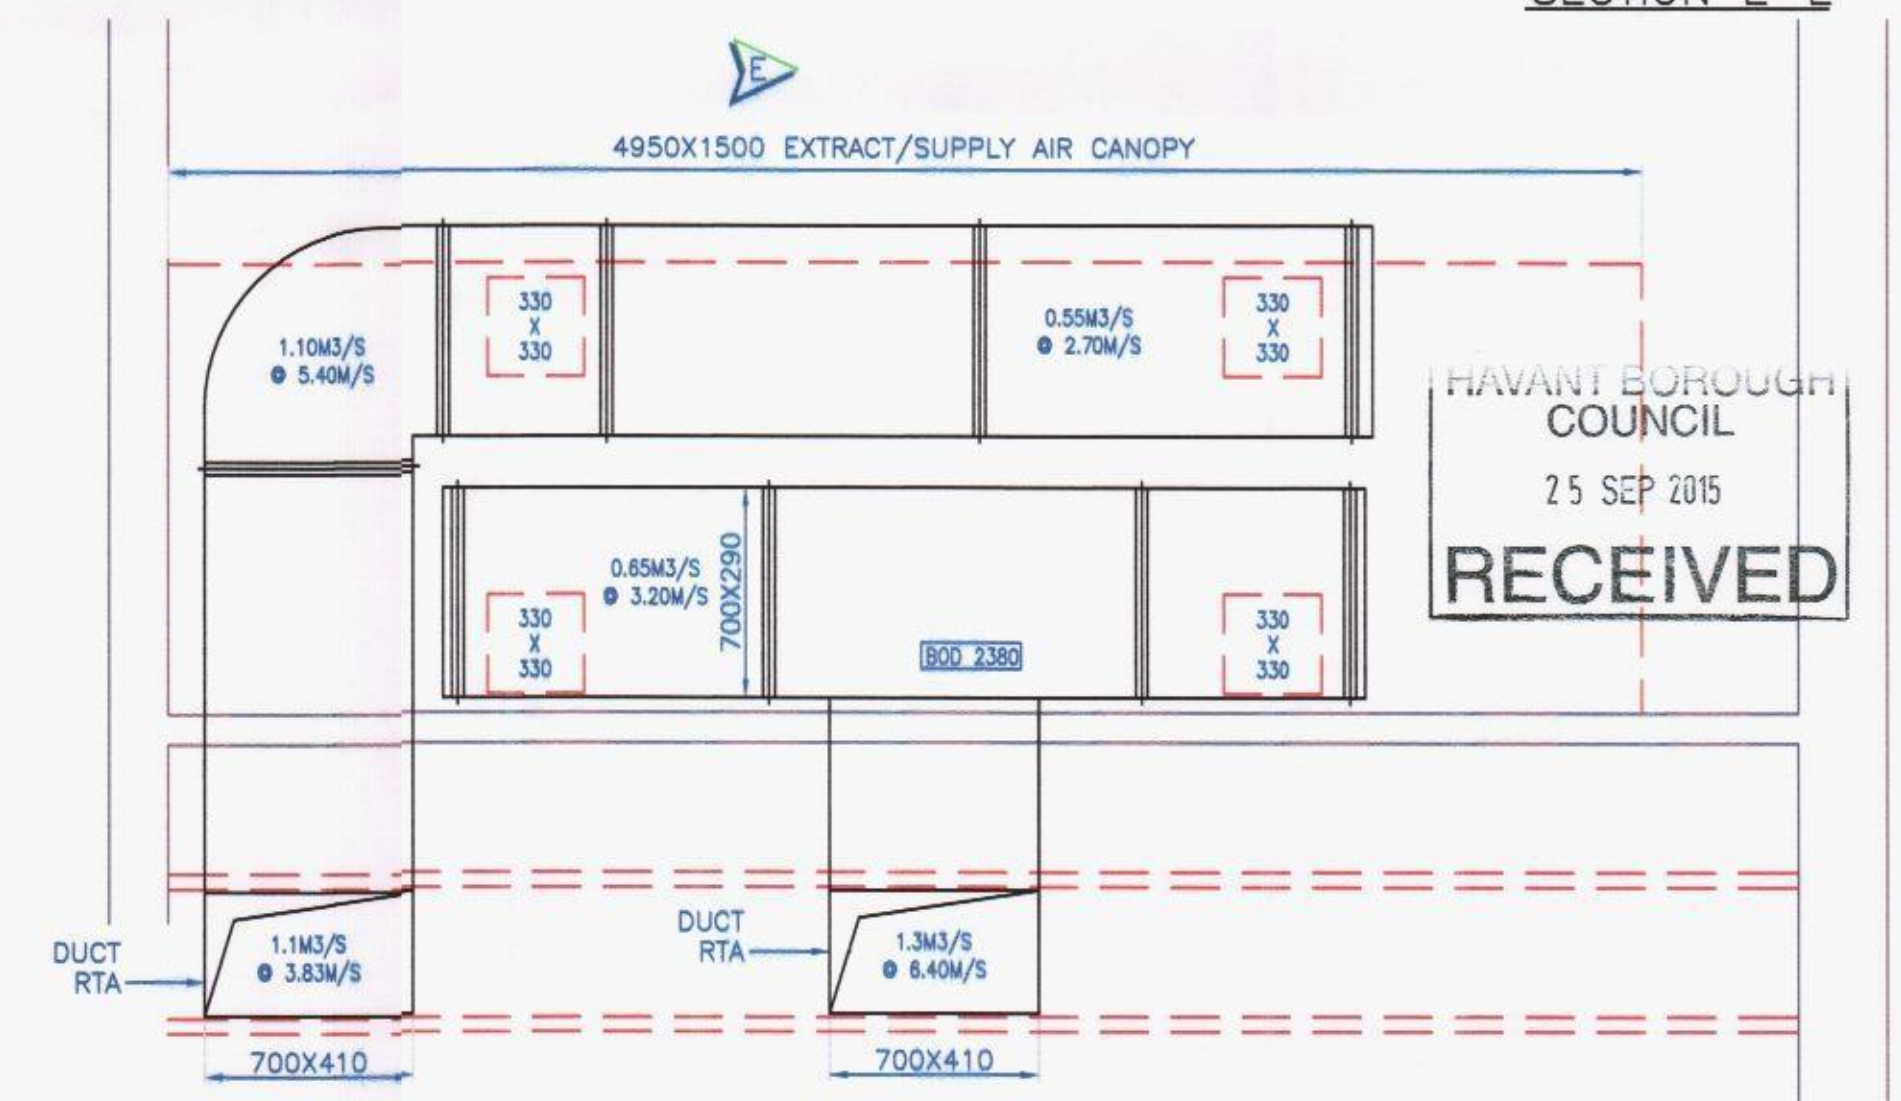

PLAN VIEW
MAIN KITCHEN CANOPY & INTERNAL DUCTWORK

Client	GRASTAR	A			
Project	HAVANT				
Title	EXTRACT /AIR CON SYSTEM				
Drawn	CHK	Checked	Contract No.	2015-19	
Date	21/09/2015	Scale	1:25 A1	Drawing No.	2015-19-02