


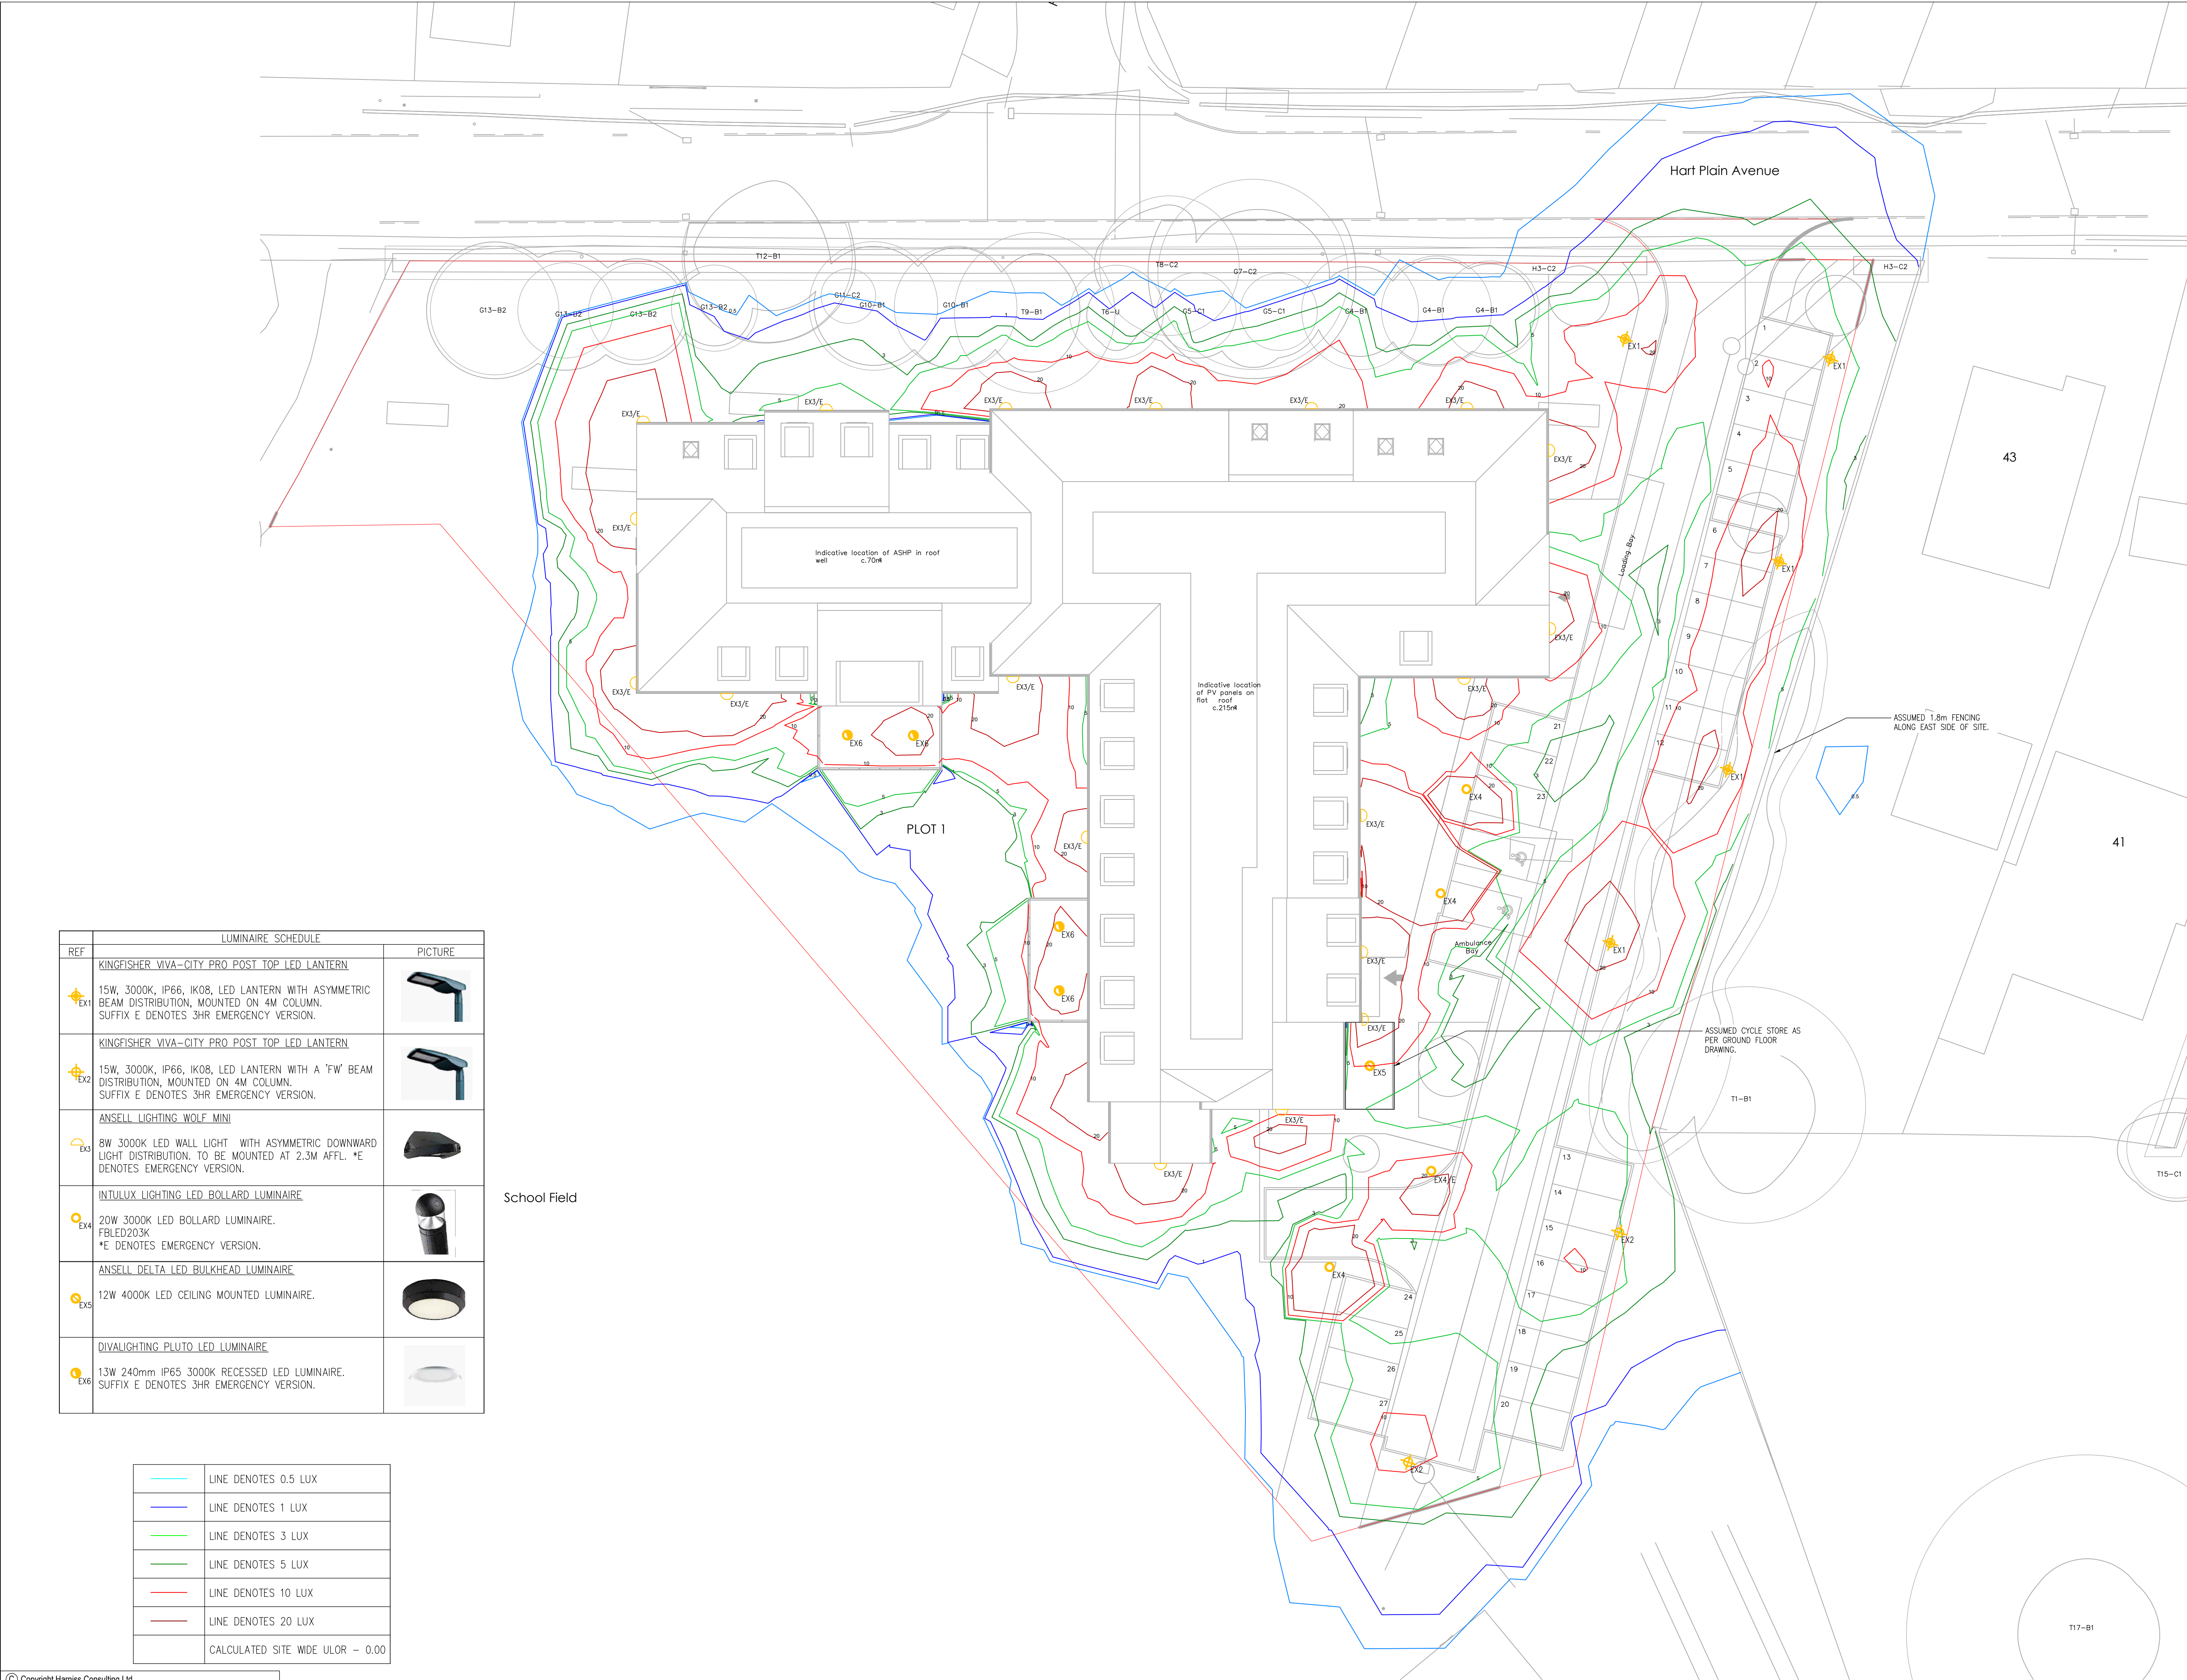

- NOTES:
- THIS DRAWING ILLUSTRATES OUTLINE DESIGN INTENT ONLY. IT IS SUBJECT TO DESIGN DEVELOPMENT & COORDINATION.
 - THIS DRAWING IS NOT TO BE SCALED.
 - ALL DIMENSIONS STATED IN mm.
 - LOCATION OF COLUMNS TO BE CO-ORDINATED WITH EXTERNAL FINISHES.
 - FINAL SETTING OUT DETAILS TO BE ADVISED BY ARCHITECT / LANDSCAPE ARCHITECT.
 - LUMINAIRES SHALL BE CONTROLLED VIA A COMBINATION OF PHOTOCELL, TIME CLOCK & PIR CONTROLS. THE TIME SWITCH SHALL SWITCH OFF THE LIGHTS BETWEEN 23:00PM & 6:00AM.

THE CONCEPTUAL DESIGN DOCUMENTATION IS BASED ON PERFORMANCE DUTIES WHICH REPRESENT AN AGREED SERVICING STRATEGY AND THE MINIMUM PERFORMANCE STANDARDS TO BE ACHIEVED. THE DRAWINGS PRODUCED BY HARNISS ARE INTENDED TO STEER THE D&B CONTRACTOR TOWARDS AN APPROPRIATE SOLUTION TO MEET THE EMPLOYERS REQUIREMENTS AND THUS PROVIDE GUIDANCE AS TO THE DESIGN INTENT. ANY SIZES SHOWN ON THESE INTENT DRAWINGS ARE INDICATIVE AND ONLY FOR THE PURPOSE OF IDENTIFYING INITIAL SPATIAL COORDINATION WITH THE BUILDING ARCHITECTURE. THE DESIGN AND BUILD CONTRACTOR MUST SATISFY THEMSELVES THAT THE SOLUTIONS OFFERED BY THEM, BASED ON THE DESIGN INTENT, CAN BE ACHIEVED WITHIN THE PROJECT CONSTRAINTS. THE DESIGN AND BUILD CONTRACTOR IS REQUIRED UNDER THE CONTRACT TO SUBMIT DRAWINGS AND TECHNICAL SUBMITTALS FOR ALL ASPECTS OF THEIR DETAILED DESIGN FOR REVIEW AND COMMENT PRIOR TO COMMENCEMENT OF THE WORKS.

LUMINAIRE SCHEDULE		
REF		PICTURE
EX1	KINGFISHER VIVA-CITY PRO POST TOP LED LANTERN 15W, 3000K, IP66, IK08, LED LANTERN WITH ASYMMETRIC BEAM DISTRIBUTION, MOUNTED ON 4M COLUMN. SUFFIX E DENOTES 3HR EMERGENCY VERSION.	
EX2	KINGFISHER VIVA-CITY PRO POST TOP LED LANTERN 15W, 3000K, IP66, IK08, LED LANTERN WITH A 'FW' BEAM DISTRIBUTION, MOUNTED ON 4M COLUMN. SUFFIX E DENOTES 3HR EMERGENCY VERSION.	
EX3	ANSELL LIGHTING WOLF MINI 8W 3000K LED WALL LIGHT WITH ASYMMETRIC DOWNWARD LIGHT DISTRIBUTION. TO BE MOUNTED AT 2.3M AFFL. *E DENOTES EMERGENCY VERSION.	
EX4	INTULUX LIGHTING LED BOLLARD LUMINAIRE 20W 3000K LED BOLLARD LUMINAIRE. FBLED203K *E DENOTES EMERGENCY VERSION.	
EX5	ANSELL DELTA LED BULKHEAD LUMINAIRE 12W 4000K LED CEILING MOUNTED LUMINAIRE.	
EX6	DIVALIGHTING PLUTO LED LUMINAIRE 13W 240mm IP65 3000K RECESSED LED LUMINAIRE. SUFFIX E DENOTES 3HR EMERGENCY VERSION.	

	LINE DENOTES 0.5 LUX
	LINE DENOTES 1 LUX
	LINE DENOTES 3 LUX
	LINE DENOTES 5 LUX
	LINE DENOTES 10 LUX
	LINE DENOTES 20 LUX
	CALCULATED SITE WIDE ULOR - 0.00

A	02/04/24	FOR TENDER	CC
REV	DATE	DETAILS OF REVISION	BY

**HARNISS CONSULTING**
www.harniss.co.uk
1 Weekley Wood Avenue,
Kettering, Northants, NN14 1UQ
Tel: 01933 656850
Email: info@harniss.co.uk

CLIENT
BARCHESTER HEALTHCARE LTD

PROJECT
PROPOSED CARE HOME
HART PLAIN AVENUE
WATERLOOVILLE, PO8 8RY

DRAWING TITLE
ELECTRICAL SERVICES
EXTERNAL LIGHTING STRATEGY

Issue Status						
PRELIMINARY						
Original Size	Scale	Drawn				
A1	1:200	CC				
HCO Project No.	Suitability	Checked				
2354	-	TS				
Project	Originator	Volume	Level	Type	Role	Number
2354	-HCO-ZZ	-ZZ	-DR	-E	-	9000