


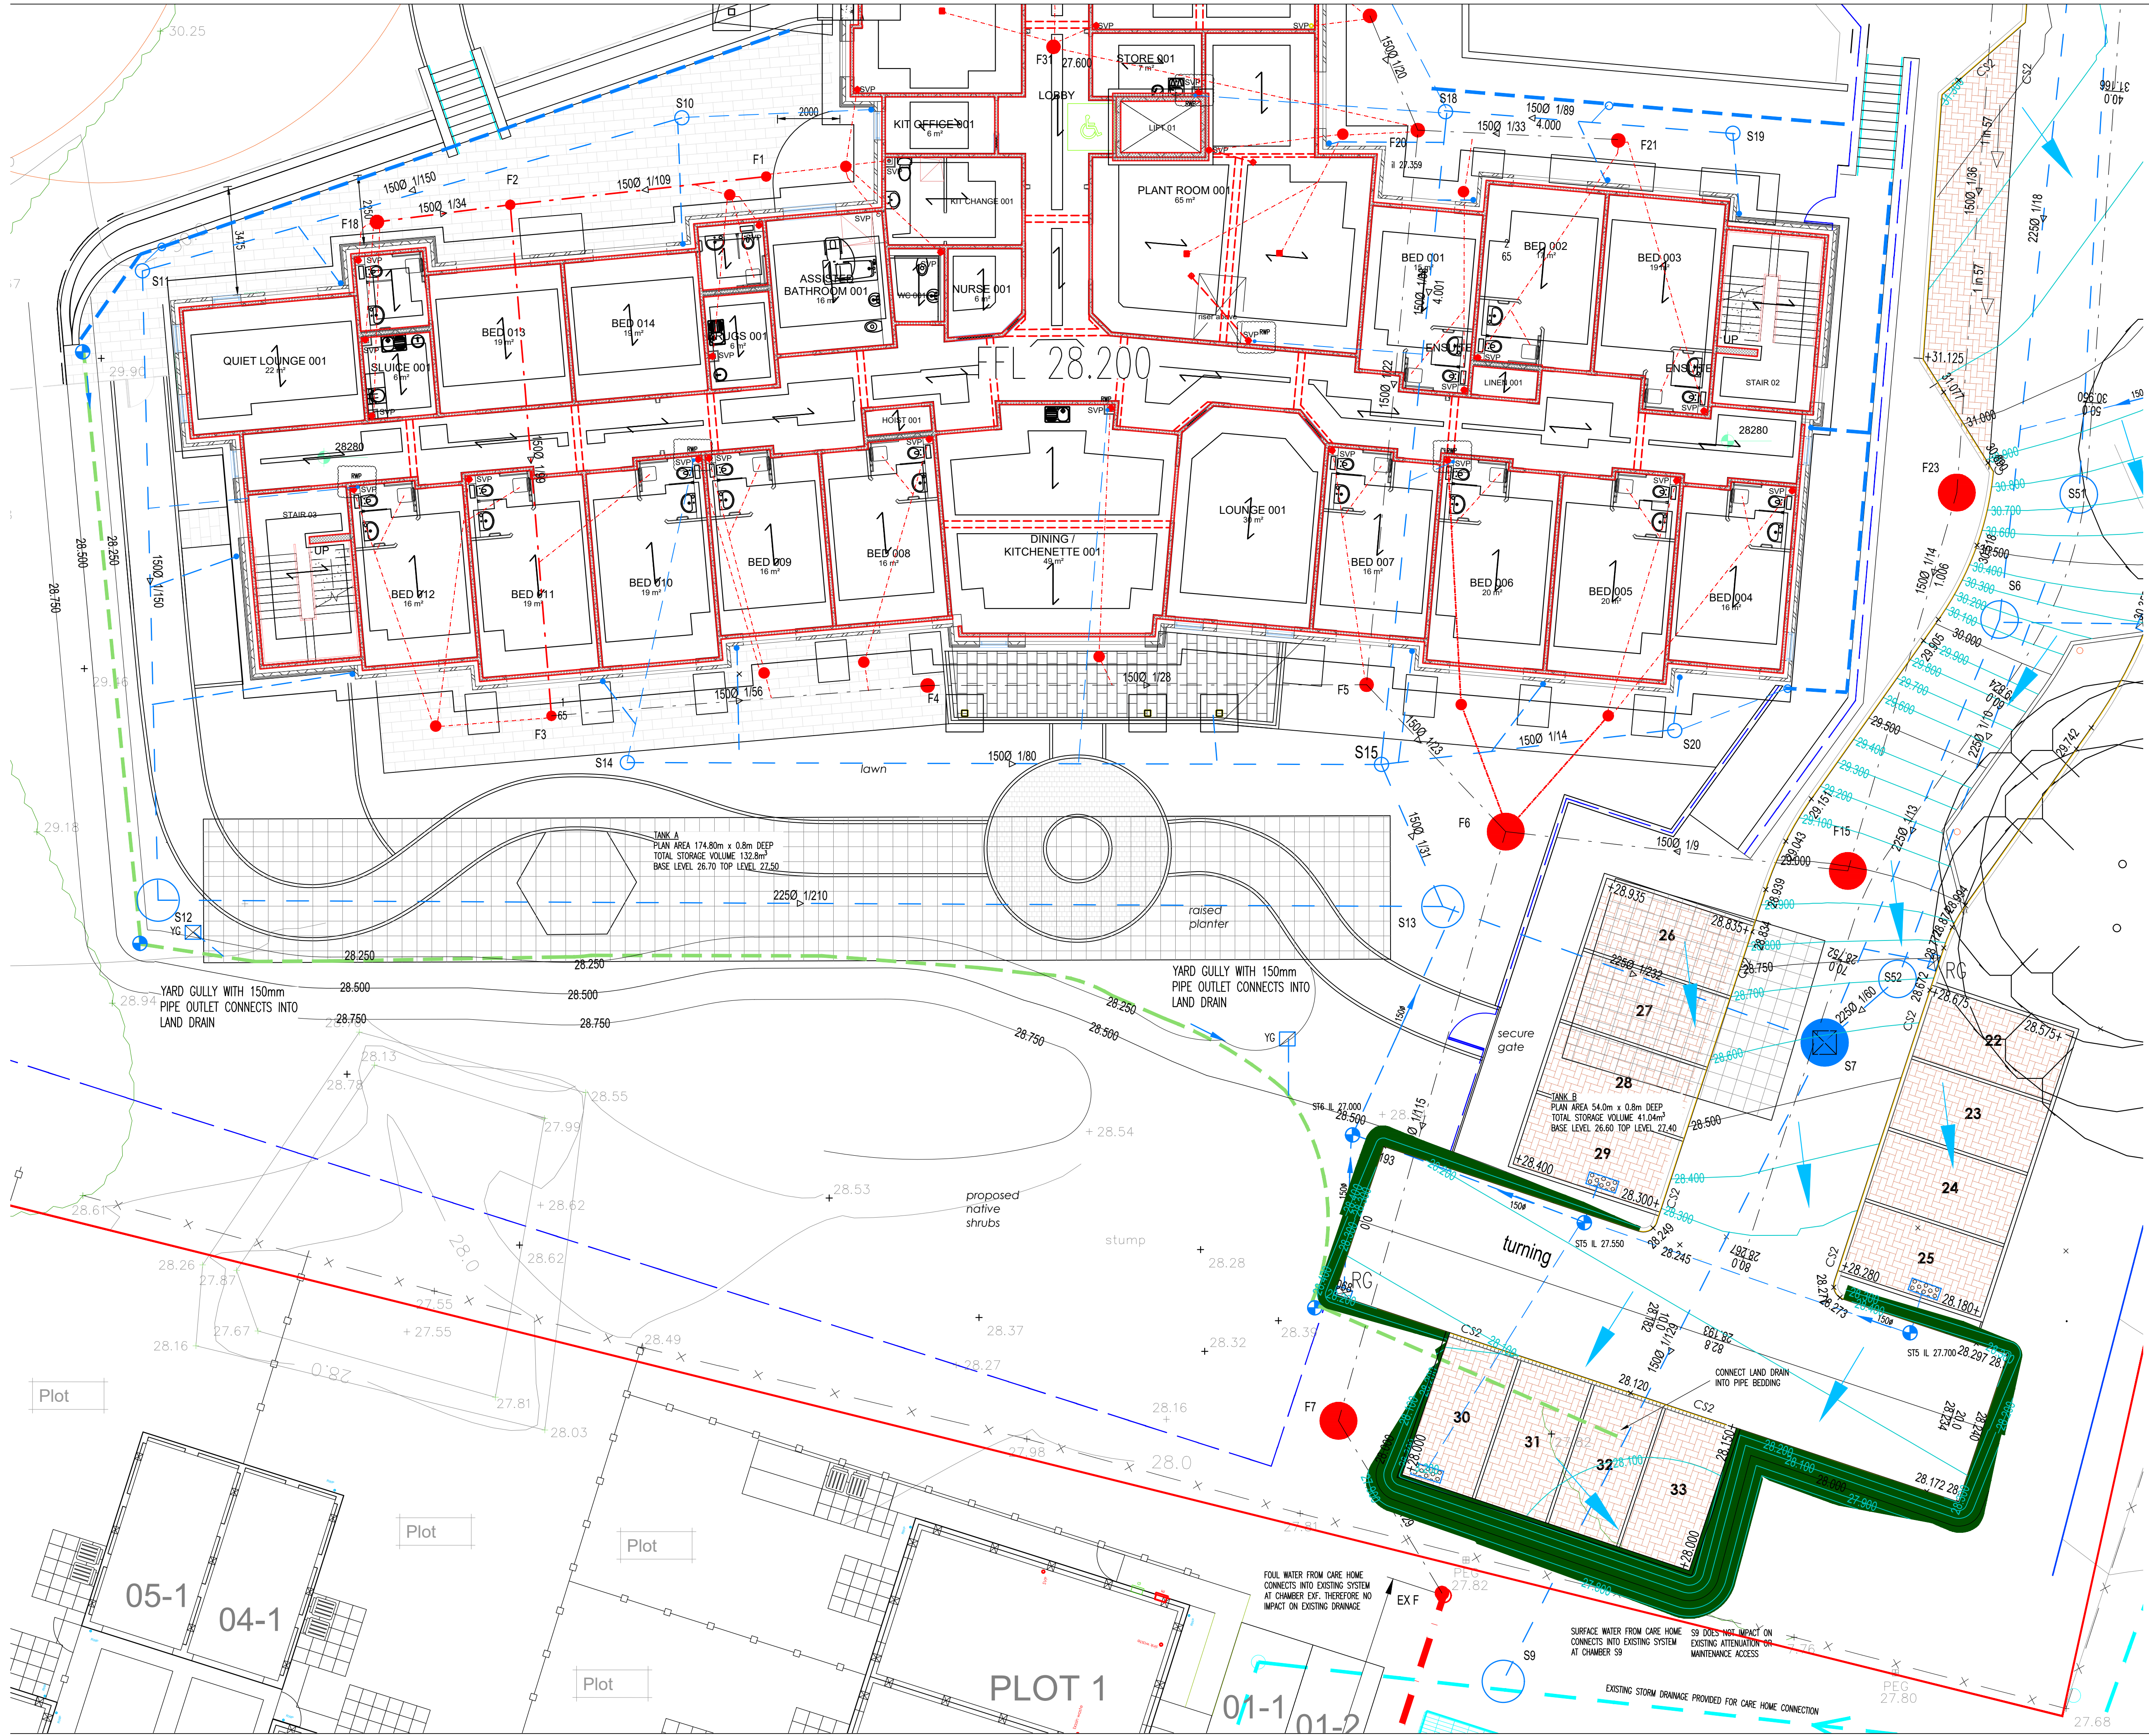

- NOTES**
1. DO NOT SCALE FROM THIS DRAWING. USE FIGURED DIMENSIONS ONLY, IF IN DOUBT ASK.
 2. ALL DIMENSIONS IN MILLIMETRES UNLESS NOTED OTHERWISE.
 3. THIS DRAWING IS TO BE READ IN CONJUNCTION WITH ALL RELEVANT ENGINEERS AND ARCHITECTS DRAWINGS AND SPECIFICATIONS.

LEGEND

- Foul Manhole
- Foul Type 3 Inspection Chamber Private, Main Range 315 or 450 Refer to Schedule
- SVP Soil and Vent Pipe
- FG Floor Gully with Roddable Trap
- Rodding Eye Private
- Surface Water Type 3 Inspection Chamber Private, Main Range 450 Max Depth 2.0m
- Hydrobrake Flow Control Chamber
- 150mm Land Drain
- Surface Water Drain Private
- Acc Line Drain with A15 Glass Load Carving, Rodding Points and Slumps at Discharge Points
- Silt Trap
- Distribution Chamber to Drain Drainage Blanket Below Car Park Size 1500m x 700m x 150mm with Geotextile Surround on 10mm Pipe Bedding
- RG Road Gully
- YG Yard Gully
- Tobemore Hydrobrake Pedestal 200 x 100 x 60 Permeable Paving to Car Park Colour to Architect/Client Requirements
- SOS Geolight Attenuation System
- Existing Overland Flow Routes
- Post Construction Overland Flow Routes

PLANNING ISSUE		RN
08.11.24	REVISION	DRAWN
	DATE	CHECKED

Client:
ANAVO DEVELOPMENTS LIMITED

Project Title:
**HAVANT :
HAVANT CARE HOME
BARTONS ROAD, HAVANT**

Drawing Title:
**PROPOSED DRAINAGE LAYOUT
SHEET 2 OF 4**

Drawn By:	Scale:	Rev:
RN	1:1000M1	
Date:	APRIL 2024	Drawing Number:
Checked By:	ANR	11063-501P
Date:	APRIL 2024	C1

Drawing Status:
PLANNING

NJP Consulting Engineers Limited
20 St Andrews Crescent
Cardiff CF10 3DD

Tel: 029 2072 9500
Email: info@njpuk.com
Web: www.njpuk.com