


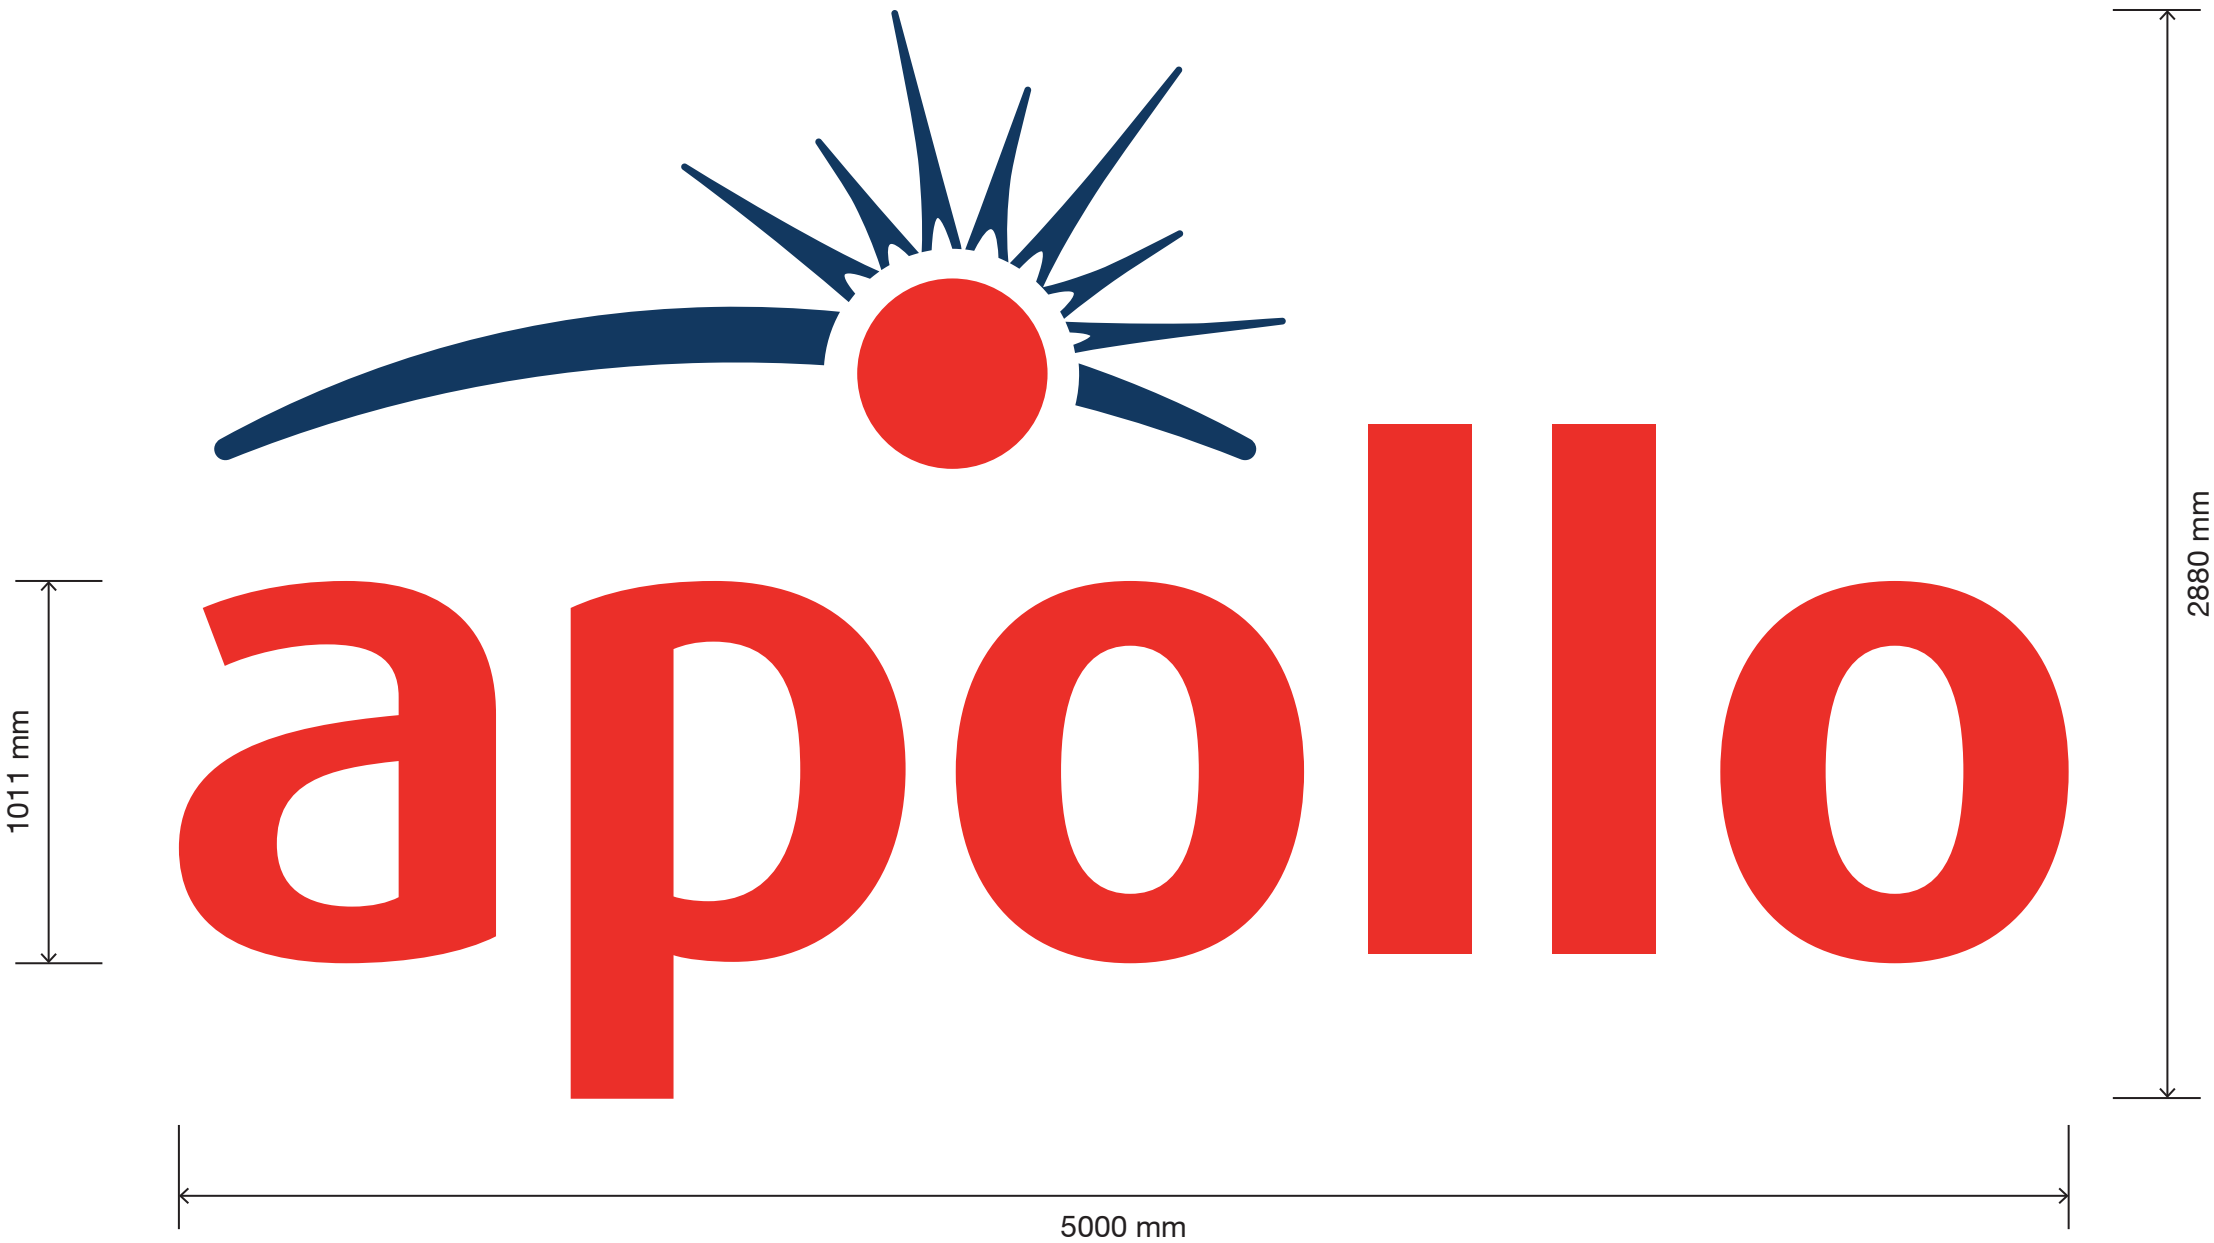



Item A
Qty 1
100mm deep built up HALO-ILLUMINATED letters, powdercoated
aluminium body RAL 3020 red / RAL 5003 blue with opal spacers
to rear
Size: 5000mm x 2880mm
Scale 1:20 @ A3

FACE VIEW




SIDE VIEW

Powdercoated
RAL 5003 blue /
RAL 3020 red

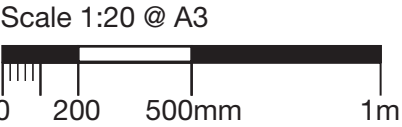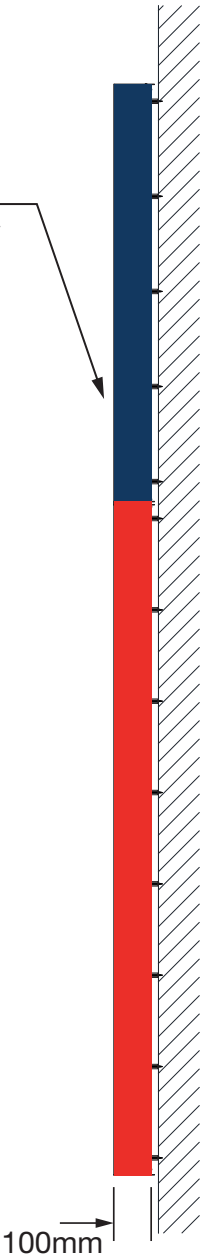


4 Eastboro Fields Hemdale Business Park
Nuneaton CV11 6GL
024 7632 0032 info@magnasigns.co.uk

Client: Apollo Fire Detectors	Project: Building Signage	Date: 20/10/24	Revision: 1	Job No: 45886
Estimator: Josh Peel	Revision Details: Revision 2 Revision 3 Revision 4	Signage Colours:		
Designer: Ryan Nicholds		RAL 5003 Blue	RAL 3020 Red	
This artwork and its content is copyright of Magna Signs - © Magna Signs 1991. All rights reserved. Any redistribution or reproduction of part or all of the contents in any form is prohibited other than the following: You may print or download to a local hard disk extracts for your personal and non-commercial use only. You may copy the content to individual third parties for their personal use, but only if you acknowledge the material. You may not, except with our express written permission, distribute or commercially exploit the content. Nor may you transmit it or store it in any other website or other form of electronic retrieval system.				Page: 1 of 3

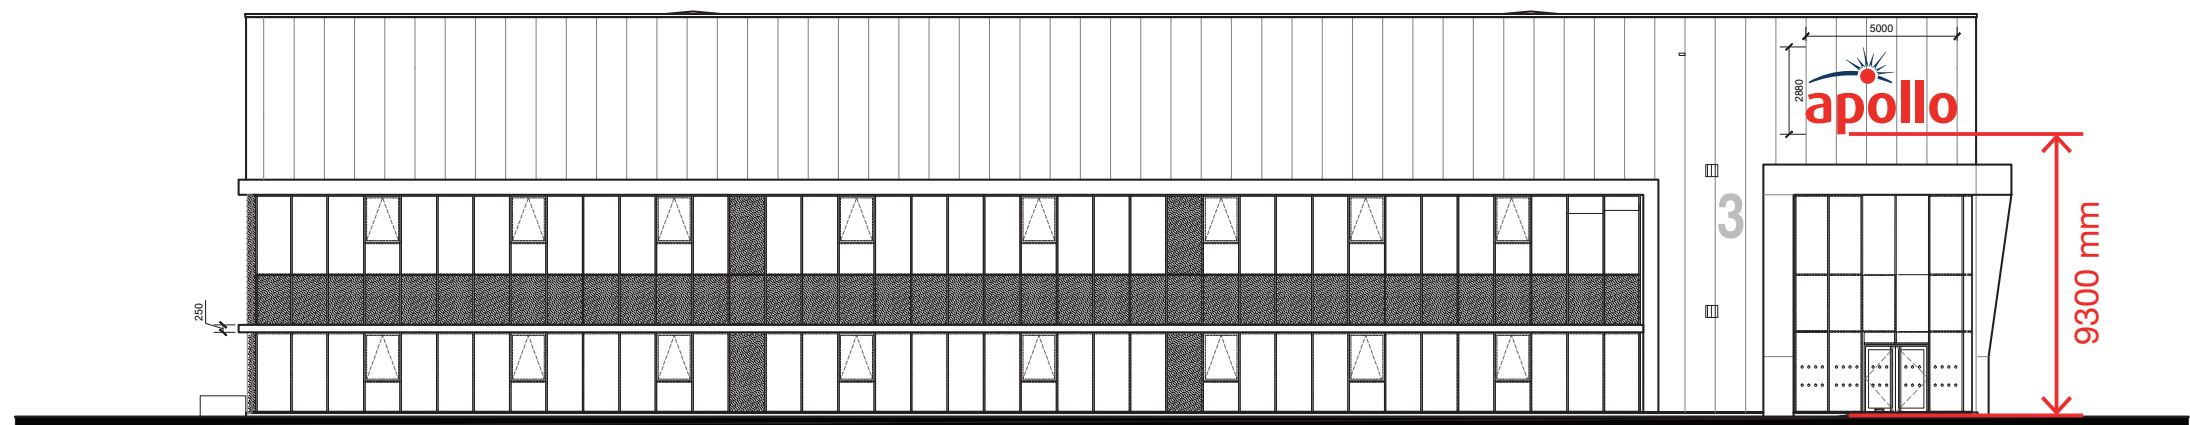


NORTH ELEVATION
SCALE 1:250 @ A3

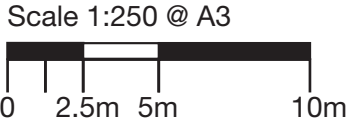

4 Eastboro Fields Hemdale Business Park
Nuneaton CV11 6GL
024 7632 0032 info@magnasigns.co.uk

Client: Apollo Fire Detectors	Project: Building Signage	Date: 20/10/24	Revision: 1	Job No: 45886
Estimator: Josh Peel	Revision Details: Revision 2 Revision 3 Revision 4	Signage Colours:		
Designer: Ryan Nicholds	This artwork and its content is copyright of Magna Signs - © Magna Signs 1991. All rights reserved. Any redistribution or reproduction of part or all of the contents in any form is prohibited other than the following: You may print or download to a local hard disk extracts for your personal and non-commercial use only. You may copy the content to individual third parties for their personal use, but only if you acknowledge the material. You may not, except with our express written permission, distribute or commercially exploit the content. Nor may you transmit it or store it in any other website or other form of electronic retrieval system.			Page: 2 of 3

SITE PLAN
SCALE 1:1000 @ A3

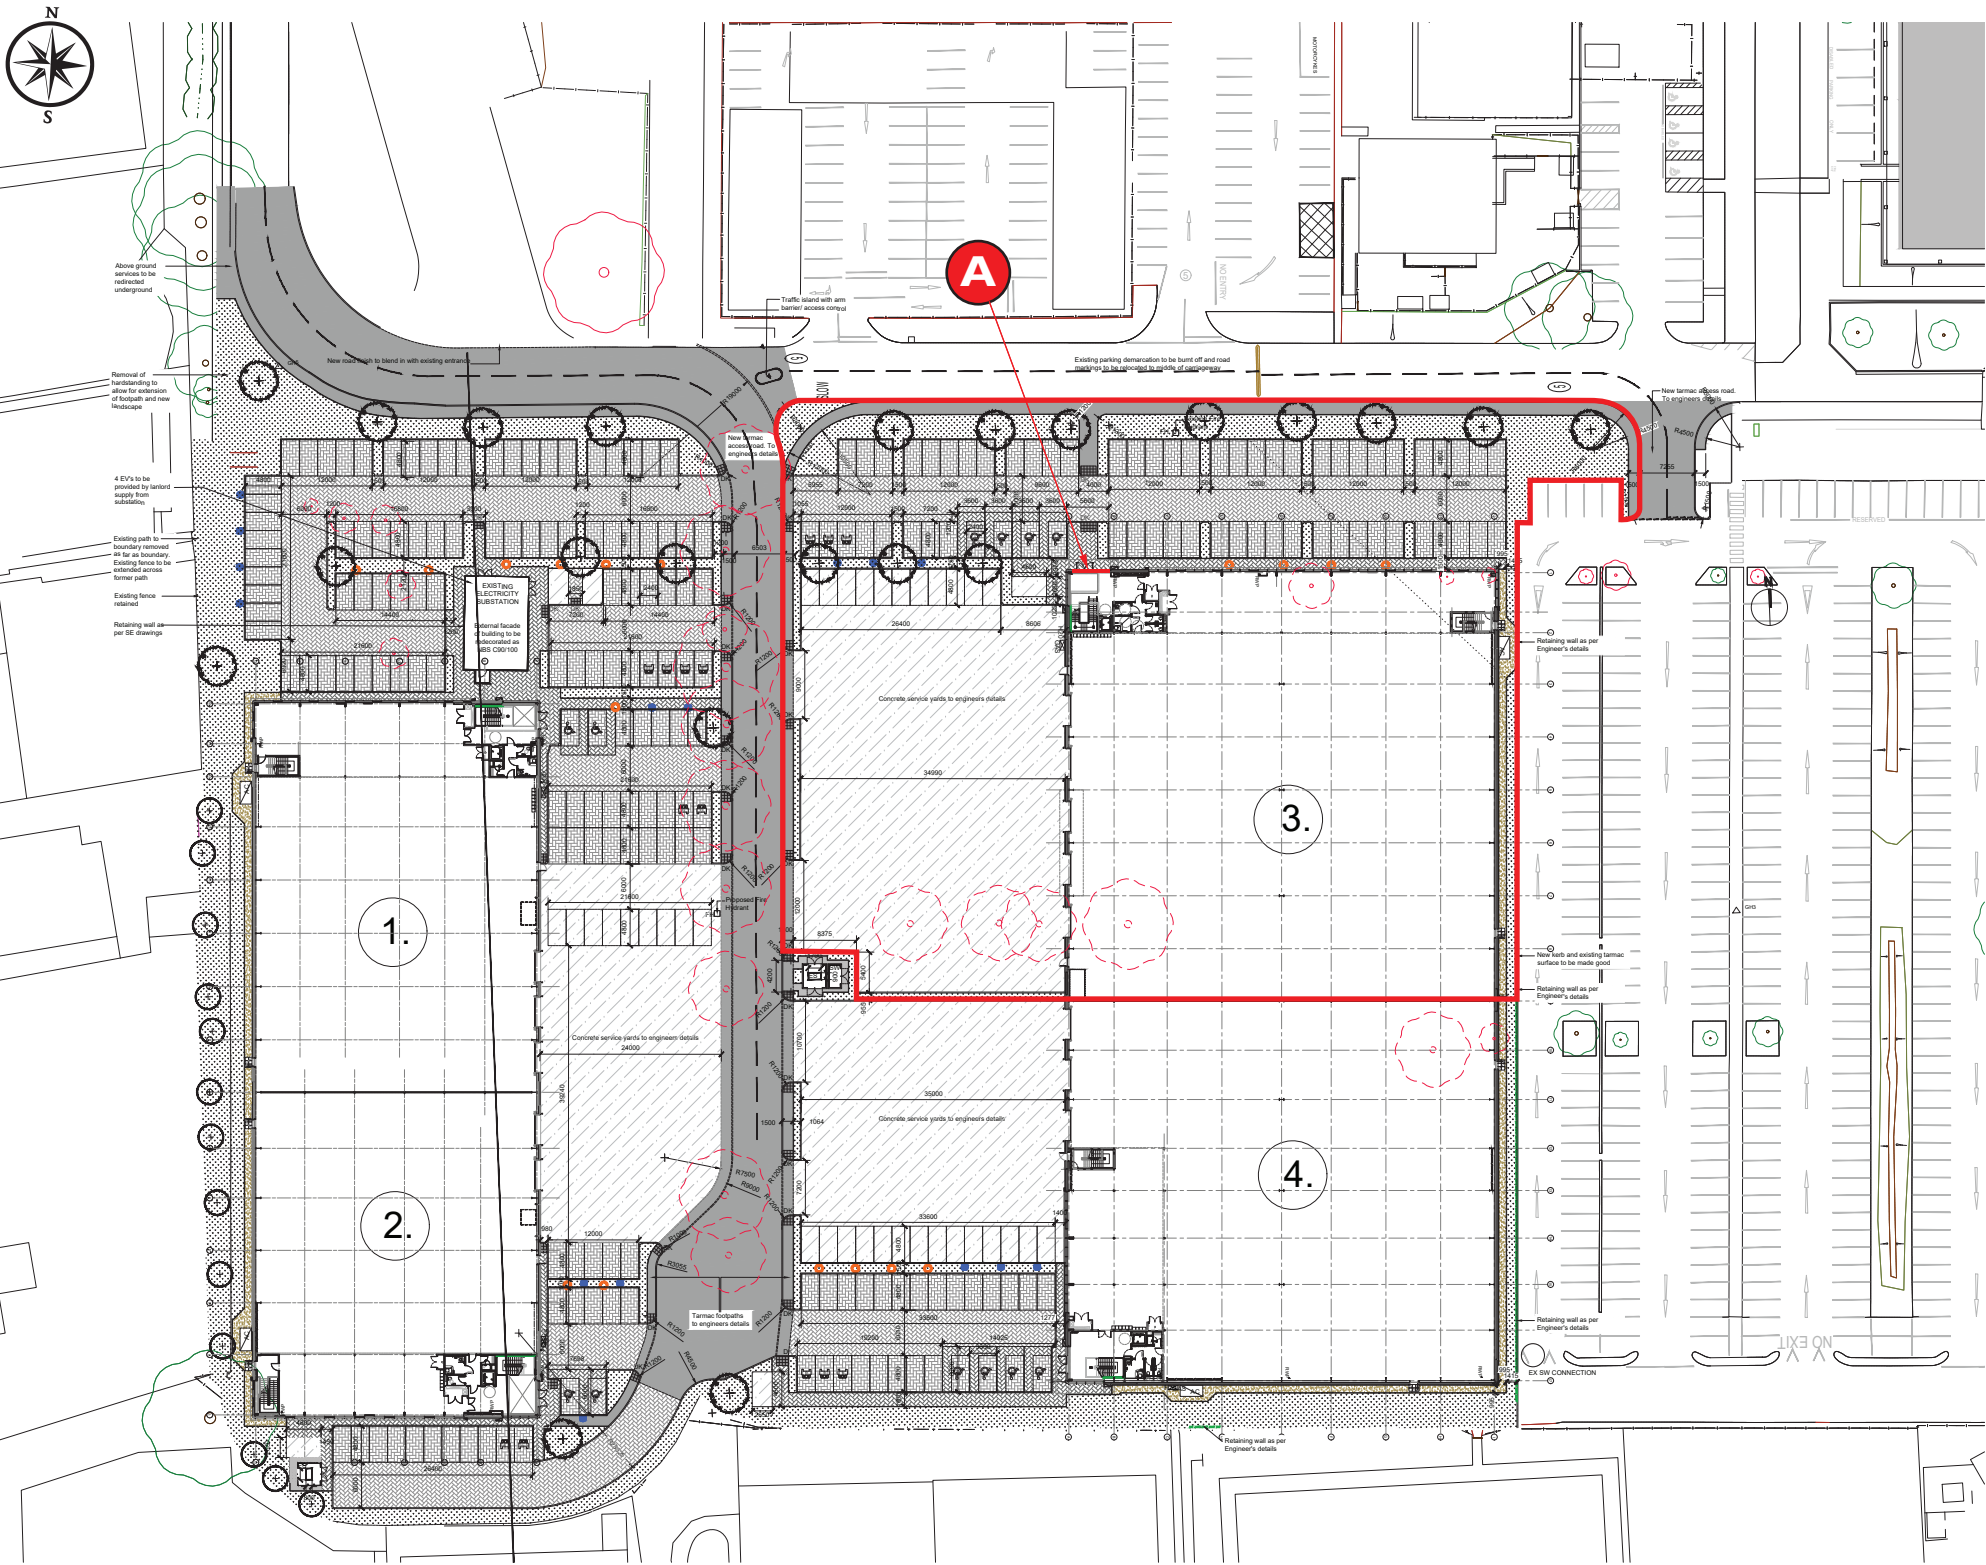

Scale 1:1000 @ A3
0 10m 20m 50m



4 Eastboro Fields Hemdale Business Park
Nuneaton CV11 6GL
024 7632 0032 info@magnasigns.co.uk

Client: Apollo Fire Detectors	Project: Building Signage	Date: 20/10/24	Revision: 1	Job No: 45886
Estimator: Josh Peel	Revision Details: Revision 2 Revision 3 Revision 4	Signage Colours:		
Designer: Ryan Nicholds				