




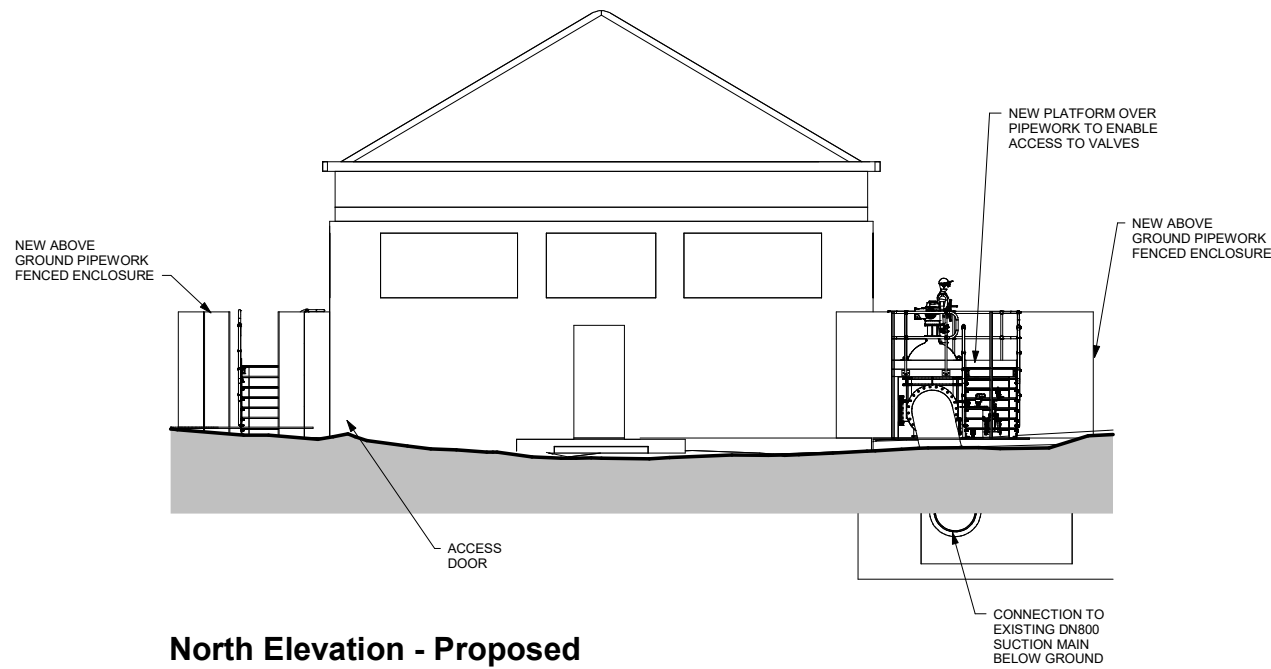

North Elevation - Proposed
1 : 75

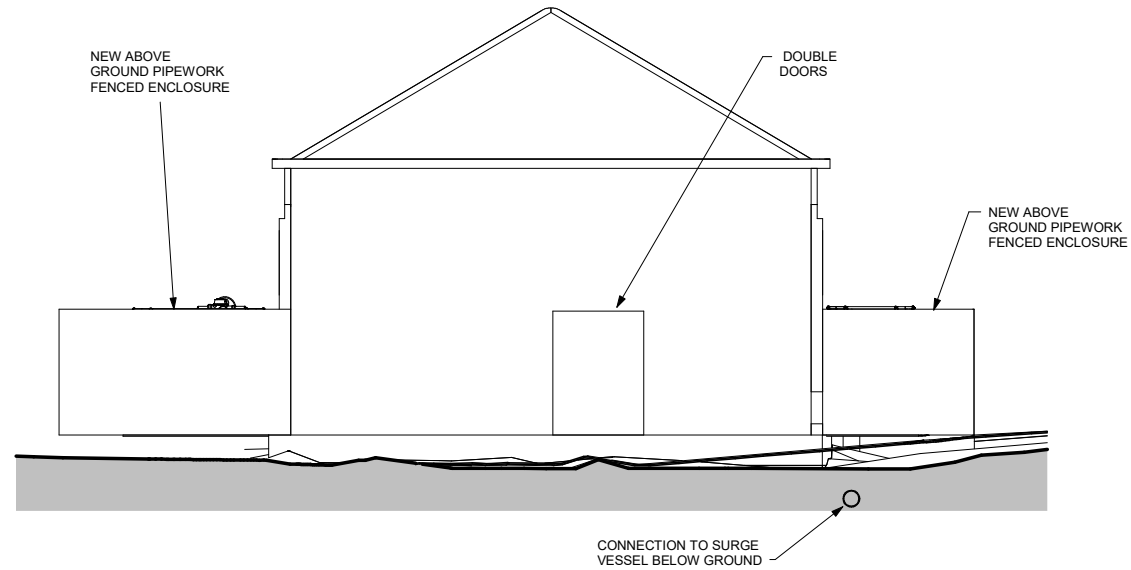

South Elevation - Proposed
1 : 75

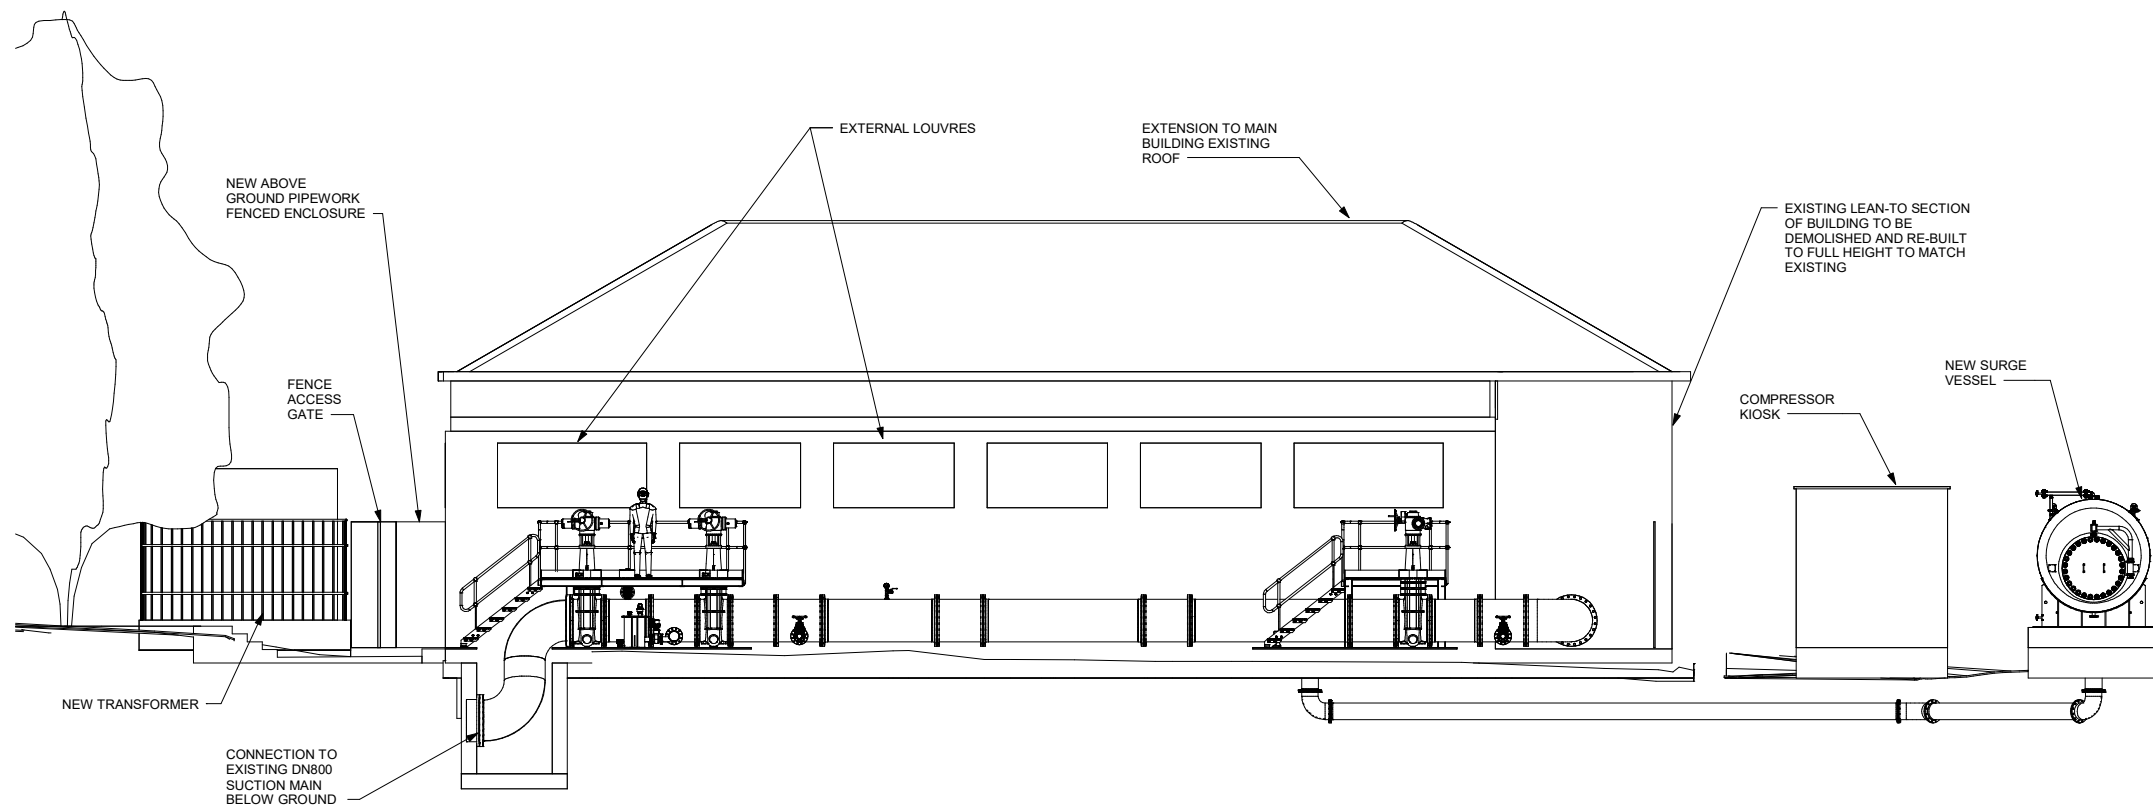

West Elevation - Proposed
1 : 75

- NOTES:
1. ALL DIMENSIONS ARE IN MILLIMETRES UNLESS OTHERWISE SPECIFIED.

P08	REVISED AS PER CLIENT COMMENTS	JJC	MW	03/05/24
P07	EXISTING BUILDING ROOF DETAIL REMOVED. WEST ELEVATION ADDED.	JJC	SW	13/02/24
P06	BUILDING LAYOUT UPDATE	JJC	SW	21/11/23
P05	ROOF EXTENDED. PUMPS REMOVED FROM VIEW	JJC	SW	13/11/23
P04	CHANGE TO ROOF DETAIL. GALLERY PROTECTION ADDED TO SUCTION PIPEWORK	JJC	SW	22/09/23
P03	TRANSFORMER/SURGE VESSEL LOCATION CHANGED	JJC	SW	19/09/23

MK	REVISION	DRN	CHK	DATE
----	----------	-----	-----	------

CLIENT: PORTSMOUTH WATER

HAVANT THICKET - BEDHAMPTON 2

ELEVATION VIEWS

FOR PLANNING

DESIGNED: Designer
ORIGINAL DRAWING SIZE: A2 SCALE:

DRAWING NUMBER	REV.
HTR-BRD-PS-B2-DR-M- 2012	P08

UNLESS OTHERWISE STATED:
- 3RD ANGLE PROJECTION
- ALL DIMENSIONS IN MM
- NEVER SCALE FROM DRAWING -IF IN DOUBT ASK

Bridges

Bridges Electrical Engineers Limited
Unit 31A, Second Avenue
Westfield Trading Estate
Midsomer Norton, Bath
BA3 4BH

Tel: 01761 419337
Fax: 01761 413521