



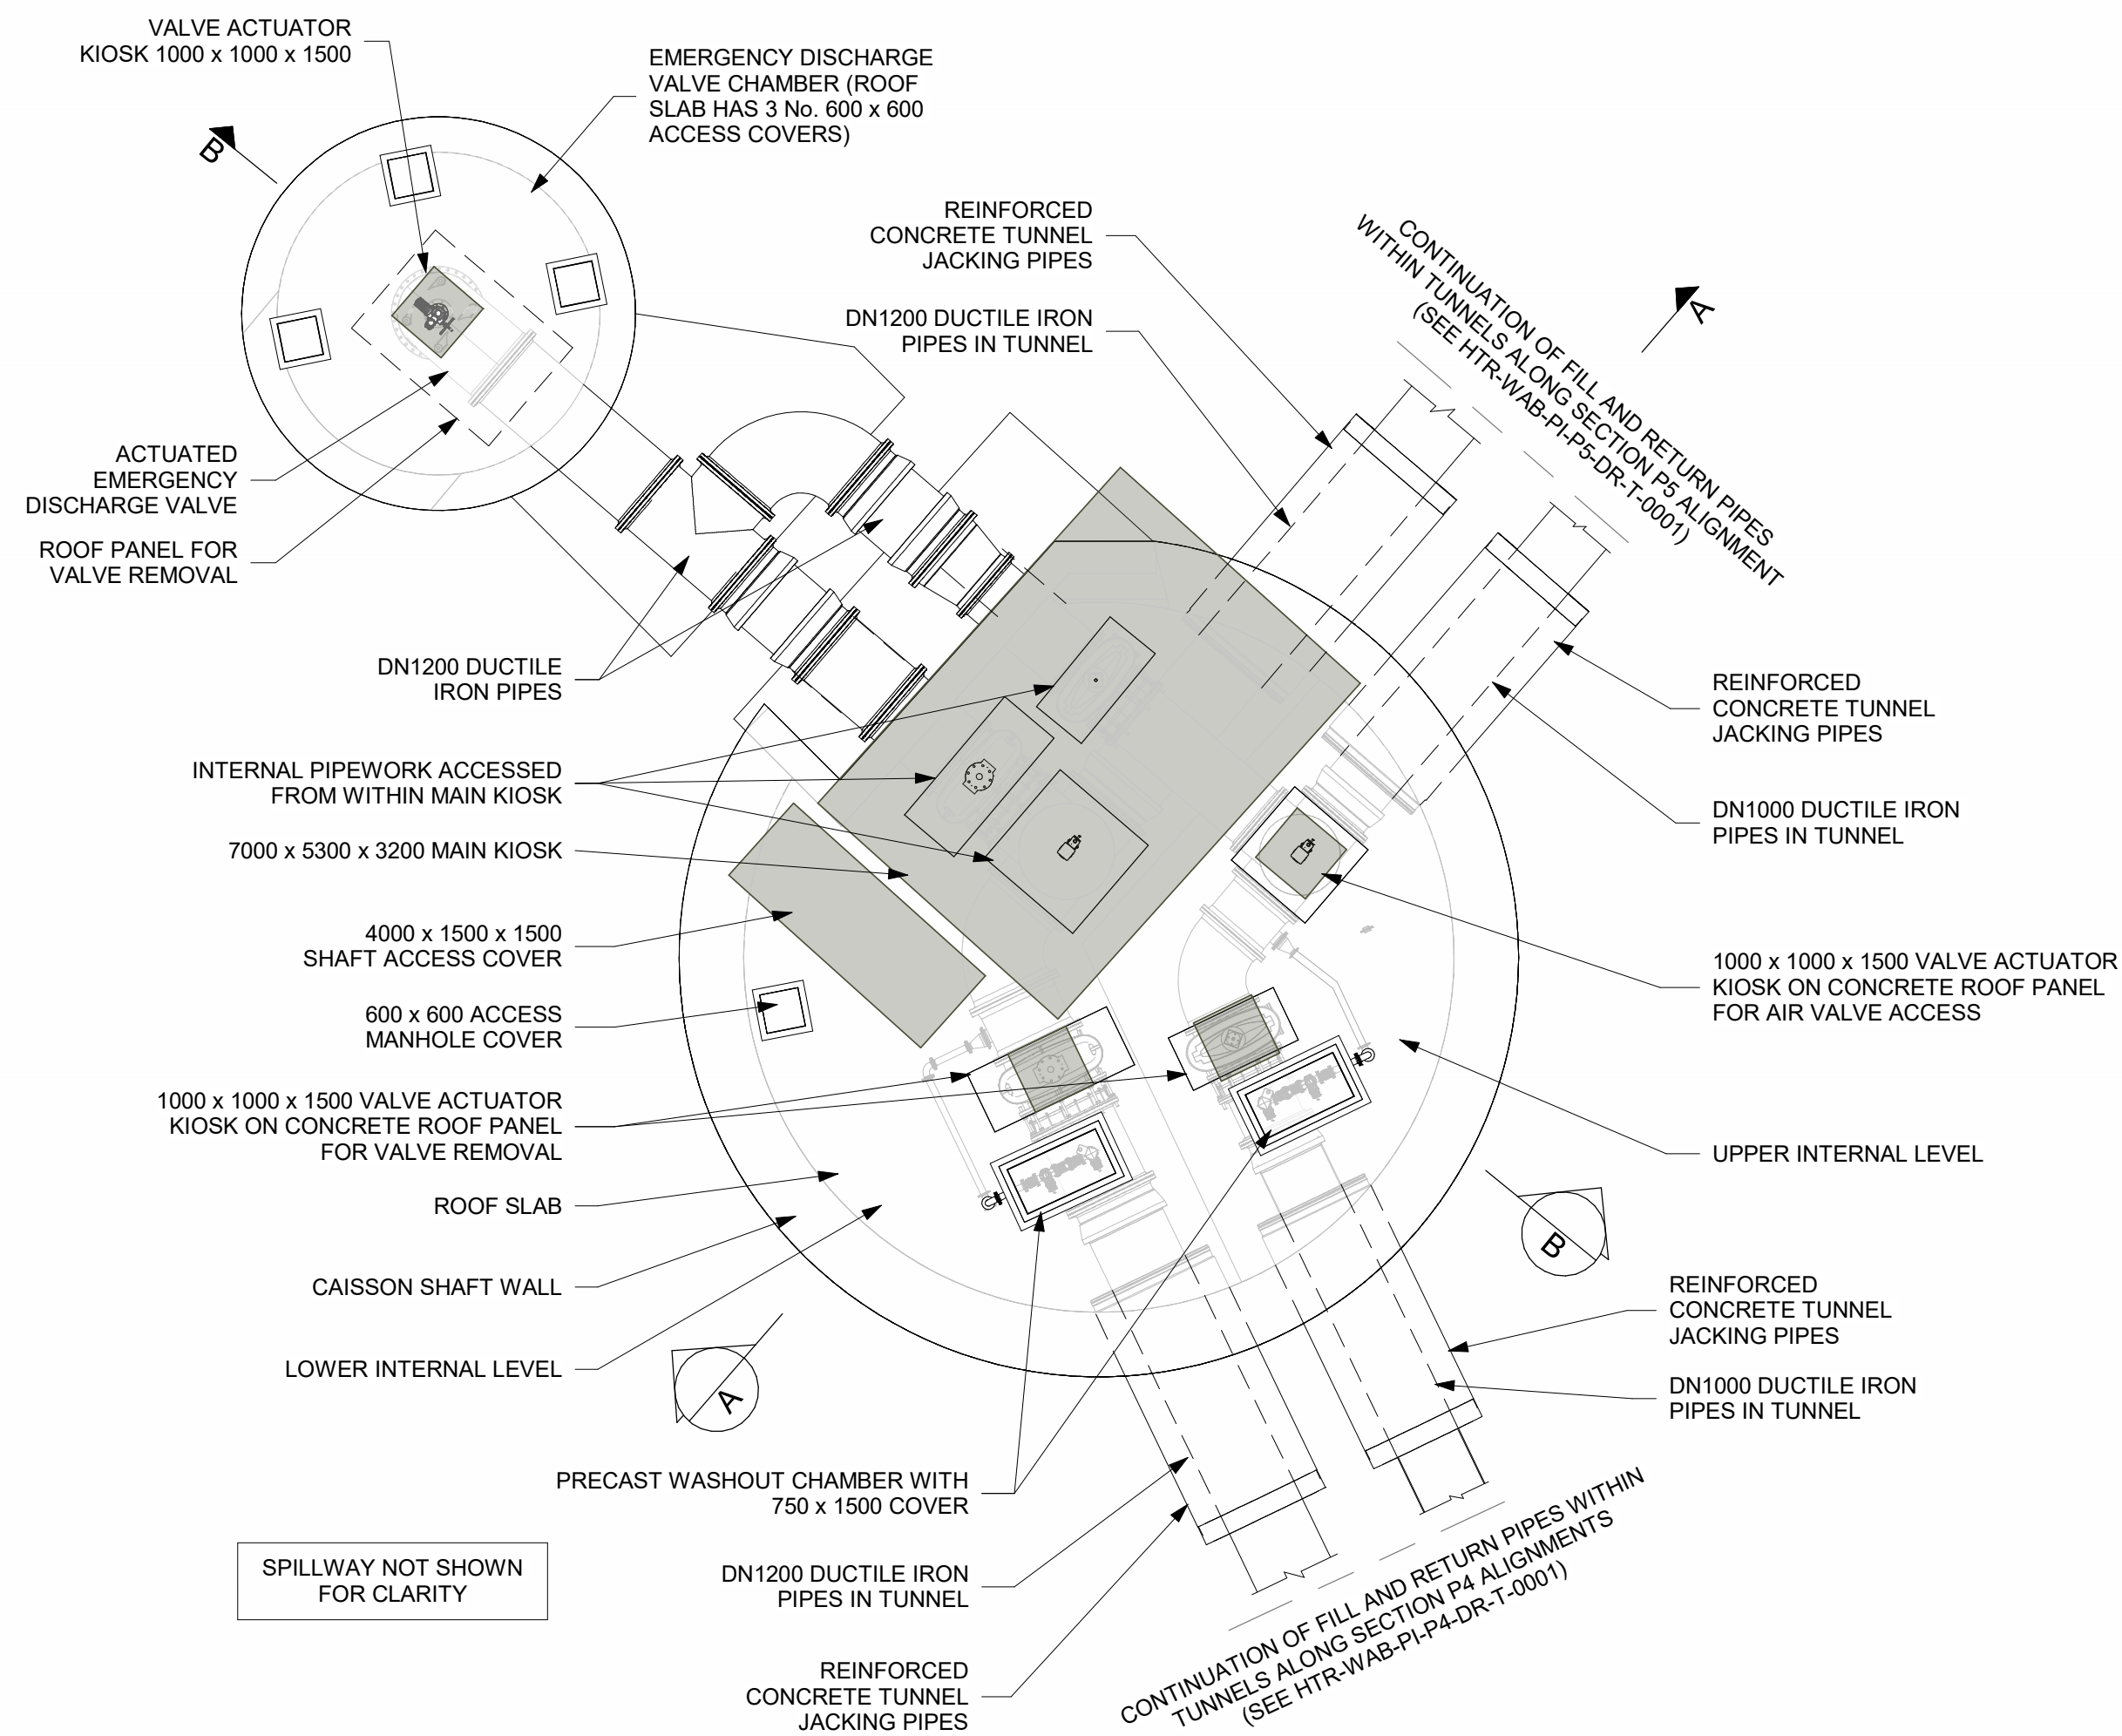


PLAN
SCALE 1 : 50

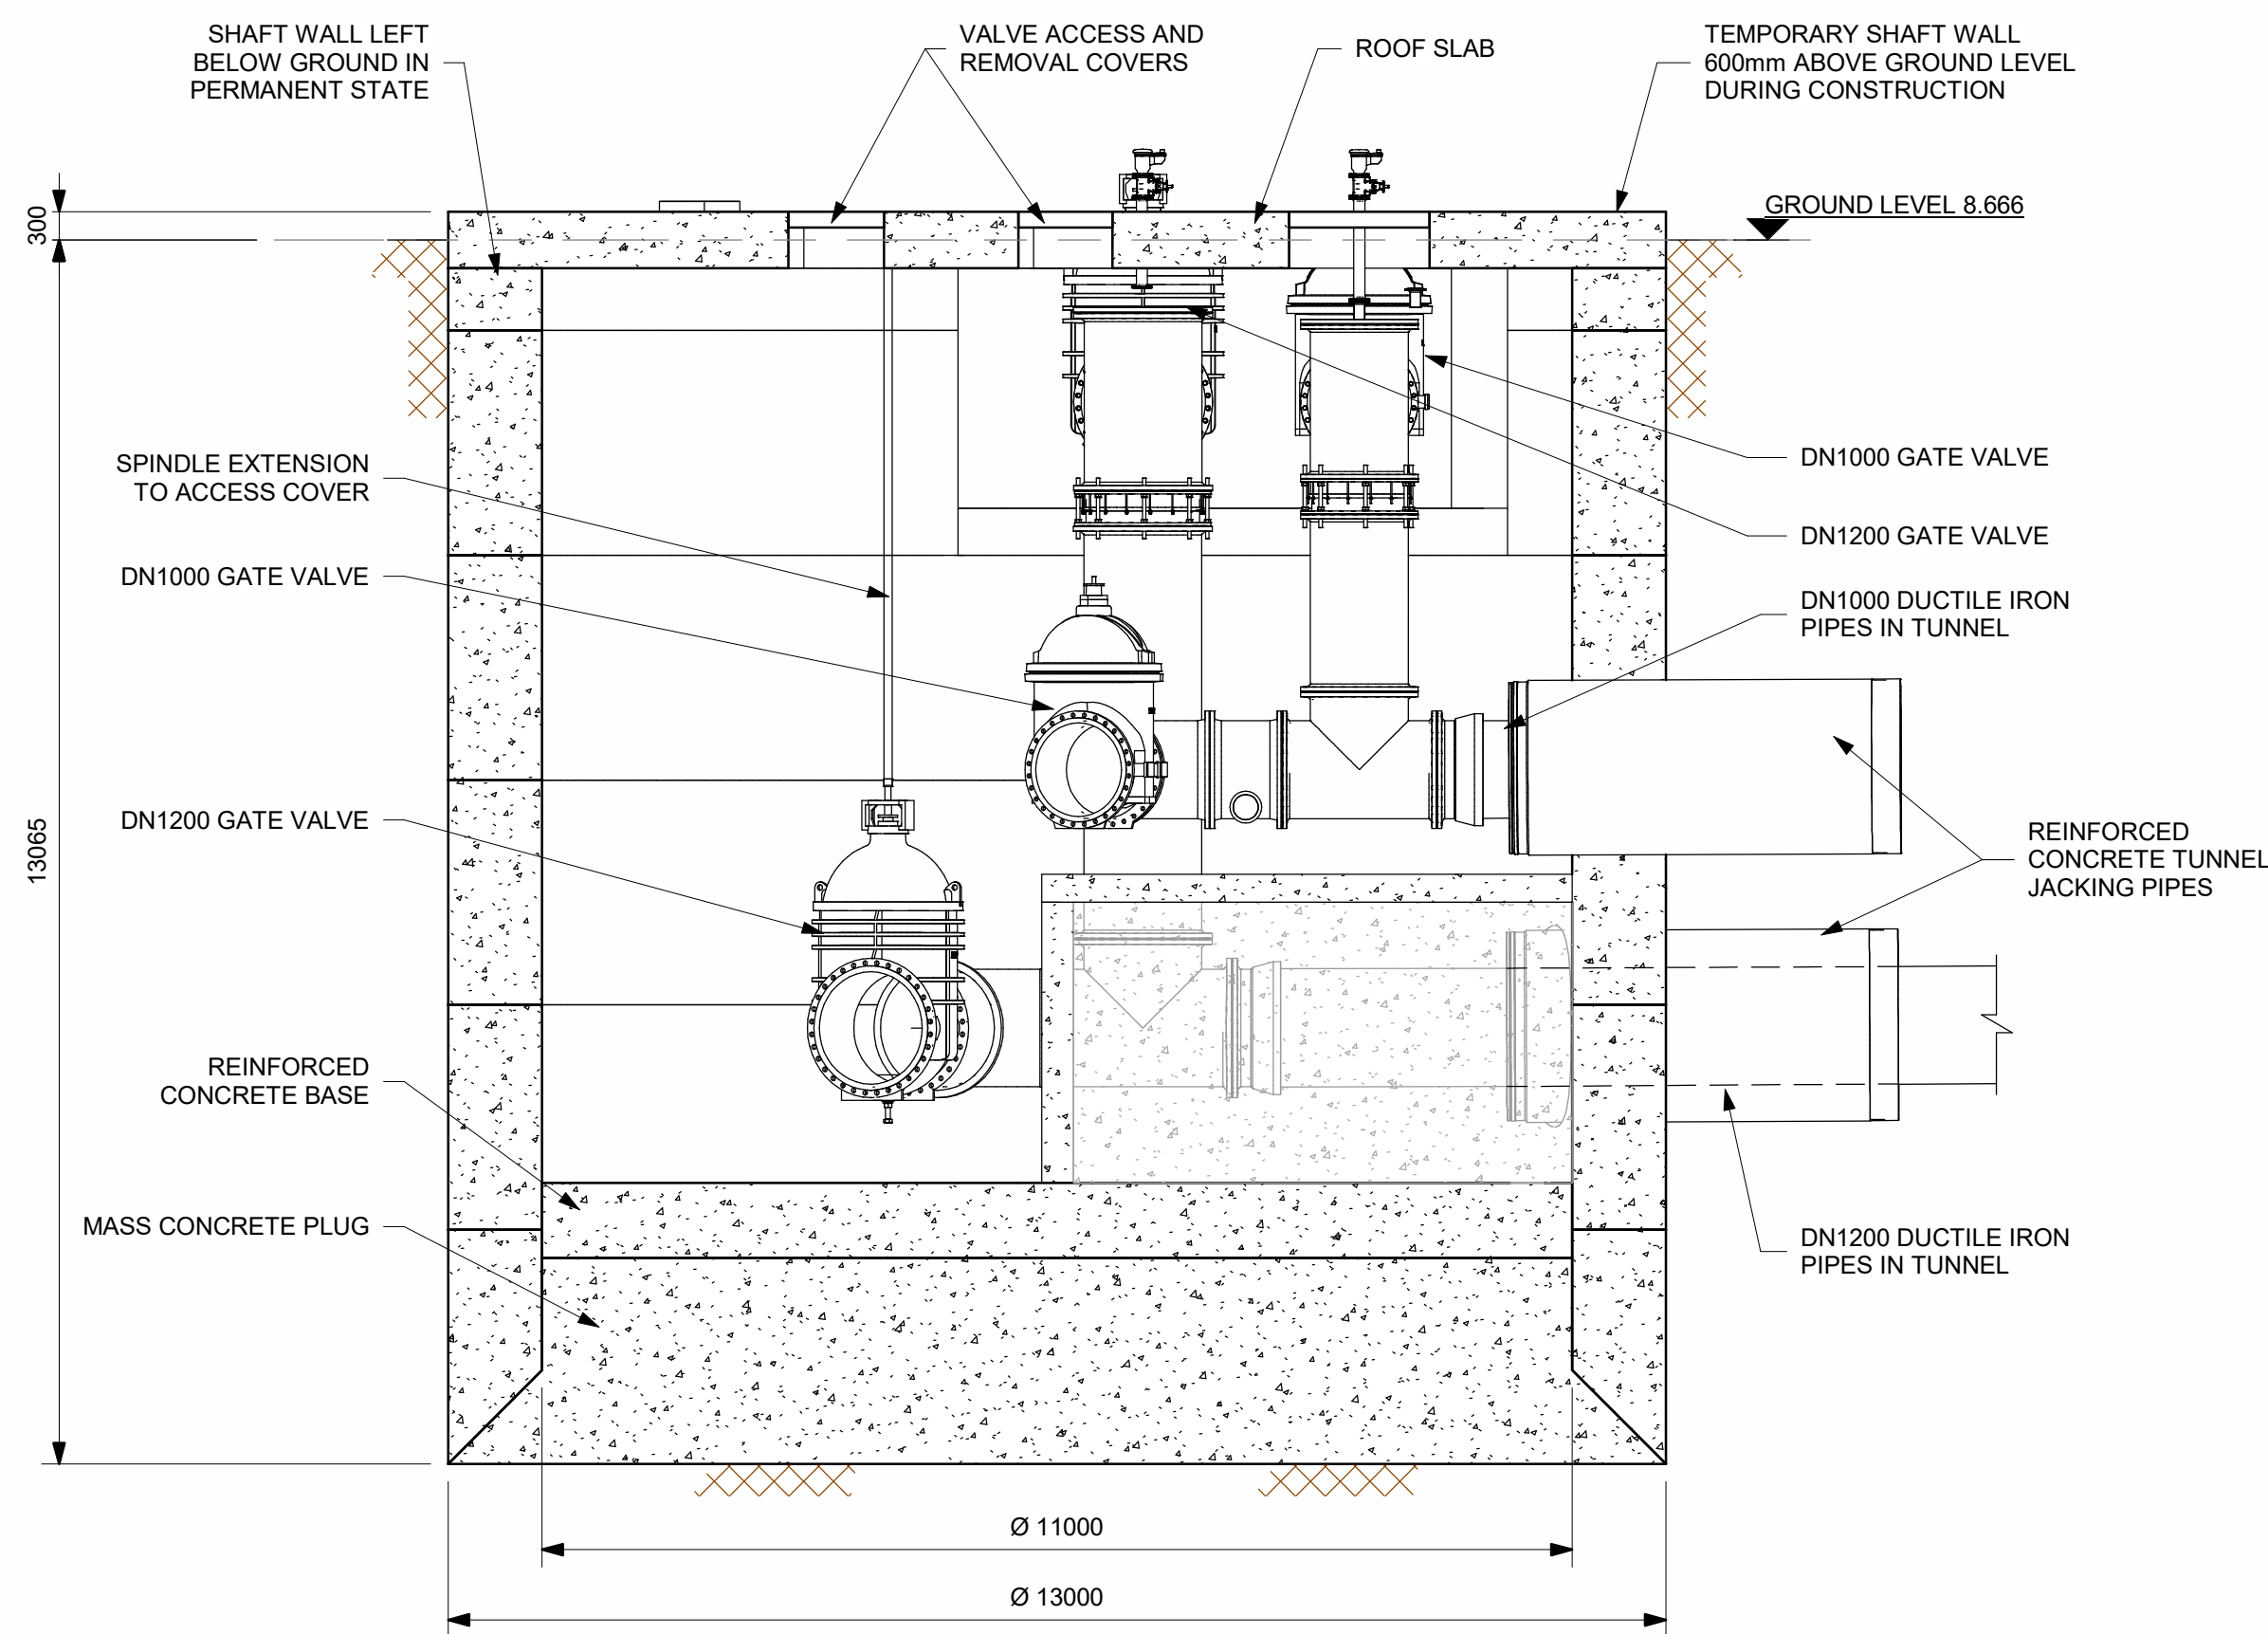


SECTION A-A

SCALE 1 : 50
KIOSKS REMOVED FOR CLARITY

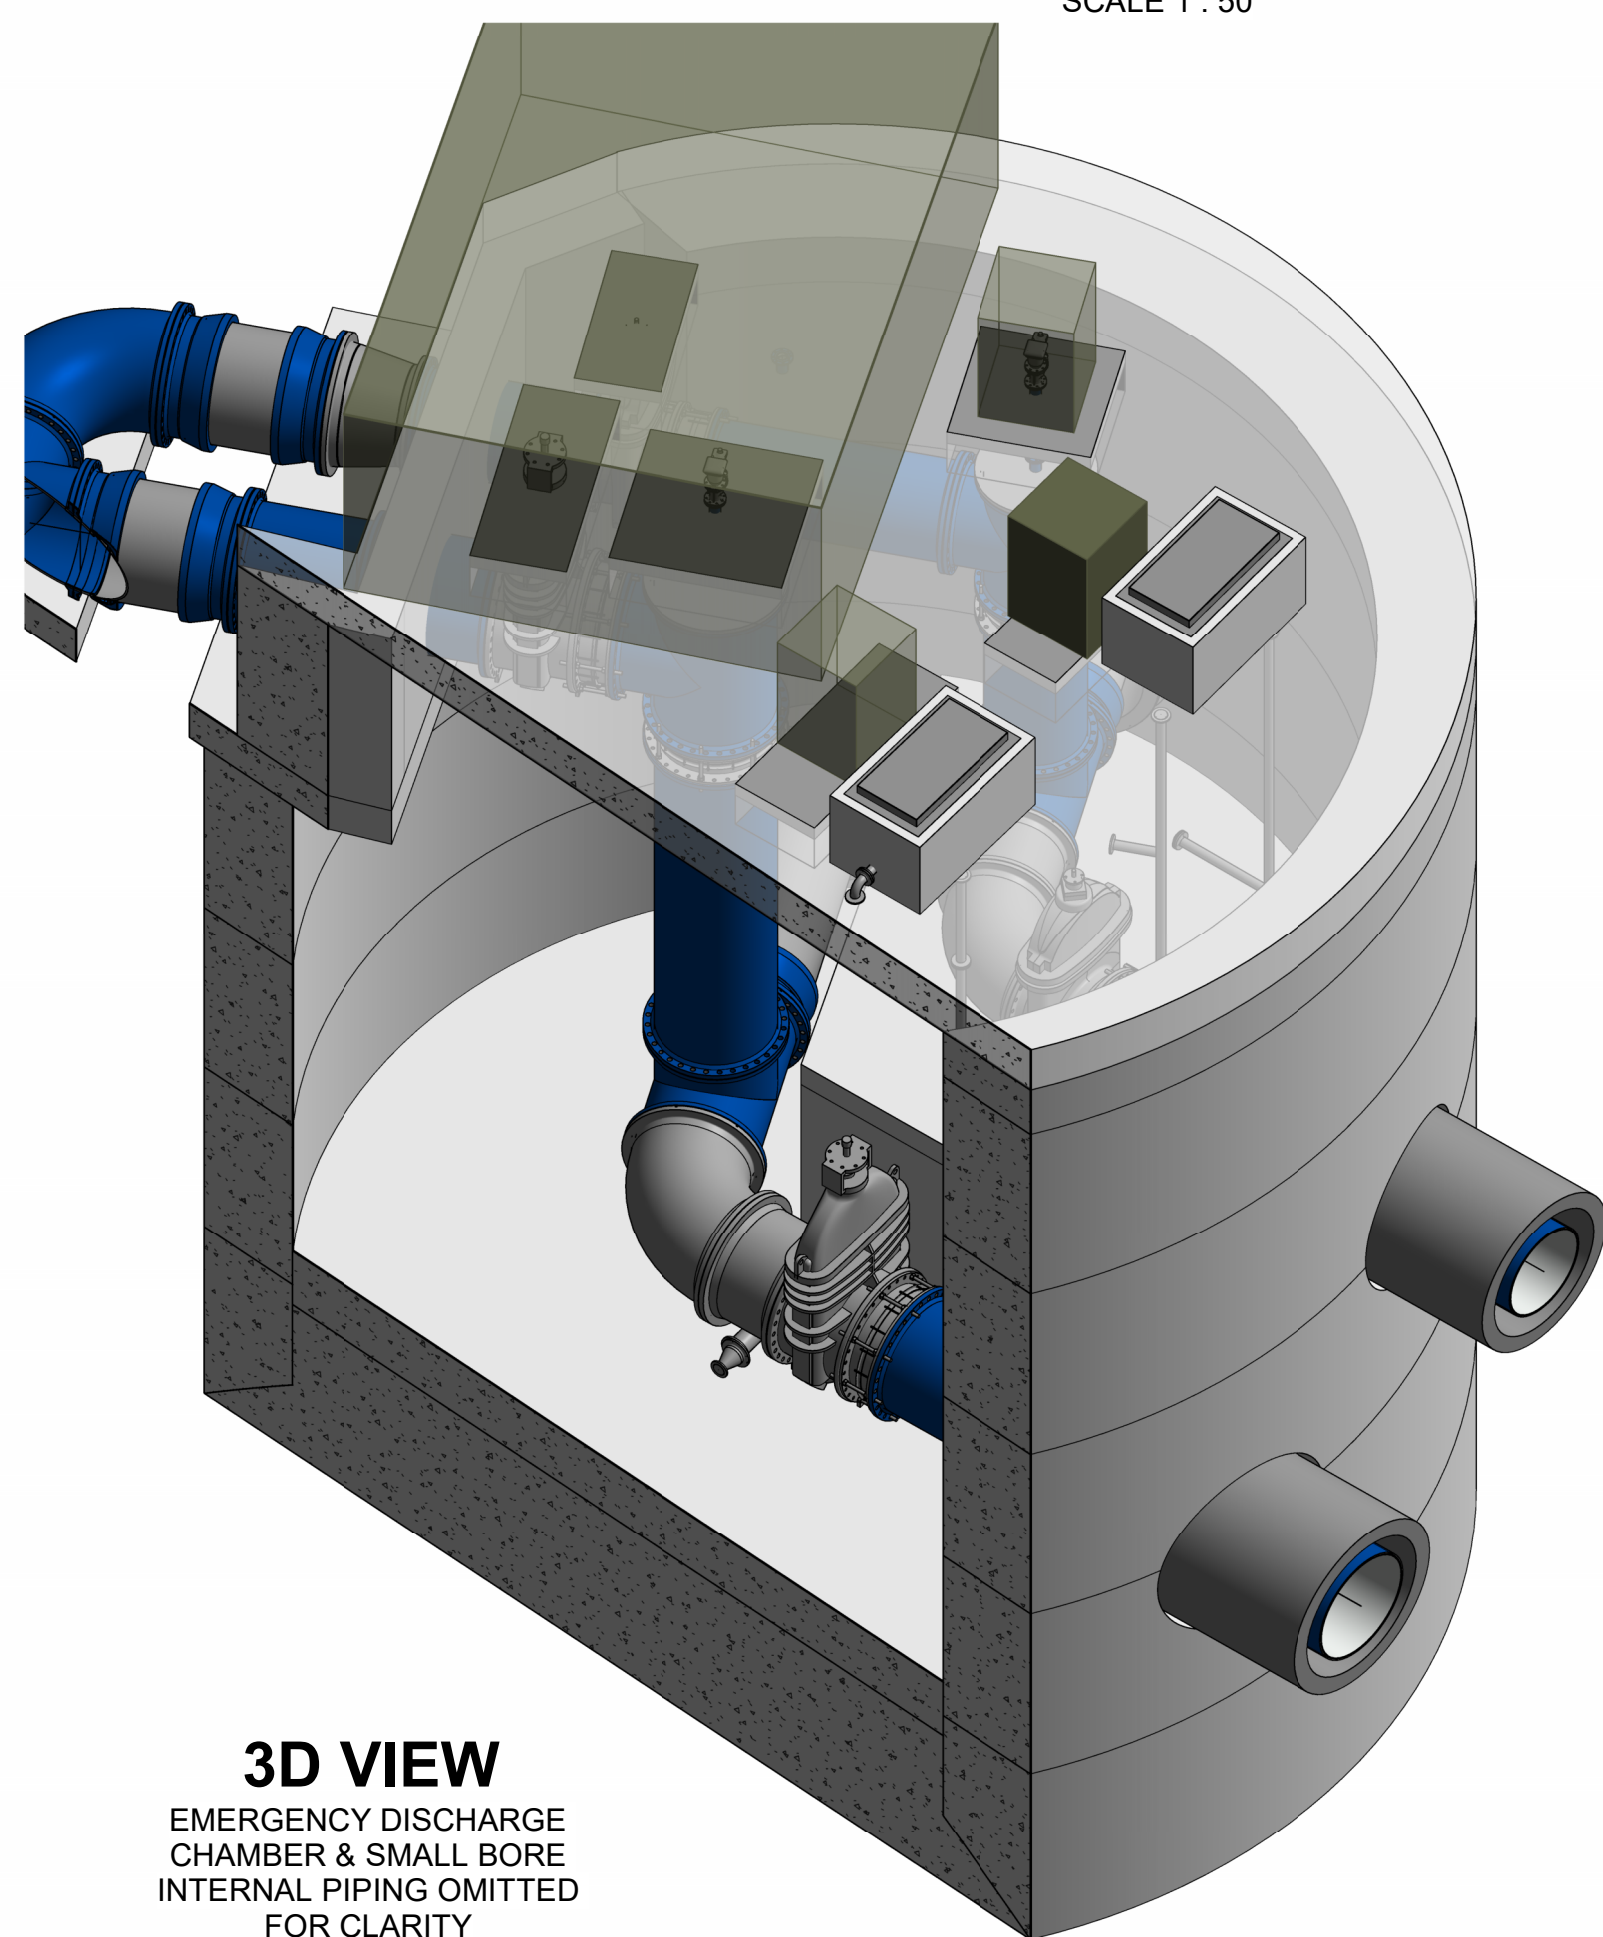

3D VIEW

EMERGENCY DISCHARGE CHAMBER & SMALL BORE INTERNAL PIPING OMITTED FOR CLARITY

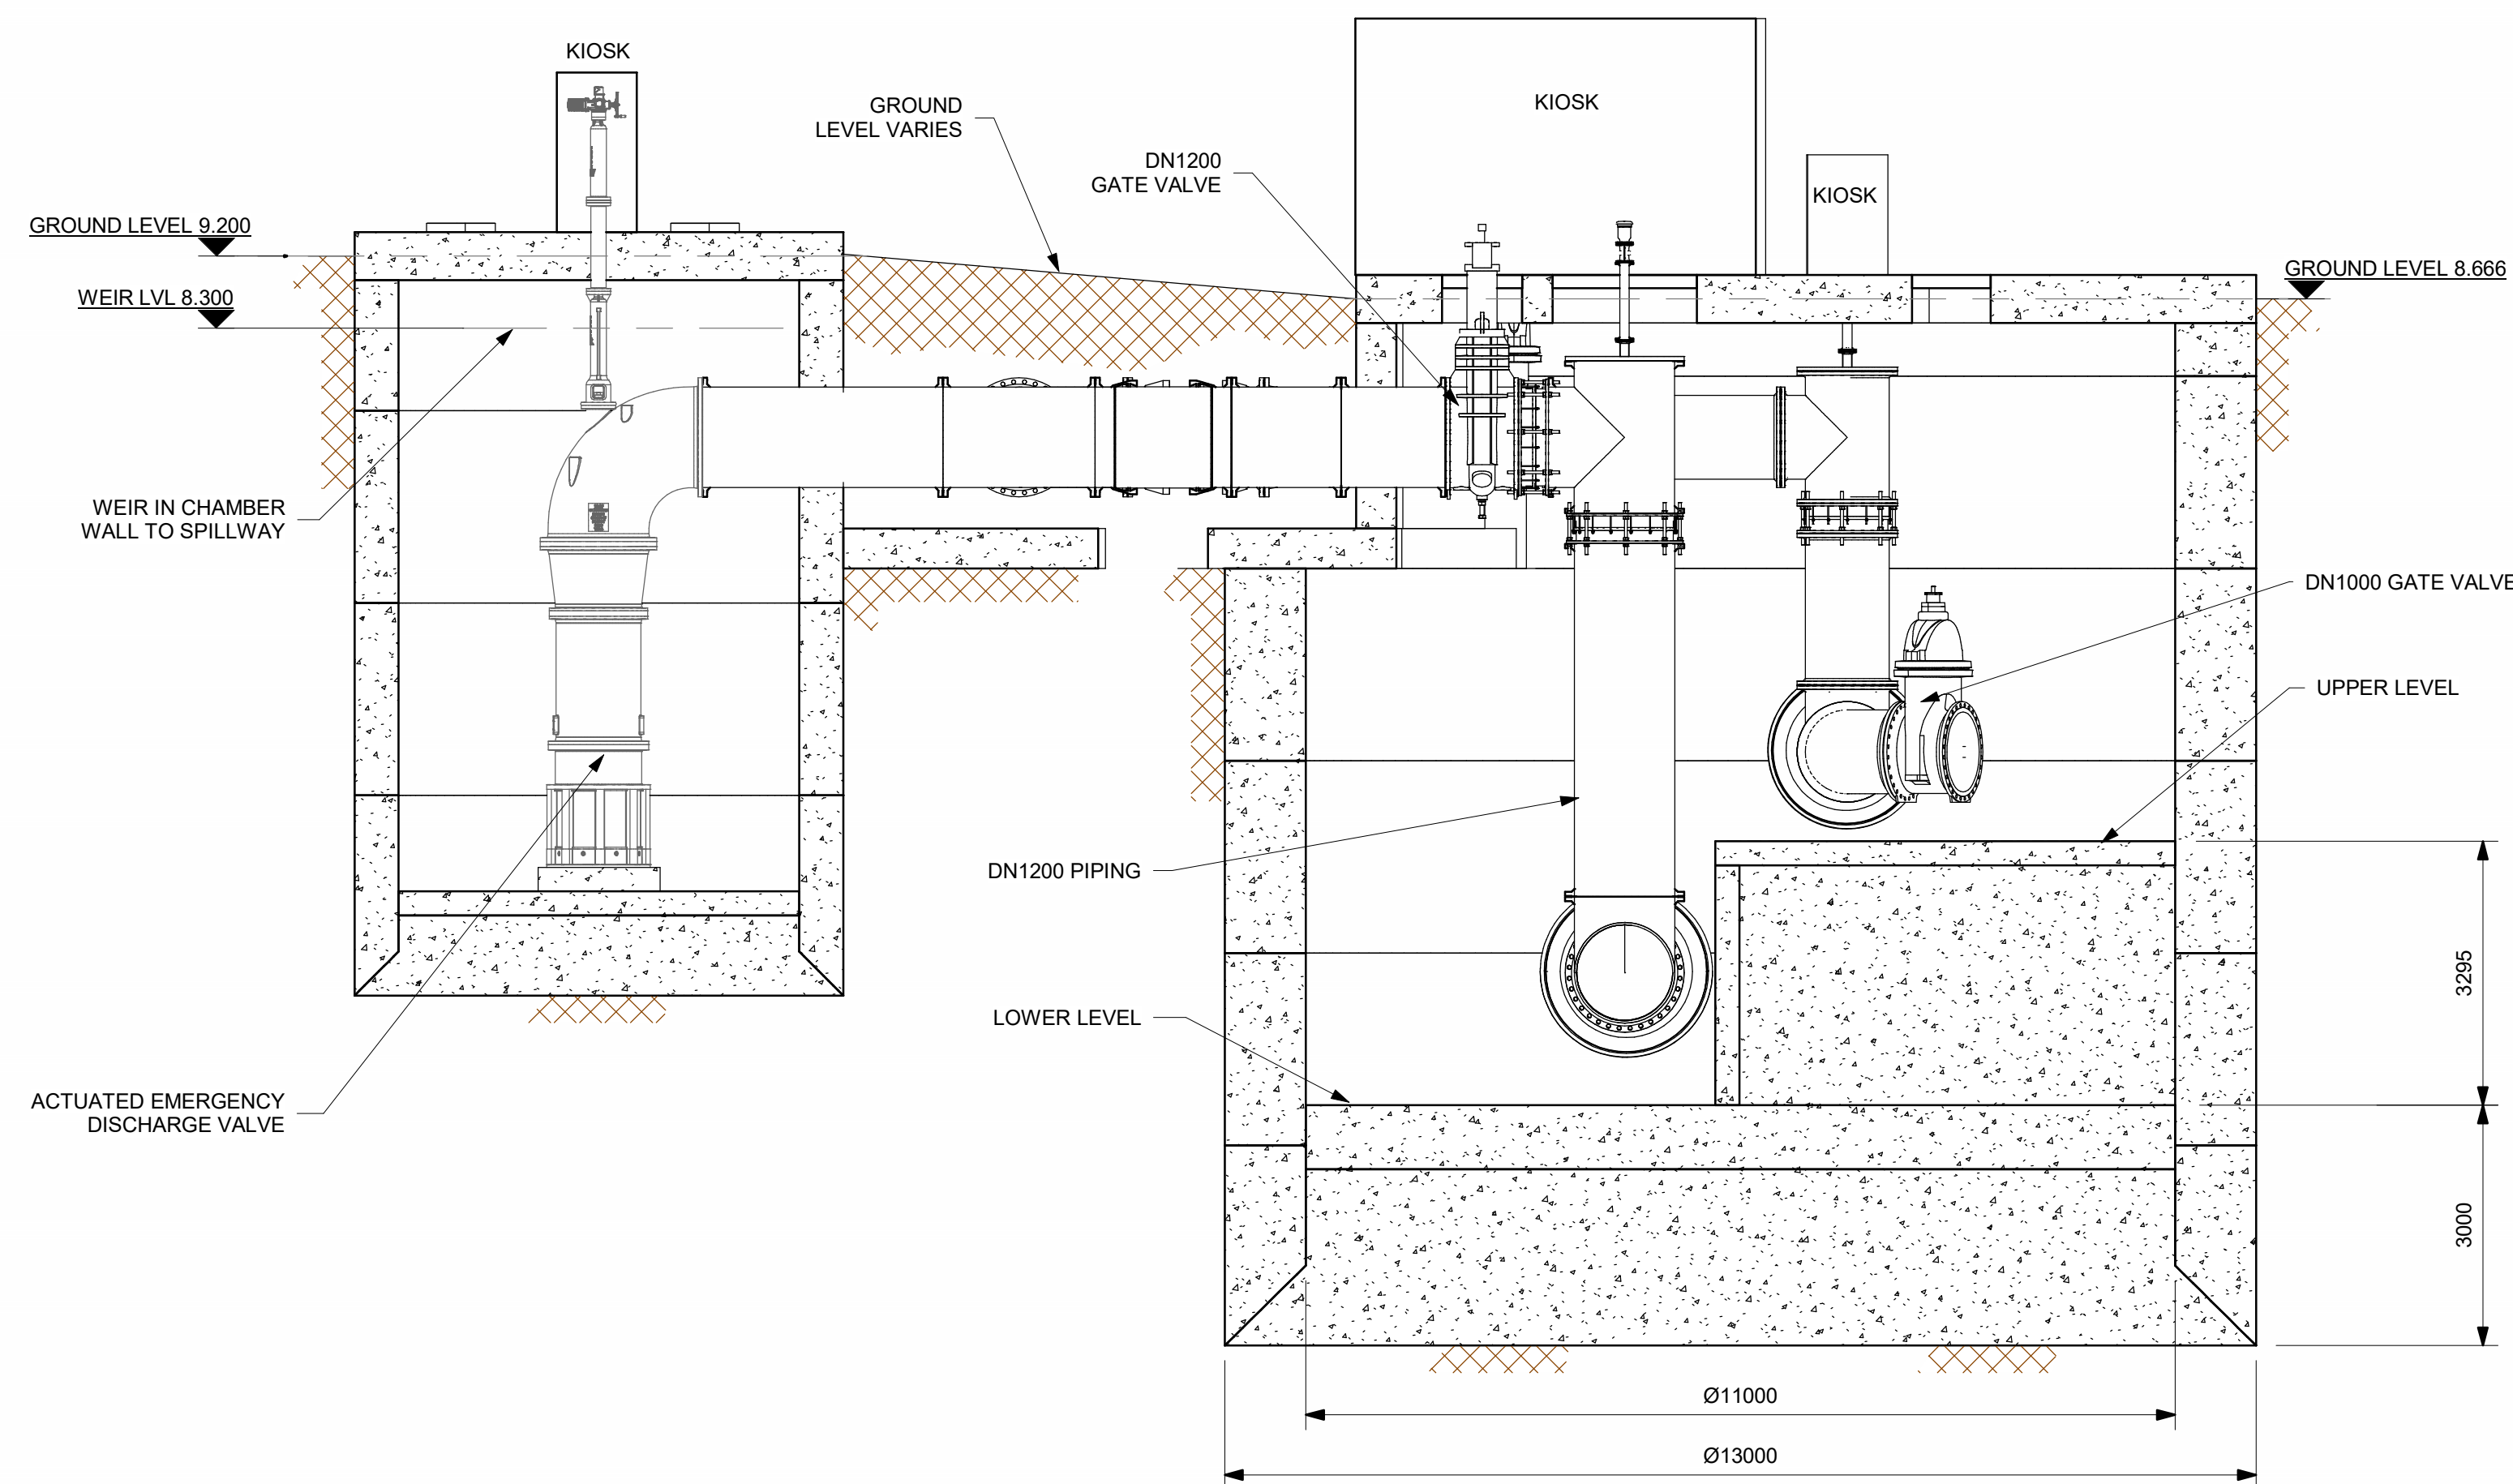


SECTION B-B

SCALE 1 : 50

Notes:

 1. ALL LEVELS ARE DEFINED IN METRES ABOVE ORDNANCE DATUM
2. SHAFT WALLS ARE 600mm ABOVE GROUND LEVEL DURING CONSTRUCTION. WALLS ARE CUT DOWN TO BELOW GROUND LEVEL IN PERMANENT STATE.
3. FOR ED CHAMBER PLAN SEE DRAWING: HTR-WAB-PI-ED-DR-T-0002
4. FOR ED SHAFT PERMANENT SITE PLAN SEE DRAWING: HTR-WAB-PI-ED-DR-T-0002
5. FOR ED KIOSK ELEVATIONS SEE DRAWING: HTR-WAB-PI-ED-DR-T-0003



P04 A4	RD	JT	BP	PLANNING VERSION	03/05/24
P03 S4	RD	JT	BP	FILL PIPE UPSIZE	16/02/24
P02 S4	RD	BP	BC	DUAL PIPELINE OPTION	18/09/23
Rev	Dm	Ckd	App	Description	Date
	By	By	By		

WARD & BURKE

Drawing Suitability: APPROVED FOR DETAILED DESIGN Status: A4

Contractors Drawing Number: HTR-WAB-PI-ED-DR-T-0004

Telephone: Havant (023) 9249 9888
Fax: Havant (023) 9245 3632
Website: www.portsmouthwater.co.uk
Registered Office: PO Box 8 West Street
Havant Hampshire PO9 1LG
REGISTERED IN ENGLAND No. 2536455



Date: 03/05/24 Scale: AS SHOWN Sheet: 01 OF 01 Sheet Size: A1

Project Title: HAVANT THICKET RESERVOIR

Drawing Title: BEDHAMPTON TO HTR PIPELINE
EMERGENCY DISCHARGE SHAFT & VALVE CHAMBER
GENERAL ARRANGEMENT

Portsmouth Water Drawing Number : Rev: P04