


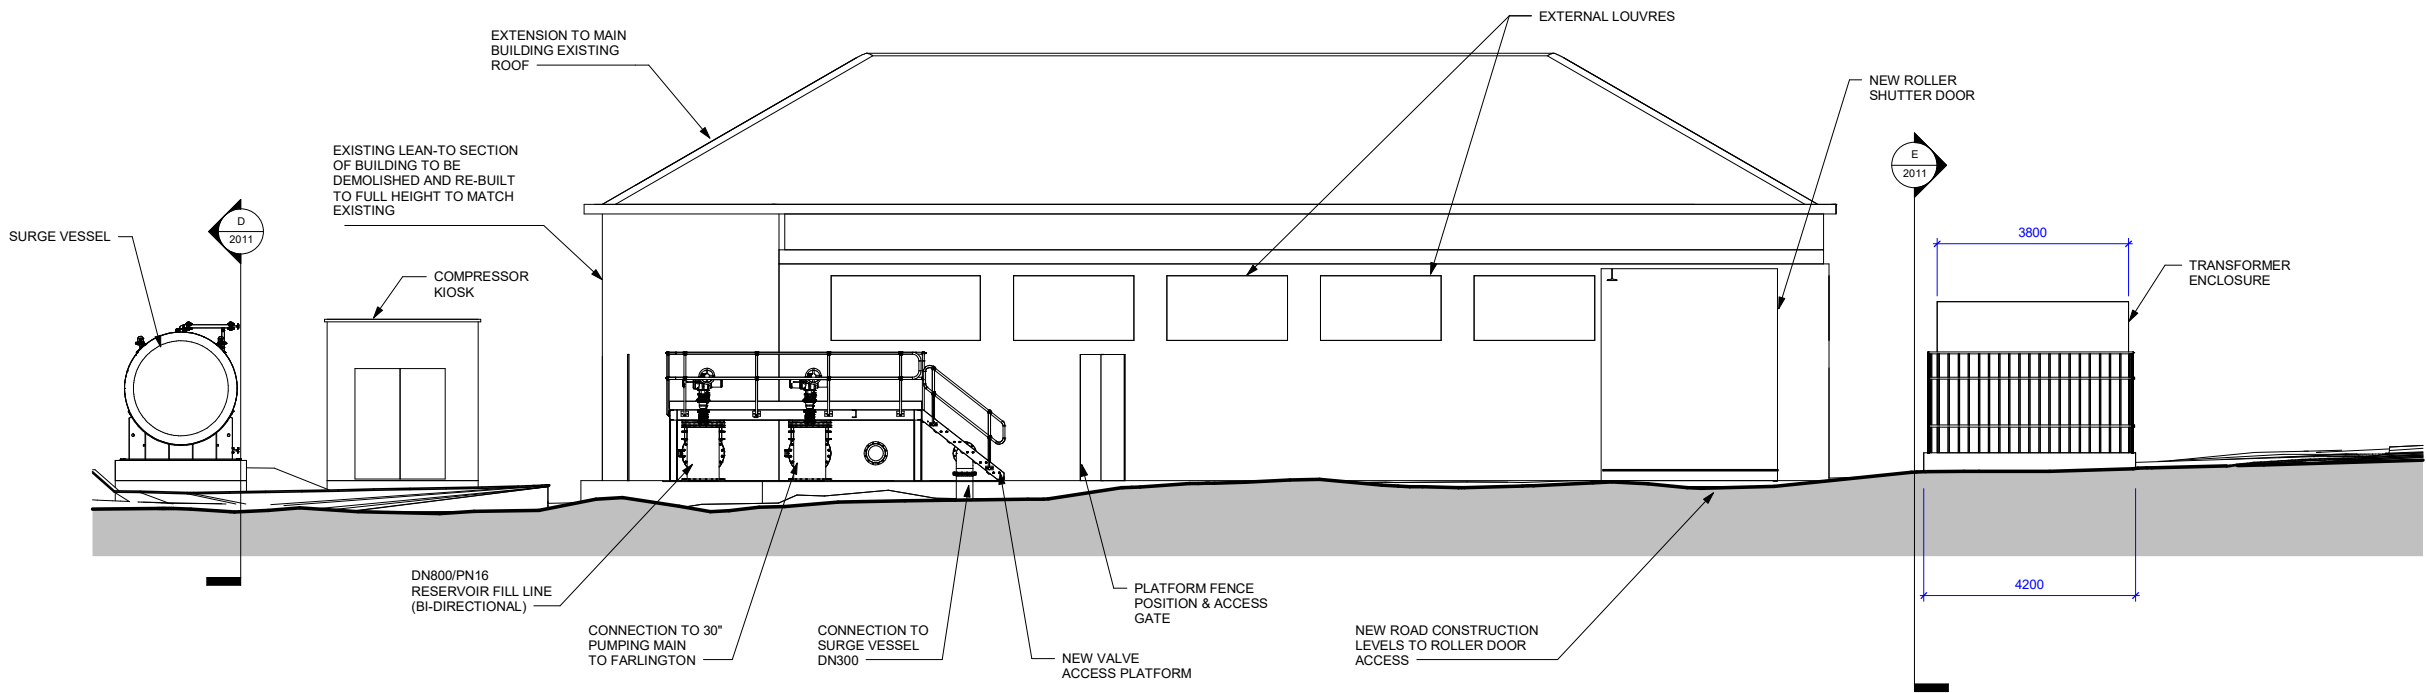


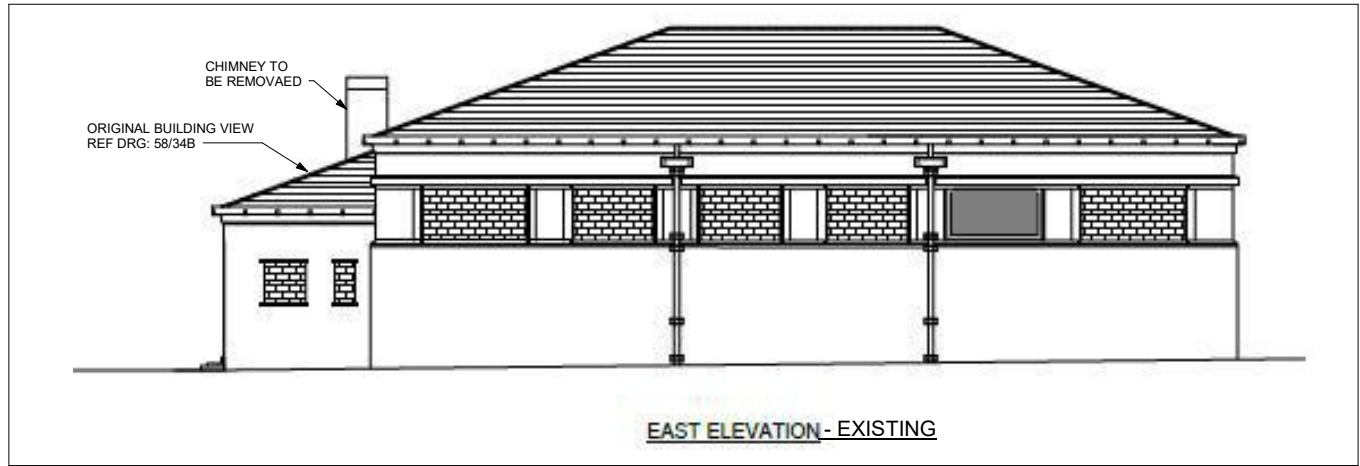


East Elevation - Proposed Building
1 : 75

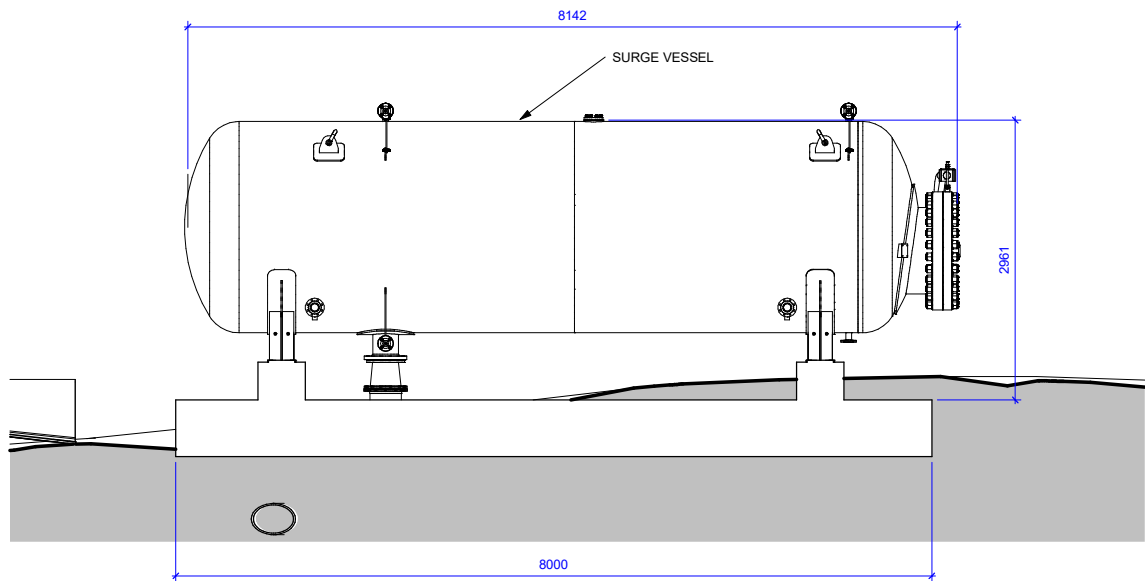

Section D - Surge Vessel/Transformer Slab Side Elevation
1 : 40

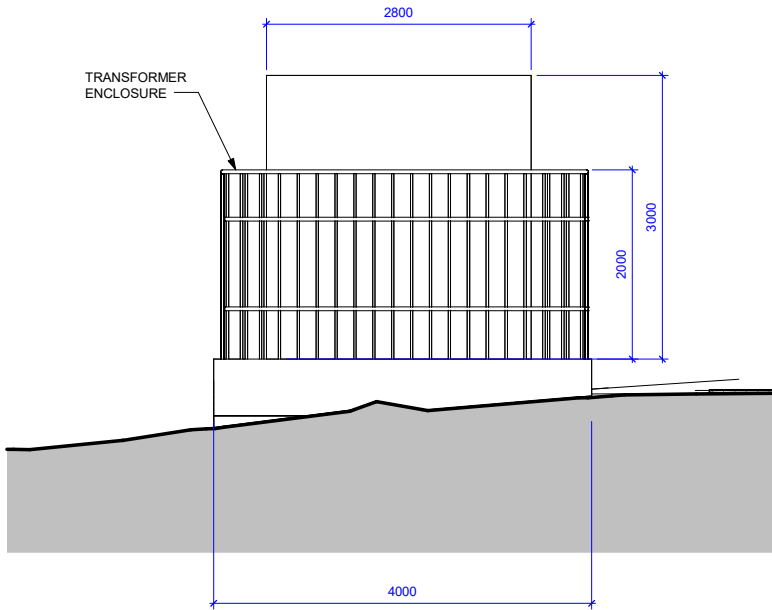

 Section E - Transformer Slab End View
1 : 40



- NOTES:
- ALL DIMENSIONS ARE IN MILLIMETRES UNLESS OTHERWISE SPECIFIED.

P08	REVISED AS PER CLIENT COMMENTS	JJC	MW	03/05/24
P07	EXISTING BUILDING ROOF DETAIL REMOVED. WEST ELEVATION ADDED.	JJC	SW	13/02/24
P06	BUILDING LAYOUT UPDATE	JJC	SW	21/11/23
P05	ROOF EXTENDED. PUMPS REMOVED FROM VIEW	JJC	SW	13/11/23
P04	CHANGE TO ROOF DETAIL. GALLERY PROTECTION ADDED TO SUCTION PIPEWORK	JJC	SW	22/09/23
P03	TRANSFORMER/SURGE VESSEL LOCATION CHANGED	JJC	SW	19/09/23
MK	REVISION	DRN	CHK	DATE
CLIENT: PORTSMOUTH WATER				

HAVANT THICKET - BEDHAMPTON 2

ELEVATION VIEWS

FOR PLANNING

DESIGNED: Designer

ORIGINAL DRAWING SIZE: A2 SCALE:

DRAWING NUMBER
HTR-BRD-PS-B2-DR-M- 2011

REV.
P08

UNLESS OTHERWISE STATED:

- 3RD ANGLE PROJECTION
- ALL DIMENSIONS IN MM
- NEVER SCALE FROM DRAWING - IF IN DOUBT ASK



Bridges Electrical Engineers Limited
Unit 31A, Second Avenue
Westfield Trading Estate
Midsomer Norton, Bath
BA3 4BH

Tel: 01761 419337
Fax: 01761 413521