




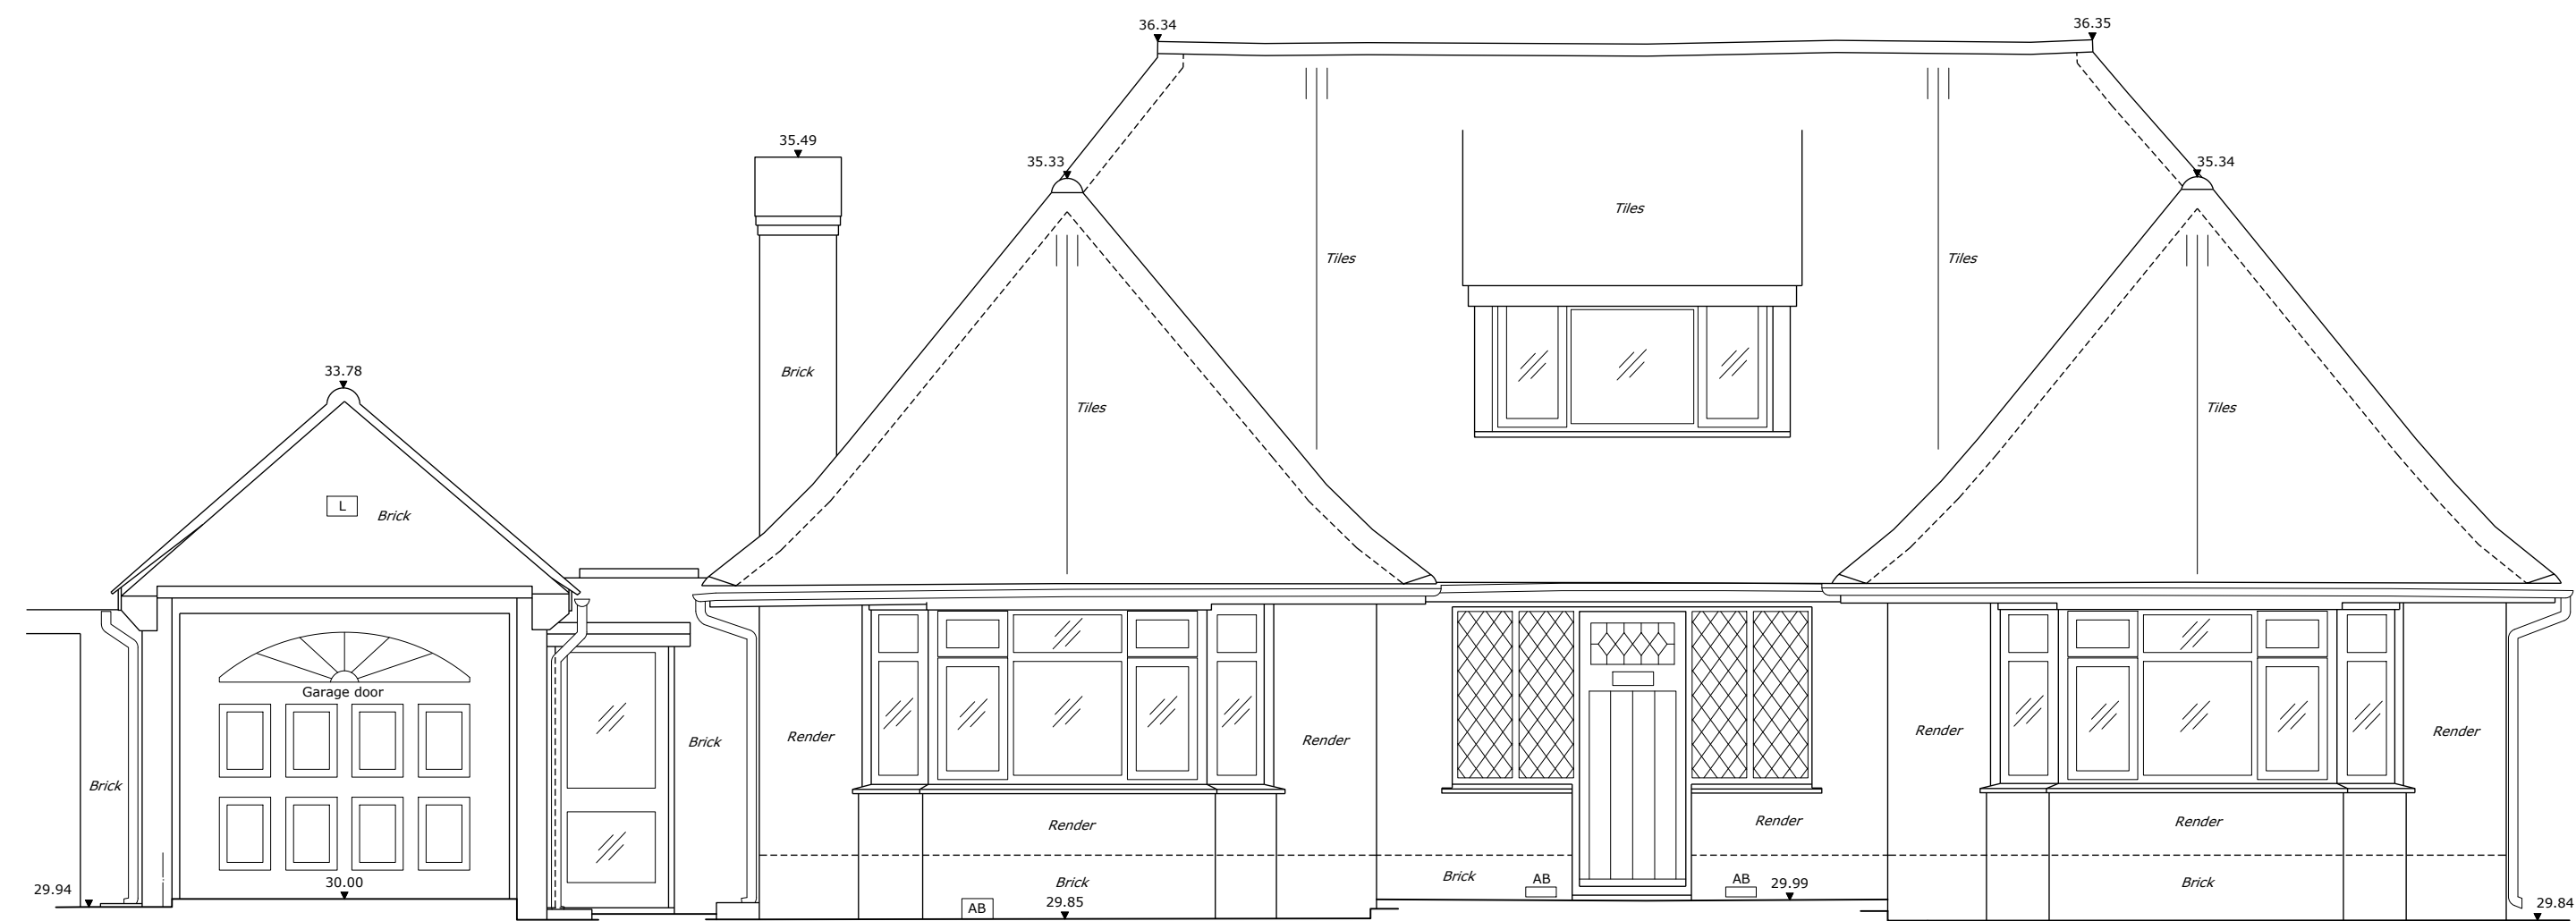


ELEVATION 1

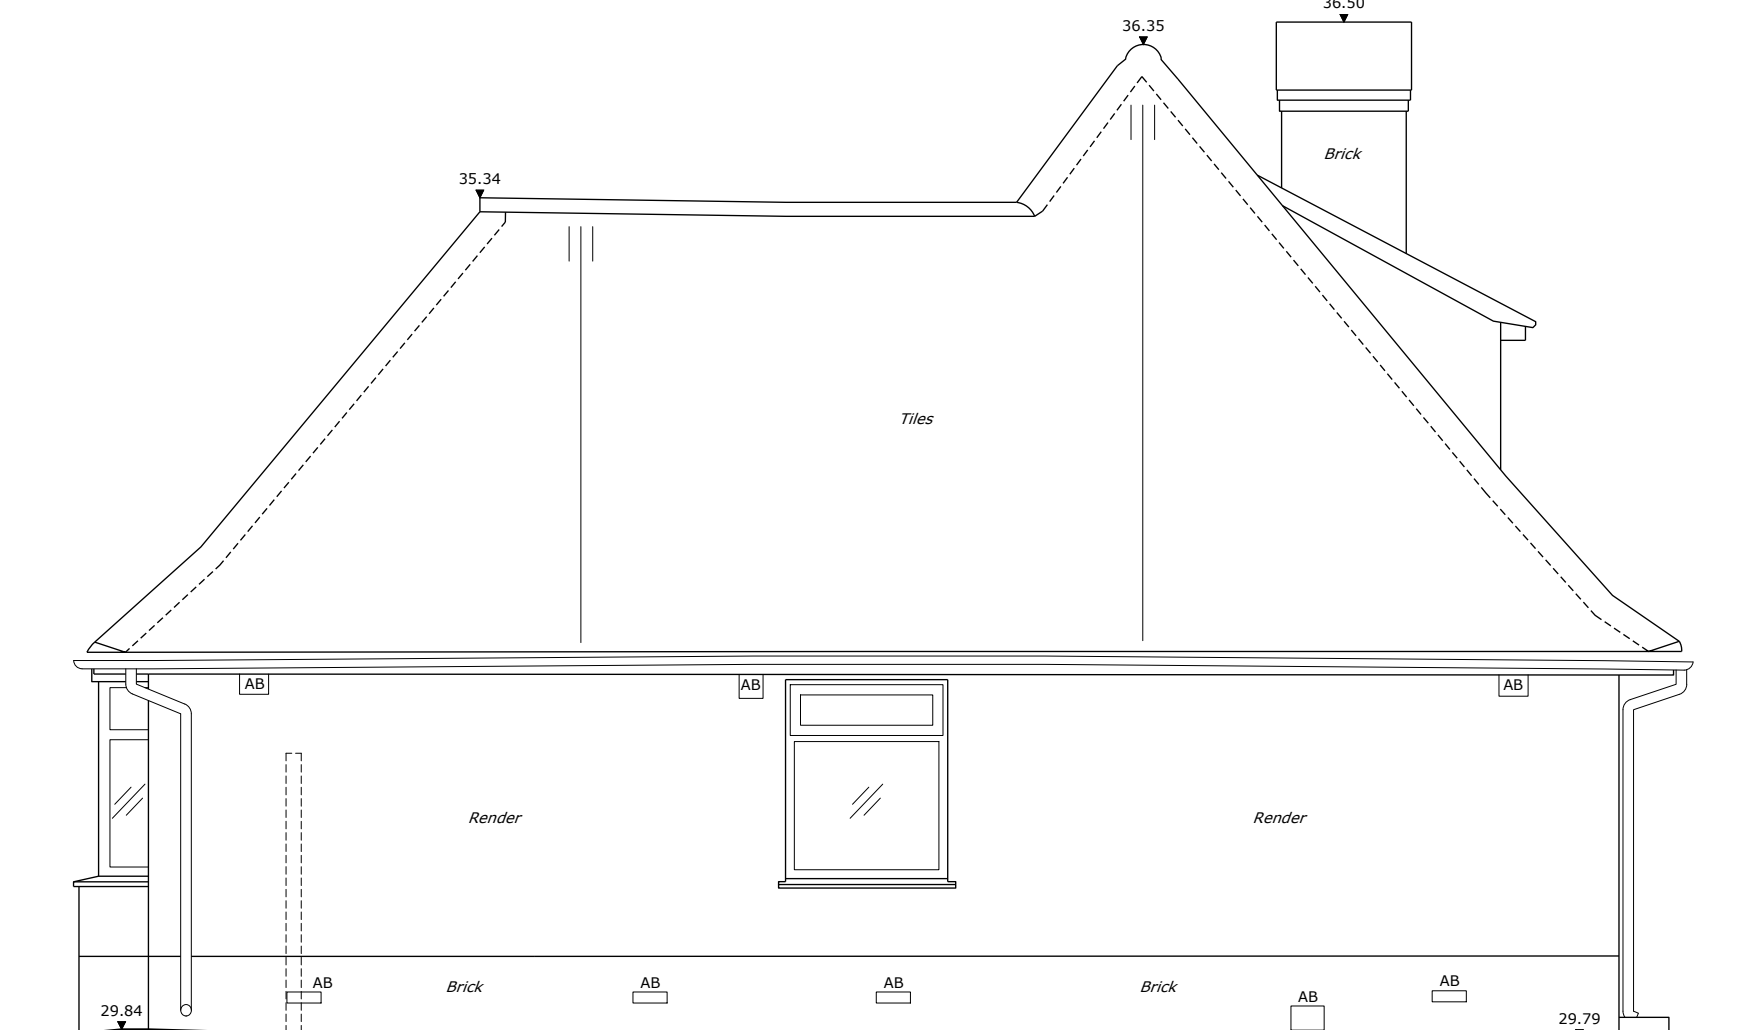

ELEVATION 2

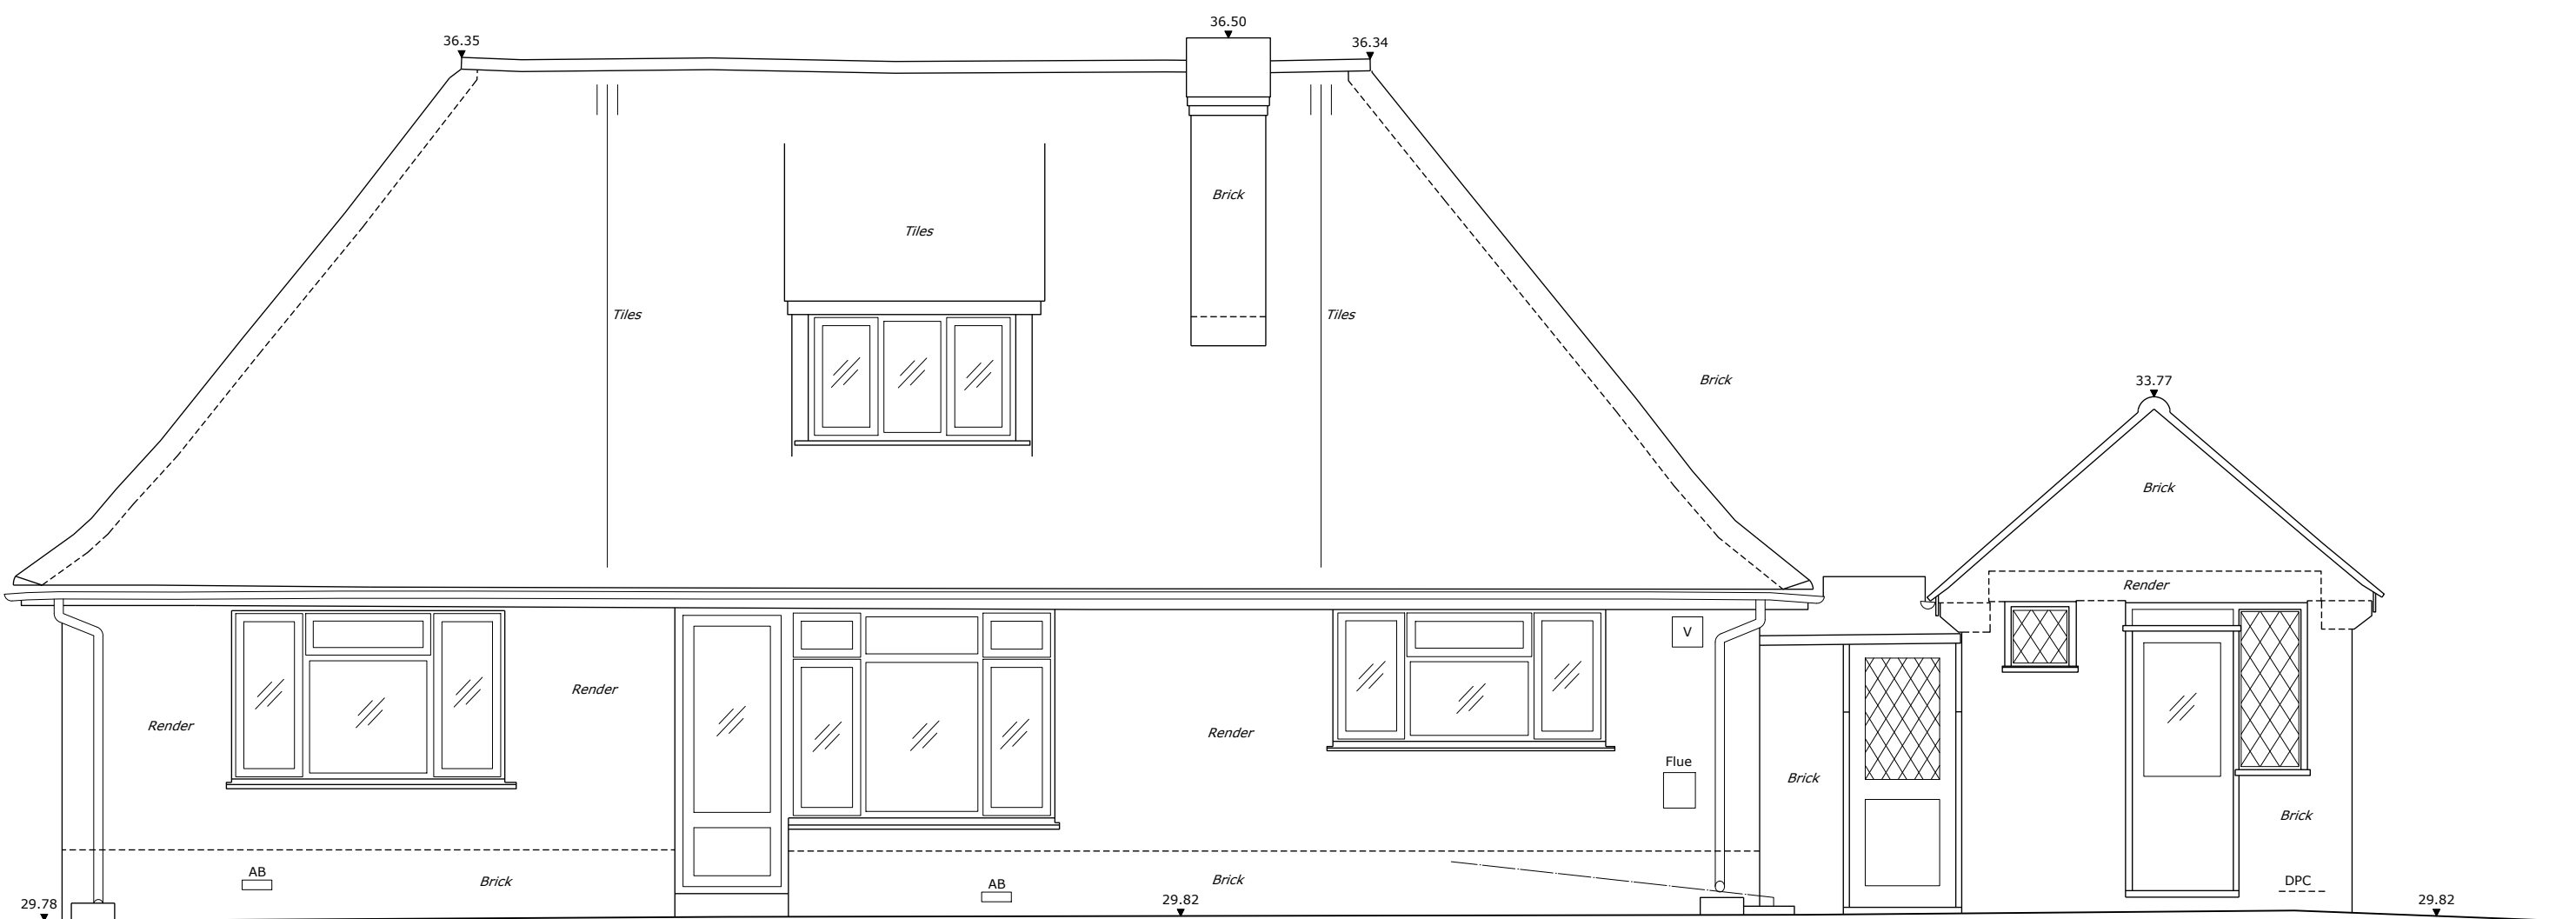

ELEVATION 3

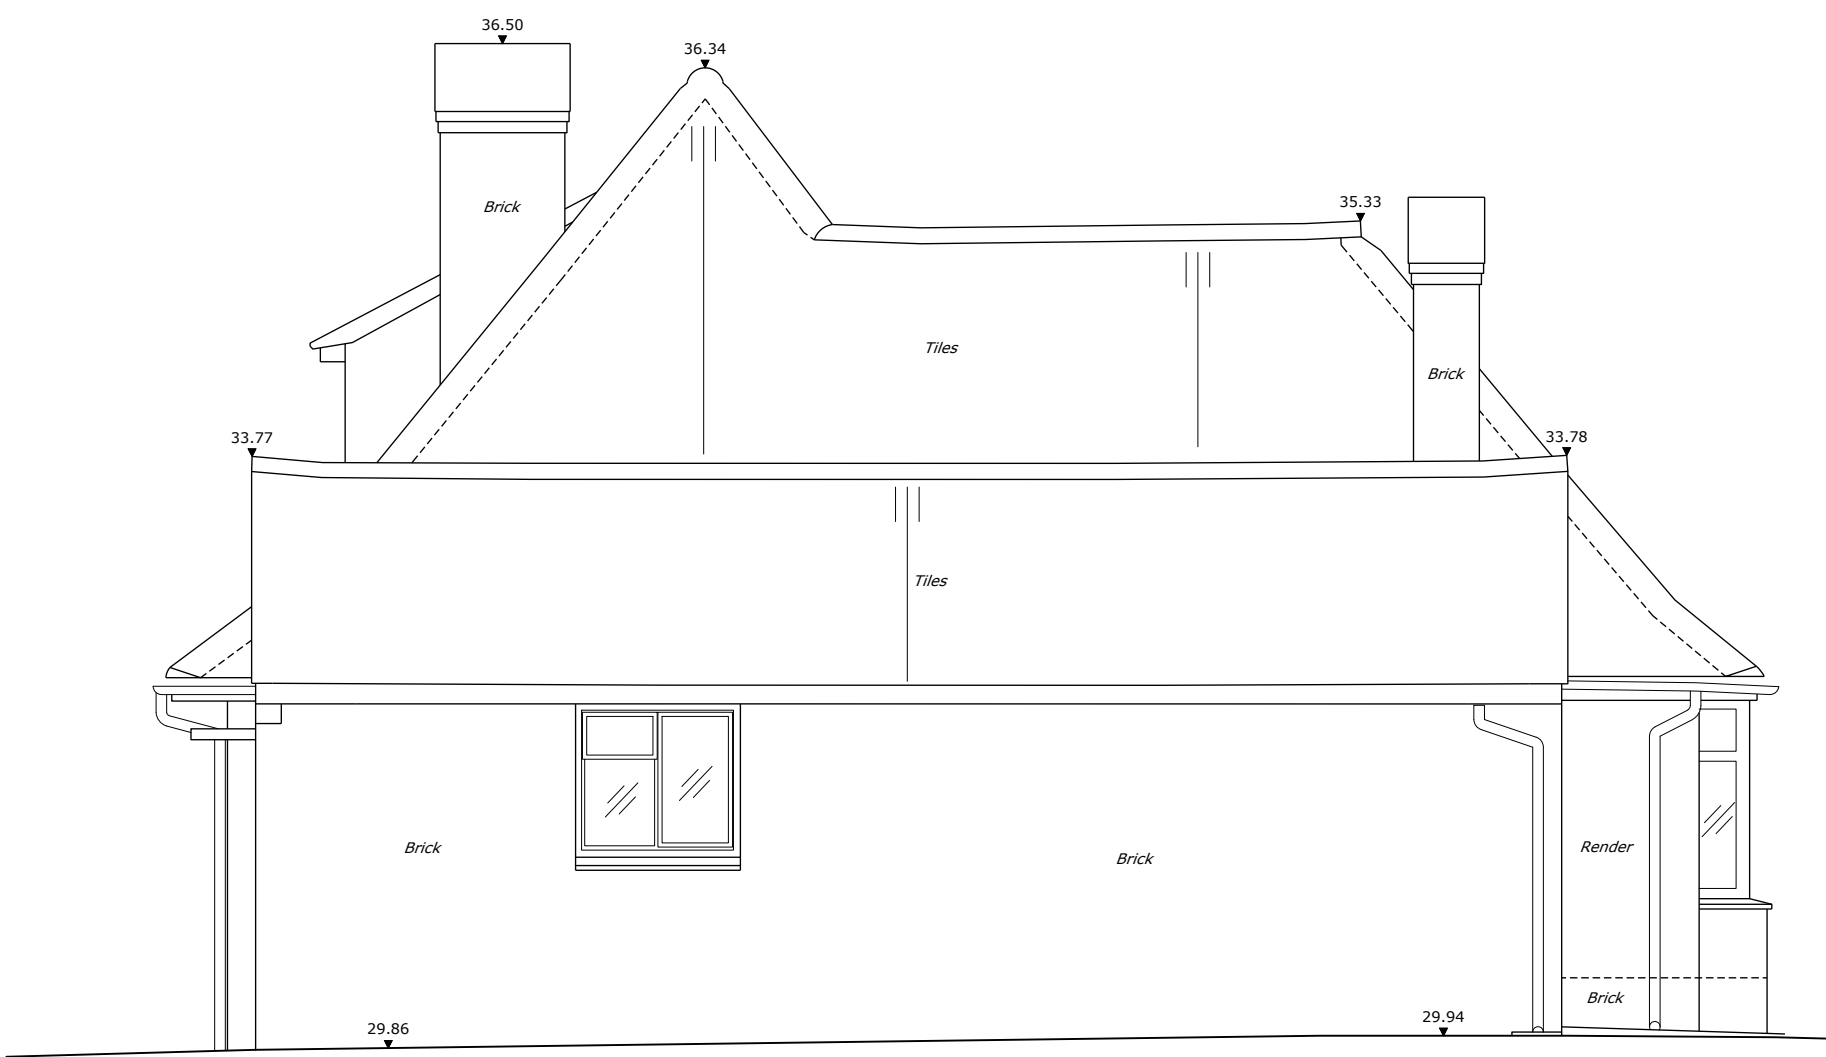

ELEVATION 4

SYMBOLS		
	SURVEY STATION	BENCH MARK
	STEP UP	LEVEL POSITION
	BANKING	SLOPING CEILING
	FENCE	SLOPING MASONRY
	HEDGE	GATES
	FOUL DRAINAGE (100mm Pipe)	TREE
	STORM DRAINAGE (100mm Pipe)	SAPLING
	ELECTRICITY U/G	TELECOM O/H
	ELECTRICITY O/H	TELECOM U/G
	SOLID WALL / BUILDING LINE	WATER MAIN
	ARCHED CEILING	GAS
	ELEVATION	FLOORBOARD DIRECTION
	SECTION	ANGLED FACE

SURVEY GRID	
Please note that the grid shown on this drawing is as follows;	
☒ Arbitrary	☐ Arbitrary but approximately related to grid North
☐ Best fit to Ordnance Survey Digital Data	☐ Ordnance Survey National Grid using GPS

LEVELS AND HEIGHTS	
ASL	ARCH SPRINGER LEVEL
ASL	ARCH SPRINGER LEVEL
BSL	BEAM SOFFIT LEVEL
CSL	CEILING SOFFIT LEVEL
DHL	DOOR HEAD LEVEL
IL	INVERT LEVEL
LL	LANDING LEVEL
FCSL	FALSE CEILING LEVEL
FL	FLOOR LEVEL
SL	SOFFIT LEVEL
THL	THRESHOLD LEVEL
WSL	WINDOW SILL LEVEL
WHL	WINDOW HEAD LEVEL
as	ARCH SPRINGER HEIGHT
ab	ARCH HEAD HEIGHT
b	BEAM SOFFIT HEIGHT
c	CEILING SOFFIT HEIGHT
cd	CLAD BEAM HEIGHT
d	DOOR HEAD HEIGHT
e	FALSE CEILING HEIGHT
s	SOFFIT HEIGHT
ws	WINDOW SILL HEIGHT
wh	WINDOW HEAD HEIGHT
PLEASE NOTE: ALL HEIGHTS TAKEN FROM FLOOR/LANDING UNLESS OTHERWISE STATED.	
DATUM: ARBITRARY	
STN101, VALUE: 30.000m	

ABBREVIATIONS (Where Applicable)	
AB	AIR BRICK
ACU	AIR CONDITIONING UNIT
BOL	BOLLARD
BRW	BRICK WALL
BT	BRITISH TELECOM
CATV	CABLE TELEVISION COVER
CE	CLEANING EYE
CL	COVER LEVEL
CPS	CONC PAVING SLABS
DP	DOWN PIPE
ECP	ELECTRIC CABLE PIT
EP	ELECTRICITY POLE
FH	FIRE HYDRANT
G	GULLY
GSC	GAS STOP COCK
GV	GAS VALVE
HWK	HOT WATER CYLINDER
HTR	HEATED TOWEL RAIL
IC	INSPECTION COVER
LP	LAMP POST
MH	MANHOLE
MKR	MARKER
NB	NOTICE BOARD
NFI	NO FURTHER INFORMATION
O/H	OVERHEAD
PLT	PAVEMENT LIGHT
R	RADIATOR
RG	ROAD GULLY
RH	RADIATOR HOUSING
RNB	ROAD NAME BOARD
RS	ROAD SIGN
RW	RETAINING WALL
RWP	RAINWATER PIPE
SC	STOP COCK
SP	SECURITY PANEL
SV	STOP VALVE
T	TRUNKING
TIC	TELECOM INSPECTION COVER
TOD	TRAP DOOR OVER
TLT	TRAFFIC LIGHT
TP	TELEGRAPH POLE
TPS	TACTILE PAVING SLABS
UTL	UNABLE TO LIFT
V	VENT
VP	VENT PIPE
WM	WATER METER
WP	WASTE PIPE

FENCE TYPES AND ABBREVIATIONS	
BW	BARBED WIRE
CB	CLOSE BOARDED
CL	CORRUGATED IRON
CLX	CHAIN LINK
CPG	CHESTNUT PALING
IR	IRON RAILINGS
PR	POST & RAIL
PW	POST & WIRE
OB	OPEN BOARDED
WM	WIRE MESH

FENCE TYPES AND ABBREVIATIONS	
BW	BARBED WIRE
CB	CLOSE BOARDED
CL	CORRUGATED IRON
CLX	CHAIN LINK
CPG	CHESTNUT PALING
IR	IRON RAILINGS
PR	POST & RAIL
PW	POST & WIRE
OB	OPEN BOARDED
WM	WIRE MESH

DRAWINGS	
This survey consists of floor plans, elevations and section.	


Mr & Mrs. Downer

80 Southleigh Road

HAVANT

PO9 2QL

ELEVATIONS		
SCALE:	SHEET SIZE:	DRAWING:
1:50	A1	1 OF 1
JOB No.	SURVEYOR:	DRAWN:
w240	WGP	WGP
	CHECKED:	DATE:
	GMP	NOV 2023

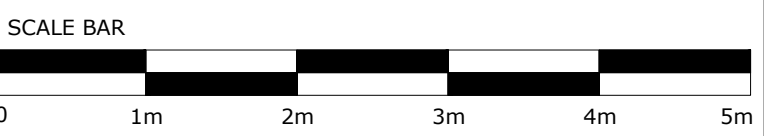

REV.	DATE	INIT	REVISION DETAILS

© WGP DIGITAL - ALL RIGHTS RESERVED.

TOPOGRAPHIC SURVEYS | MEASURED BUILDING SURVEYS | LASER SCANNING | BIM | 3D RECTIFIED PHOTOGRAPHY | AERIAL SURVEY & PHOTOGRAPHY | 360 IMAGERY | LEASE PLANS

45 LOWER WARDOWN, PETERSFIELD, HAMPSHIRE GU31 4PA

TEL. 07798 711271

Email: warren@wgpdigital.com

Web: https://www.wgpdigital.com