
 


SITE LOCATION

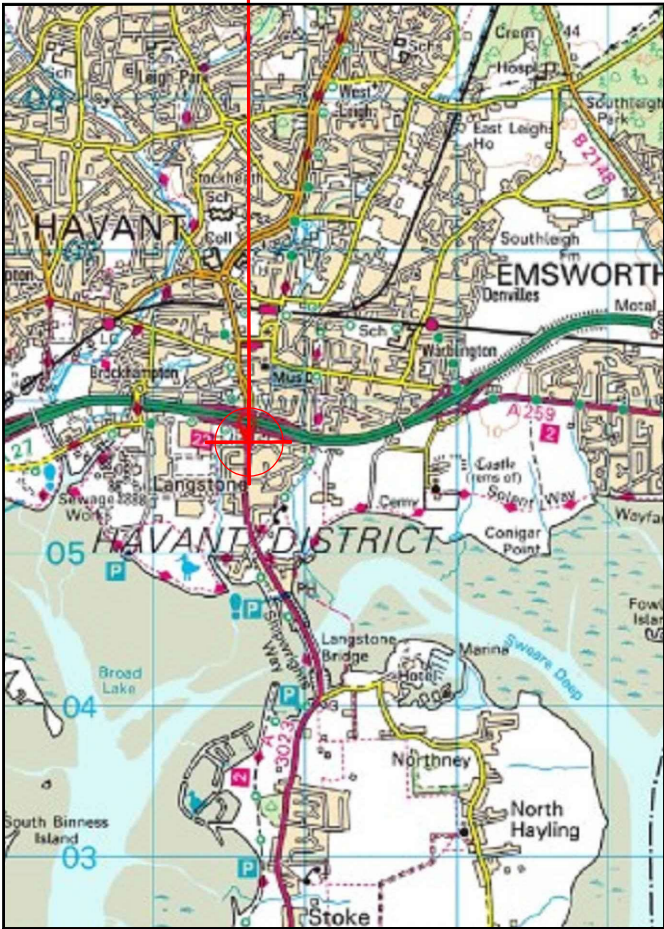


Reproduced by permission of Ordnance Survey on behalf of the Controller of Her Majesty's Stationery Office
All rights reserved. © Crown Copyright licence no. 100022432

SITE AREA PLAN




SITE PHOTOGRAPH

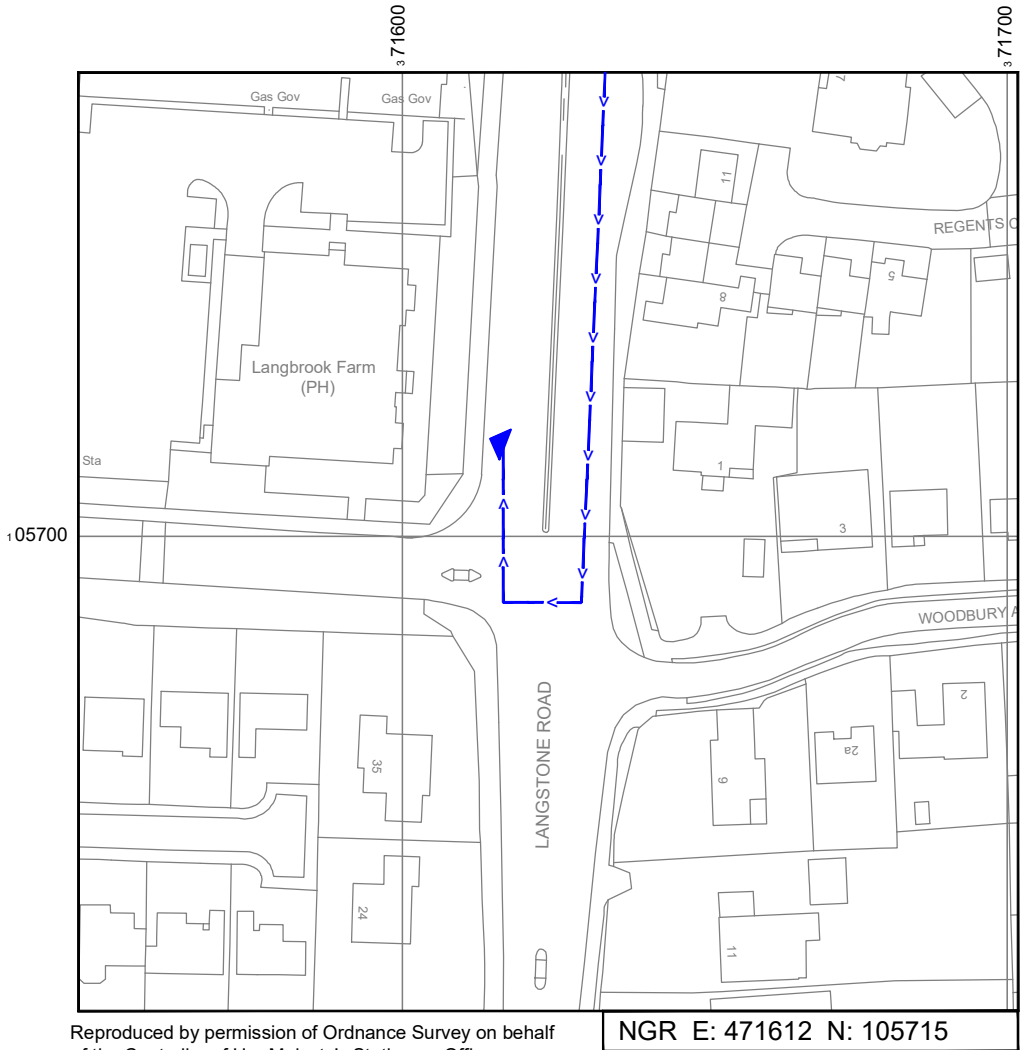

Reproduced by permission of Ordnance Survey on behalf
of the Controller of Her Majesty's Stationery Office
All rights reserved. © Crown Copyright licence no. 100022432

 SITE LOCATION PLAN



GOOGLE MAPS QR CODE

GOOGLE MAPS - <https://g.page/LangbrookFarmHavant?share>

GOOGLE STREETVIEW -<https://goo.gl/maps/RzThfrAFrcUMVjX38>

NOTES:

1. ALL DIMENSIONS IN MM UNLESS OTHERWISE NOTED.

DIRECTIONS TO SITE:

Head East on Havant Bypass/A27 and take the exit towards Rowlands Castle/Langstone/Industrial Estate N/Industrial Est Central and after 0.3 miles at the roundabout , take the 3rd exit onto Langstone Road/A3023.After 0.1 miles make a U-turn and then site will be on left hand side.

Access Route To Site:



Master:	MBNL / EE / H3G:	Project:	Purpose of Issue:	Issue:
M002	H3G	DENSIFICATION SW	Planning	B
Date:	06/10/2022	Revision / Upgrade Description:		
Drawn:	S.Booth	QR code and directions updated		
Checked:	G.Thomas			
Approved:	G.Thomas			
Master:	MBNL / EE / H3G:	Project:	Purpose of Issue:	Issue:
M001	H3G	DENSIFICATION SW	Planning	A
Date:	15/09/2022	Revision / Upgrade Description:		
Drawn:	S.Booth	First Issue - Site nomination dated: TBC		
Checked:	G.Thomas			
Approved:	G.Thomas			



Hutchison 3G UK Limited
Green Park, 450 Longwater Avenue
Reading, RG30 3UR
Tel: 01628 765 000
Fax: 01628 765 001

H3G Base Station Information line:
0845 6043000
Available 8am-8pm Monday to Friday

Design Consultant & Principal Contractor:



Unit E, Madison Place, Northampton Road,
Manchester, M40 5AG
Tel: 0161 785 4500 Fax: 0161 785 4501
Web: www.clarke-telecom.com

Site Name: LANGSTONE ROAD

Site ID: HVT25307

Address: LANGSTONE ROAD
HAVANT
HAMPSHIRE
PO9 1RE


Title: 002 SITE LOCATION PLAN

Project: H3G DENSIFICATION STREETWORKS

Purpose of Issue: PLANNING

EE Cell ID:	MBNL Cell ID:	3UK Cell ID:
-	-	HVT25307

Master Drawing No:	Issue:
HVT25307_B35_M002_H3G_DNSW_GA_B	B

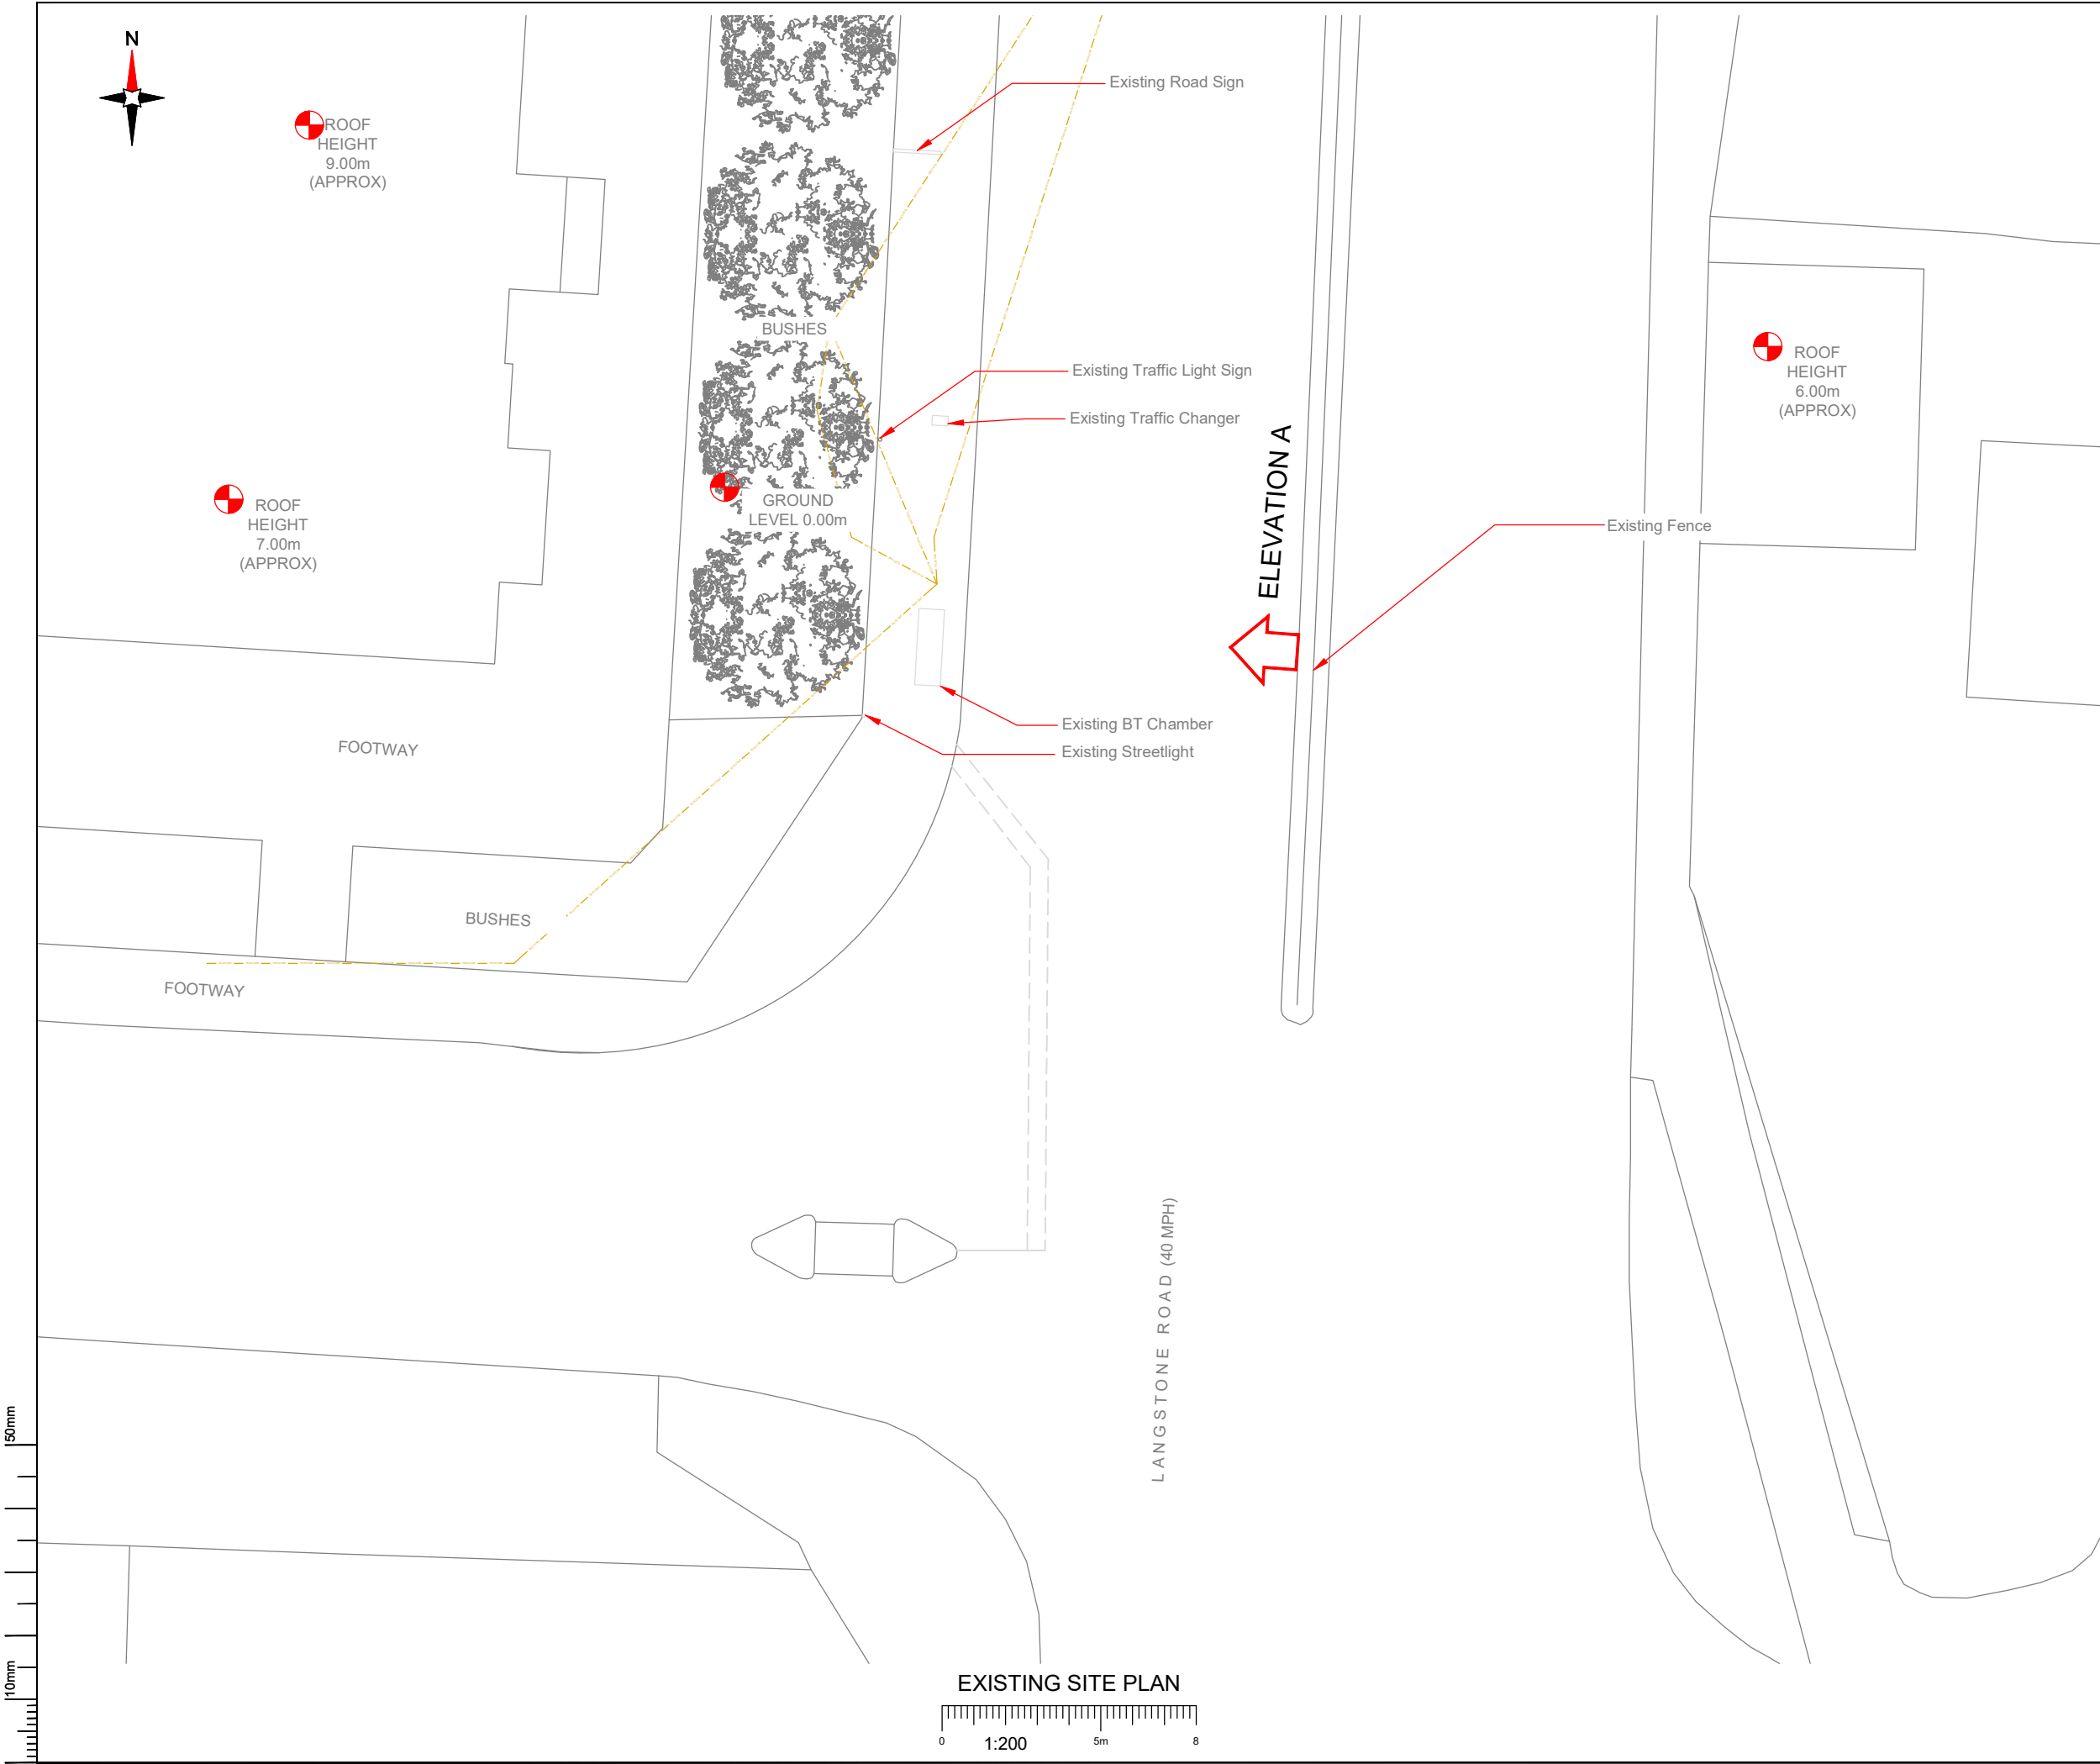

NOTES:

1. ALL DIMENSIONS IN MM UNLESS OTHERWISE NOTED.

SERVICES:

WATER HV GAS TELECOMS ELEC

NOTES:

Stats to be reviewed prior to any build works commencing.Radar Scan TBC.

Master:	MBNL / EE / H3G:	Project:	Purpose of Issue:	Issue:
M002	H3G	DENSIFICATION SW	Planning	B
Date:	06/10/2022	Revision / Upgrade Description:		
Drawn:	S.Booth	QR code and directions updated		
Checked:	G.Thomas			
Approved:	G.Thomas			
Master:	MBNL / EE / H3G:	Project:	Purpose of Issue:	Issue:
M001	H3G	DENSIFICATION SW	Planning	A
Date:	15/09/2022	Revision / Upgrade Description:		
Drawn:	S.Booth	First Issue - Site nomination dated: TBC		
Checked:	G.Thomas			
Approved:	G.Thomas			

Hutchison 3G UK Limited
Green Park, 450 Longwater Avenue
Reading, RG30 3UR
Tel: 01628 765 000
Fax: 01628 765 001


H3G Base Station Information line:
0845 6043000
Available 8am-8pm Monday to Friday

Design Consultant & Principal Contractor:


Unit E, Madison Place, Northampton Road,
Manchester, M40 5AG
Tel: 0161 785 4500 Fax: 0161 785 4501
Web: www.clarke-telecom.com

Site Name:	LANGSTONE ROAD				
Site ID:	HVT25307				
Address:	LANGSTONE ROAD HAVANT HAMPSHIRE PO9 1RE				
Title:	100 EXISTING H3G SITE PLAN				
Project:	H3G DENSIFICATION STREETWORKS				
Purpose of Issue:	PLANNING				
EE Cell ID:	-	MBNL Cell ID:	-	3UK Cell ID:	HVT25307
Master Drawing No:					Issue:
HVT25307_B35_M002_H3G_DNSW_GA_B					B

100mm
50mm
10mm

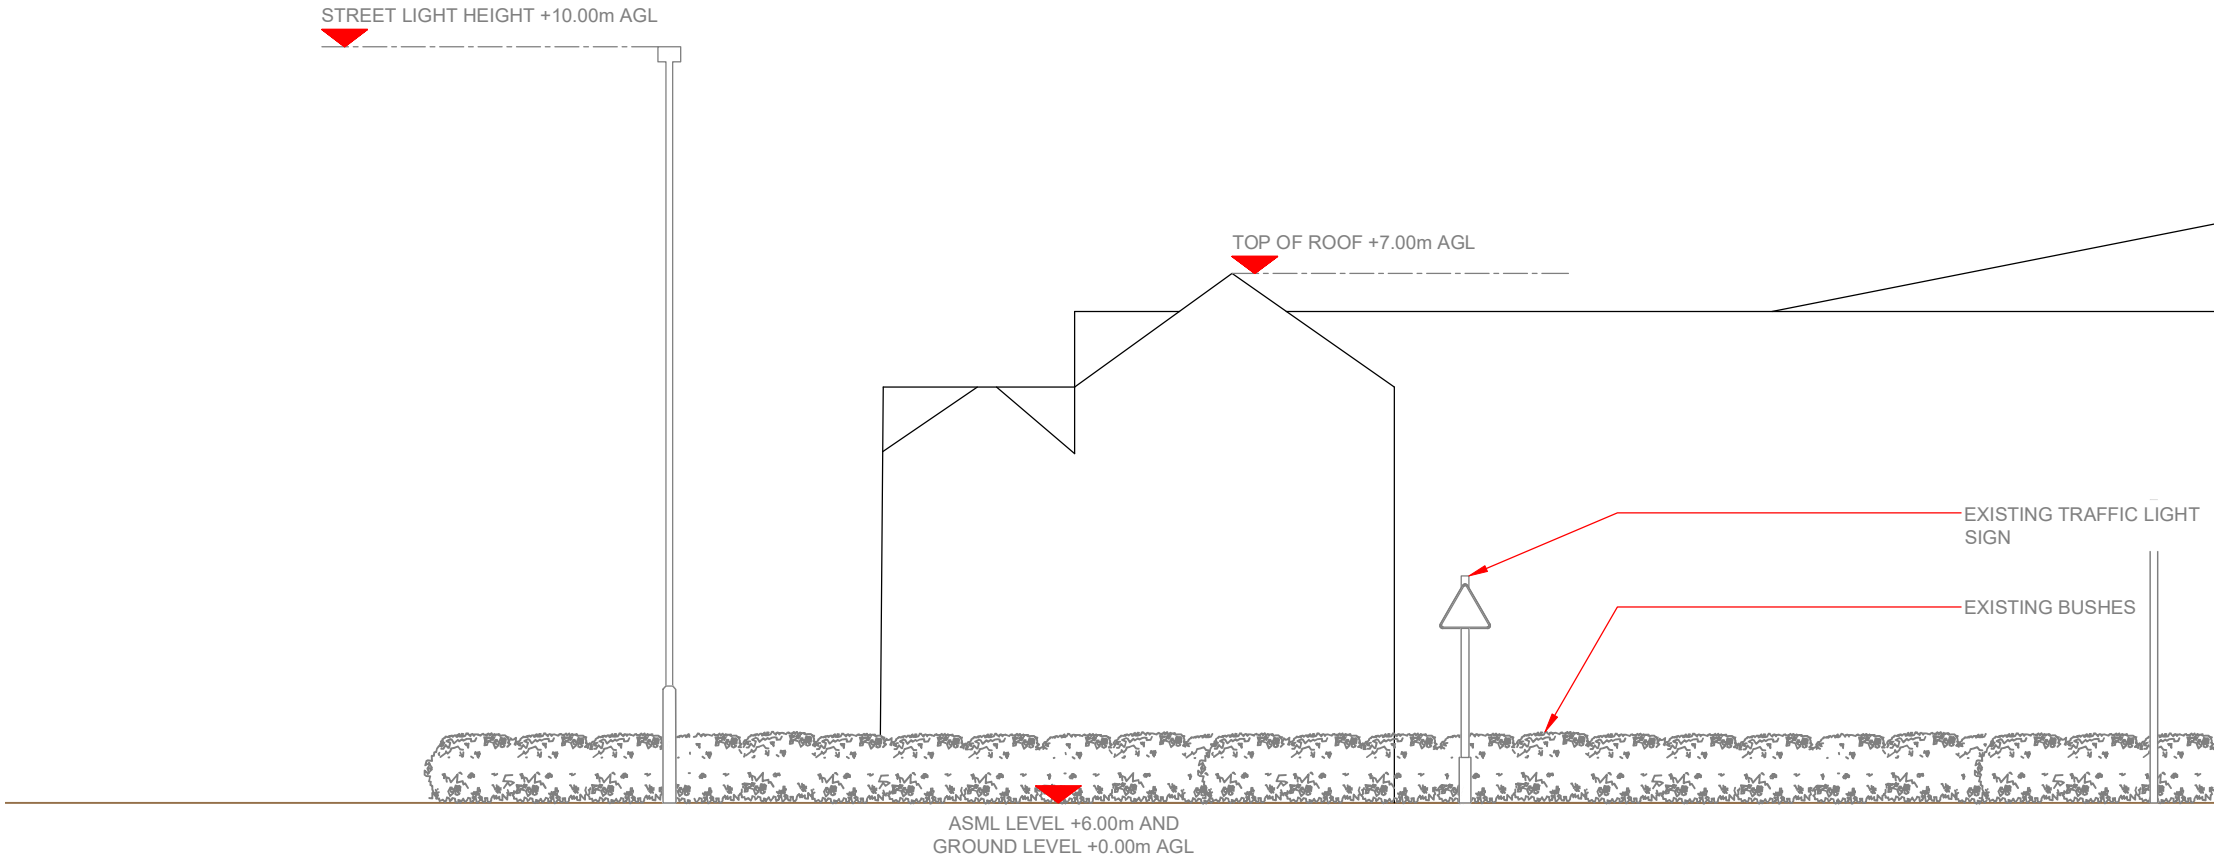

EXISTING ELEVATION A

 

- NOTES:
- ALL DIMENSIONS IN MM UNLESS OTHERWISE NOTED.

Master:	MBNL / EE / H3G:	Project:	Purpose of Issue:	Issue:
M002	H3G	DENSIFICATION SW	Planning	B
Date:	06/10/2022	Revision / Upgrade Description:		
Drawn:	S.Booth	QR code and directions updated		
Checked:	G.Thomas			
Approved:	G.Thomas			
Master:	MBNL / EE / H3G:	Project:	Purpose of Issue:	Issue:
M001	H3G	DENSIFICATION SW	Planning	A
Date:	15/09/2022	Revision / Upgrade Description:		
Drawn:	S.Booth	First Issue - Site nomination dated: TBC		
Checked:	G.Thomas			
Approved:	G.Thomas			




Hutchison 3G UK Limited
Green Park, 450 Longwater Avenue
Reading, RG30 3UR
Tel: 01628 765 000
Fax: 01628 765 001

H3G Base Station Information line:
0845 6043000
Available 8am-8pm Monday to Friday

Design Consultant & Principal Contractor:



CLARKE telecom
Unit E, Madlison Place, Northampton Road,
Manchester, M40 5AG
Tel: 0161 785 4500 Fax: 0161 785 4501
Web: www.clarke-telecom.com

Site Name:	LANGSTONE ROAD		
Site ID:	HVT25307		
Address:	LANGSTONE ROAD HAVANT HAMPSHIRE PO9 1RE		
Title:	150 EXISTING H3G SITE ELEVATION		
Project:	H3G DENSIFICATION STREETWORKS		
Purpose of Issue:	PLANNING		
EE Cell ID:	MBNL Cell ID:	3UK Cell ID:	
-	-	HVT25307	
Master Drawing No:			Issue:
HVT25307_B35_M002_H3G_DNSW_GA_B			B

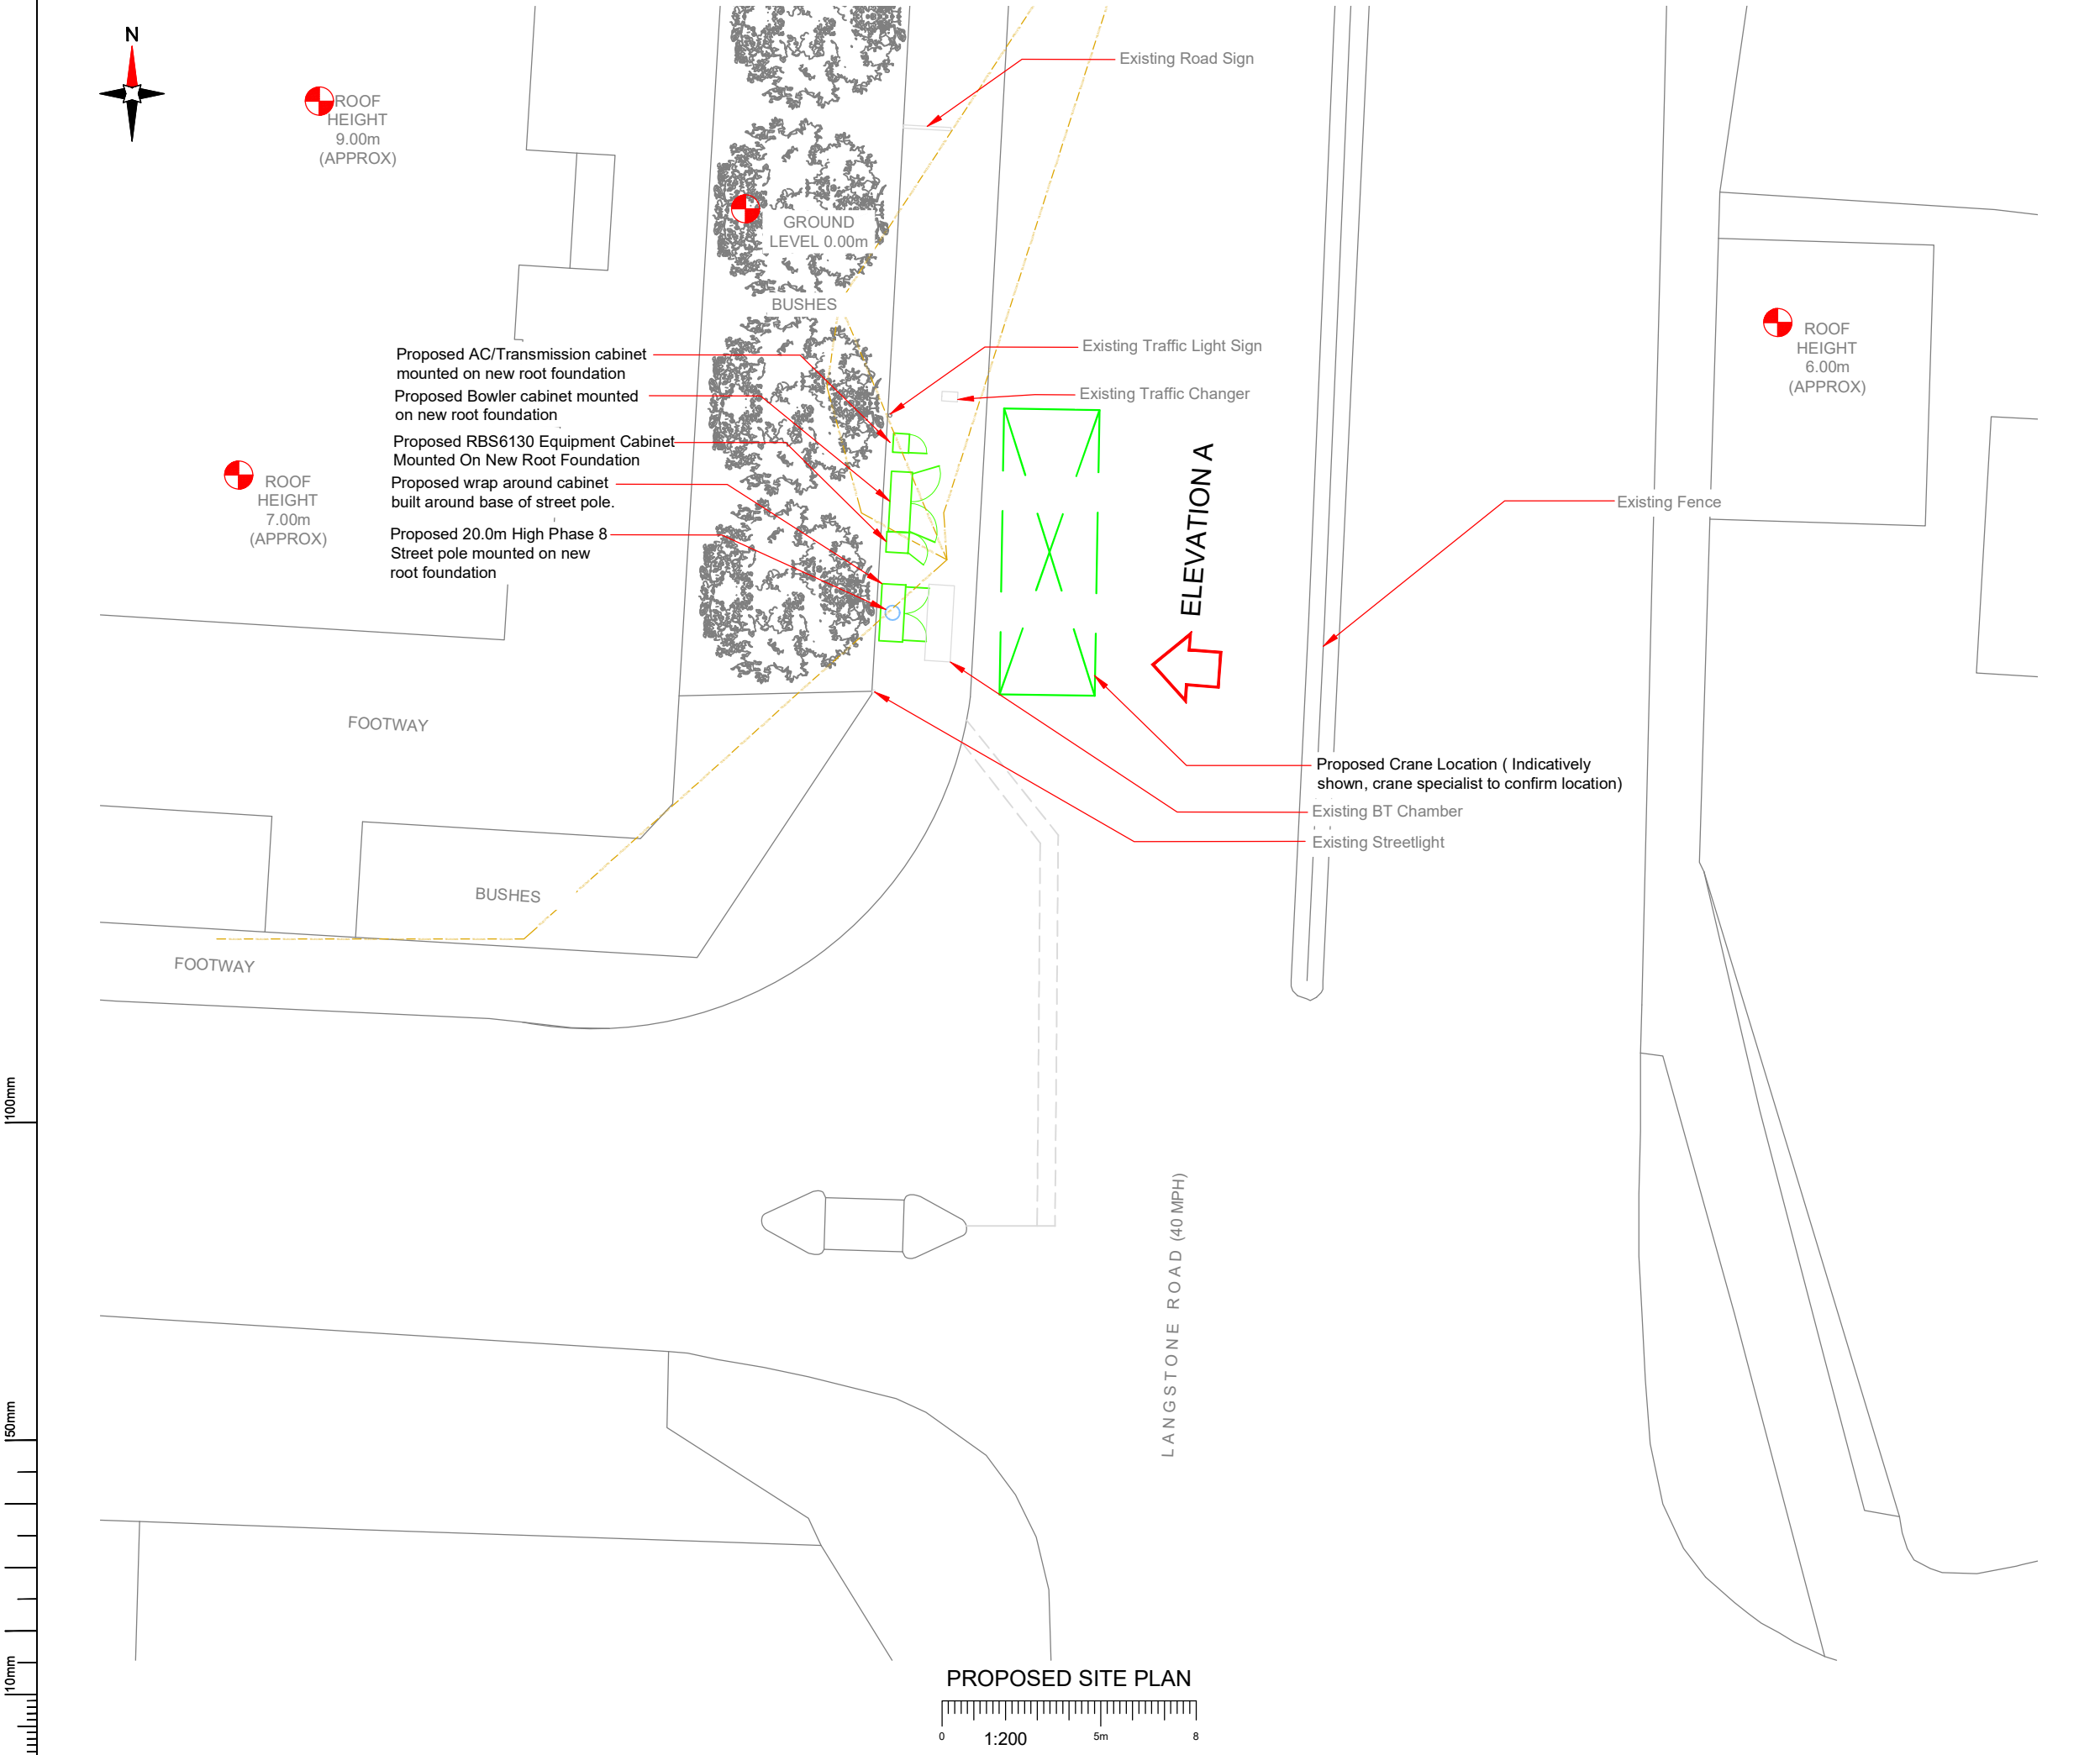

NOTES:

1. ALL DIMENSIONS IN MM UNLESS OTHERWISE NOTED.

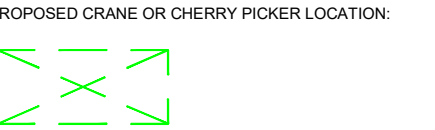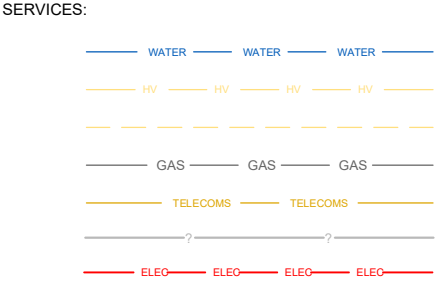

NOTES:

Stats to be reviewed prior to any build works commencing.Radar Scan TBC.

Master:	MBNL / EE / H3G:	Project:	Purpose of Issue:	Issue:
M002	H3G	DENSIFICATION SW	Planning	B
Date:	06/10/2022	Revision / Upgrade Description:		
Drawn:	S.Booth	QR code and directions updated		
Checked:	G.Thomas			
Approved:	G.Thomas			
Master:	MBNL / EE / H3G:	Project:	Purpose of Issue:	Issue:
M001	H3G	DENSIFICATION SW	Planning	A
Date:	15/09/2022	Revision / Upgrade Description:		
Drawn:	S.Booth	First Issue - Site nomination dated: TBC		
Checked:	G.Thomas			
Approved:	G.Thomas			




Hutchison 3G UK Limited
Green Park, 450 Longwater Avenue
Reading, RG30 3UR
Tel: 01628 765 000
Fax: 01628 765 001

H3G Base Station Information line:
0845 6043000
Available 8am-8pm Monday to Friday

Design Consultant & Principal Contractor:

Unit E, Madison Place, Northampton Road,
Manchester, M40 5AG
Tel: 0161 785 4500 Fax: 0161 785 4501
Web: www.clarke-telecom.com

Site Name:		LANGSTONE ROAD	
Site ID:		HVT25307	
Address:		LANGSTONE ROAD HAVANT HAMPSHIRE PO9 1RE	
Title:		210 PROPOSED H3G SITE PLAN	
Project:		H3G DENSIFICATION STREETWORKS	
Purpose of Issue:		PLANNING	
EE Cell ID:	MBNL Cell ID:	3UK Cell ID:	
-	-	HVT25307	
Master Drawing No:			Issue:
HVT25307_B35_M002_H3G_DNSW_GA_B			B

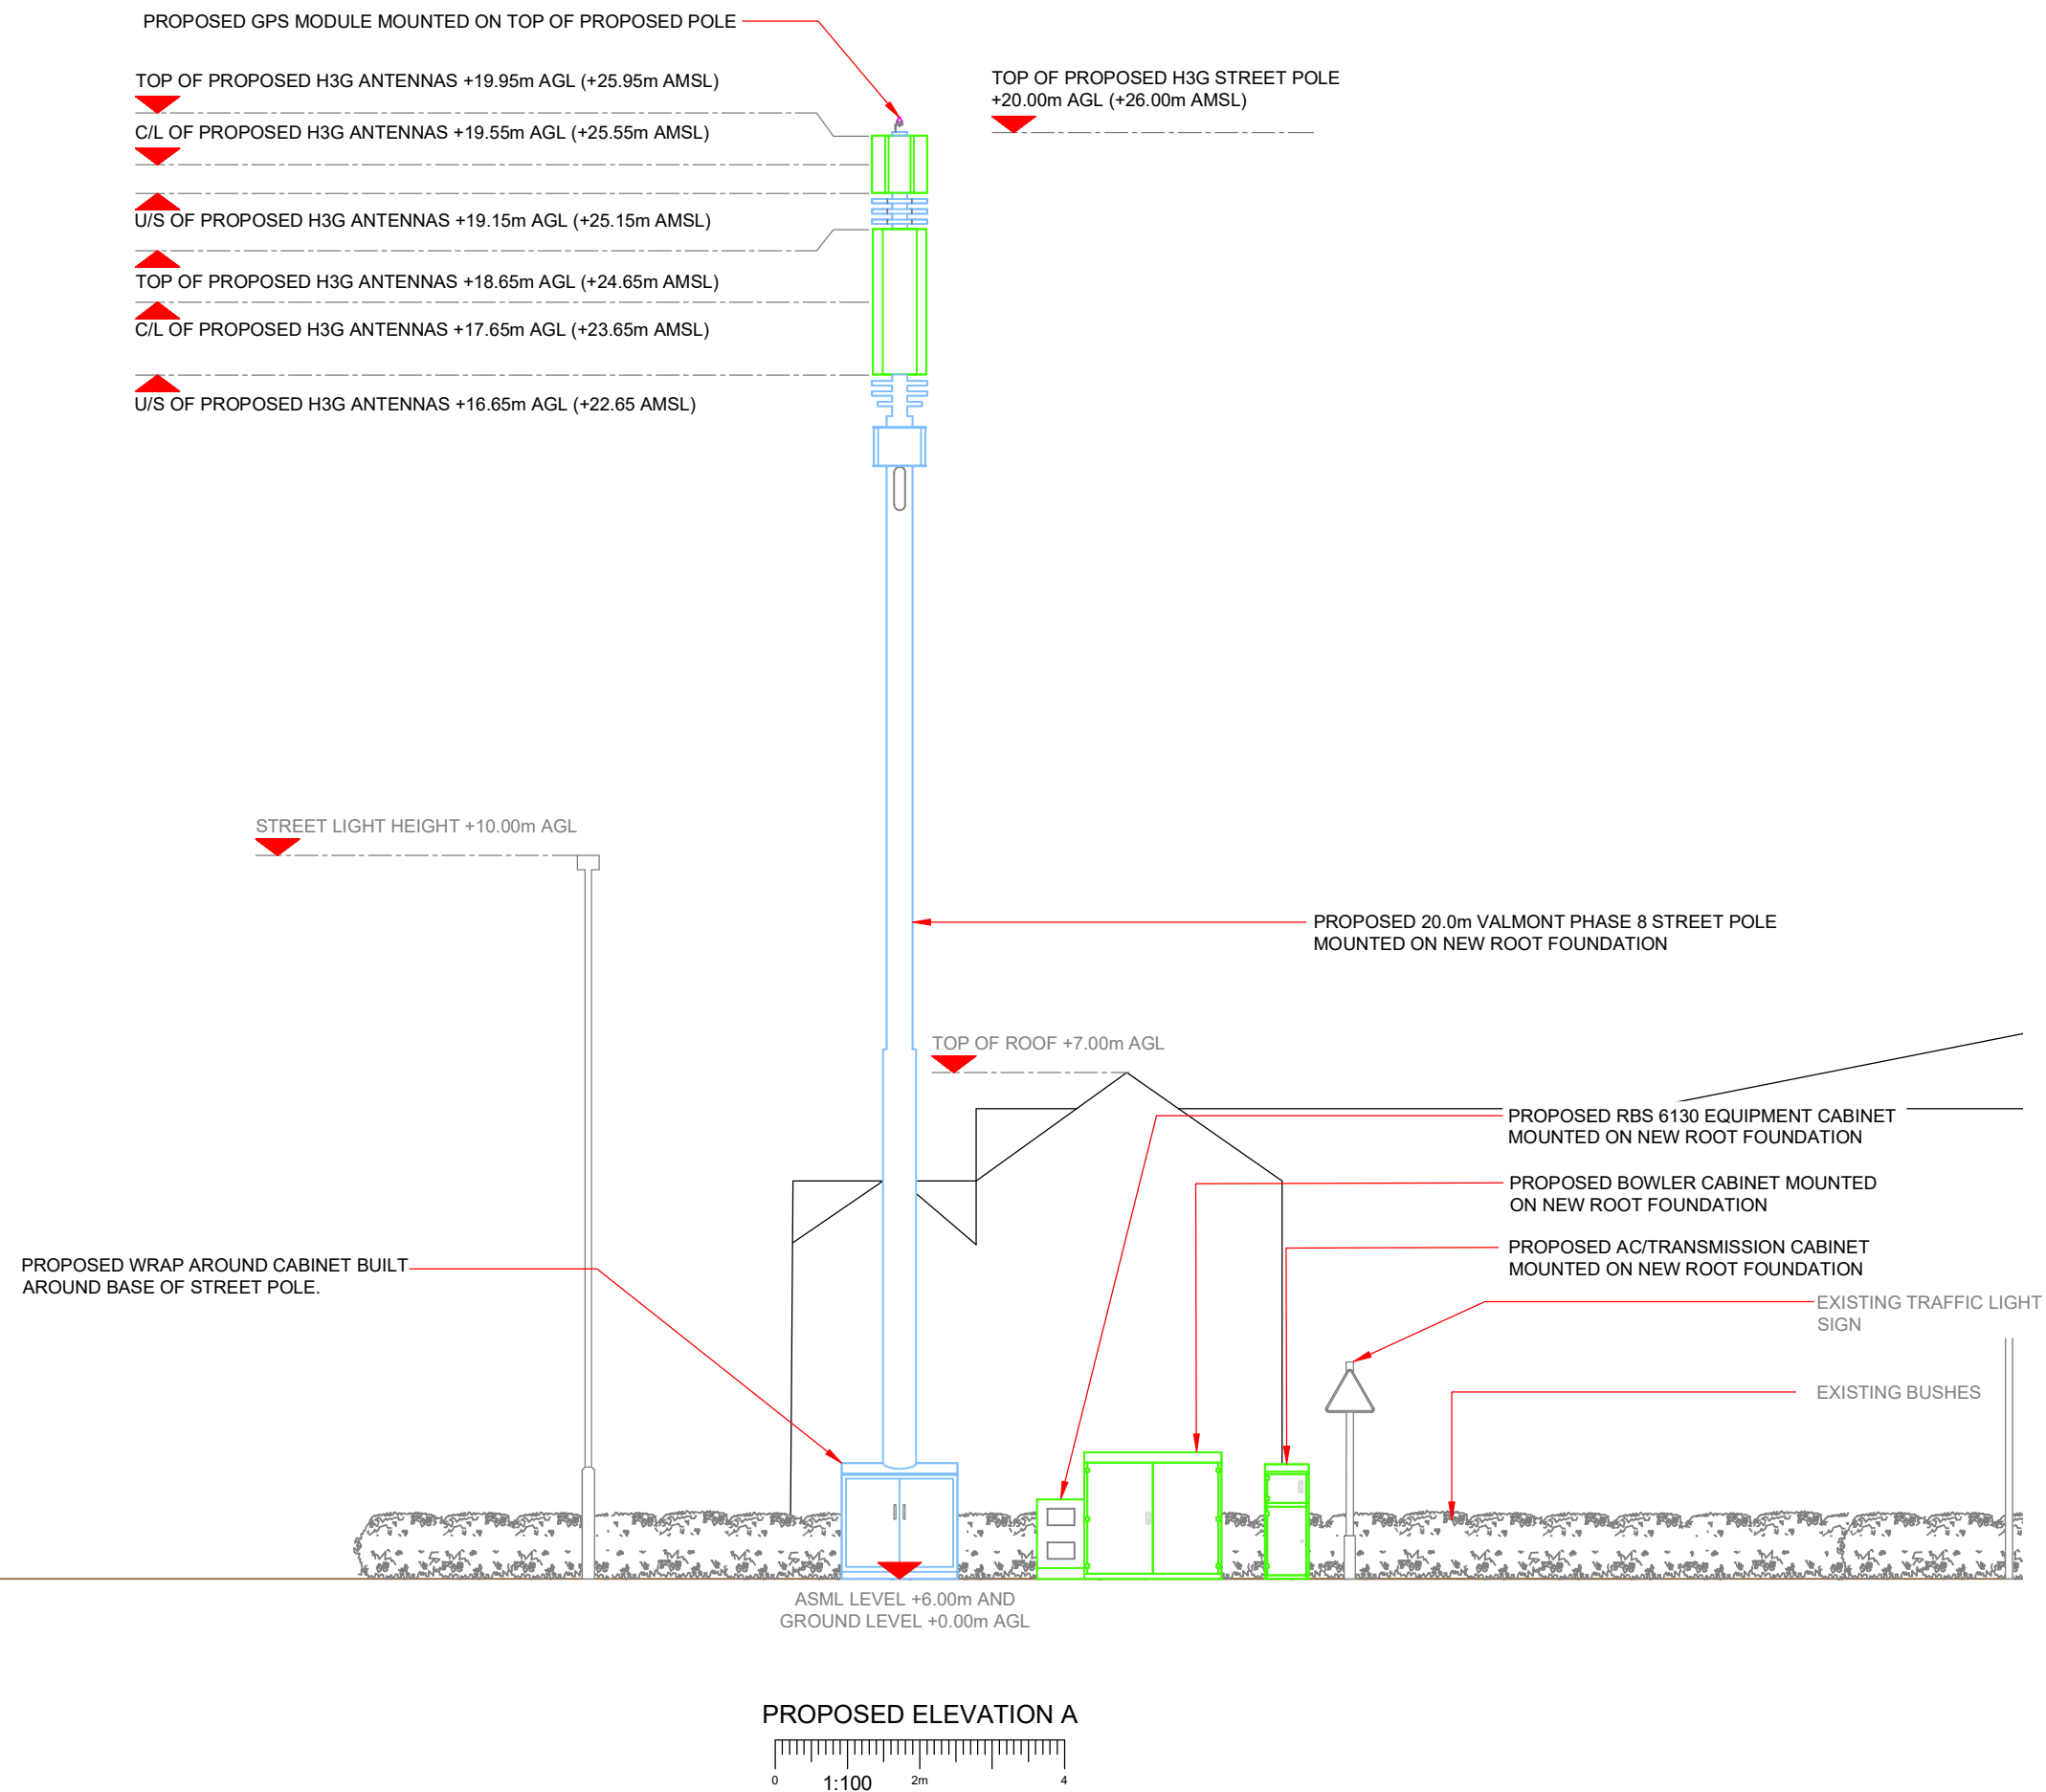

NOTES:

1. ALL DIMENSIONS IN MM UNLESS OTHERWISE NOTED.

Master:	MBNL / EE / H3G:	Project:	Purpose of Issue:	Issue:
M002	H3G	DENSIFICATION SW	Planning	B
Date:	06/10/2022	Revision / Upgrade Description: QR code and directions updated		
Drawn:	S.Booth			
Checked:	G.Thomas			
Approved:	G.Thomas			
Master:	MBNL / EE / H3G:	Project:	Purpose of Issue:	Issue:
M001	H3G	DENSIFICATION SW	Planning	A
Date:	15/09/2022	Revision / Upgrade Description: First Issue - Site nomination dated: TBC		
Drawn:	S.Booth			
Checked:	G.Thomas			
Approved:	G.Thomas			



Hutchison 3G UK Limited
Green Park, 450 Longwater Avenue
Reading, RG30 3UR
Tel: 01628 765 000
Fax: 01628 765 001

H3G Base Station Information line:
0845 6043000
Available 8am-8pm Monday to Friday

Design Consultant & Principal Contractor:



Unit E, Madison Place, Northampton Road,
Manchester, M40 5AG
Tel: 0161 785 4500 Fax: 0161 785 4501
Web: www.clarke-telecom.com

Site Name:

LANGSTONE ROAD

Site ID:

HVT25307

Address:

LANGSTONE ROAD
HAVANT
HAMPSHIRE
PO9 1RE

Title:

260 PROPOSED H3G SITE ELEVATION

Project:

H3G DENSIFICATION STREETWORKS

Purpose of Issue:	
-------------------	--

PLANNING

EE Cell ID:	MBNL Cell ID:	3UK Cell ID:
-	-	HVT25307

Master Drawing No:

HVT25307 B35 M002 H3G DNSW GA B

Issue: