


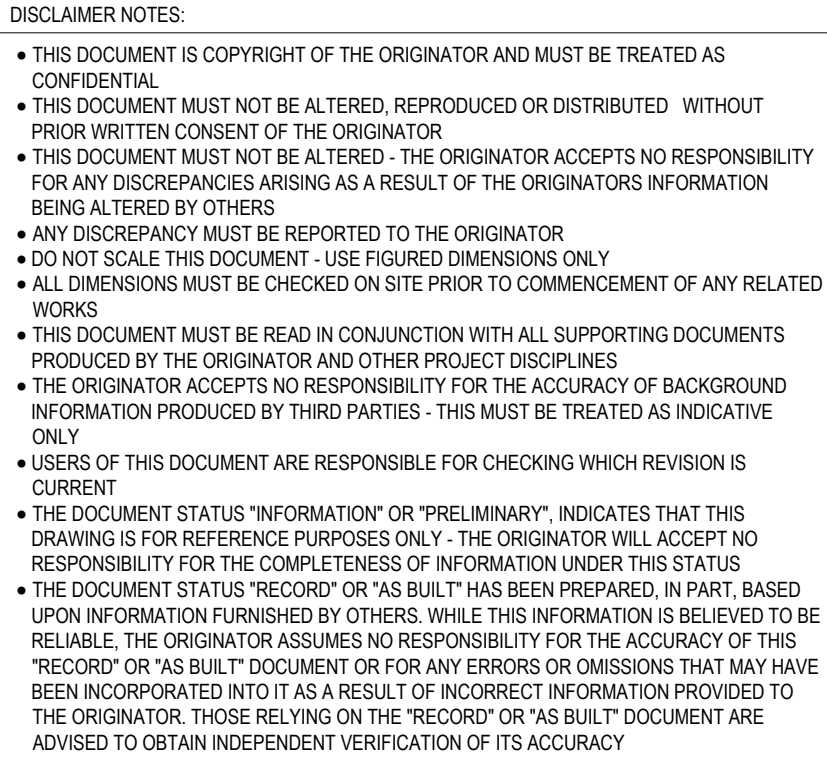

LEGEND

EXISTING SURFACE WATER DRAIN
 EXISTING FOUL WATER DRAIN
 PROPOSED SURFACE WATER DRAIN
 PROPOSED FOUL WATER DRAIN
 PROPOSED MANHOLE CHAMBER (1.2m DIA.)
 PROPOSED INSPECTION CHAMBER
 DEPTH > 600mm-450mm DIA.
 PROPOSED RODDING EYE
 PROPOSED RAIN WATER PIPE
 PROPOSED LINEAR CHAIN DRAIN
 PROPOSED FINISHED FLOOR LEVEL

P01	DOWNSTREAM DEFENDER ADDED	24/11/2022	TC
-	INITIAL ISSUE	11/02/2022	JM
REV	DESCRIPTION	DATE	DRAWN

RIDGE

PARTNERSHIP HOUSE
MOORSIDE ROAD
WINCHESTER
SO23 7RX

TEL: 01962 834400

WWW.RIDGE.CO.UK

CLIENT: **FED3 PROJECTS LIMITED**

IN ASSOCIATION WITH

PROJECT:
FRONTIER ESTATES
COWPLAIN SCHOOL

TITLE:
PROPOSED DRAINAGE LAYOUT
SHEET 2 of 2

TECH:	CSE:	ICSE:	SCALE: 1:100 @ A1
JM			INITIAL ISSUE: XX/02/2022

STATUS: **PLANNING**

DRAWING No:							
PROJECT:	ORG:	ZONE:	LEVEL:	TYPE:	ROLE:	NUMBER:	REV:
5017735	RDG	XX	ST	DR	C	0501	P01