
 

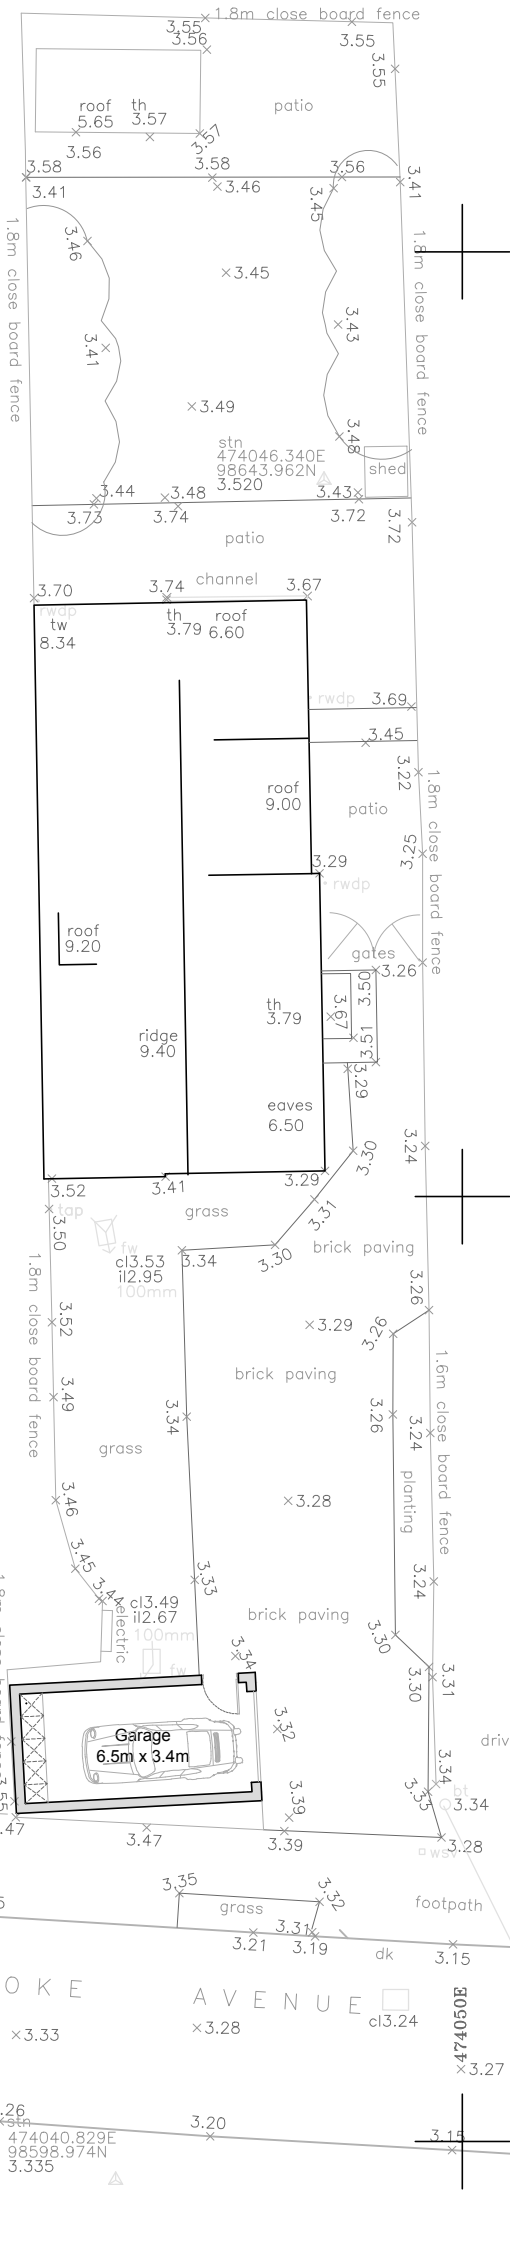

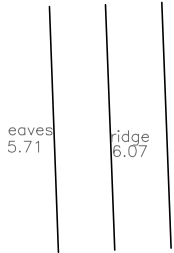
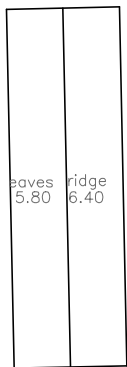


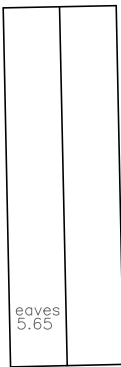

kyt	
bt	British Telecom
cb	Control Box
cl	Control Level
ctv	Cable Television
dk	Draco Kerns
el	Electric
ep	Electricity Pole
fh	Fire Hydrant
gu	Gully
gv	Gas Stop Valve
ht	Height
ic	Inspection Cover
il	Invert Level
lp	Lamp Post
mkr	Marker
o/h	Overhead
psb	Post Box
pbg	Prawn Crossing
pn	Name Plate
rs	Road Sign
st	Stop Valve
tb	Telephone Box
tl	Traffic Light
tt	Top of Tree
th	Threshold
to	Top of Wall
utl	Unable to Lift
vp	Vent pipe
wn	Water Meter
wsv	Water Stop Valve

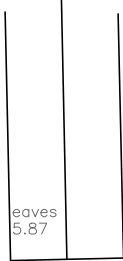

× 3.09

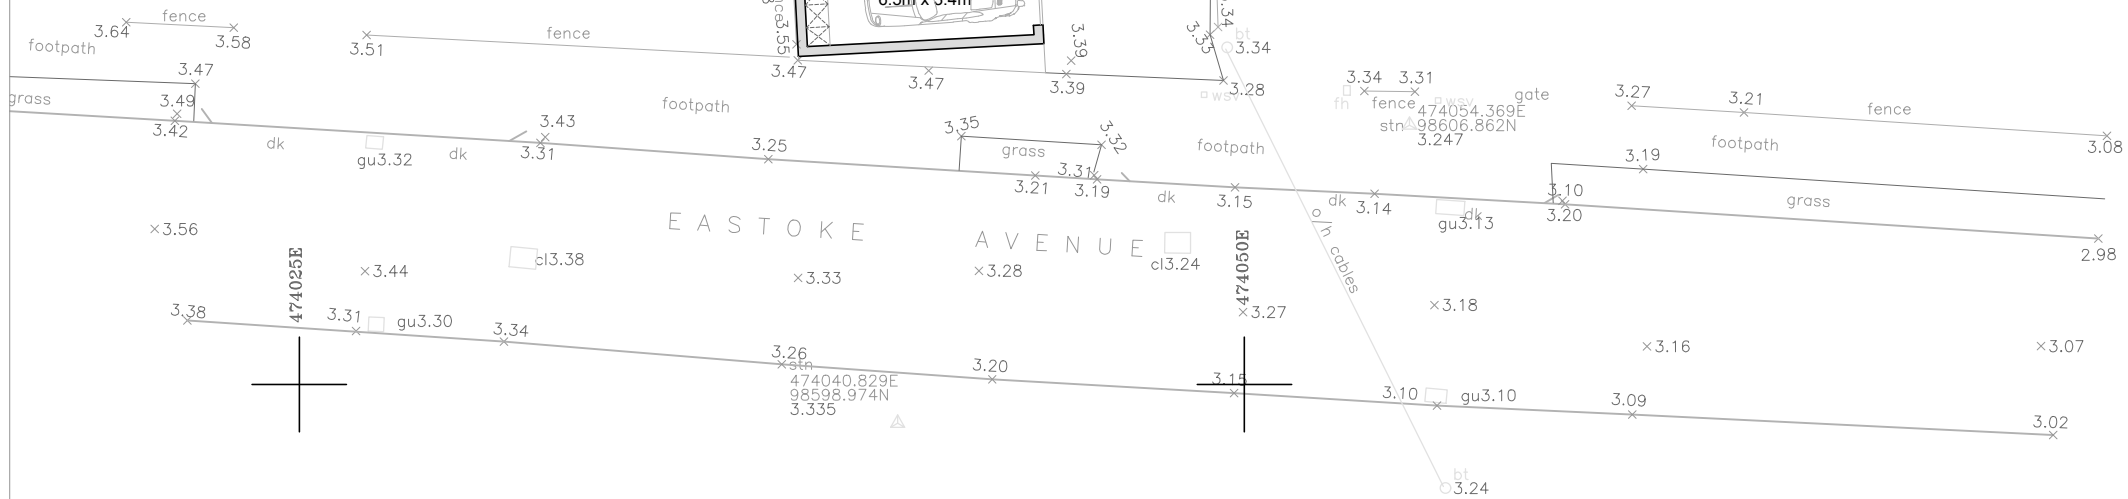

Copyright: All rights reserved.
This drawing and design must not be reproduced without permission
Dimensions are in millimetres unless specified

Job title
81 Eastoke Avenue

Drawing title
Proposed Site Plan

Status
Planning

DWG No.	Revision	Date	Scale at A3	Scale at A2
P003	-	Aug 21	1:200	-