



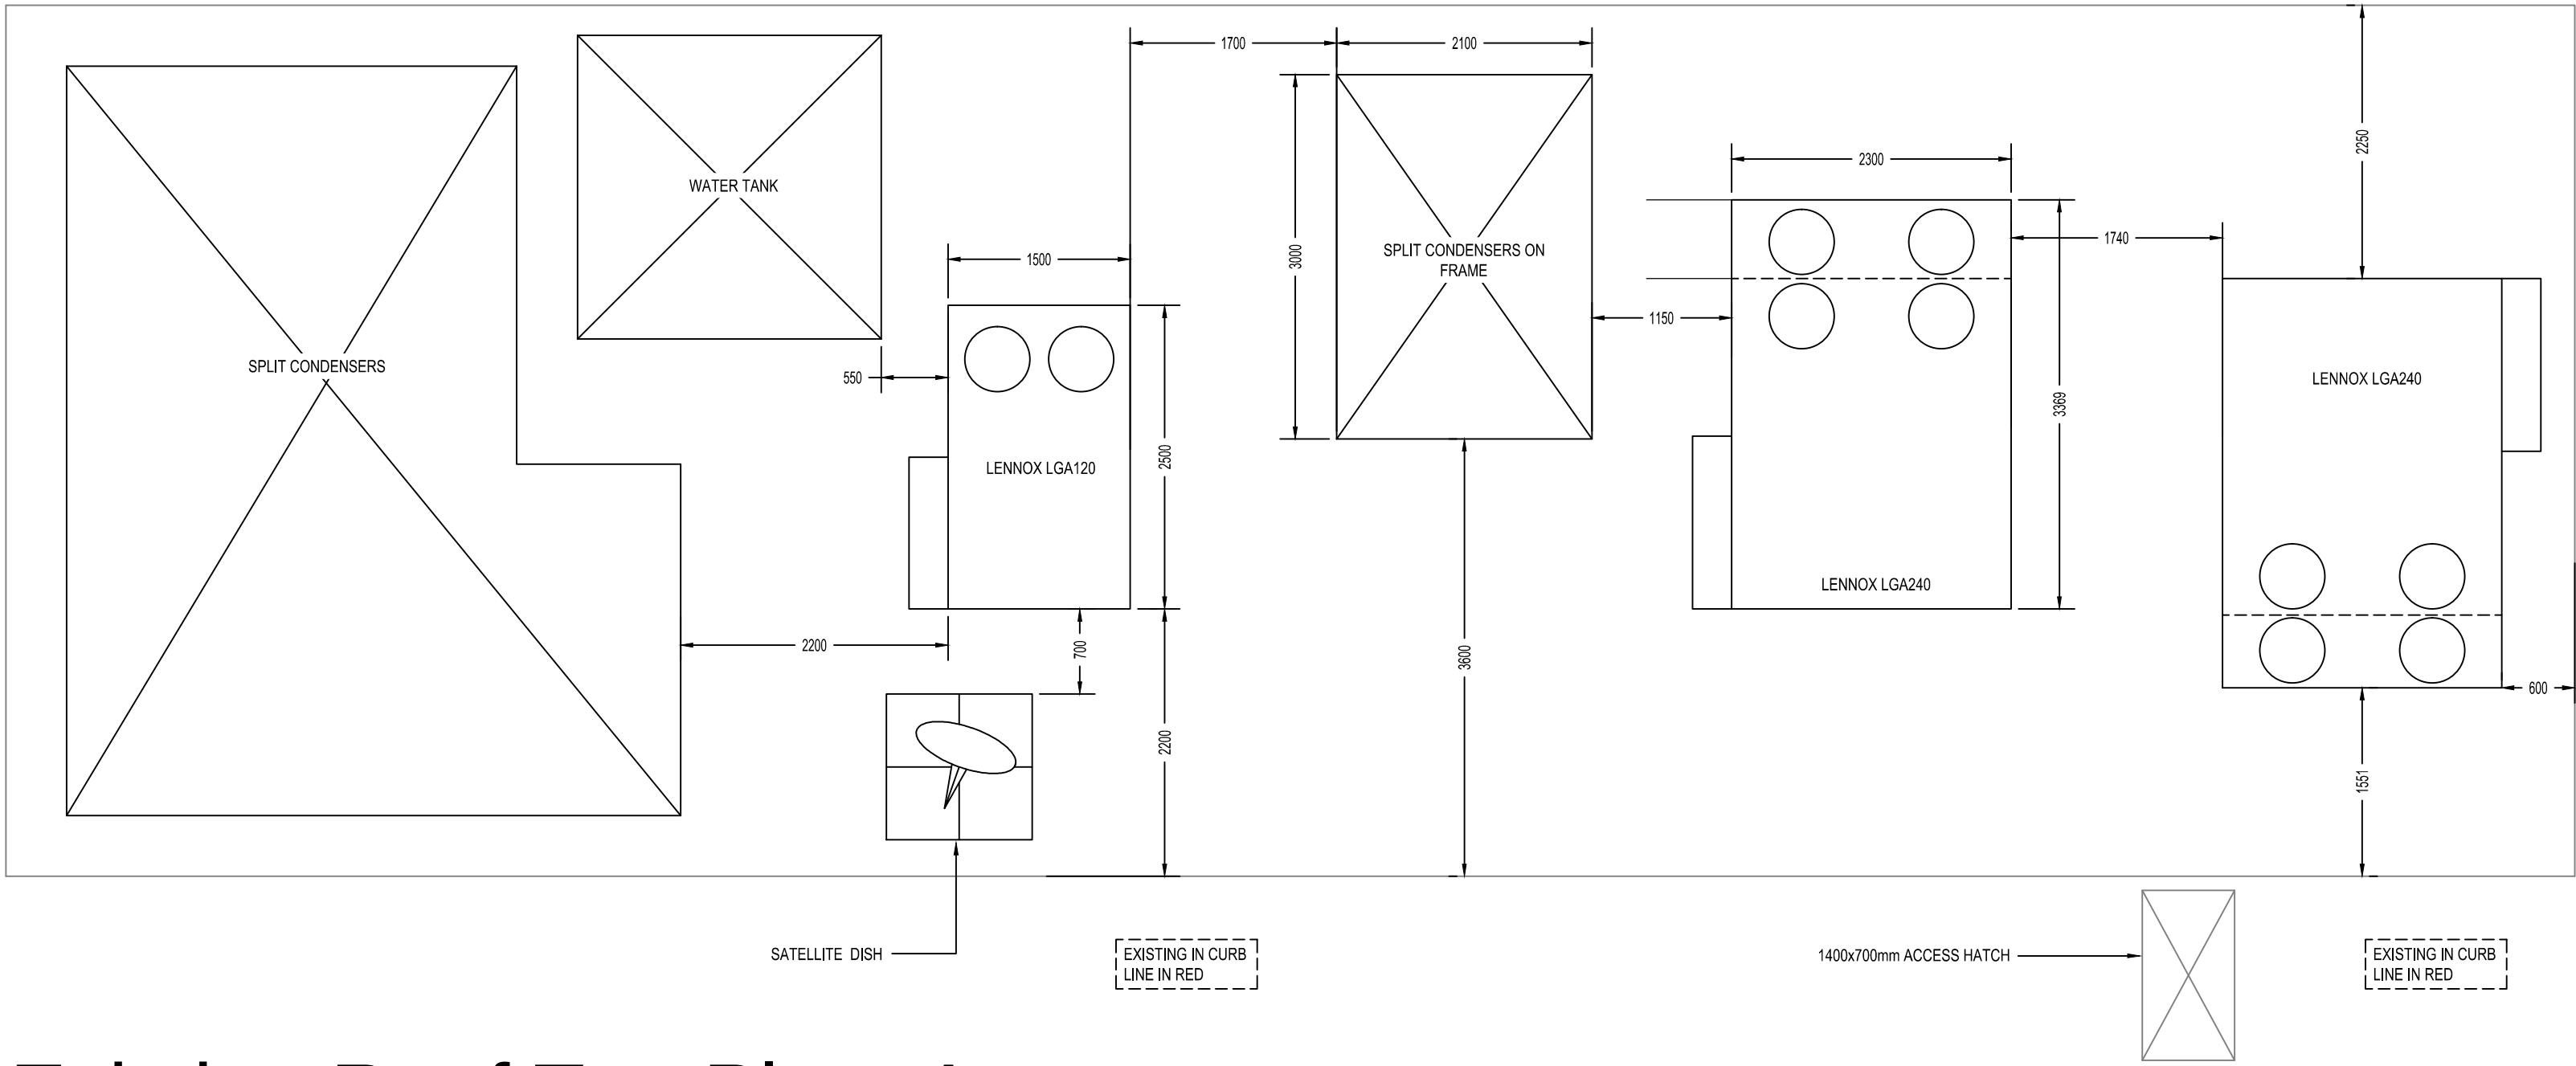

Existing Roof Top Plant Area

0 1 2 3 4 5m


EXISTING ROOF PLAN
1:50 Scale

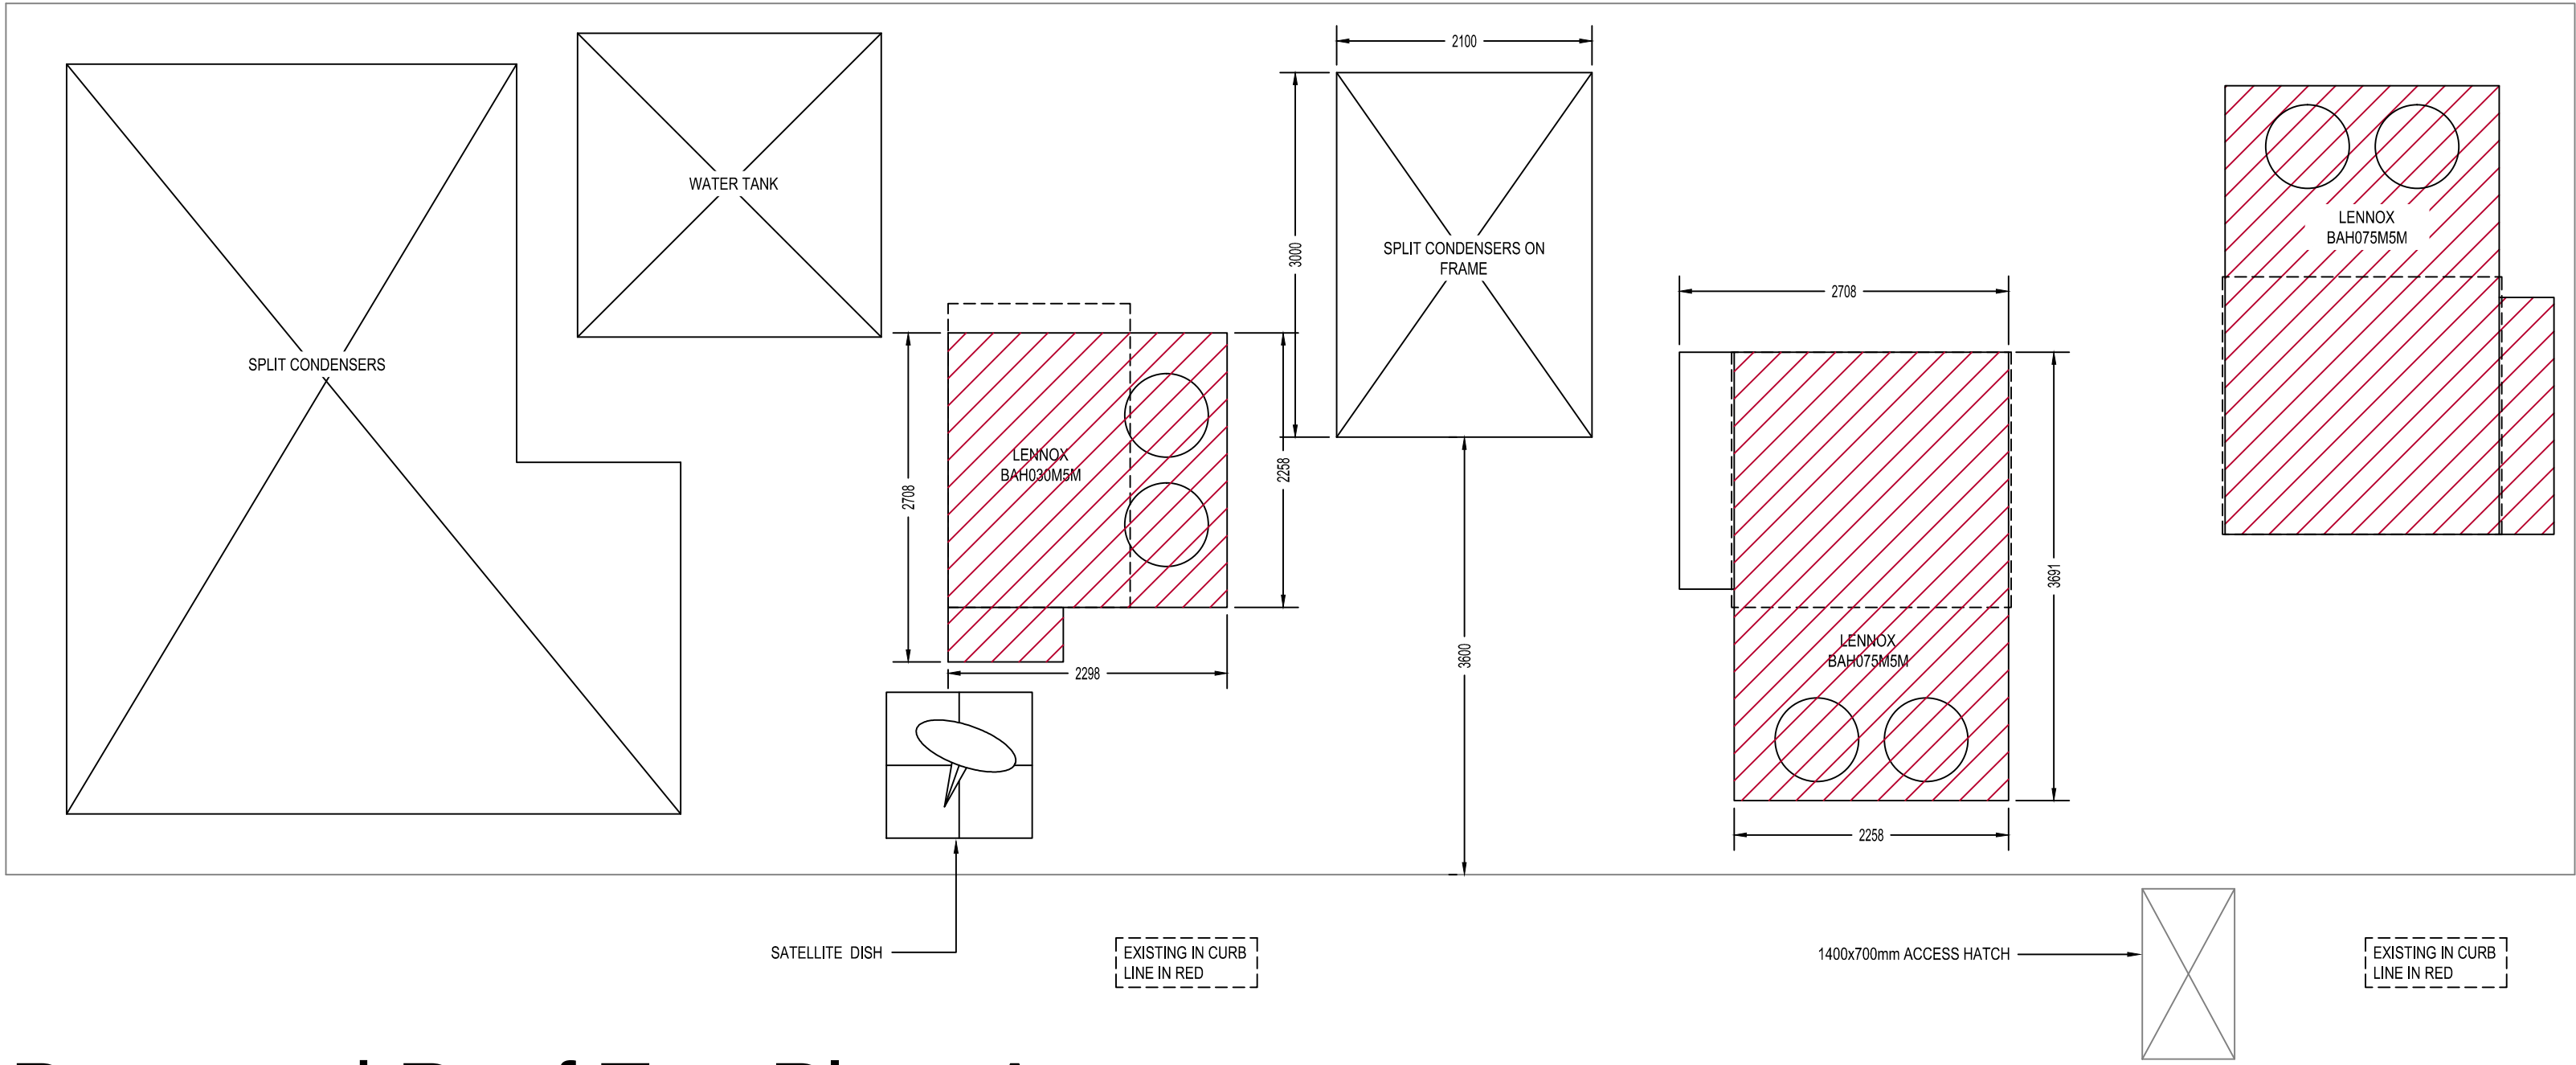

Proposed Roof Top Plant Area


0 1 2 3 4 5m

Replacement units shaded

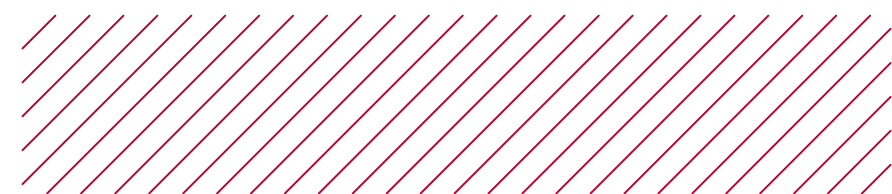


PROPOSED ROOF PLAN
1:50 Scale

NOTES
THIS DRAWING IS PROTECTED UNDER COPYRIGHT AND MUST NOT BE REPRODUCED WITHOUT THE PERMISSION OF TURN KEY AIR CONDITIONING
ALL DIMENSIONS MUST BE CHECKED ON SITE AND NOT SCALED FROM THIS DRAWING

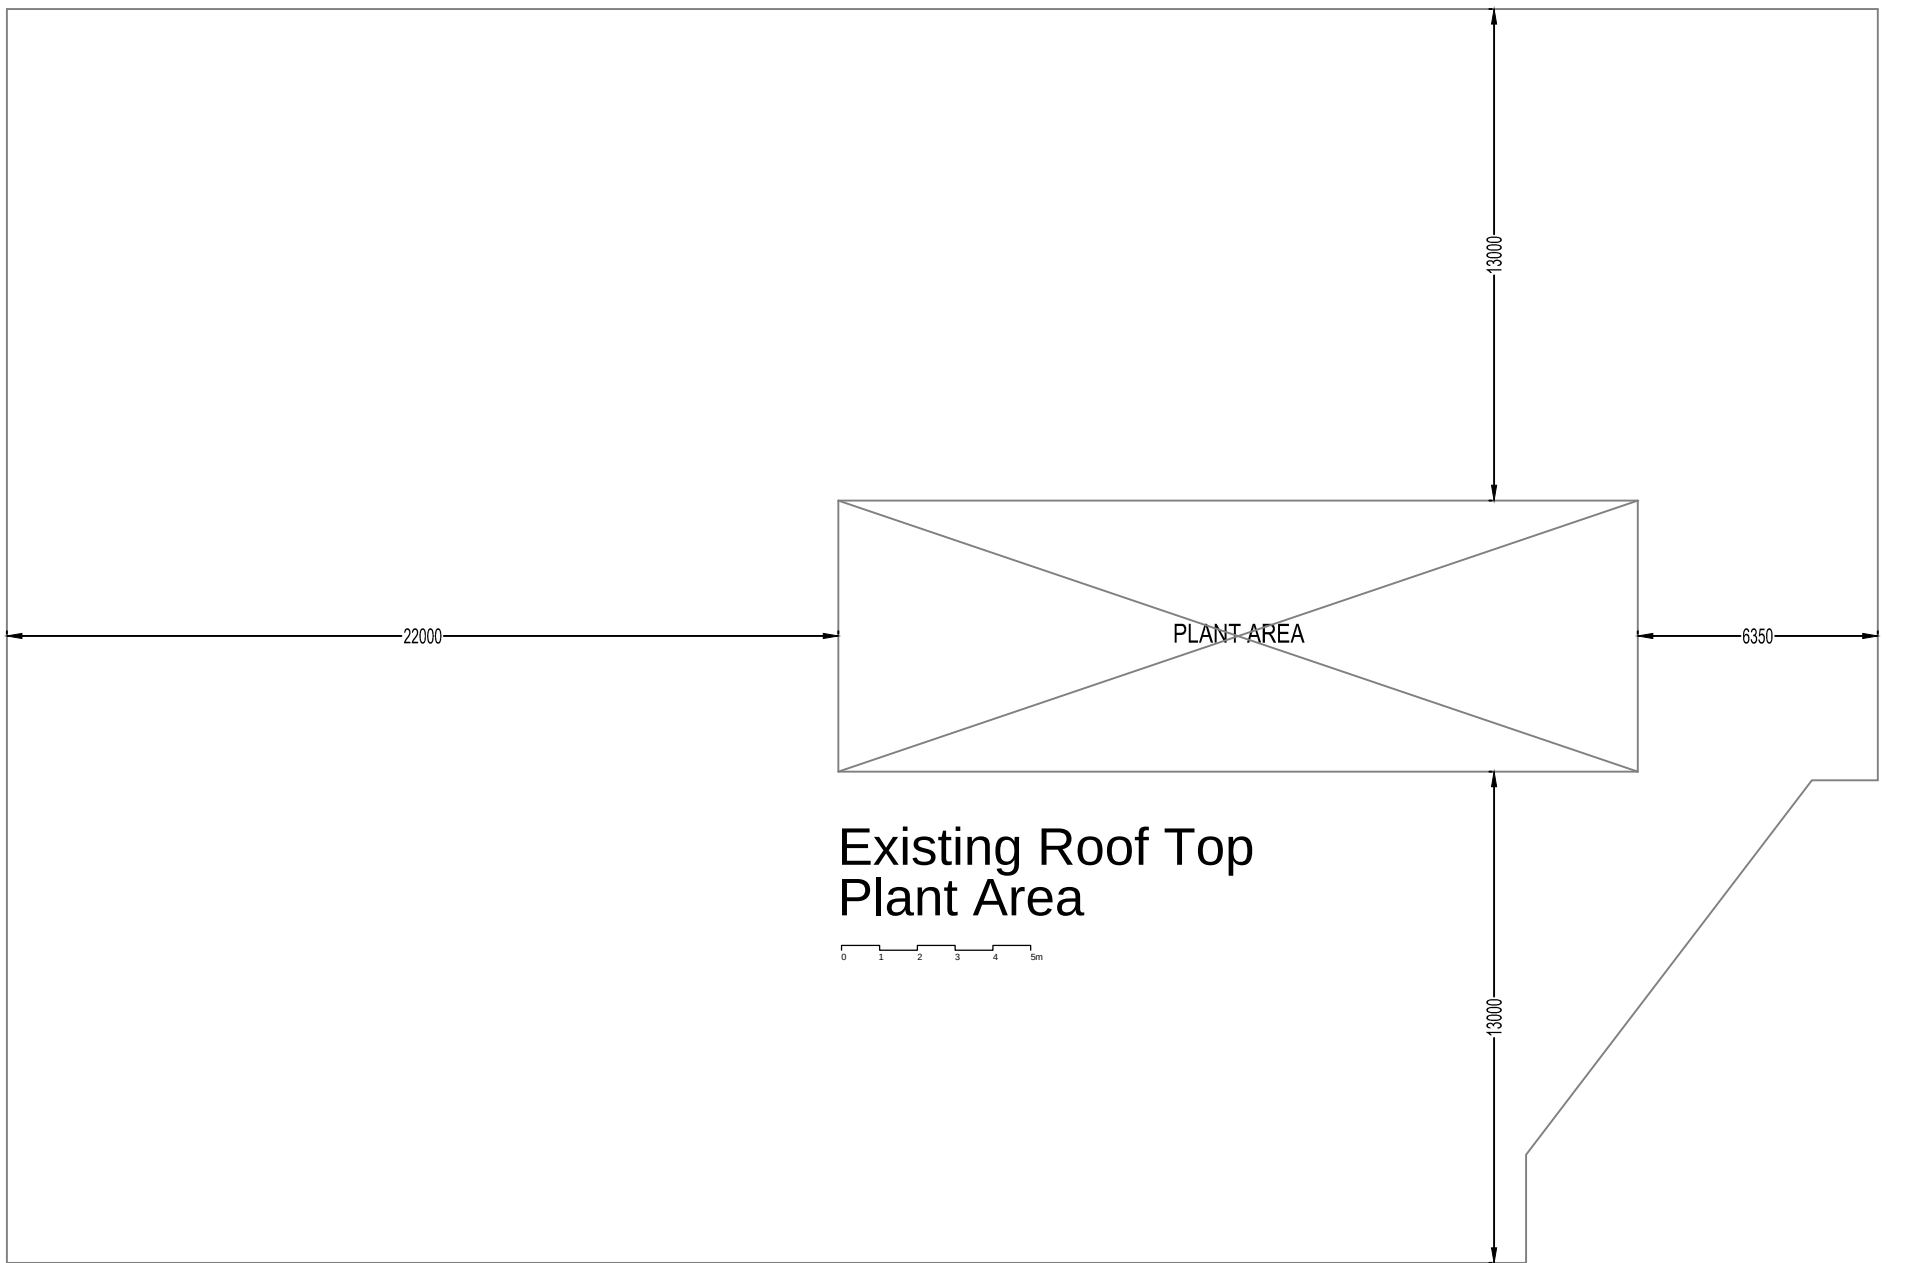


ROOF PLAN
1:200 Scale

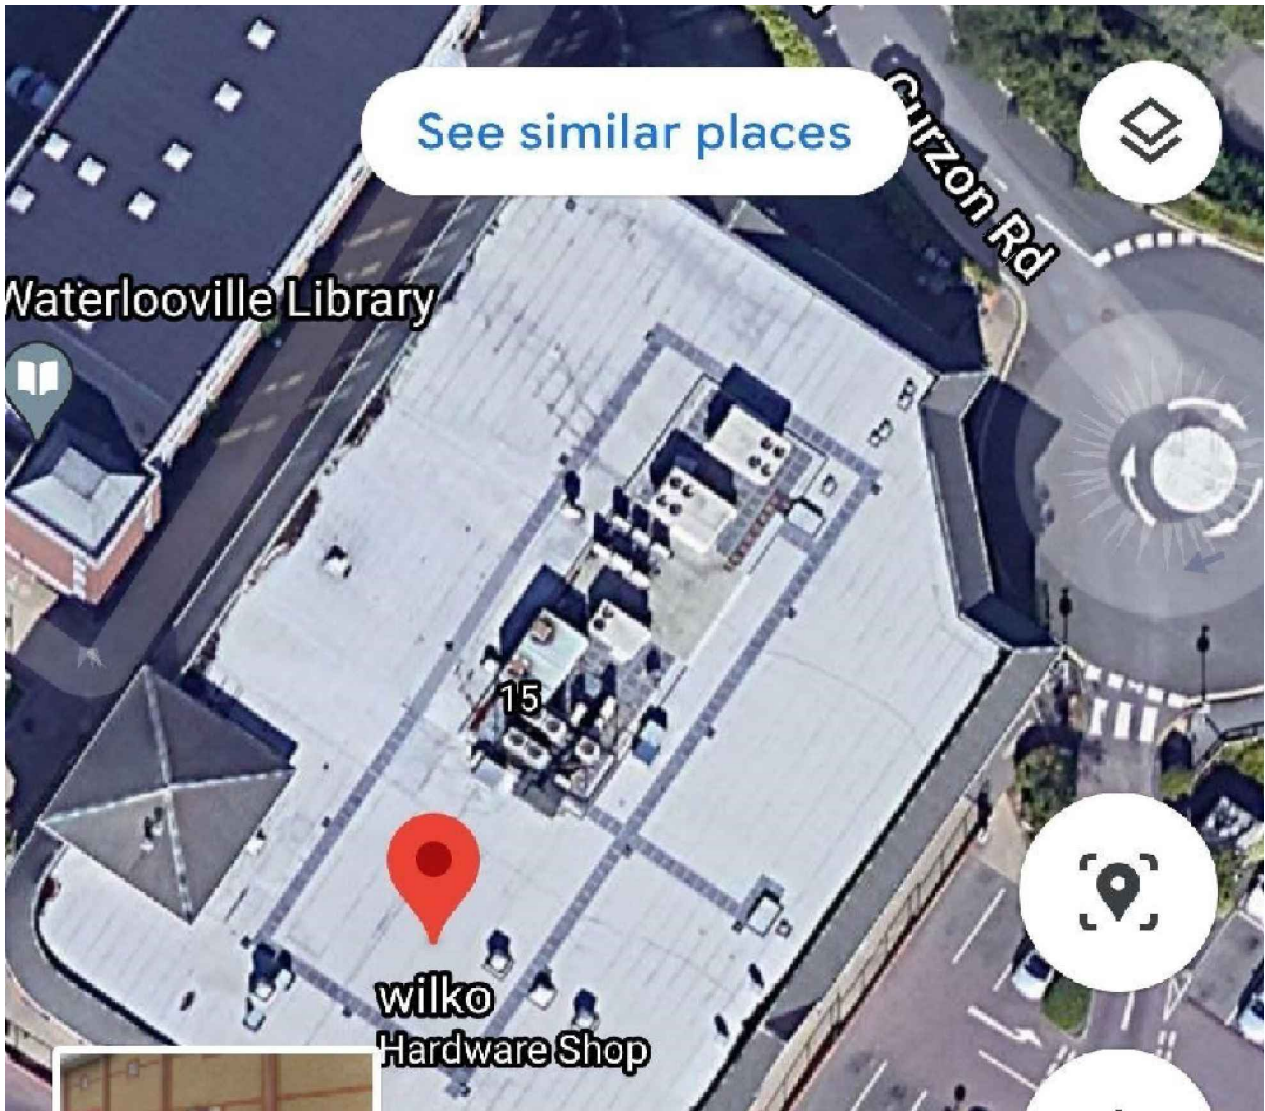

Rev	Date	Revision
B	10.05.21	New units shown hatched
A	15.03.21	Satellite View of Roof Added

PROPOSED

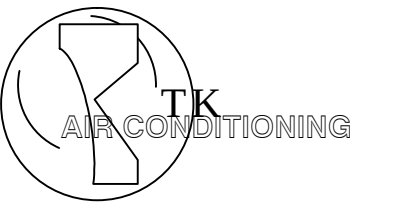

TURN KEY AIR CONDITIONING LTD

2 Apollo Court
Monkton Business Park
TYNE & WEAR
NE31 2ES

Telephone 0191 438 7410
Fax 0191 438 6001
Email office@tkac.co.uk
Web www.tkac.co.uk

Project
Wilko
Waterlooville

Drawing Title
Replacement Lennox Rooftop Units
Existing & Proposed Roof Layout

Date	Scale	Drawn By
10/03/21	1:50 / 1/200 @ A1	AJ

Drawing No.	Rev
C9311-101	B

	UNIT DIMENSIONS & WEIGHTS			
	LENNOX LGA240	REPLACEMENT LENNOX BAH075M5M	LENNOX LGA120	REPLACEMENT LENNOX BAH030M5M
LENGTH (MM)	3369	3691	2521	2298
WIDTH (MM)	2289	2258	1473	2258
HEIGHT (MM)	1378	1263	1270	1263
WEIGHT (KG)	1336	1300	666	720
NOISE SWL (dBA)	83	81.3	81	80.4