


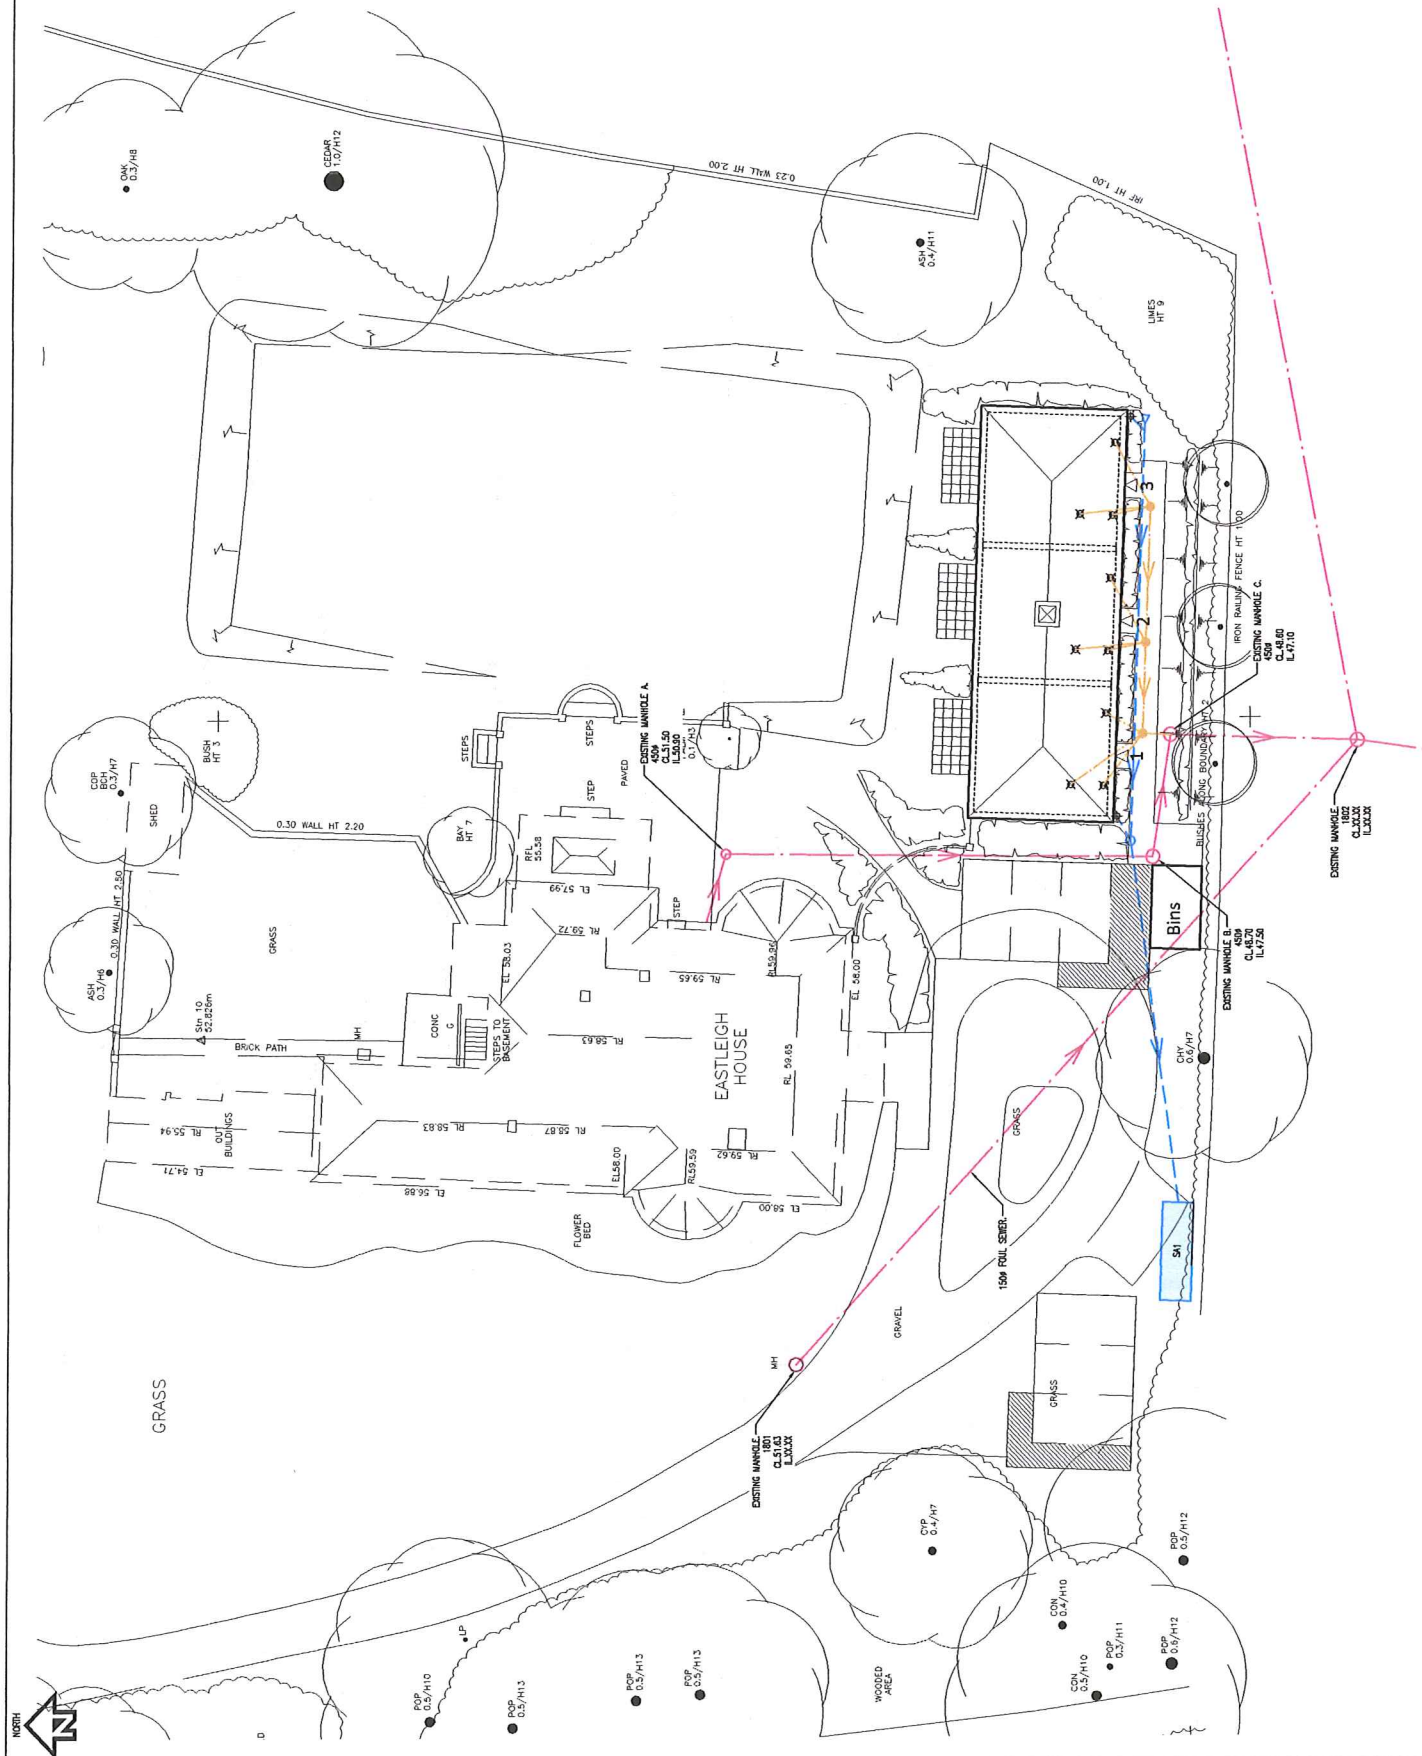

 HDL HAMIL DAVIES LIMITED Consulting Civil and Structural Engineers	1001 WALTHAM LIMITED PO BOX EASTLEIGH HOUSE, HAWAII ELEVING TON		PROPOSED DRAINAGE LAYOUT	
	Name PRELIMINARY	Drawn: HCL Designed	Date 11/125 @ A1	Drawing Number 2D-3566-501 P1