
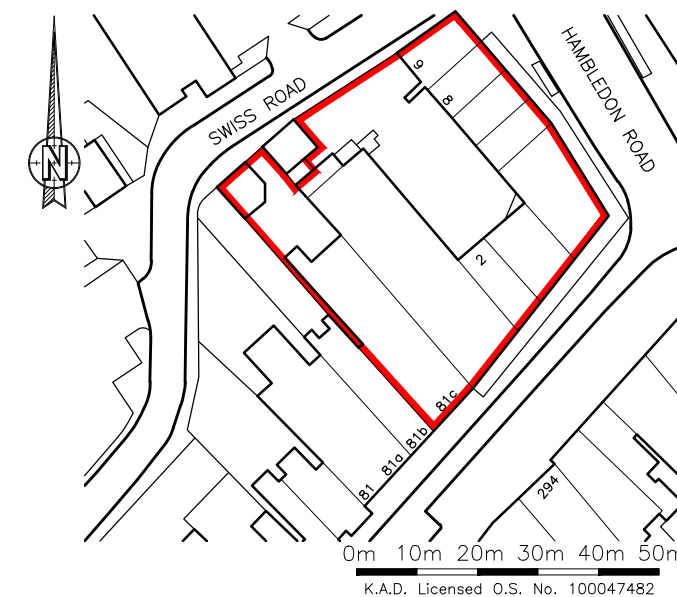


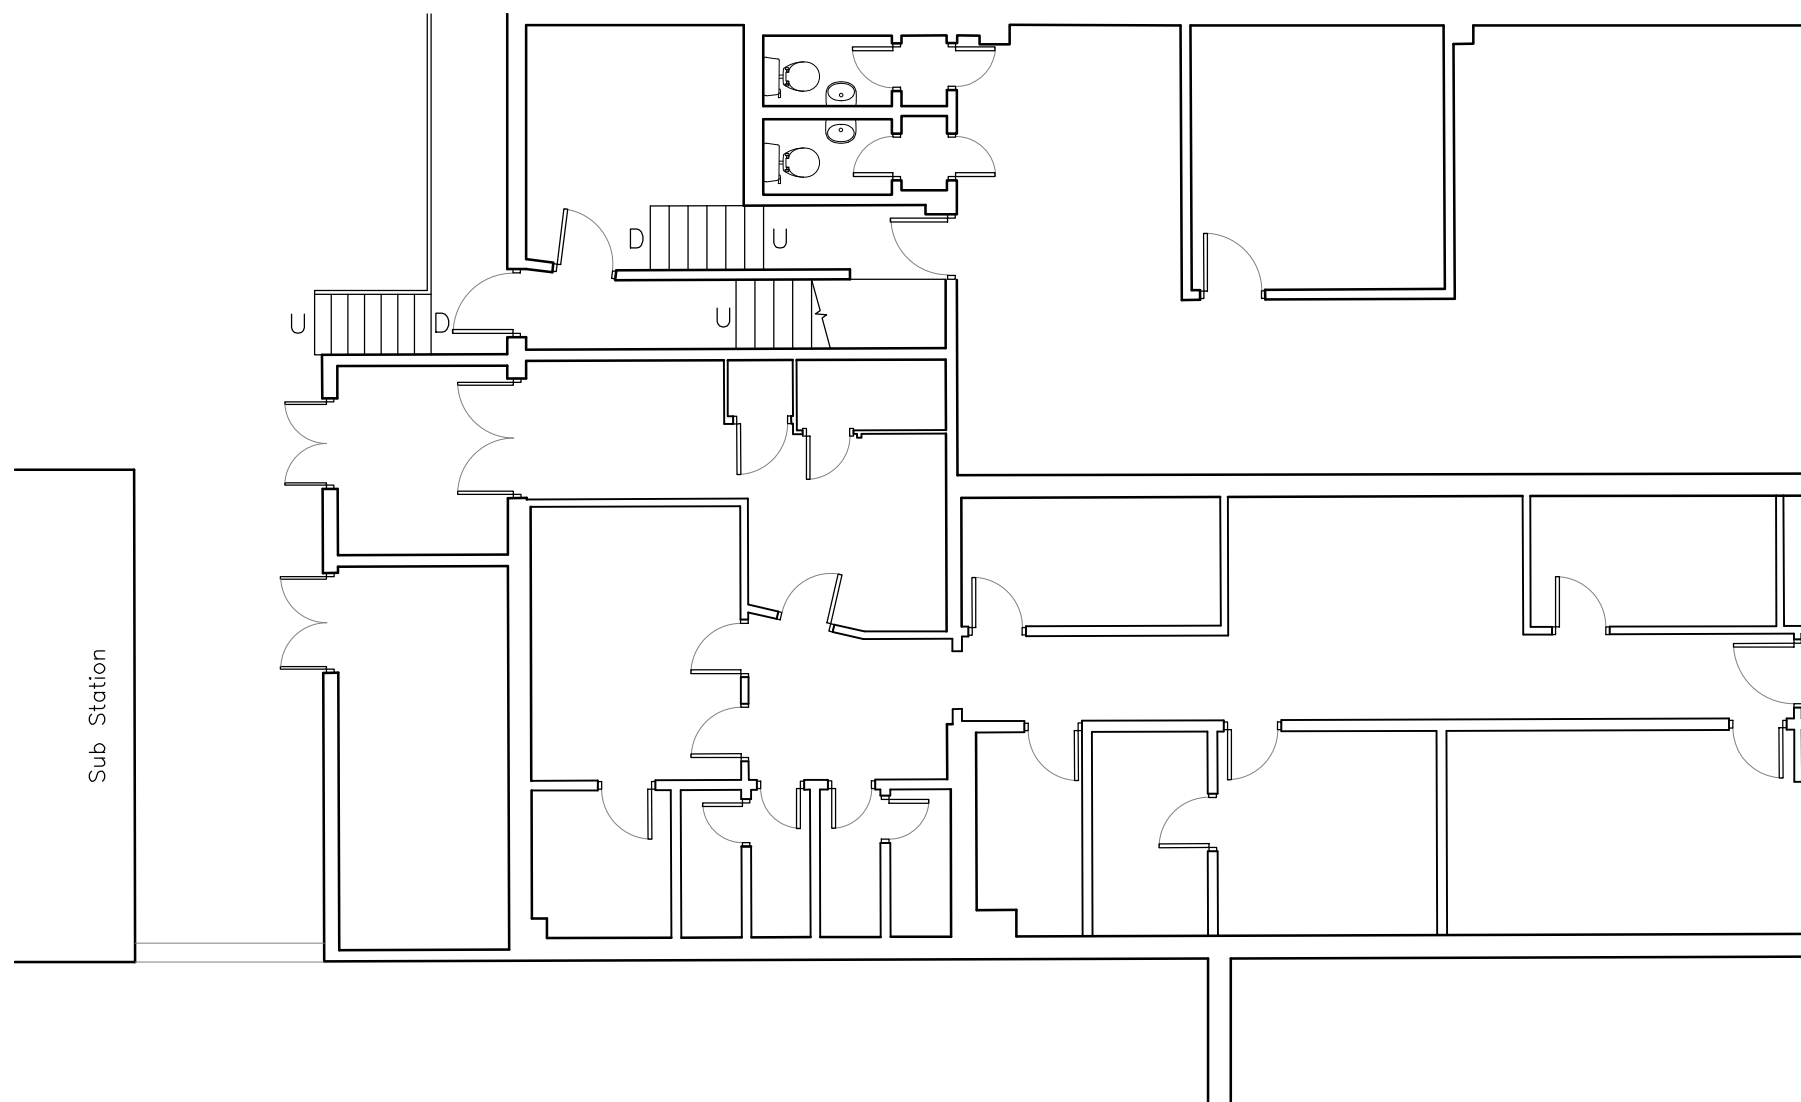

Rev	Revision						By	Date

K NIGHT ARCHITECTURAL DESIGN

K.A.D. Ltd.
First Floor Unit 7
The Quarterdeck
Port Solent
PO6 4TP

T: 01489 660194
E: admin@k-a-d.co.uk
W: www.k-a-d.co.uk

Client

W D KING GROUP

Project

UNIT 1 CLOCKHOUSE
WATERLOOVILLE
PO7 7HE

Drawing

EXISTING FLOOR PLAN

Scale 1:100@A3	Date DEC 2021
---	--

Project no.	Sequential	Bldg/Floor	Detail	Rev
KAD	01	A	EX	.