


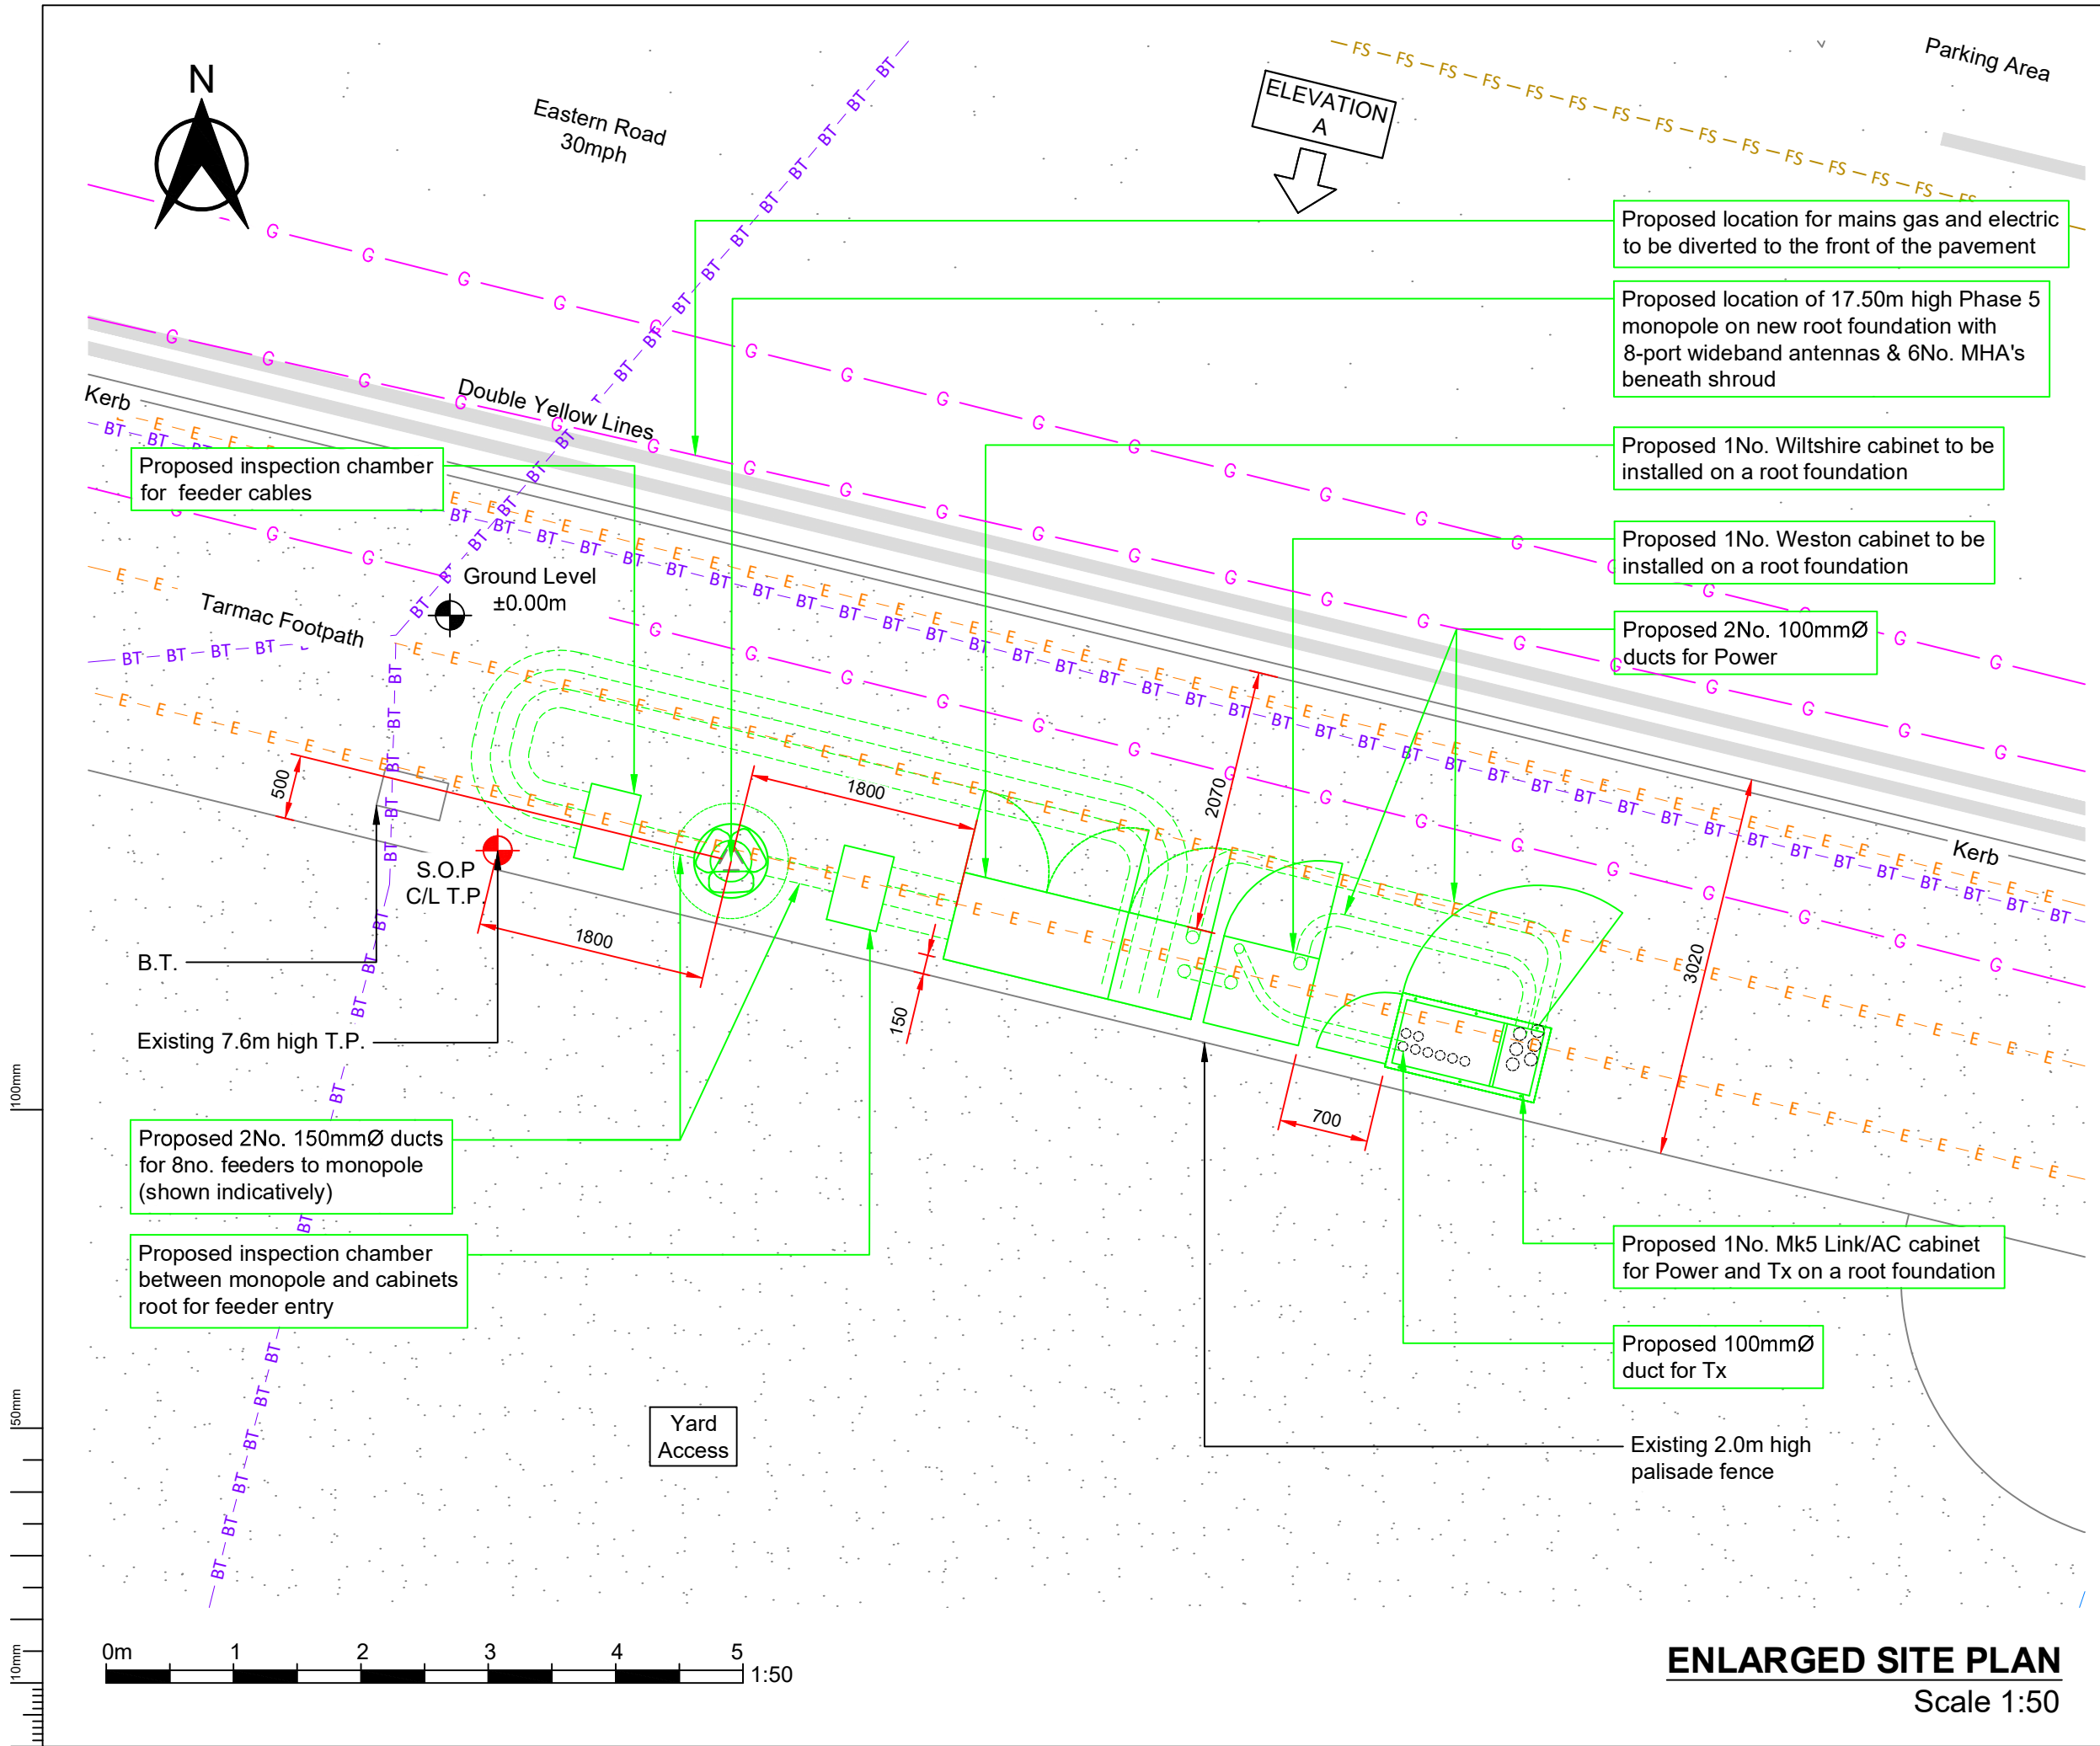

NOTES:

- DRAWING TO BE READ IN CONJUNCTION WITH ALL RELEVANT DRAWINGS AND SPECIFICATIONS
- ALL DIMENSIONS ARE IN MILLIMETRES UNLESS OTHERWISE STATED
- DO NOT SCALE DRAWINGS, ALL DIMENSION TO BE CHECKED ON SITE
- DUCT ROUTES ARE SHOWN INDICATIVELY, ACTUAL ROUTES TO BE DETERMINED ON SITE
- ALL DISCREPANCIES TO BE REPORTED TO THE DESIGN ENGINEER

KEY

INDICATES PROPOSED EE EQUIPMENT

NOTES:

GAS — G — G — G —

WATER — W — W — W — W — W — W —

BT — BT — BT — BT — BT — BT — BT —

ELECTRICITY — E — E — E — E — E — E —

VIRGIN — V — V — V — V — V — V — V —

BT OVERHEAD — BTO — BTO — BTO — BTO —

FOUL SEWER — FS — FS — FS — FS — FS — FS —

CENTURY LINK — ITM — ITM — ITM — ITM — ITM —

UNKNOWN SERVICE — EM —

A2	LOCATION AMEND	26.07.21	KS	RC
A1	FIRST ISSUE	20.05.21	JDS	RC
Issue	Comment	Date	Drawn	Approved



BEACONCOMMS

UNIT E3 PITTS CLEAVE INDUSTRIAL ESTATE, TAVISTOCK, DEVON, PL19 0PW
sales@beaconcomms.co.uk Tel: +44 (0)1822 610610

Site Name & Address:

EASTERN ROAD SW
EASTERN ROAD,
HAVANT
HAMPSHIRE
PO9 2QZ

Title:

**UNDERGROUND
SERVICES &
LAYOUT**

Purpose of Issue:

NEW SITE DESIGN

Drawing No:

71224_EASTERN ROAD SW_005

Host Cell ID:

71224

Issue:	Scale at A3:	Checked:	Date:
A2	AS SHOWN	SB	26.07.21
Drawn:	Date:	Approved:	Date:
KS	26.07.21	RC	26.07.21

Beacon ref: XXXX

ENLARGED SITE PLAN
Scale 1:50